


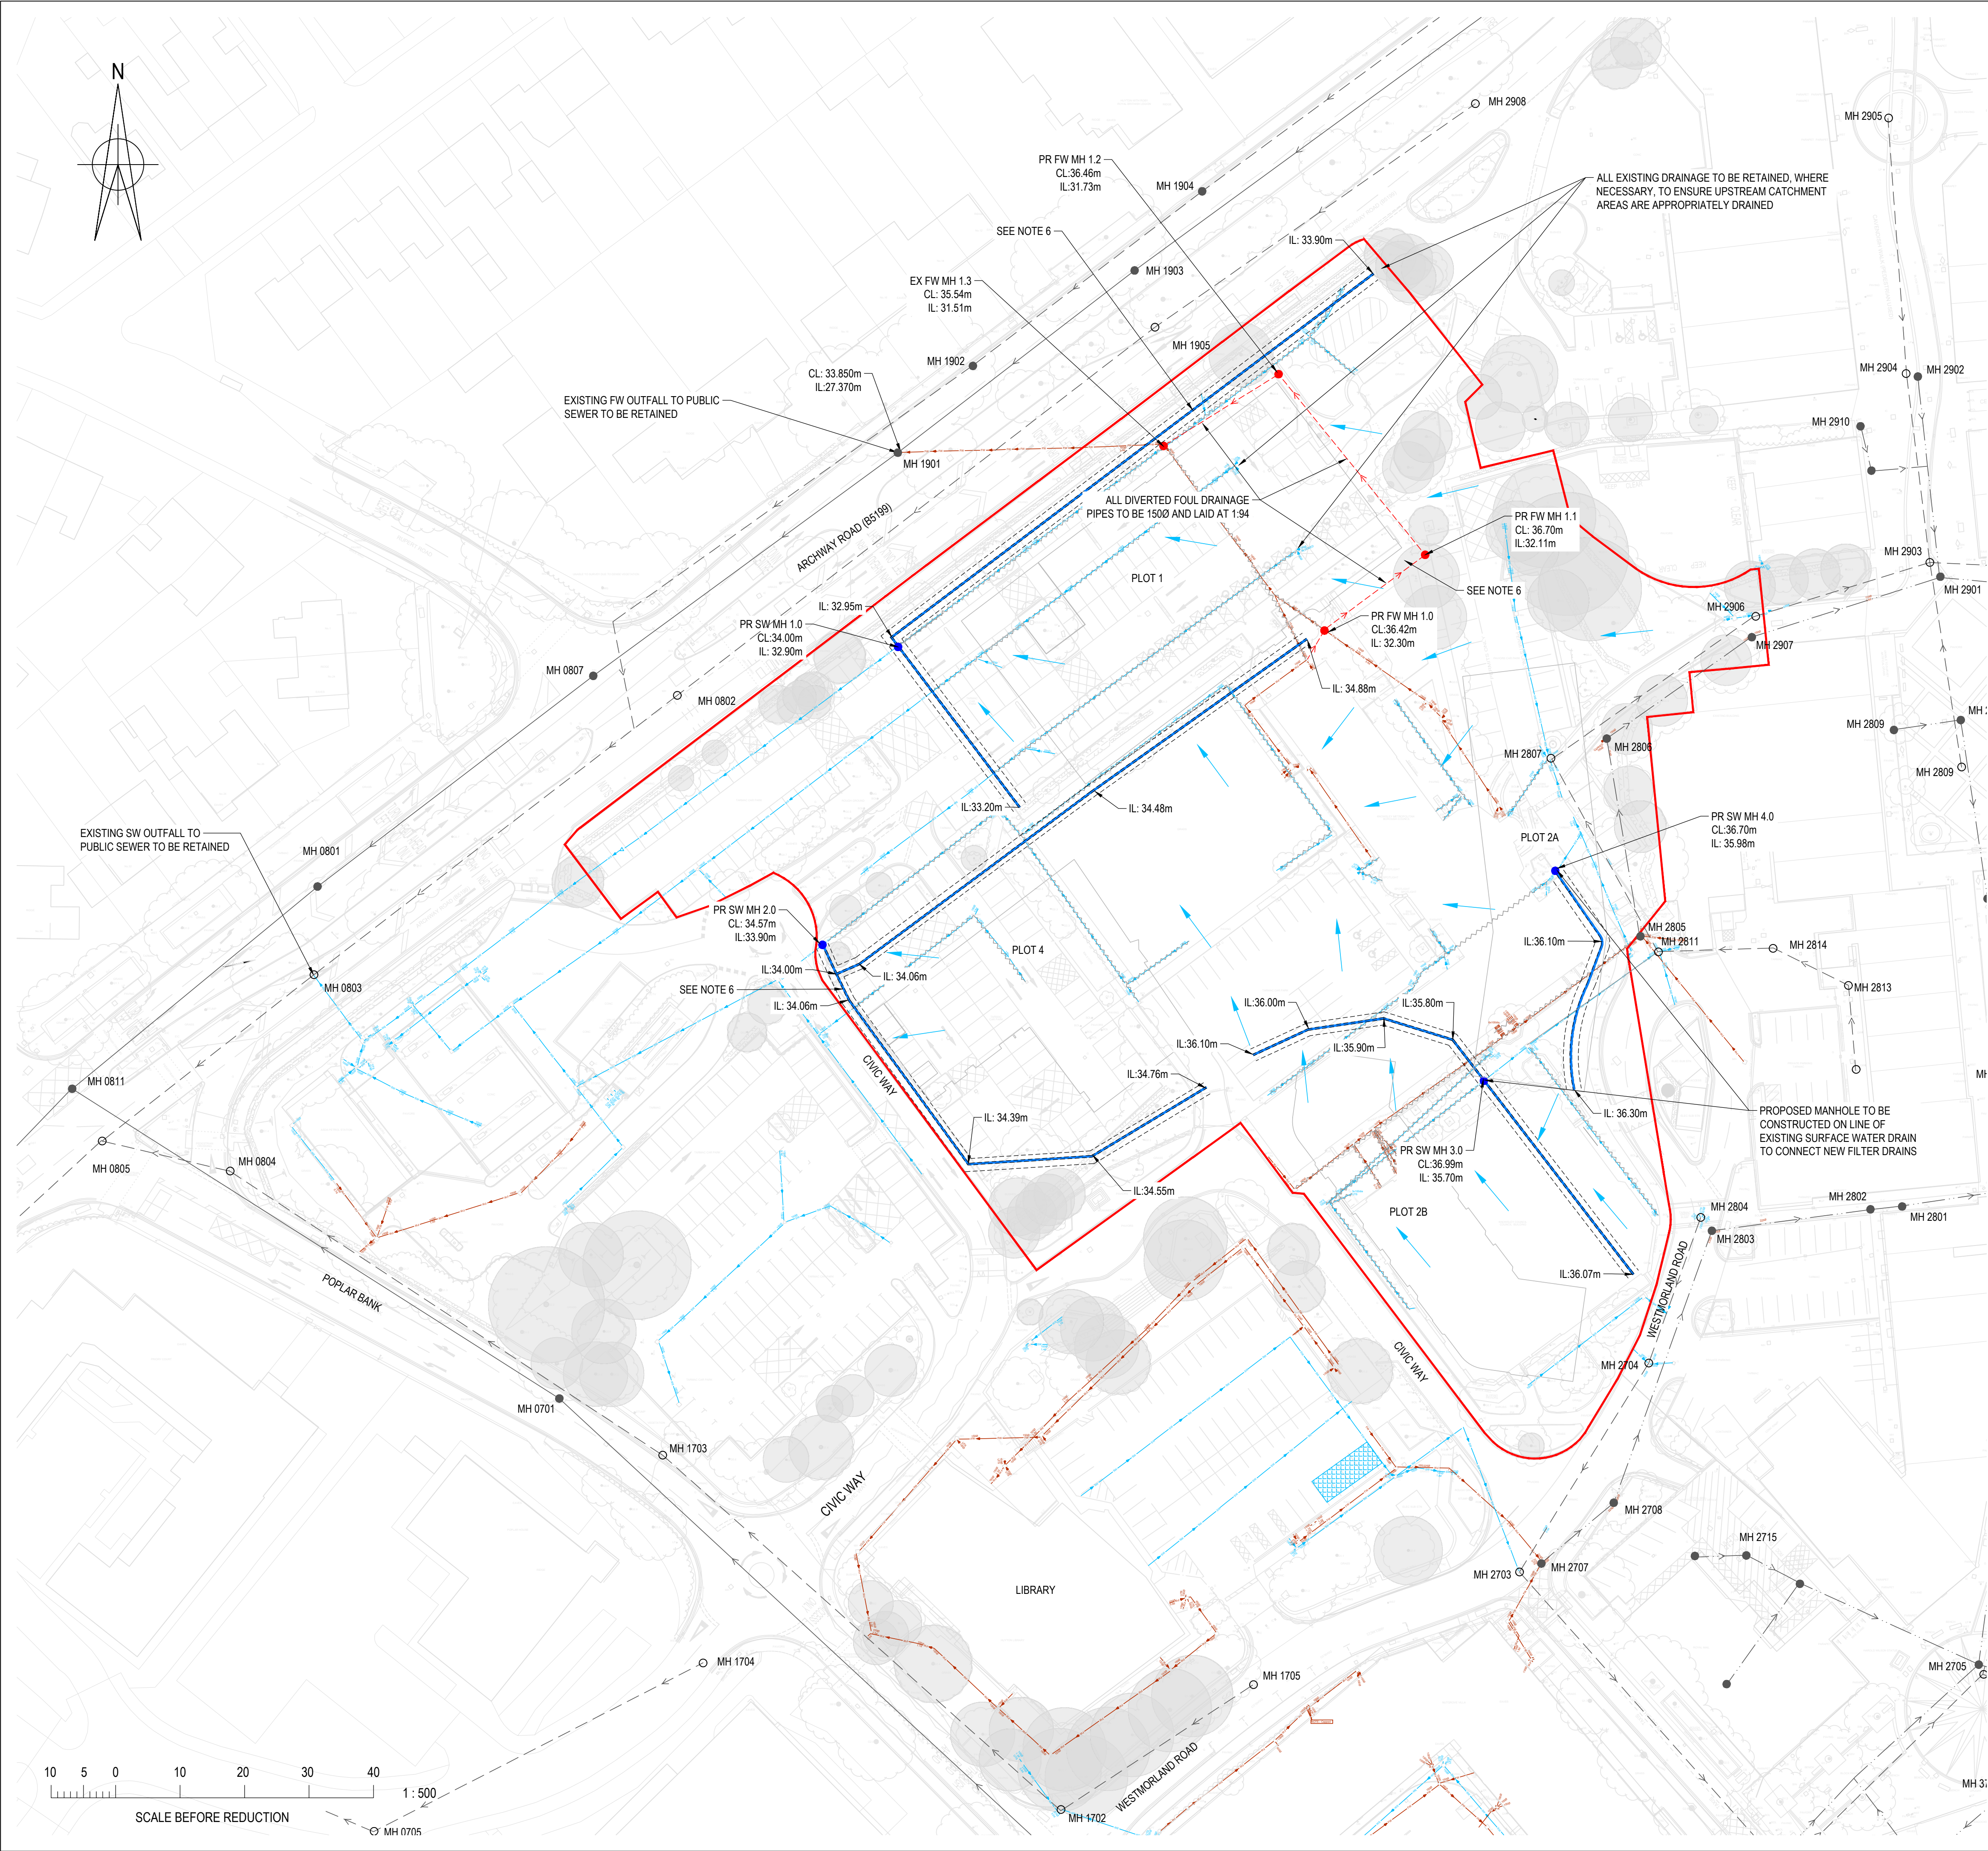

- KEY**
- SITE BOUNDARY
 - PROPOSED FILTER DRAIN
 - PROPOSED SURFACE WATER DRAIN
 - PROPOSED FOUL WATER DRAIN
 - EXISTING PUBLIC COMBINED SEWER
 - EXISTING PUBLIC FOUL WATER SEWER
 - EXISTING PUBLIC SURFACE WATER SEWER
 - EXISTING PRIVATE FOUL WATER DRAIN
 - EXISTING PRIVATE SURFACE WATER DRAIN
 - EXISTING DRAIN TO BE ABANDONED
 - DIRECTION OF SURFACE WATER RUNOFF POST DEMOLITION
 - TREES TO BE RETAINED

- © Buro Happold Limited or its group companies.
All Rights reserved. Buro Happold and its group companies assert (unless otherwise agreed in writing) their rights under s.17(1) of the Copyright, Designs and Patents Act 1988.
DO NOT SCALE THIS DRAWING.
- HEALTH AND SAFETY INFORMATION**
- IN ADDITION TO THE HAZARD/RISKS NORMALLY ASSOCIATED WITH THE TYPES OF WORK DETAILED ON THIS DRAWING, NOTE THE FOLLOWING:
- CONSTRUCTION**
- ANY INSTALLED FILTER DRAINS THAT REQUIRE VEHICLE OVERRUN ARE TO BE PROTECTED USING STEEL ROAD PLATES OR EQUIVALENT PROTECTION MEASURES.
- FOR BELOW GROUND DRAINAGE WORKS REQUIRED IN THE VICINITY OF EXISTING TREES TO BE RETAINED, WORKS ARE TO BE UNDERTAKEN TO A METHOD STATEMENT AND WITH SUPERVISION FROM A SUITABLY QUALIFIED ARBORICULTURALIST.
- MAINTENANCE/CLEANING/OPERATION**
- ANY INSTALLED FILTER DRAINS THAT REQUIRE VEHICLE OVERRUN ARE TO BE PROTECTED USING STEEL ROAD PLATES OR EQUIVALENT PROTECTION MEASURES.
- DECOMMISSIONING/DEMOLITION**
- NOTES**
- THIS DRAWING SHOULD BE READ IN CONJUNCTION WITH ALL OTHER RELEVANT DRAWINGS AND SPECIFICATIONS.
 - DRAWINGS BASED ON THE FOLLOWING BACKGROUND INFORMATION:
 - TOPOGRAPHICAL & GPR SURVEY AS PER SURVEY OPERATIONS DRAWING 23F247, RECEIVED 27/09/23
 - UNITED UTILITIES SEWER RECORDS
 - KNOWSLEY COUNCIL PROPOSED TENDER PLAN DRAWING 002, DATED 12/05/21 HIGHLIGHTING THE EXISTING DRAINAGE WITHIN THE LIBRARY CAR PARK.
 - CCTV SURVEY TS-2645 HUXTON TOWN CENTRE REGENERATION CCTV REPORT, RECEIVED 23/05/25
 - THE COMPLETENESS OF THE UNDERGROUND SERVICE INFORMATION CANNOT BE GUARANTEED AND THEREFORE OTHER SERVICES MAY EXIST.
 - THE GROUND LEVELS ARE BASED ON THE PROPOSED FINISH LEVELS DIRECTED BY LUCID DRAWING L0016_LEVELS, RECEIVED 14/05/2025
 - ANY INSTALLED FILTER DRAINS THAT REQUIRE VEHICLE OVERRUN ARE TO BE PROTECTED USING STEEL ROAD PLATES OR EQUIVALENT PROTECTION MEASURES.
 - FOR BELOW GROUND DRAINAGE WORKS REQUIRED IN THE VICINITY OF EXISTING TREES TO BE RETAINED, WORKS ARE TO BE UNDERTAKEN TO A METHOD STATEMENT AND WITH SUPERVISION FROM A SUITABLY QUALIFIED ARBORICULTURALIST.
 - FOUL WATER PROPOSALS FORM A DIVERSION OF THE EXISTING CONVEYANCE ROUTE FROM MUNICIPAL TOWER TO UNITED UTILITIES SEWER AROUND PLOT 1. THIS DIVERSION IS TO BE REVIEWED AGAINST THE CONSTRUCTION PHASING STRATEGY ONCE FINALISED.
 - ALL FOUL WATER PIPES TO BE DN150 UPVC.
 - REFER TO DRAWING HCO-BHE-XX-XX-SH-C-3810 FOR MANHOLE SCHEDULE.
 - REFER TO DRAWING HCO-BHE-XX-XX-DR-C-3710-3711 FOR DRAINAGE DETAILS.
 - ANY DRAINAGE TO BE ABANDONED SHALL BE DONE IN ACCORDANCE WITH MCHW SERIES 500 CLAUSE 506.3.
 - INVERT LEVELS AT MANHOLES SHOWN REFER TO INCOMING PIPE CONNECTIONS.

P01 ISSUED FOR APPROVAL 22.08.2025 WM PA PA

Rev	Description	Date	Iss'd	Rev'd	App'd
-----	-------------	------	-------	-------	-------

TENDER

Project Stage

APPROVAL

Status of Drawing

BURO HAPPOLD

2nd Floor Eastgate
2 Castle Street
Manchester M3 4LZ
UK

Tel: +44 (0)161 233 5000
Fax: +44 (0)870 787 4143
Email: 0054419@burohappold.com
Web: www.burohappold.com

Client: GENR8 KAJIMA REGENERATION LTD
Architect: 5PLUS
Project: Huyton Town Centre Regeneration
Orig Title: ENABLING WORKS
PROPOSED DRAINAGE PLAN

Job No: 0054419 Scale: A1
Drawing No: HCO-BHE-XX-XX-DR-C-3110

Drawn/Designed By: WM
Checked By: PA
Approved By: PA

Revision: P01