



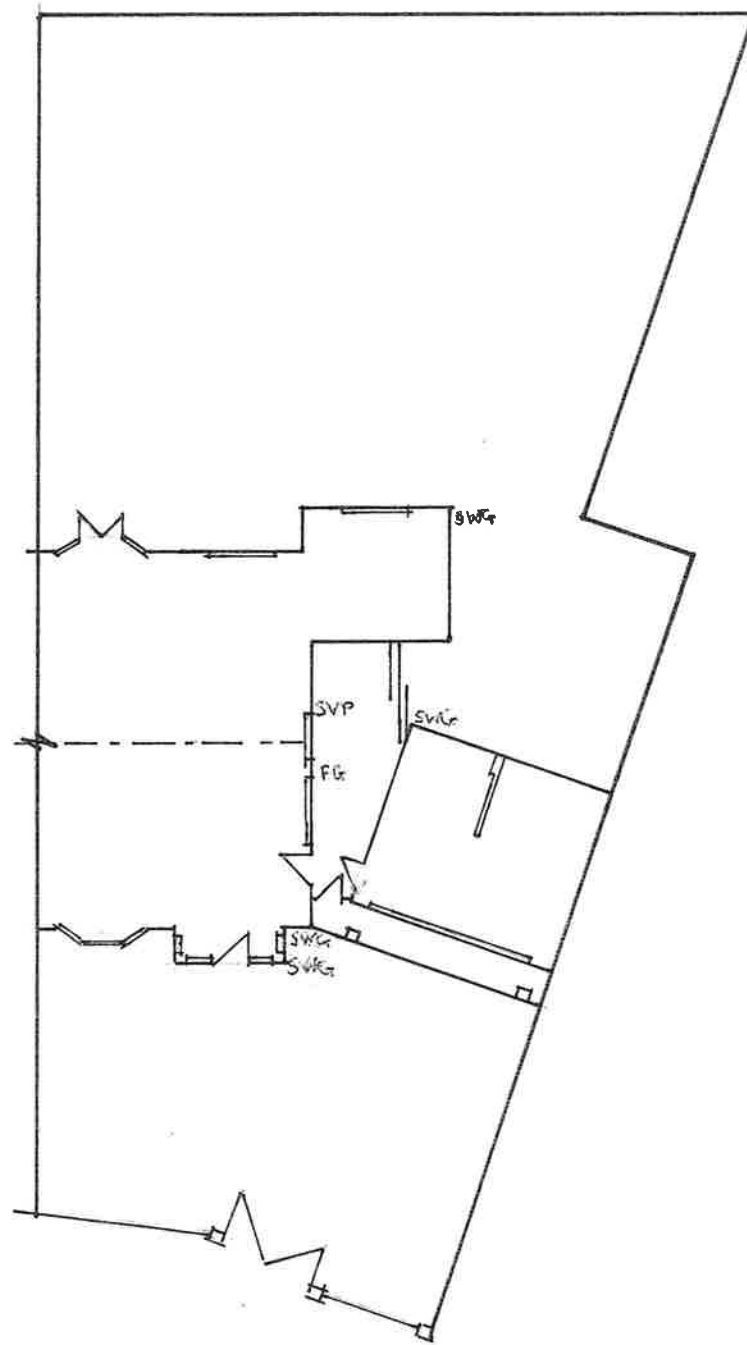

EXISTING

NOTES:

CONTRACTOR TO TAKE OWN
MEASUREMENTS.
SWG = SURFACE WATER GULLY
FG = FOUL WATER GULLY
SVP = SOIL VENT PIPE
V = VELUX ROOF LIGHT

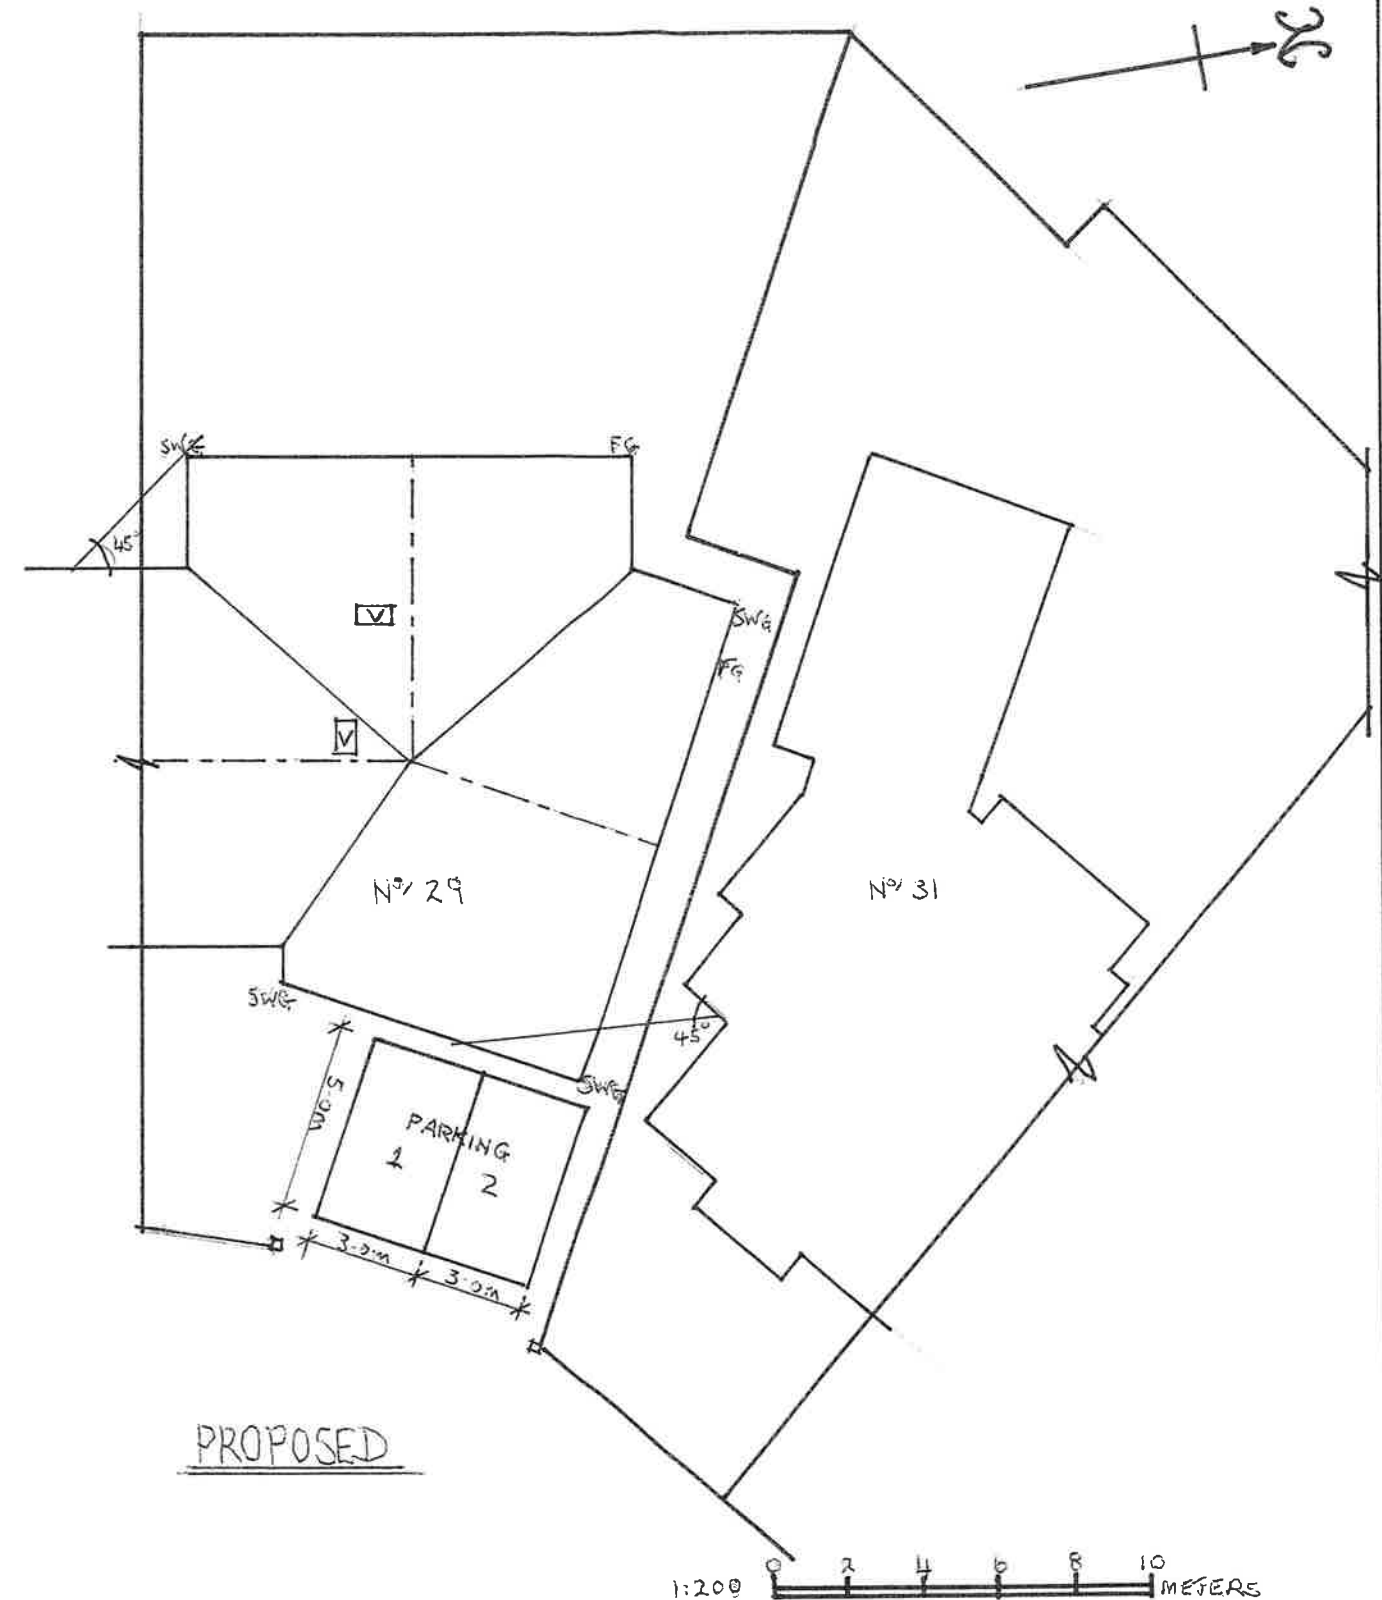

PROPOSED

1:200 0 2 4 6 8 10 METERS

APPLICANT:
MR CHRIS WRIGLEY

SITE ADDRESS:
29 MELLING WAY
OLD HALL ESTATE
KIRKBY
L32 1TH

DRAWING TITLE:
SITE PLANS

SCALE:
1:200

DATE:
6 JULY '26

DRAWING No:
1 OF 4

BARRY GILFOYLE