


- | | | |
|-----------|---------|----------|
| | Foul | S.W. |
| Head Run | 1 in 40 | 1 in 60 |
| Elsewhere | 1 in 80 | 1 in 100 |

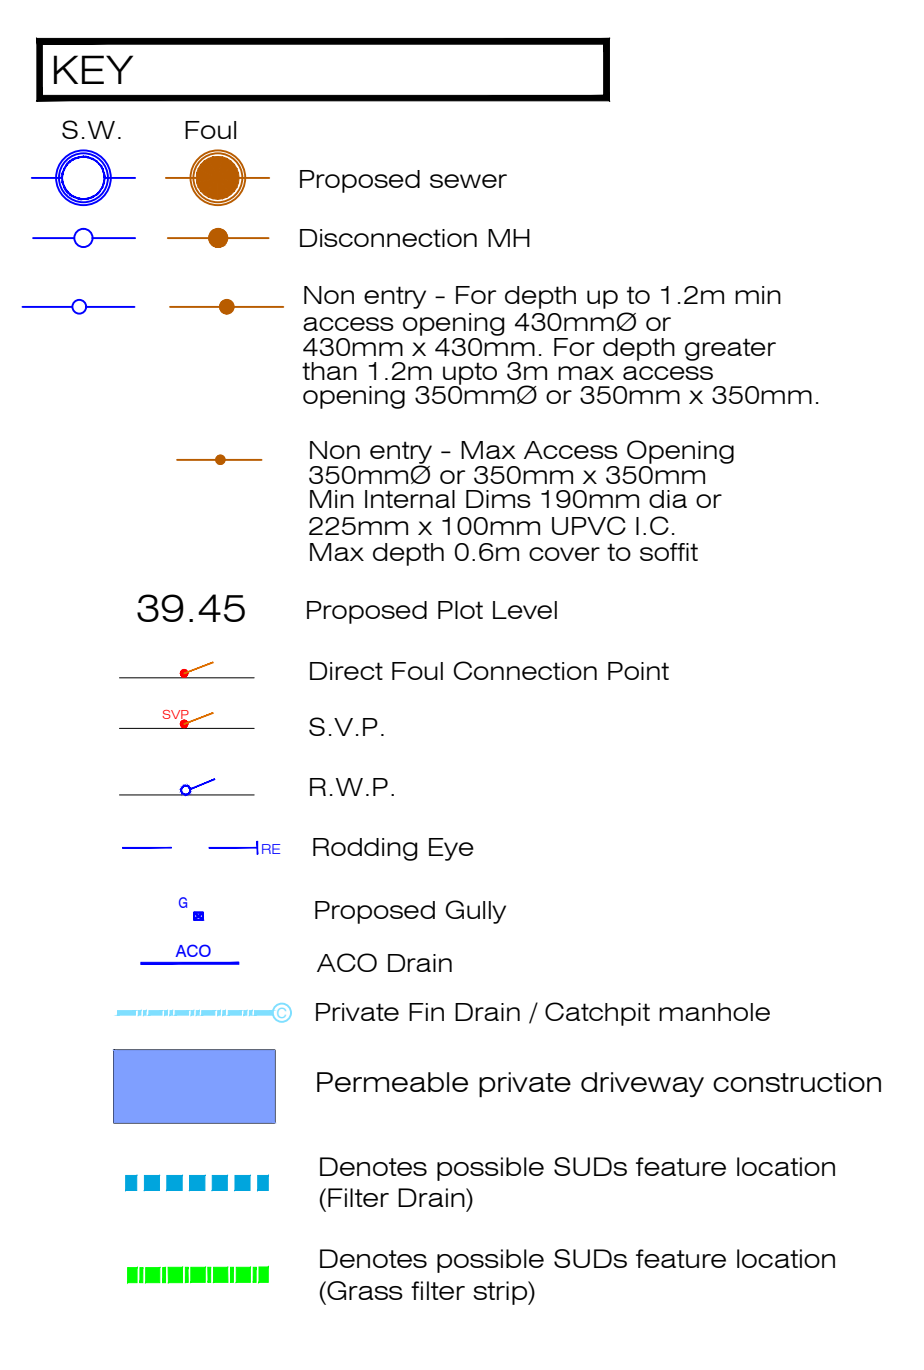

B	08/01/26	NE	Domestic Drainage updated to latest Architects Layout.	
A	22/12/25	BK	Updated to latest Layout.	
Rev	Date	Initials	Details	

Drawing Revisions

North Point 	Project Pilch Lane Liverpool
Quality Ass. UKAS 9001 Quality Assurance ISO 9001:2015 SGS Certificate GB02/54539	Client Breck Homes
Original Size Copyright Acknowledgement Ordinance Survey © Crown Copyright. All rights reserved. License No. AL100017966.	Title Domestic Drainage Layout Drawn NE Checked By RDE Date 08/01/2026 Scale 1:200

Ironsides Farrar

Engineers Planners
City Engineers
Landscape Architects
Graphic Design

3 Worsley Court **MANCHESTER** M28 3NJ
Tel. 0161 703 8801 Fax. 0161 703 8279
manchester@ironsidesfarrar.co.uk

EDINBURGH **GLASGOW**

Drawing No. 30686/9	Revision B
--	---------------------------------