



NOTES

- All dimensions are in millimetres unless otherwise shown.
- All private drainage works are to comply fully with part H of the Building Regulations.
- All existing invert levels to be checked by the contractor at the start of works and any other discrepancies notified to the Engineer. All levels are based on topographical survey information provided by others.
- All materials to bear the relevant B.S. Kitemark and comply fully with the specifications. All concrete & concrete products must use Sulphate resistant cement (unless the site investigation report proves that sulphate attack from soils and groundwater will not occur to withstand a class 3 condition).
- All opening notices etc. as required under highways acts etc. are to be obtained prior to commencement of works. All works are to be inspected by L.A., NHBC or the Network Operator as applicable.
- Where "Polypipe" UPVC pipes (or similar approved) are used in adoptable drainage they shall be handled and laid in accordance with the specification and guidance issued by the High Performance Pipe Association. A Class S Bed and surround must be used for such pipes.
- Granular material all in accordance with Sewers for Adoption CL.4.3.4.
- Modular Units to be supplied by Wavin Limited Hazlehead Crow Edge Sheffield S36 4HG

www.wavin.co.uk or similar approved
- Units shall be installed in accordance with the Manufacturers instructions.
- See drainage layout for size of tank and cover/invert levels

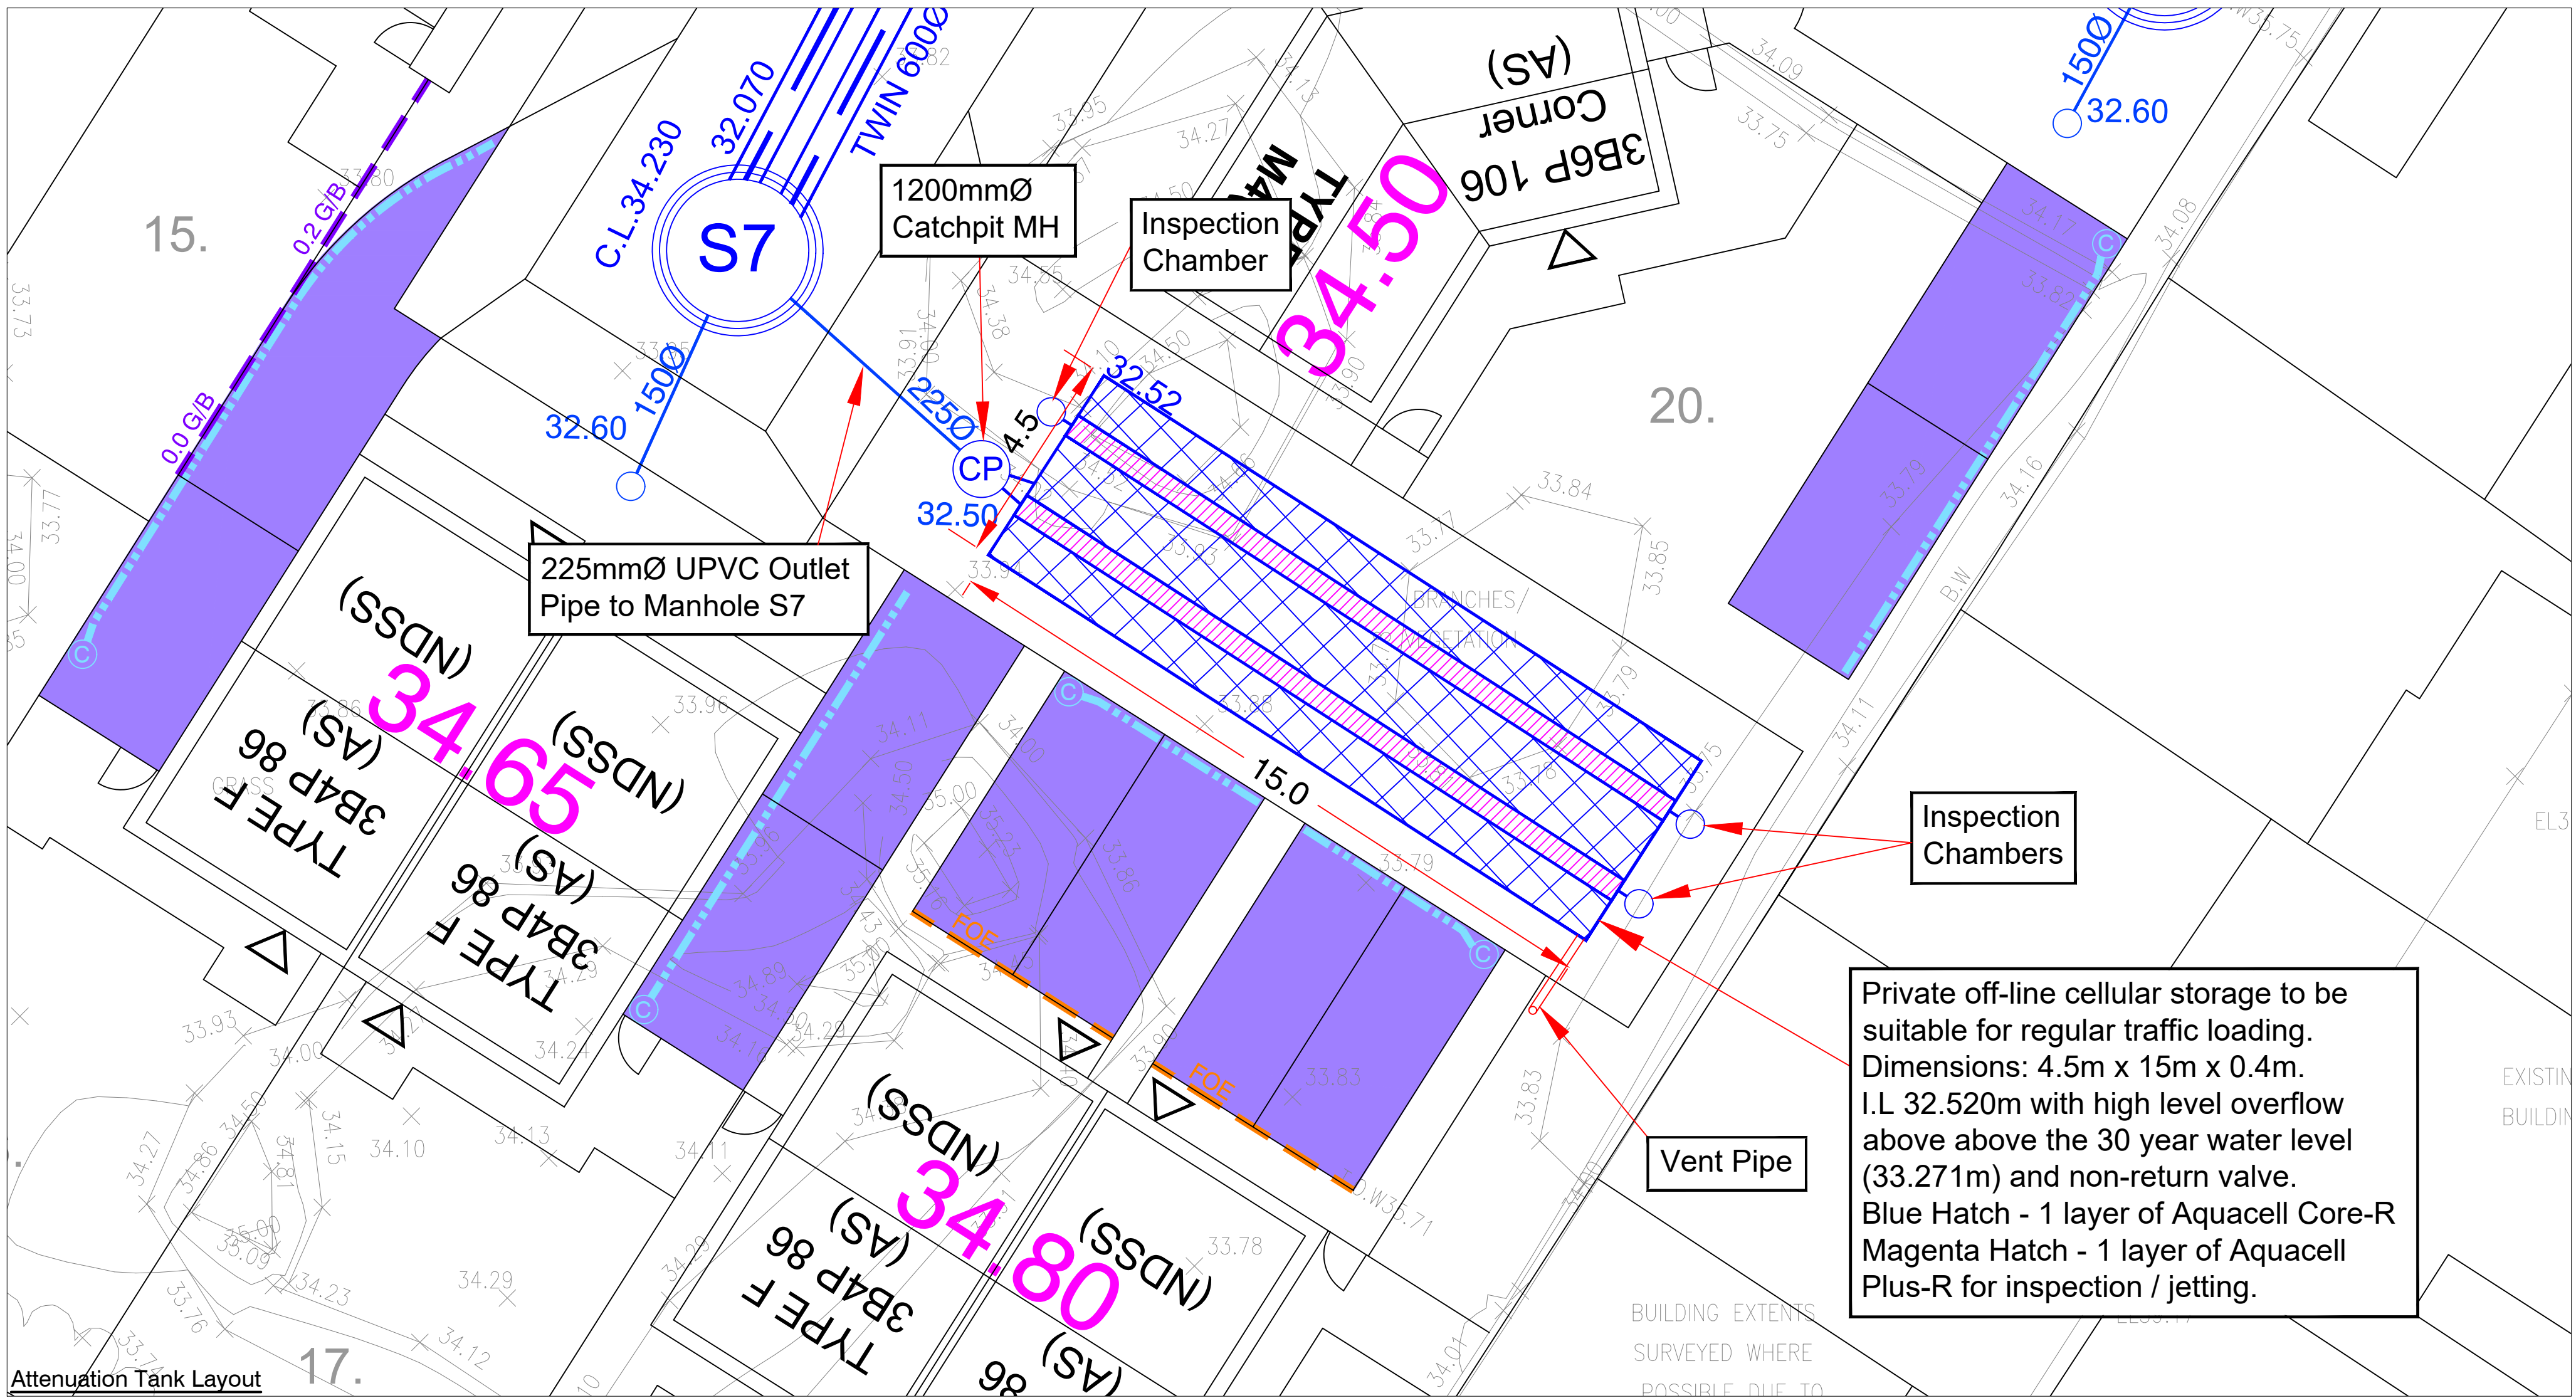


Attenuation Tank Layout
Scale 1:100 @ A1

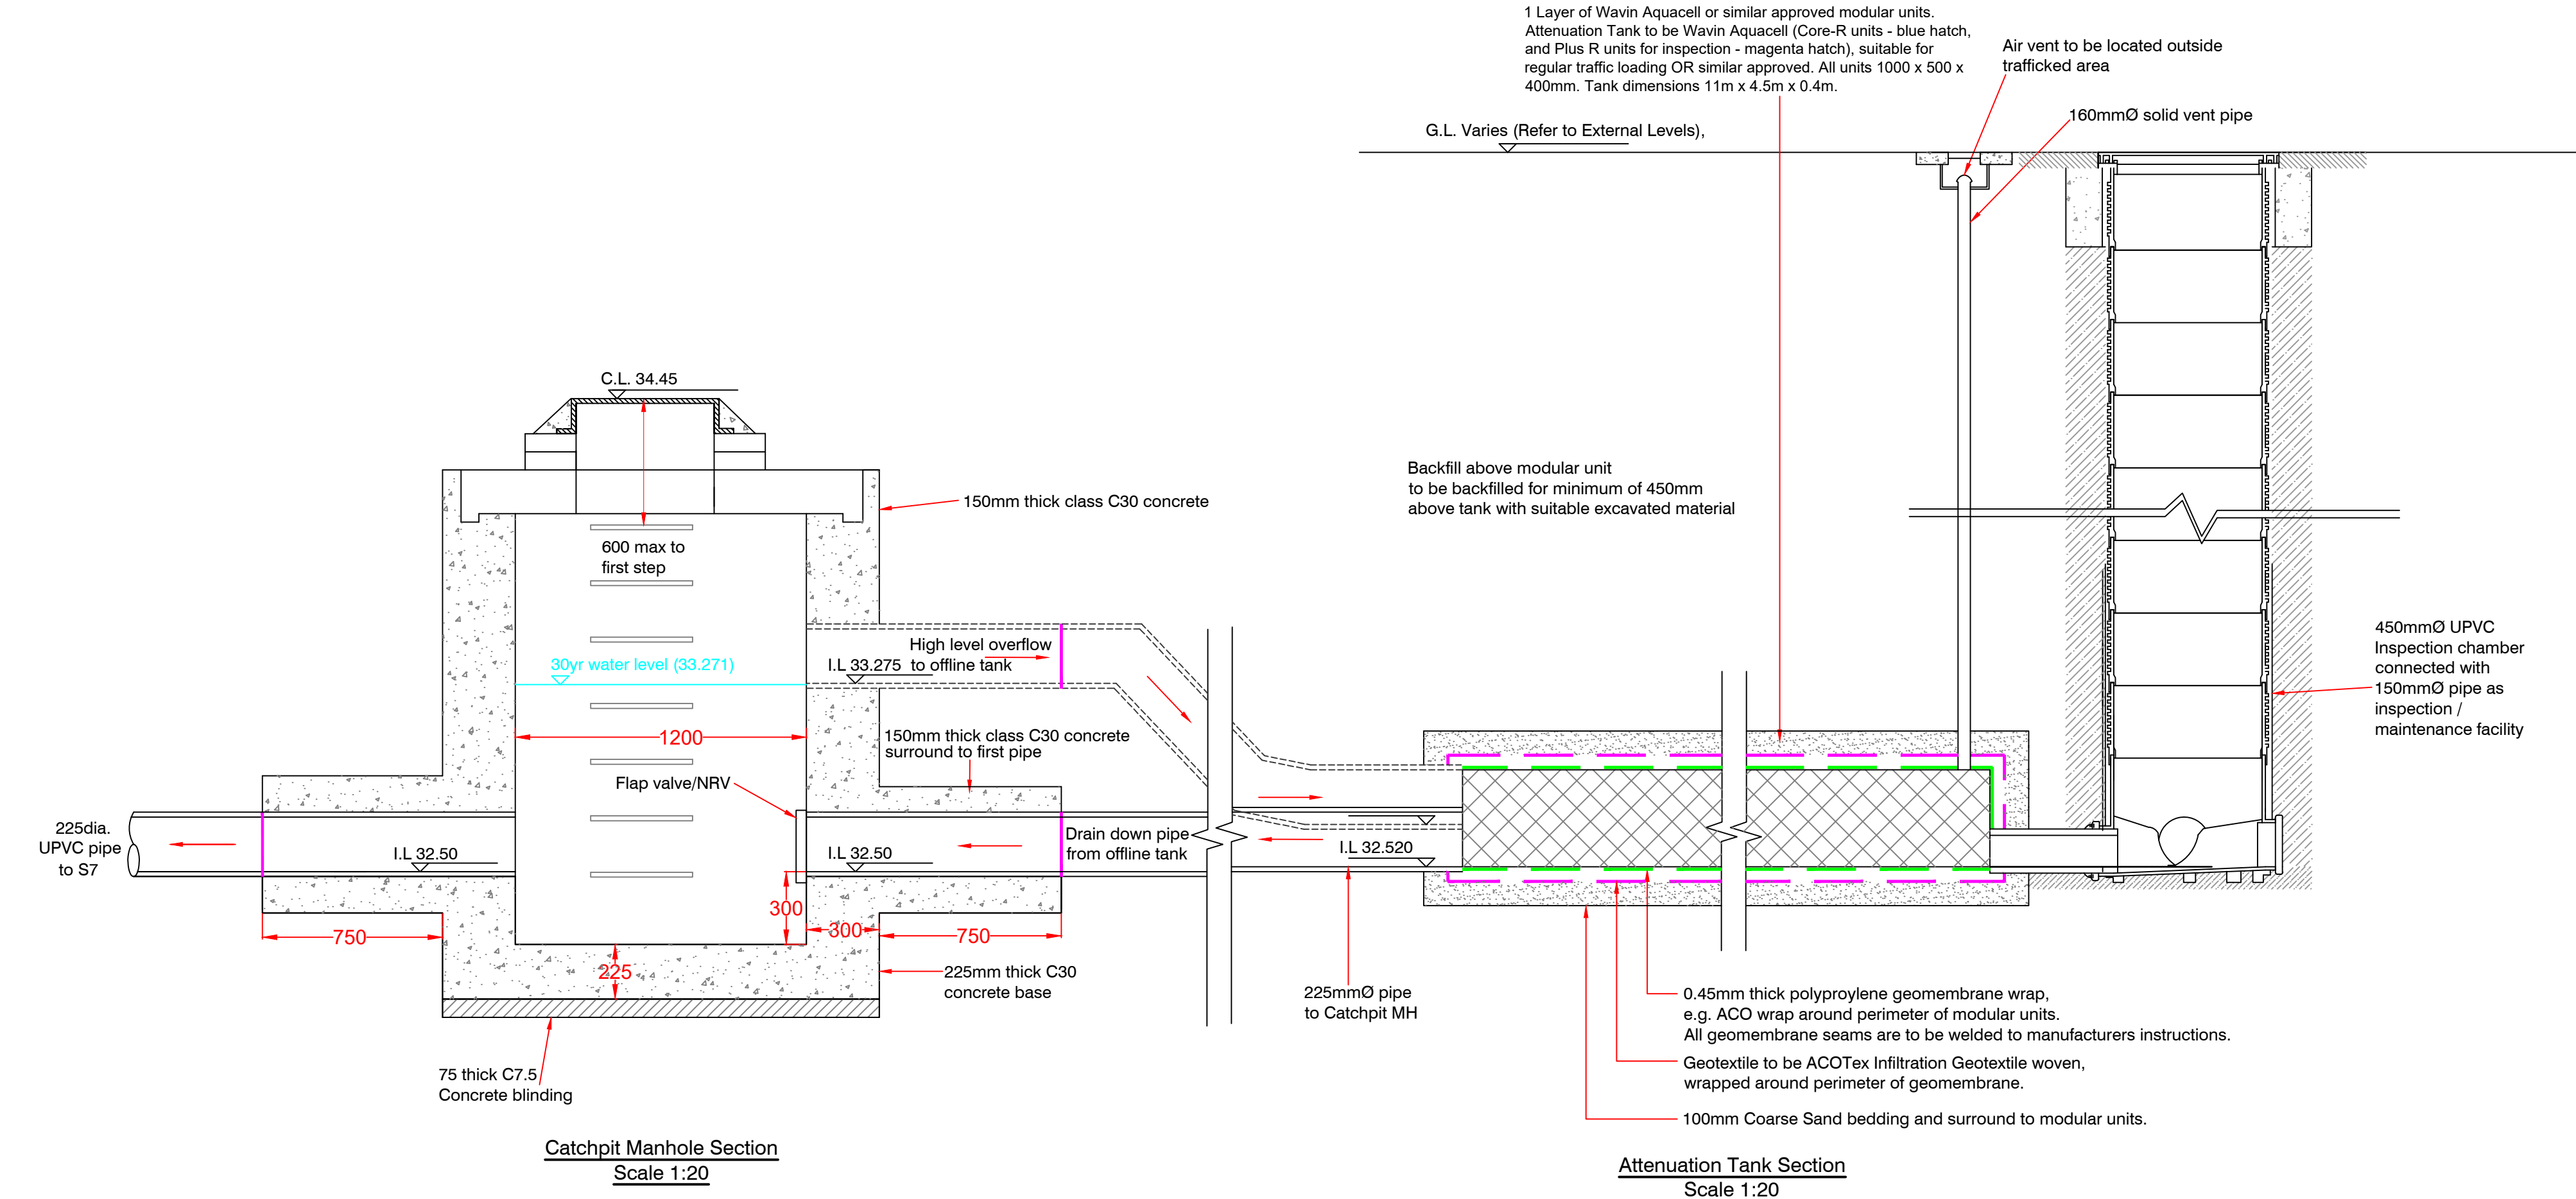

Catchpit Manhole Section
Scale 1:20

Attenuation Tank Section
Scale 1:20

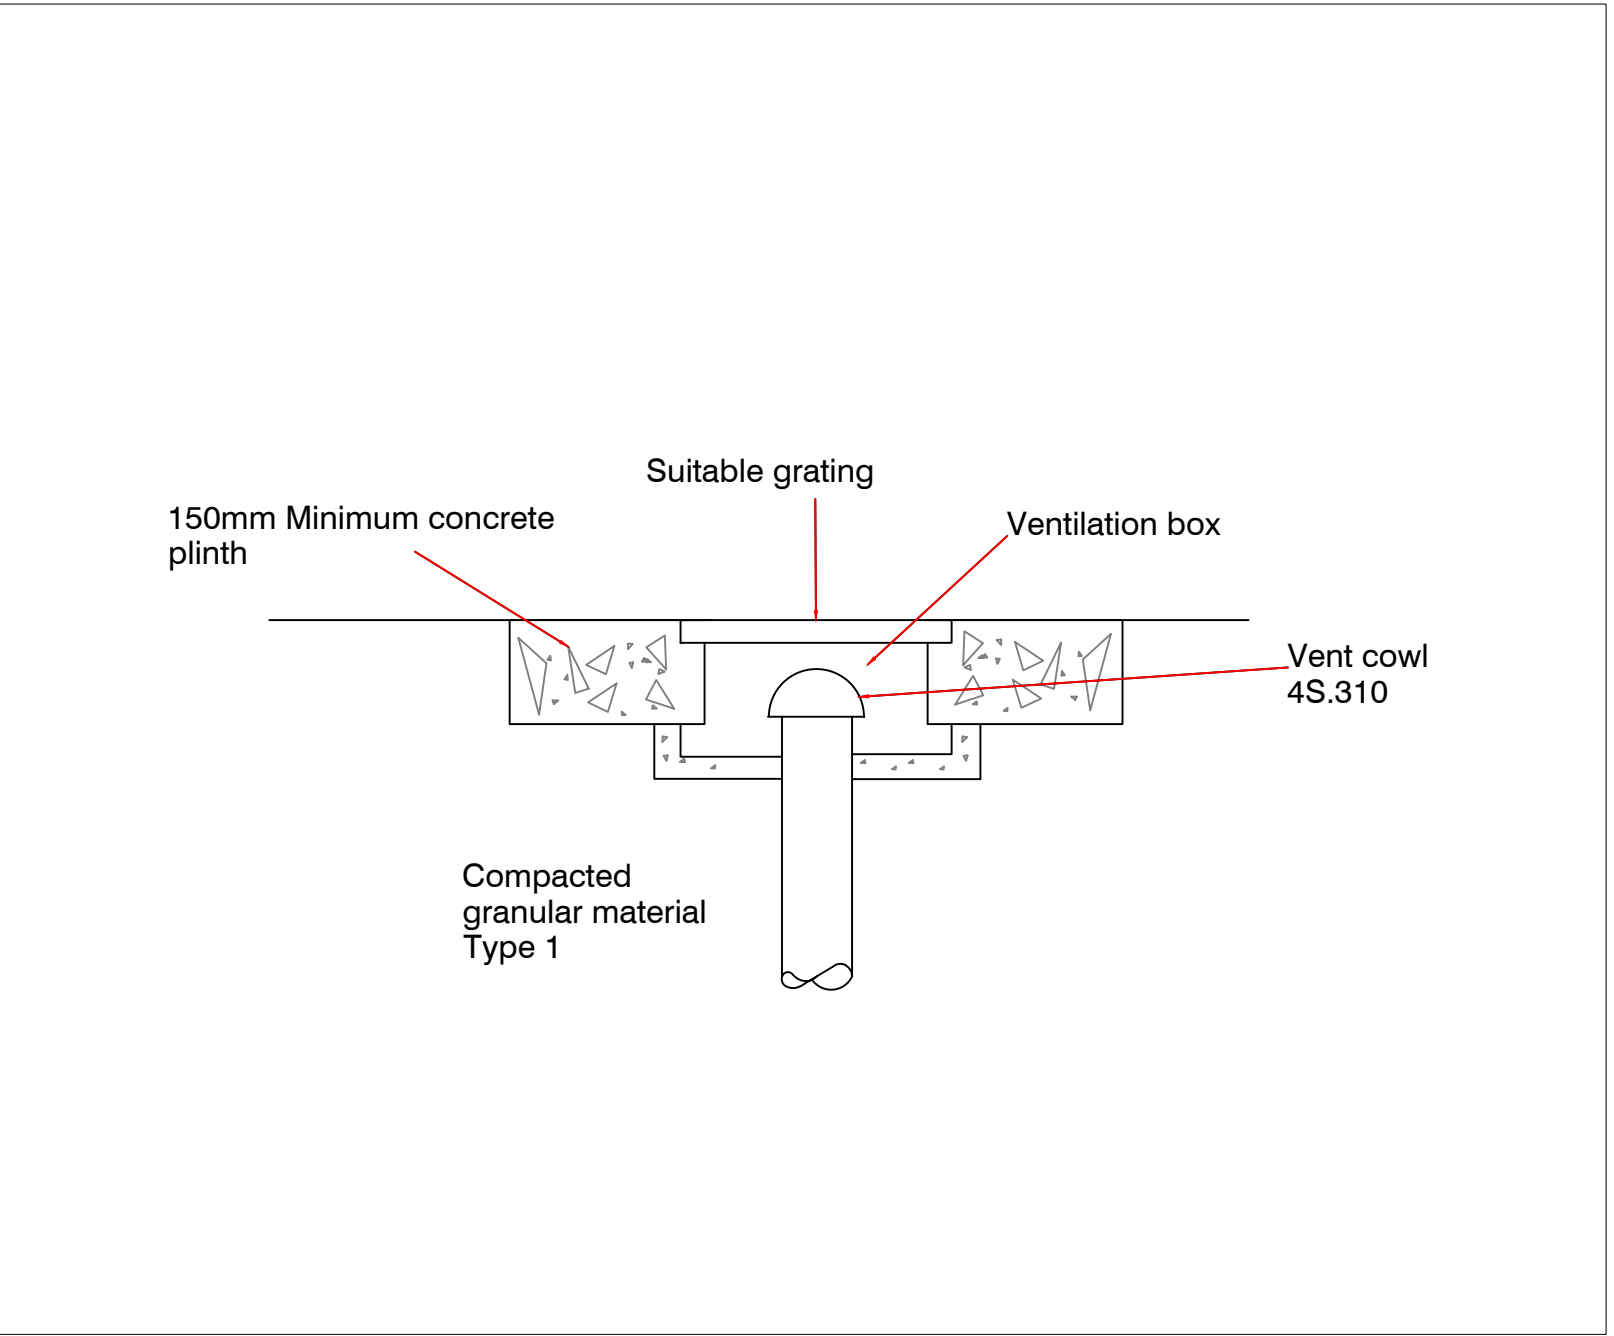

A		22/12/25	BK	Updated to latest Layout.	
Rev	Date	Initials	Details		
Drawing Revisions					
North Point		Project		Client	
Pitche Lane Liverpool		Breck Homes			
Quality Ass.		Quality Assurance		Title	
UKAS 005		ISO 9001:2015		Private Offline Attenuation	
SGS Certificate		GB02/54539		Tank Details	
Original Size		Copyright Acknowledgment		Drawing No.	
A1		Ordnance Survey®		30686/11/2	
		©Crown Copyright.		Revision	
		All rights reserved.		A	
		Licence No. AL100017966.			
		Date			
		Oct 25			
		Scale			
		As Shown			

Ironsides		Farrar	
Environmental Planners		Civil Engineers	
Landscape Architects		Graphic Design	
3 Worsley Court MANCHESTER M20 3NU			
Tel. 0161 703 8841 Fax. 0161 703 8279			
manchester@ironsidesfarrar.com			
EDINBURGH		GLASGOW	