




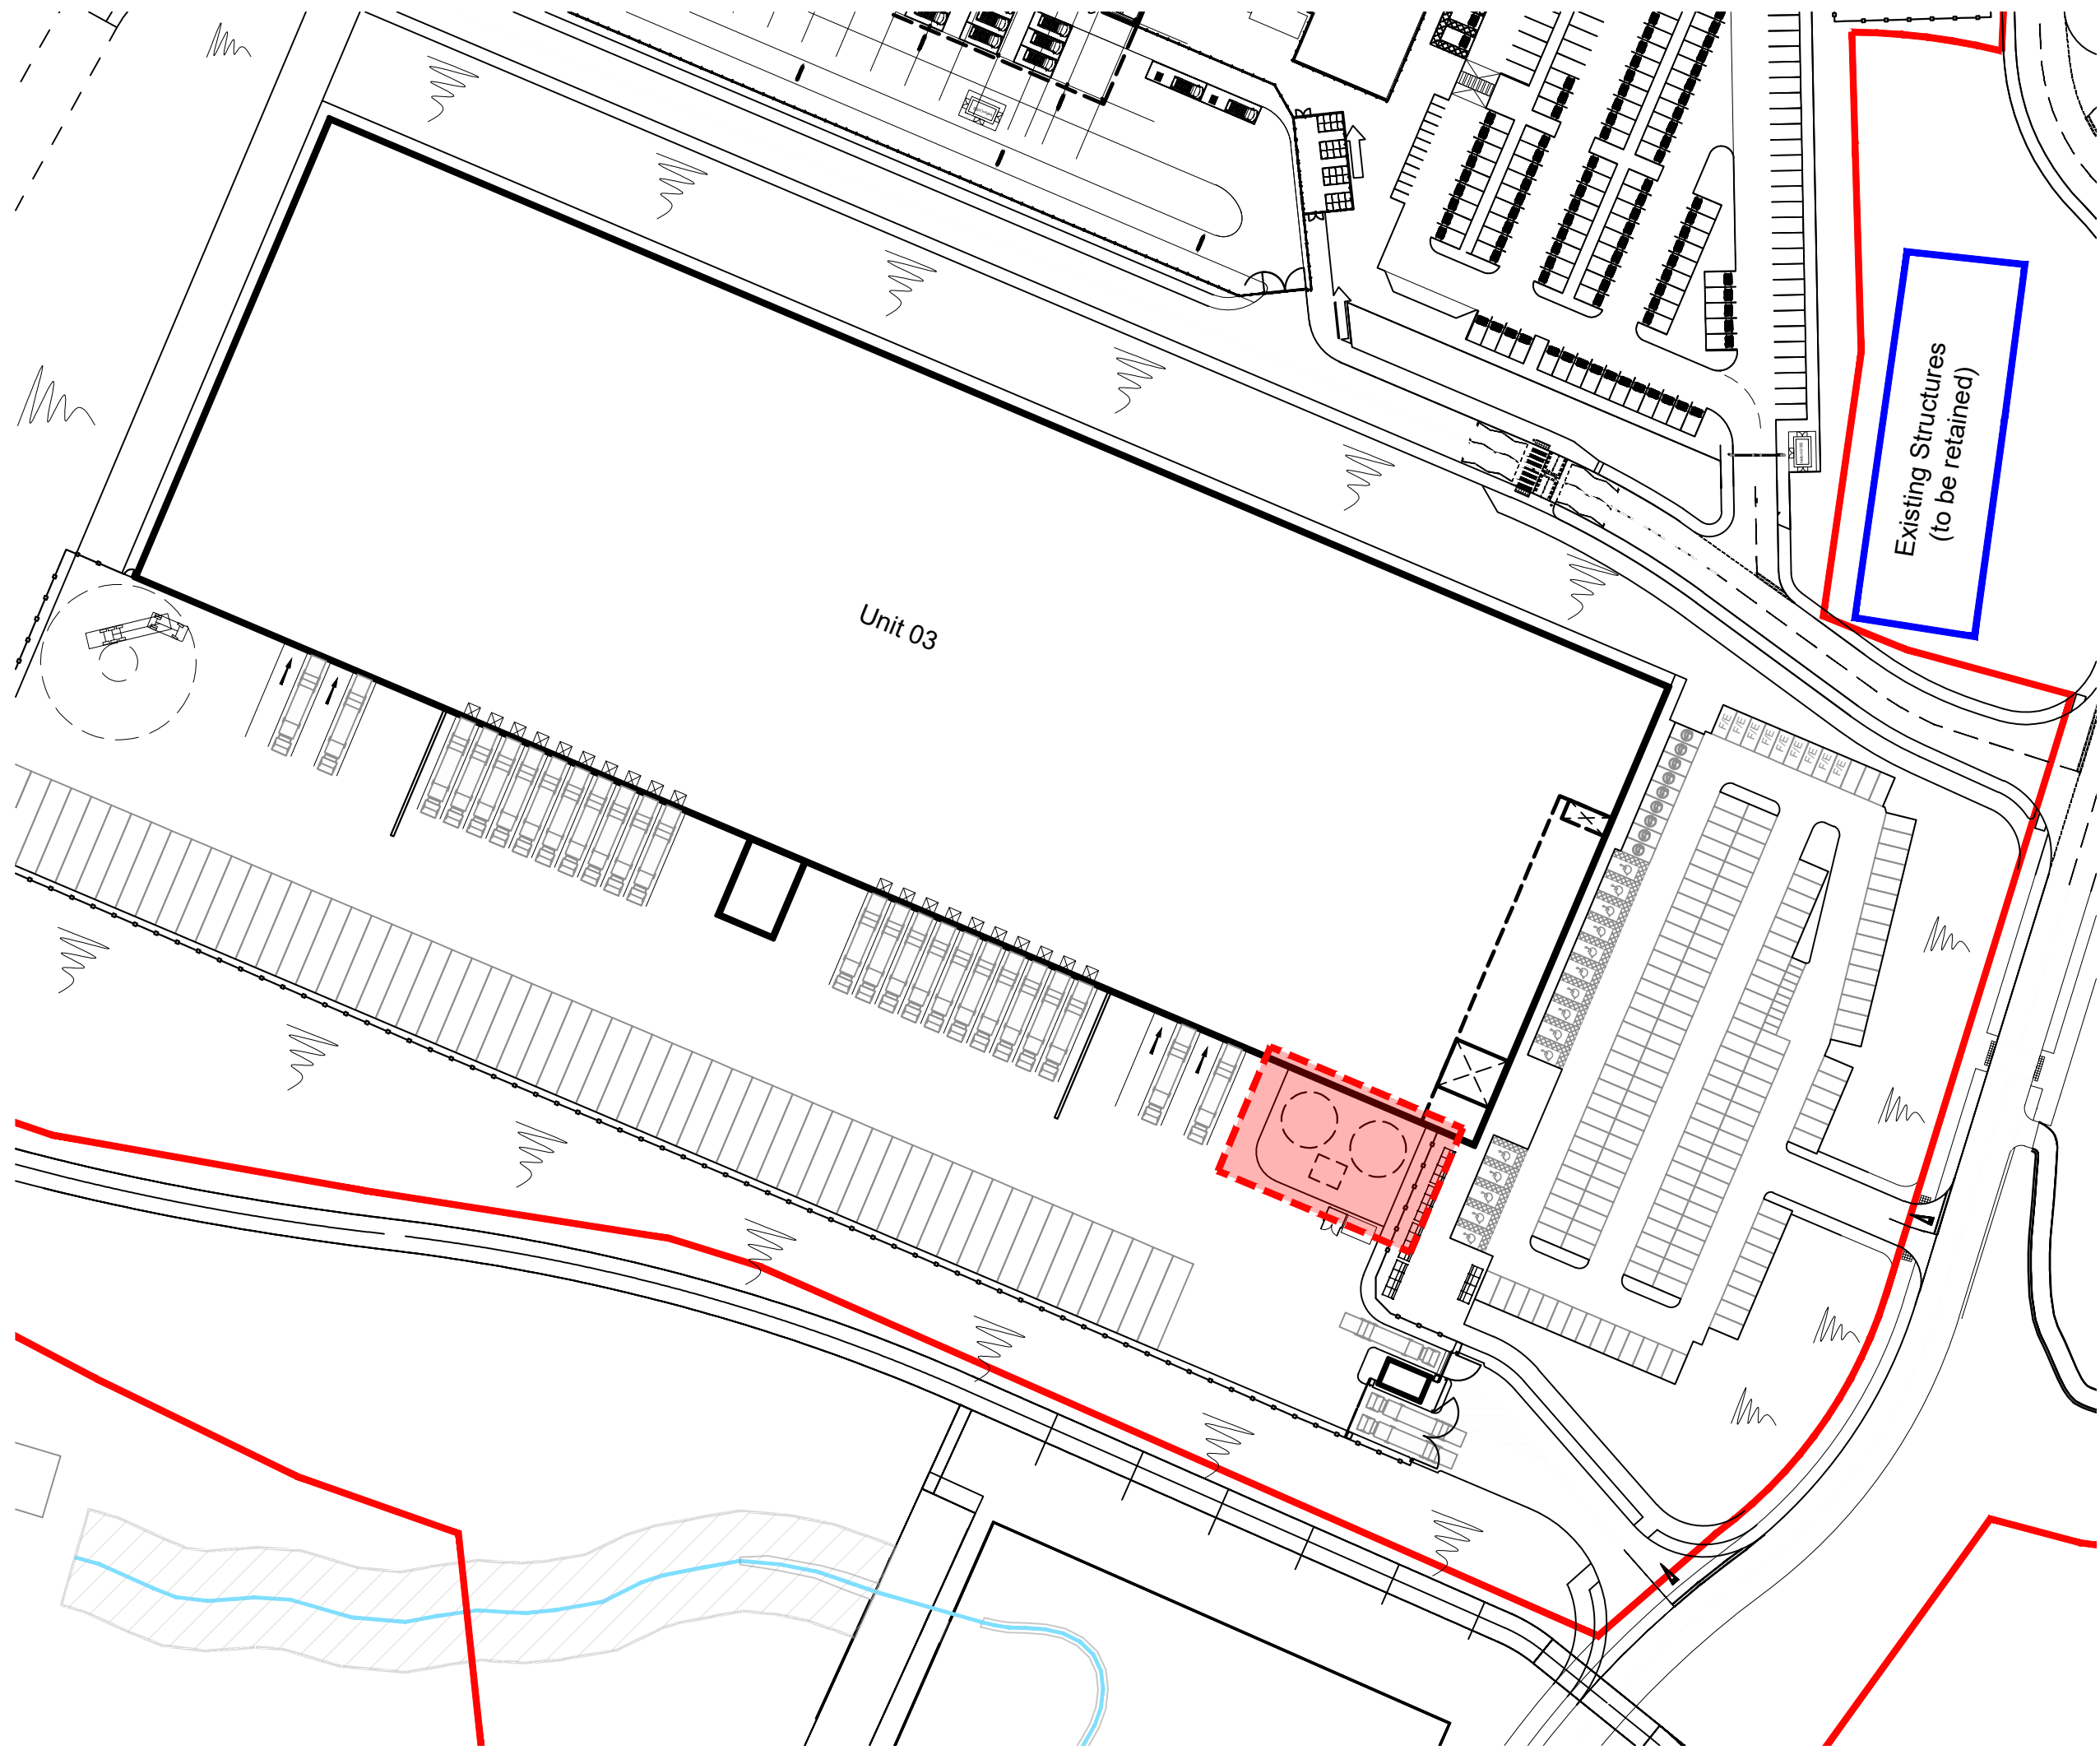


Site Plan Scale 1:1000

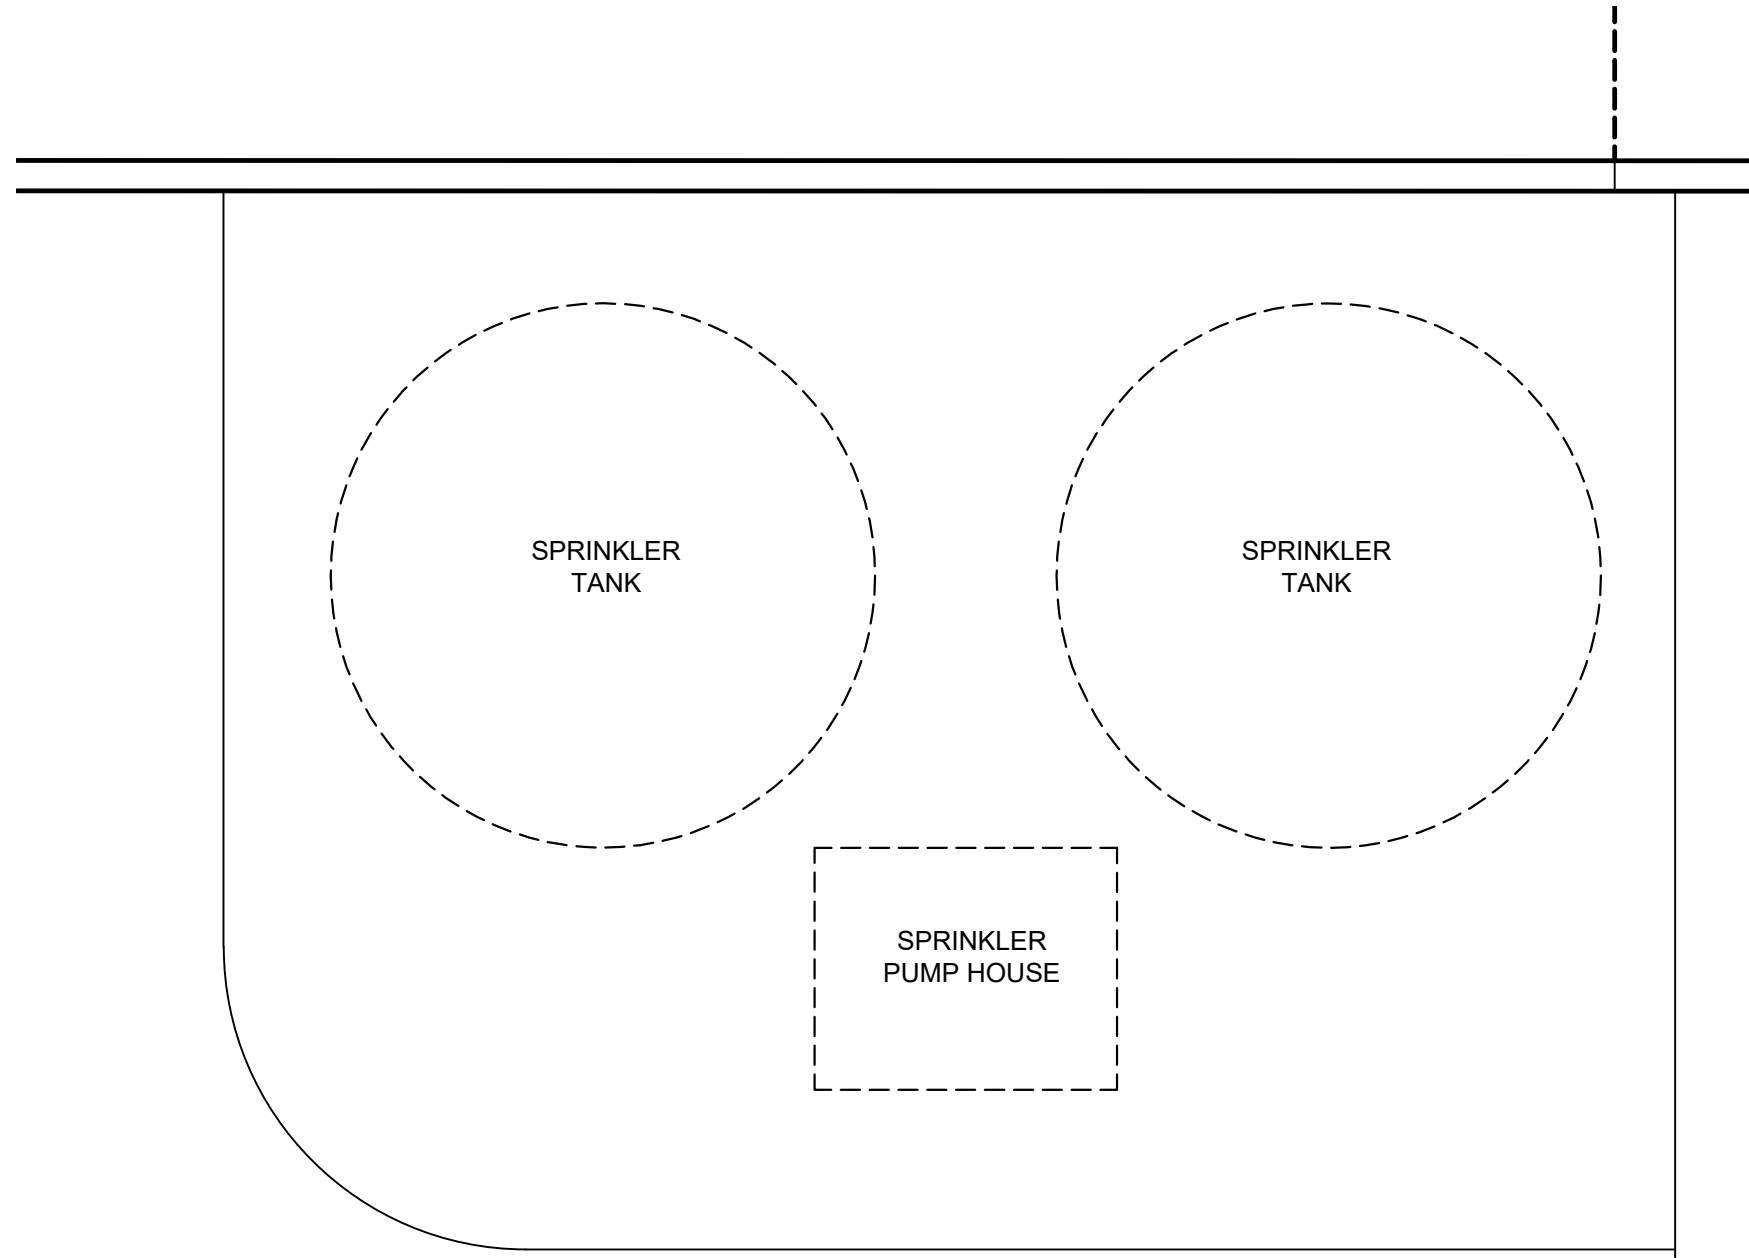

Sprinkler Tanks and Pump House Layout Scale 1:100

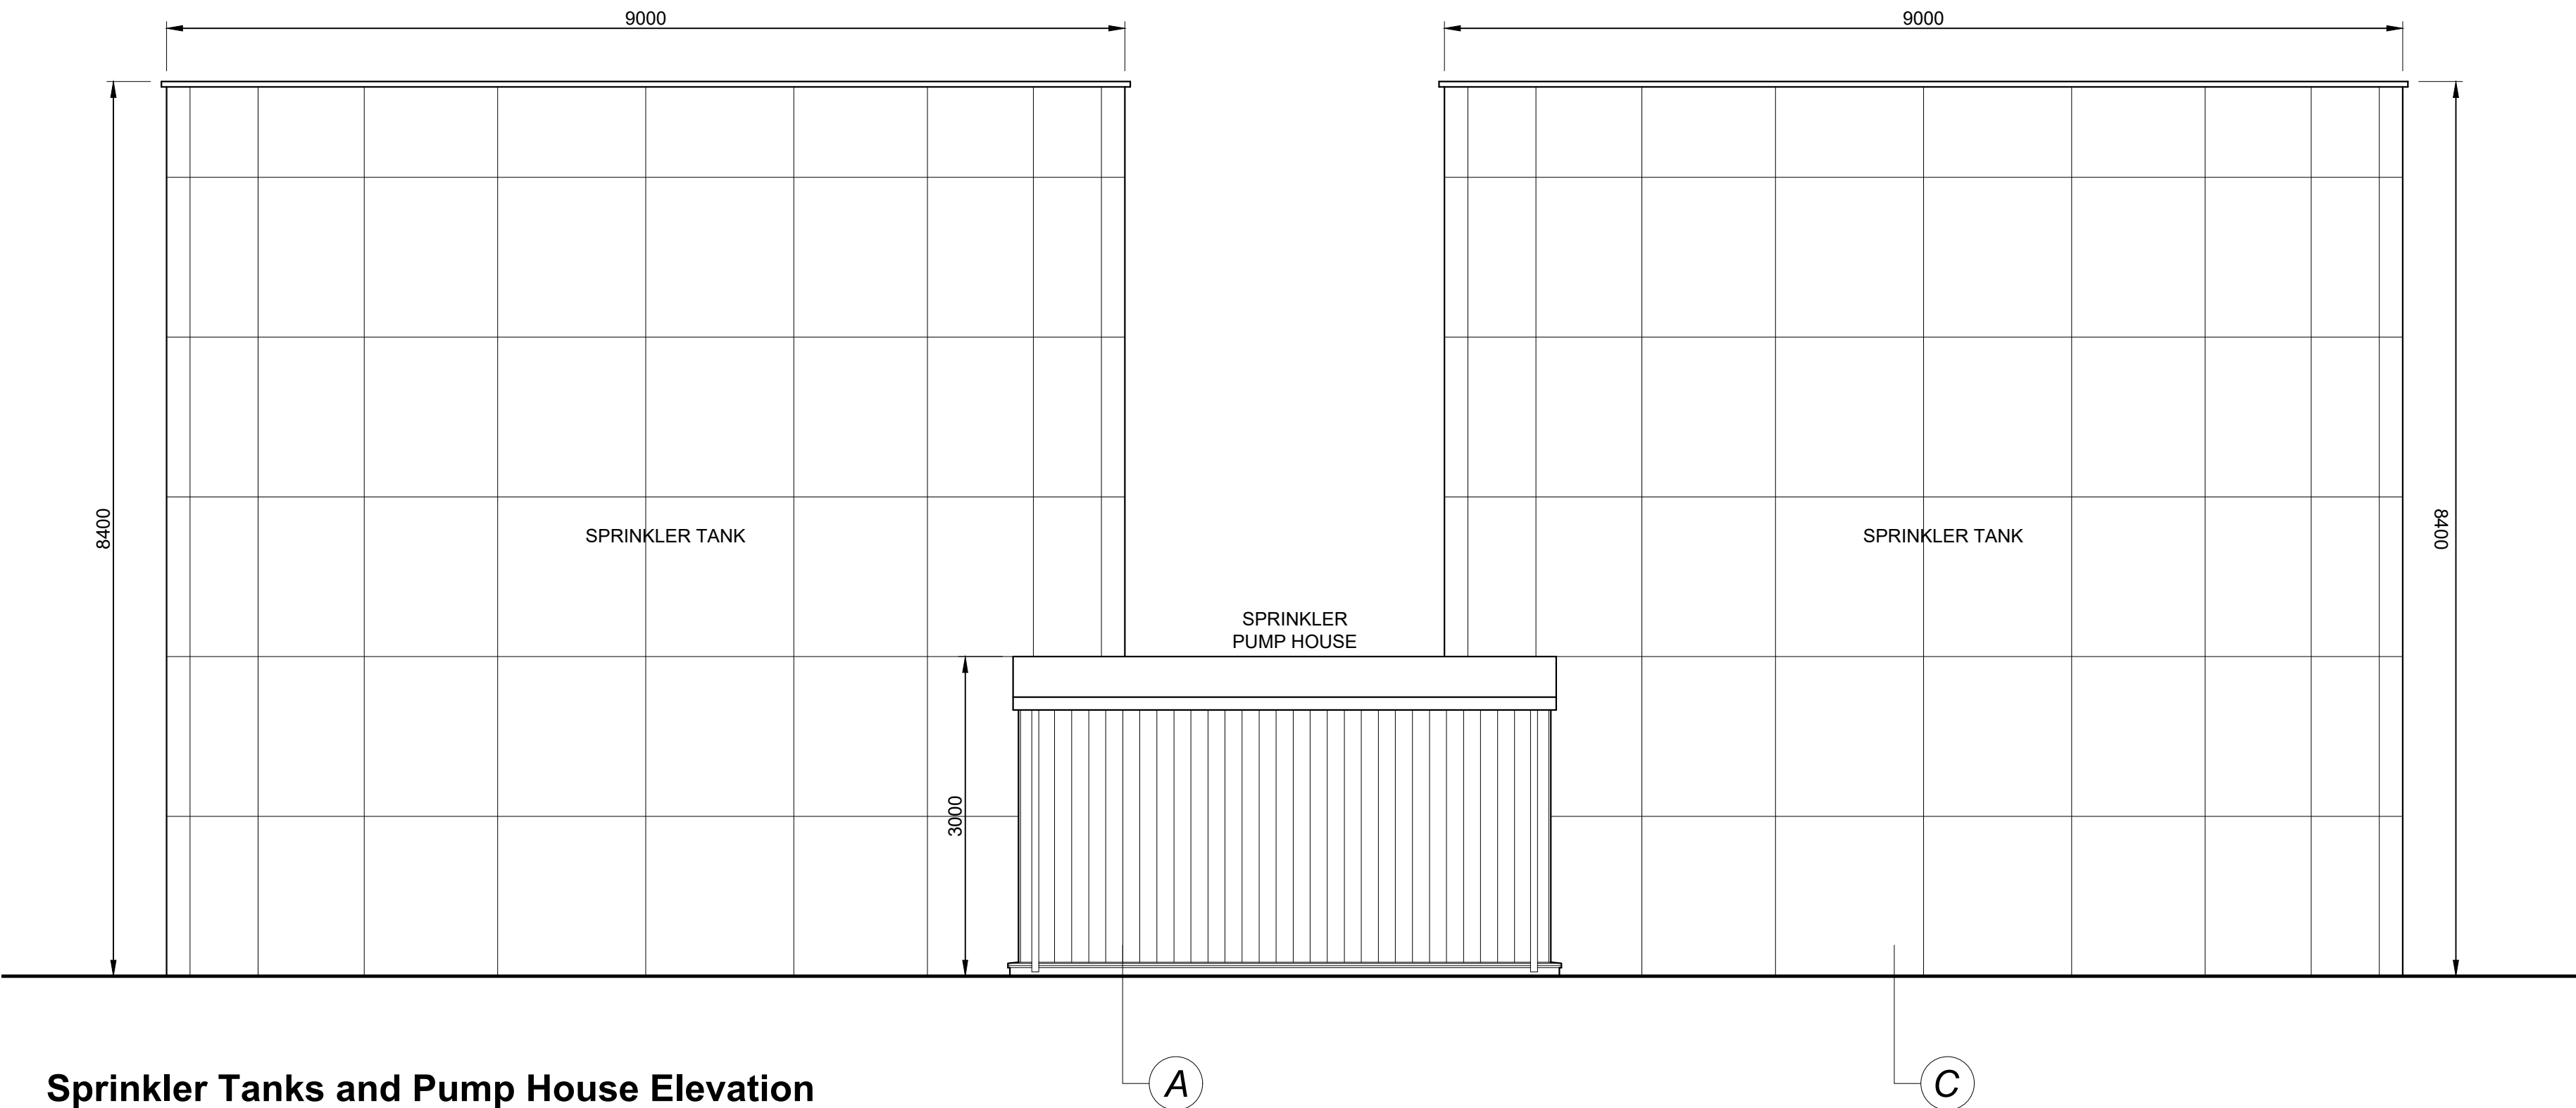

Sprinkler Tanks and Pump House Elevation Scale 1:50

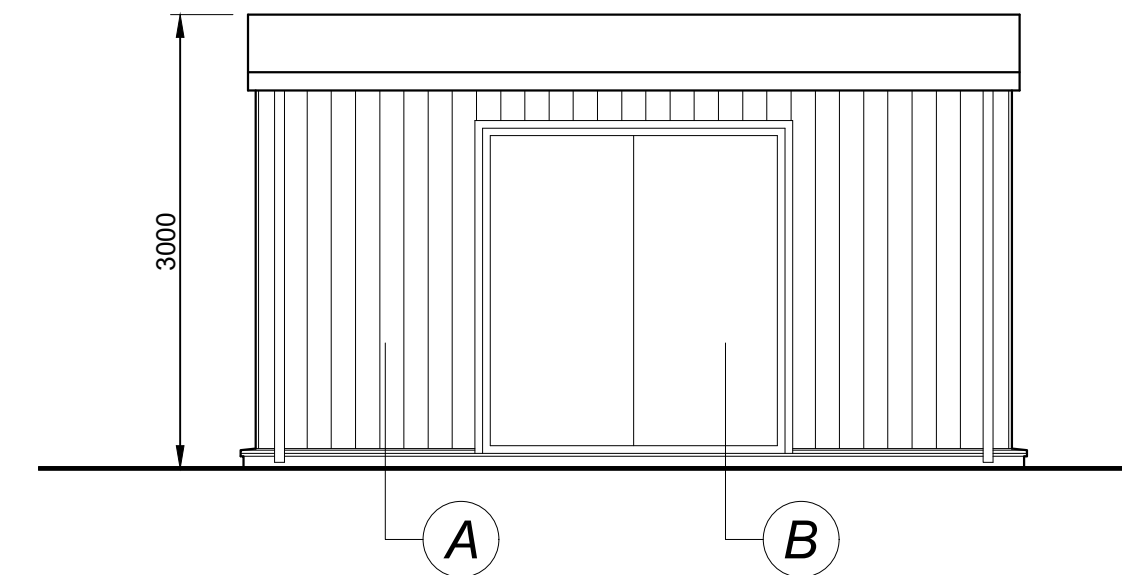


Pump House Elevation

Scale 1:50


External Finishes

- A** Vertically laid
Profiled wall cladding system.
Finish: Tata Colorcoat HPS 200 Ultra.
Colour: Alaska Grey (RAL 7000)
- B** Steel insulated personnel door & frame
Finish: Factory applied polyester powder
coat paint finish.
Colour: Anthracite (RAL 7016)
- C** Galvanised steel water storage tanks
Finish: Factory applied polyester powder
coat paint finish
Colour: Metallic Silver (RAL 9006)

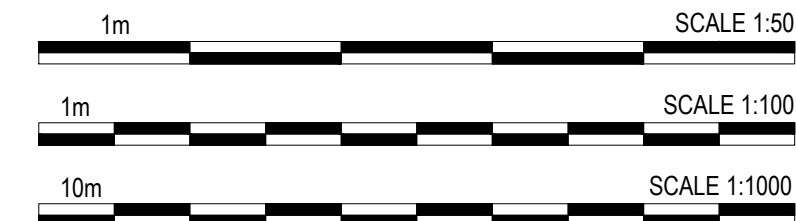

PLANNING
THIS DRAWING IS FOR PLANNING CONSIDERATION ONLY
AND SHOULD NOT BE USED FOR ANY OTHER PURPOSE

- Dimensions are in millimeters, unless stated otherwise.
- Scaling of this drawing is not recommended.
- It is the recipients responsibility to print this document to the correct scale.
- All relevant drawings and specifications should be read in conjunction with this drawing.

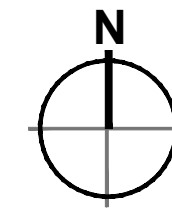

- Application Boundary
- - - Smoking Shelter Location

rev	amendments	by	ckd	date
-----	------------	----	-----	------

Phase 2, Symmetry Park,
Merseyside
Unit 3 - Sprinkler Tank and Pump House

TRITAX SYMMETRY
A TRITAX BIG BOX COMPANY

umc
architects
3rd Floor, Manchester Club, 81 King Street, Manchester, M2 4AH
t: +44 (0)161 413 0590 e: info@umcarchitects.com

Drawing Status:	Planning
Drawn / Checked:	AP / DEB
Date:	28/10/2021
Scale:	As Noted@ A1
Drawing no:	Revision:
21351 P2704	C