



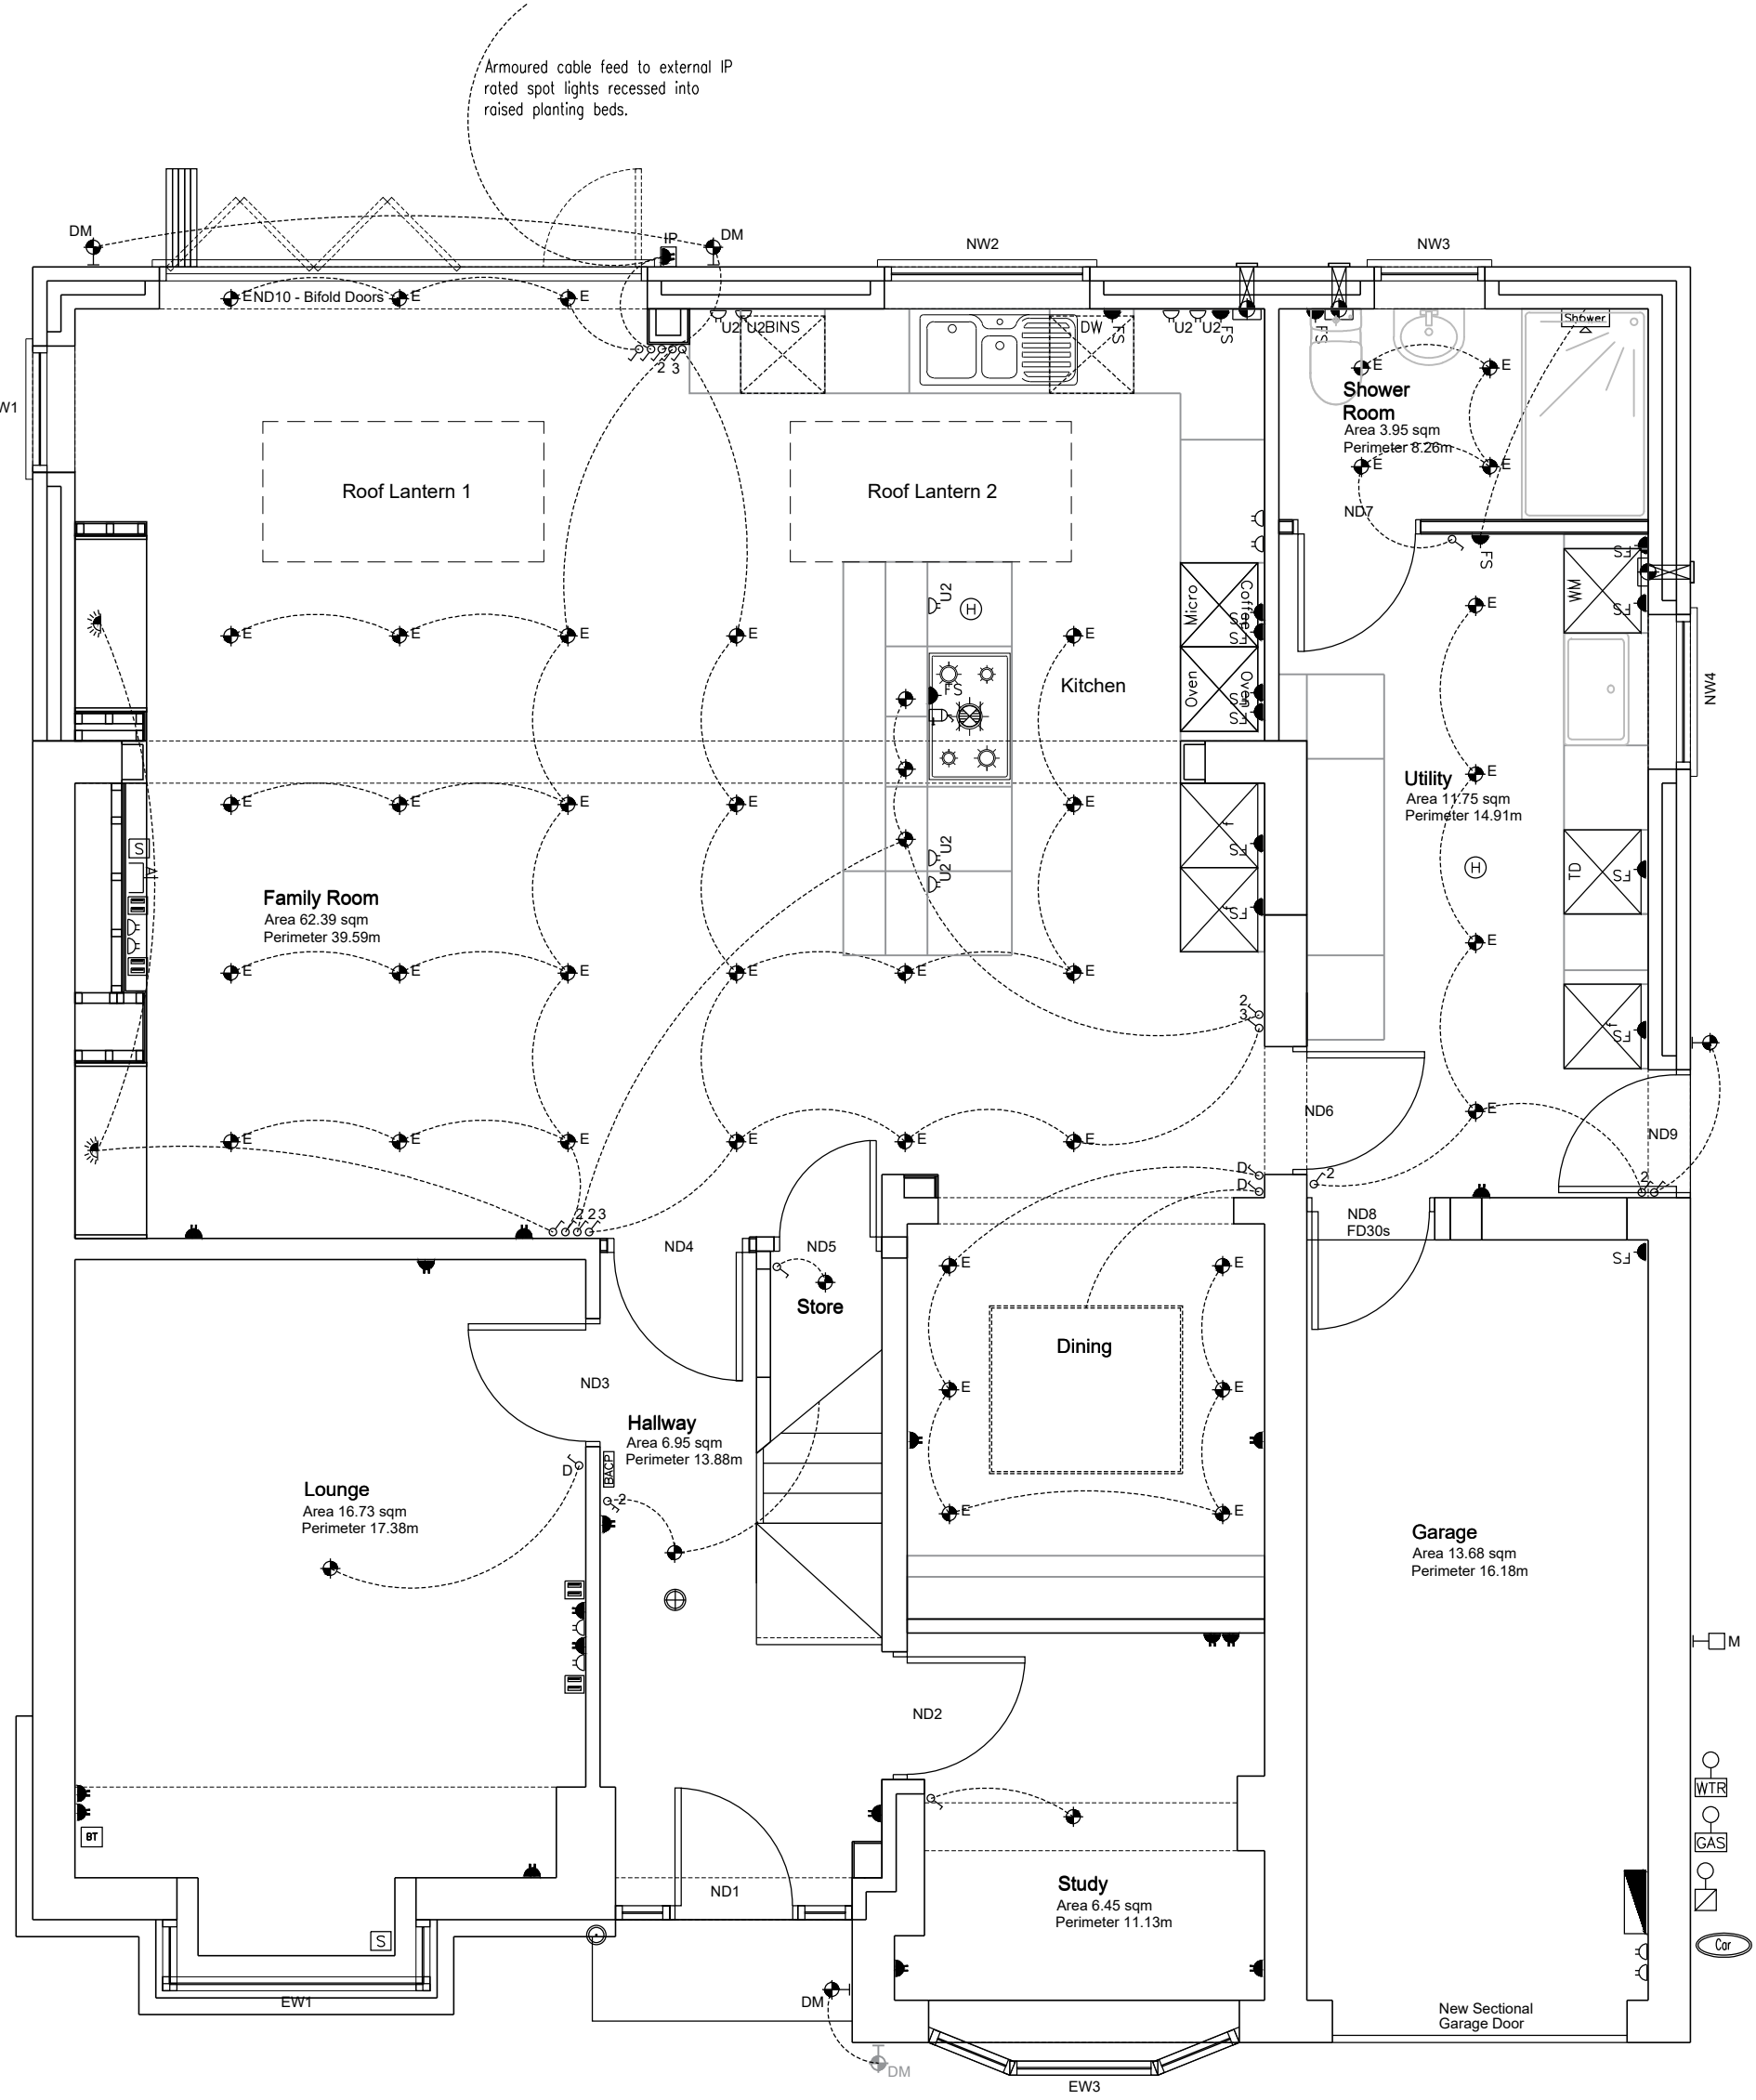

PROPOSED GROUND FLOOR
ELECTRICITY PLAN @ 1:50

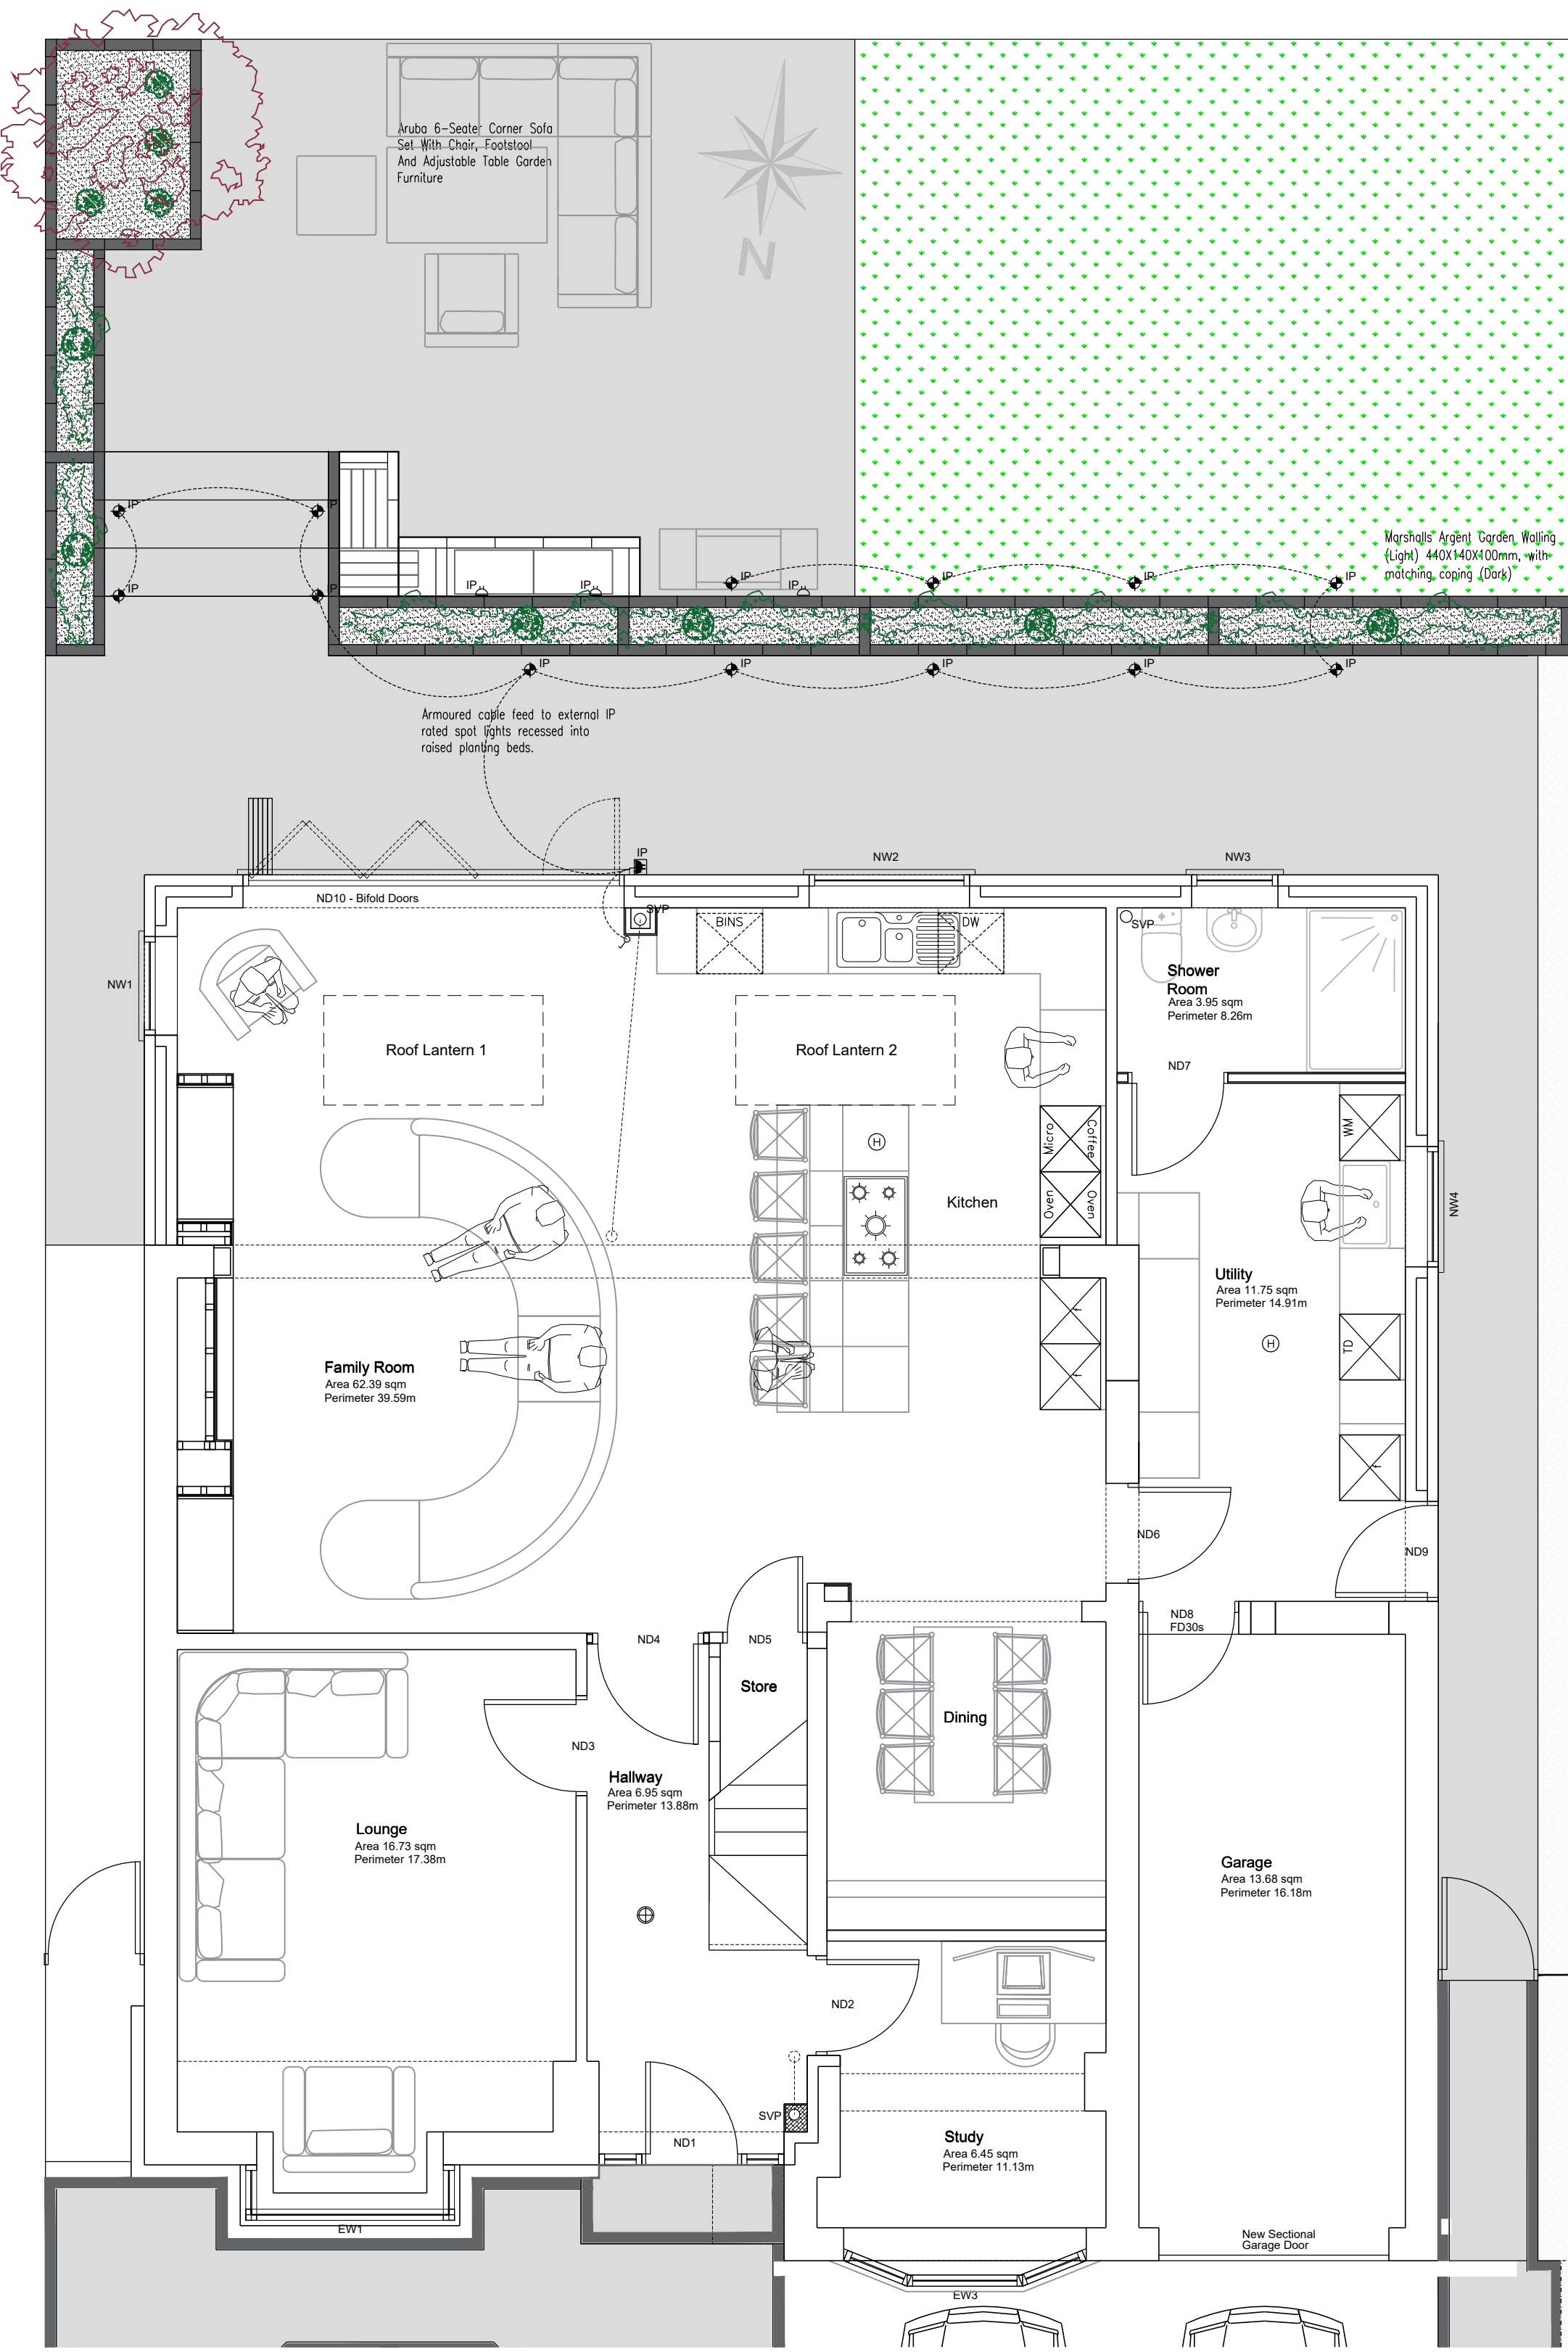

PROPOSED PATIO
ELECTRICITY PLAN @ 1:50

NOTES

ELECTRICAL/PLUMBING LEGEND	
	DISTRIBUTION BOARD
	CAR CHARGE - POD POINT
	ELECTRICITY METER
	WATER INTAKE
	GAS INTAKE AND METER
	LOW LEVEL SWITCHED SO
	HIGH LEVEL SO
	HIGH LEVEL TWIN SWITCHED SO
	U2 = with USB Twin Outlet
	IP RATED TWIN SWITCHED SO
	FLOOR MOUNTED TWIN SWITCHED SO
	USB TWIN SOCKET
	FUSED SWITCHED SPUR
	SHAVEN POINT
	DUAL TOOTHBRUSH CHARGER
	COOKER POINT
	SINGLE GANG LIGHT SWITCH
	DOUBLE GANG LIGHT SWITCH
	3 = 3-way and 2 = 2-way
	D = DIMMABLE
	SINGLE TUBE FLOU'SCENT
	BOILER
	DIGITAL THERMOSTAT
	RADIATOR
	CYLINDER
	RECESSED SPOT LIGHT
	IP = EXTERNAL
	WALL LIGHT D = WITH DUSK SENSOR
	M = WITH MOTION SENSOR
	FLOOD LIGHT M = WITH MOTION SENSOR
	PENDANT LIGHT TO CHANDELIER
	FLOOR MOUNTED UPLIGHTER
	PENDANT LIGHT
	LED STRIP LIGHT
	MECHANICAL EXTRACTOR
	CEILING FAN
	MV = Whole House
	SHOWER
	AERIAL
	BURGLAR ALARM CONTROL PANEL
	PASSIVE INFRA RED SECURITY SENSOR
	CLOSED CIRCUIT TELEVISION CAMERA
	CCTV CONTROL UNIT
	CCTV MONITOR
	BELL PUSH
	SATELLITE POINT WITH INFRA RED CONTROL PANEL
	TELEPHONE POINT
	SMOKE DETECTOR
	HEAT DETECTOR & CO ALARM
	FD30s

ISSUED FOR CONSTRUCTION

01	Feb25	Korniche style roof lantern added. Recessed spotlight numbers have reduced including additional single light switch		JS	JS
REV	DATE	DESCRIPTION		DRAWN	CHECKED
ORIGINAL SIZE		SCALE	DATE		
A1		1:50	Feb 2025		
CLIENT	Jay & Laura Siadankay 10 Lloyd Road, Prescott, L34 6LG ---				
LOCATION	10 Lloyd Road Prescot, Knowsley, L34 6LG				
DRAWING TITLE	PROPOSED LAYOUT SERVICES – ELECTRICS				
DRAWING NUMBER	LloydRd/Ext/T/07/Con			REVISION	10/1
Jay Siadankay 10 Lloyd Road, Prescott, Knowsley, L34 6LG MOB: 07843164132 - E-Mail: j.siadankay@btinternet.com					