


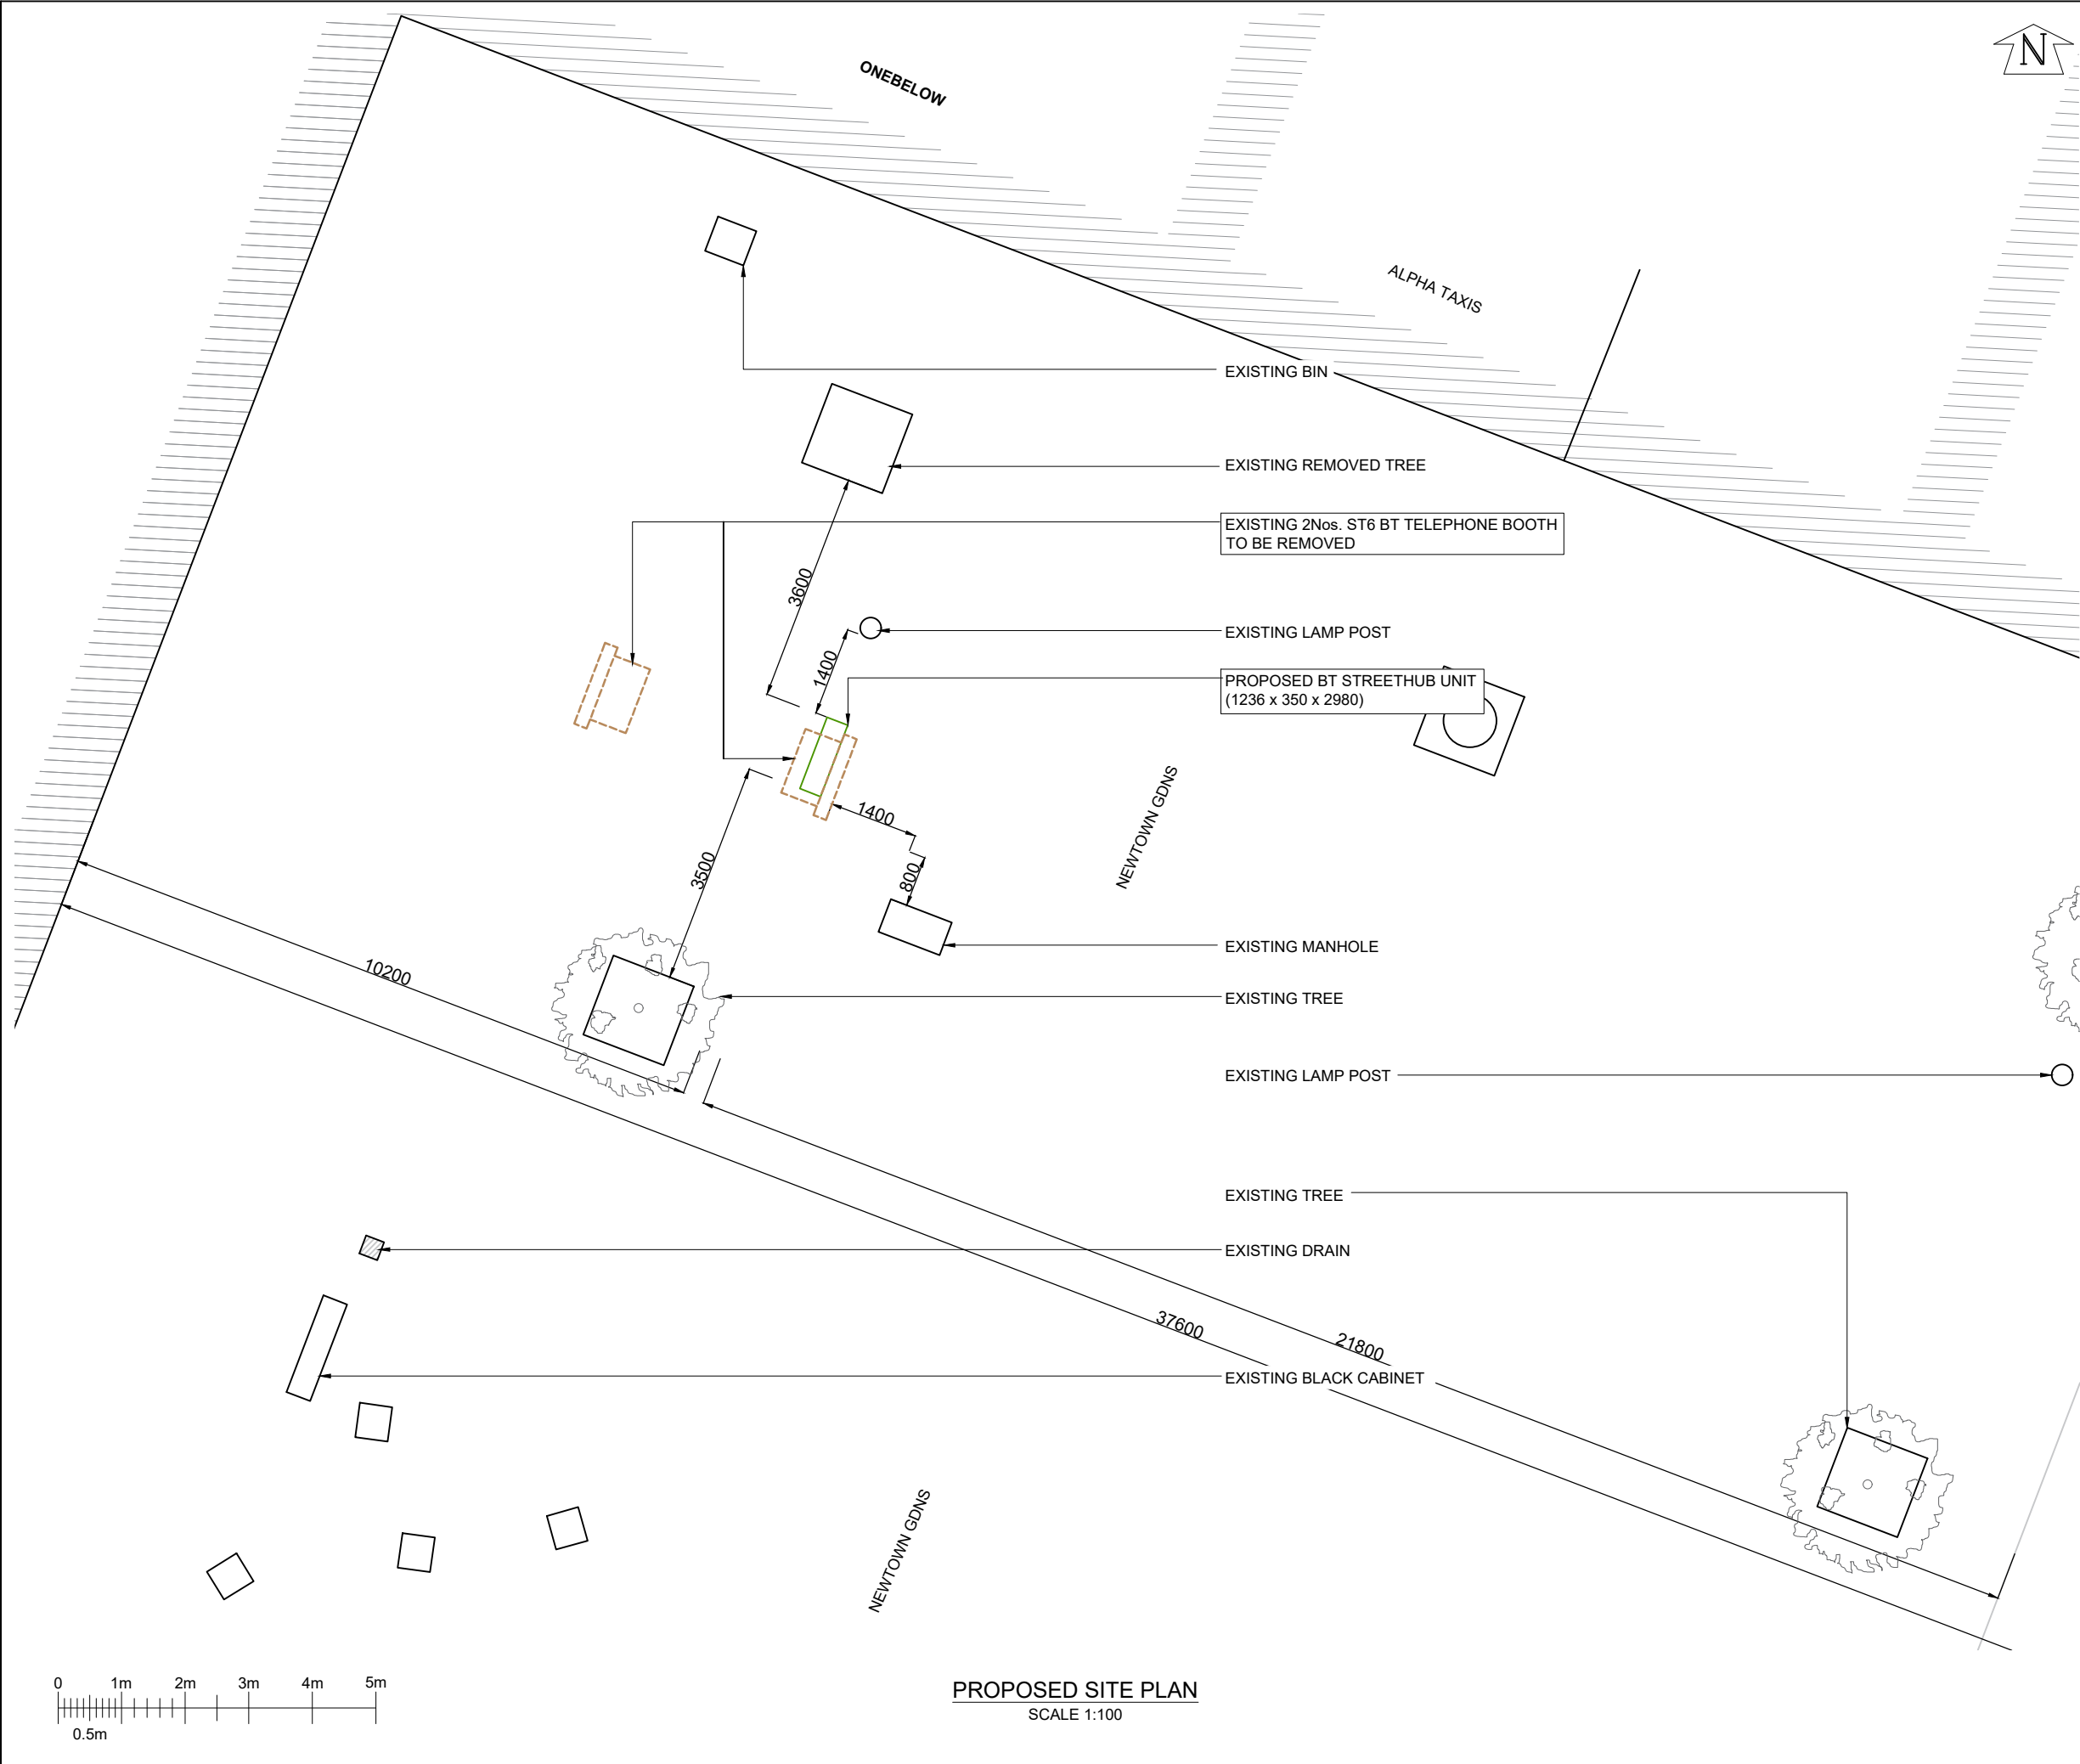

GENERAL NOTES

Use written dimensions only, do not scale from drawing. Use latest revision of all referenced information.

| A   | 24.02.22 | New BT Streethub Structure | MD    | JE   |
|-----|----------|----------------------------|-------|------|
| Rev | Date     | Description                | Drawn | Chkd |

mono

#

MONO CONSULTANTS LIMITED  
70-76 Steam Packet House  
Cross Street  
Manchester, M2 4JG  
t. 44 (0)161 839 8839  
www.monoconsultants.com

BT

Drg Status

PLANNING

Cell No. & Name

KNOW008

Site Name & Address

St Chad's Parade, Kirkby Town Centre, Liverpool, L32 8RH

Drawing Title

PROPOSED SITE PLAN

|                |       |            |            |
|----------------|-------|------------|------------|
| Scale          | 1:100 | Date       | 24.02.2022 |
| Drawn By       | MD    | Checked By | JE         |
| Drawing Number | 002   | Revision   | A          |