
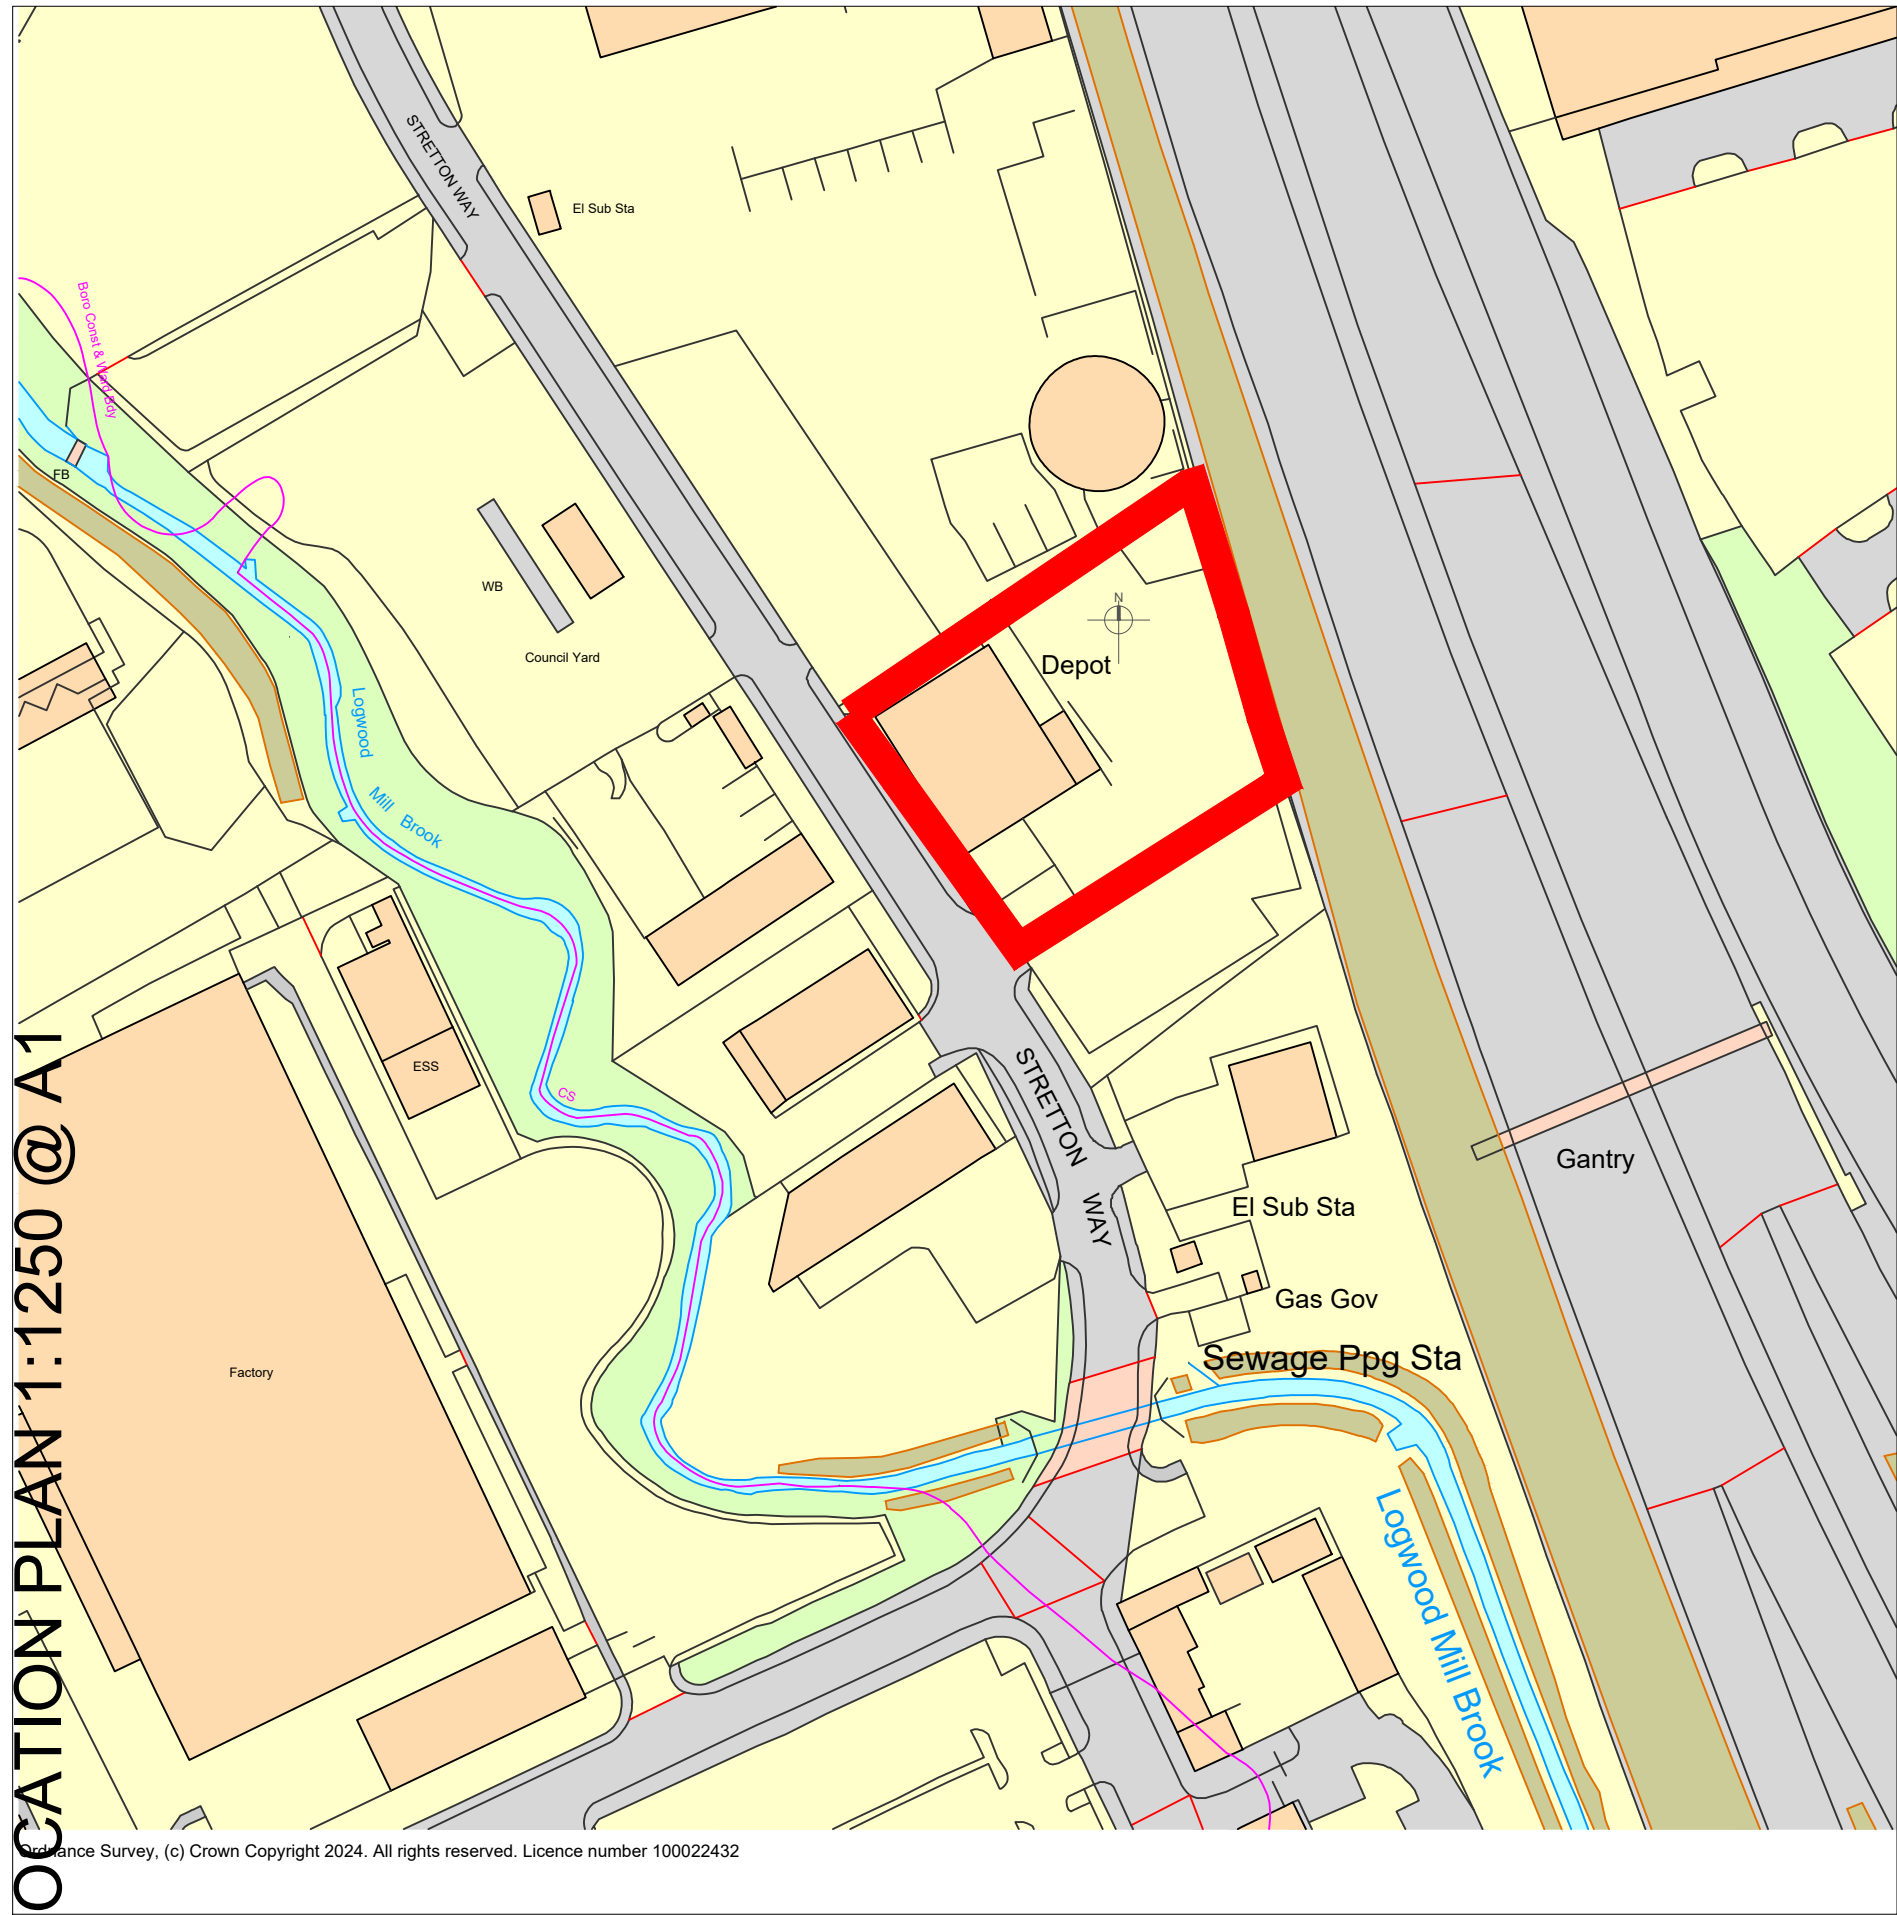


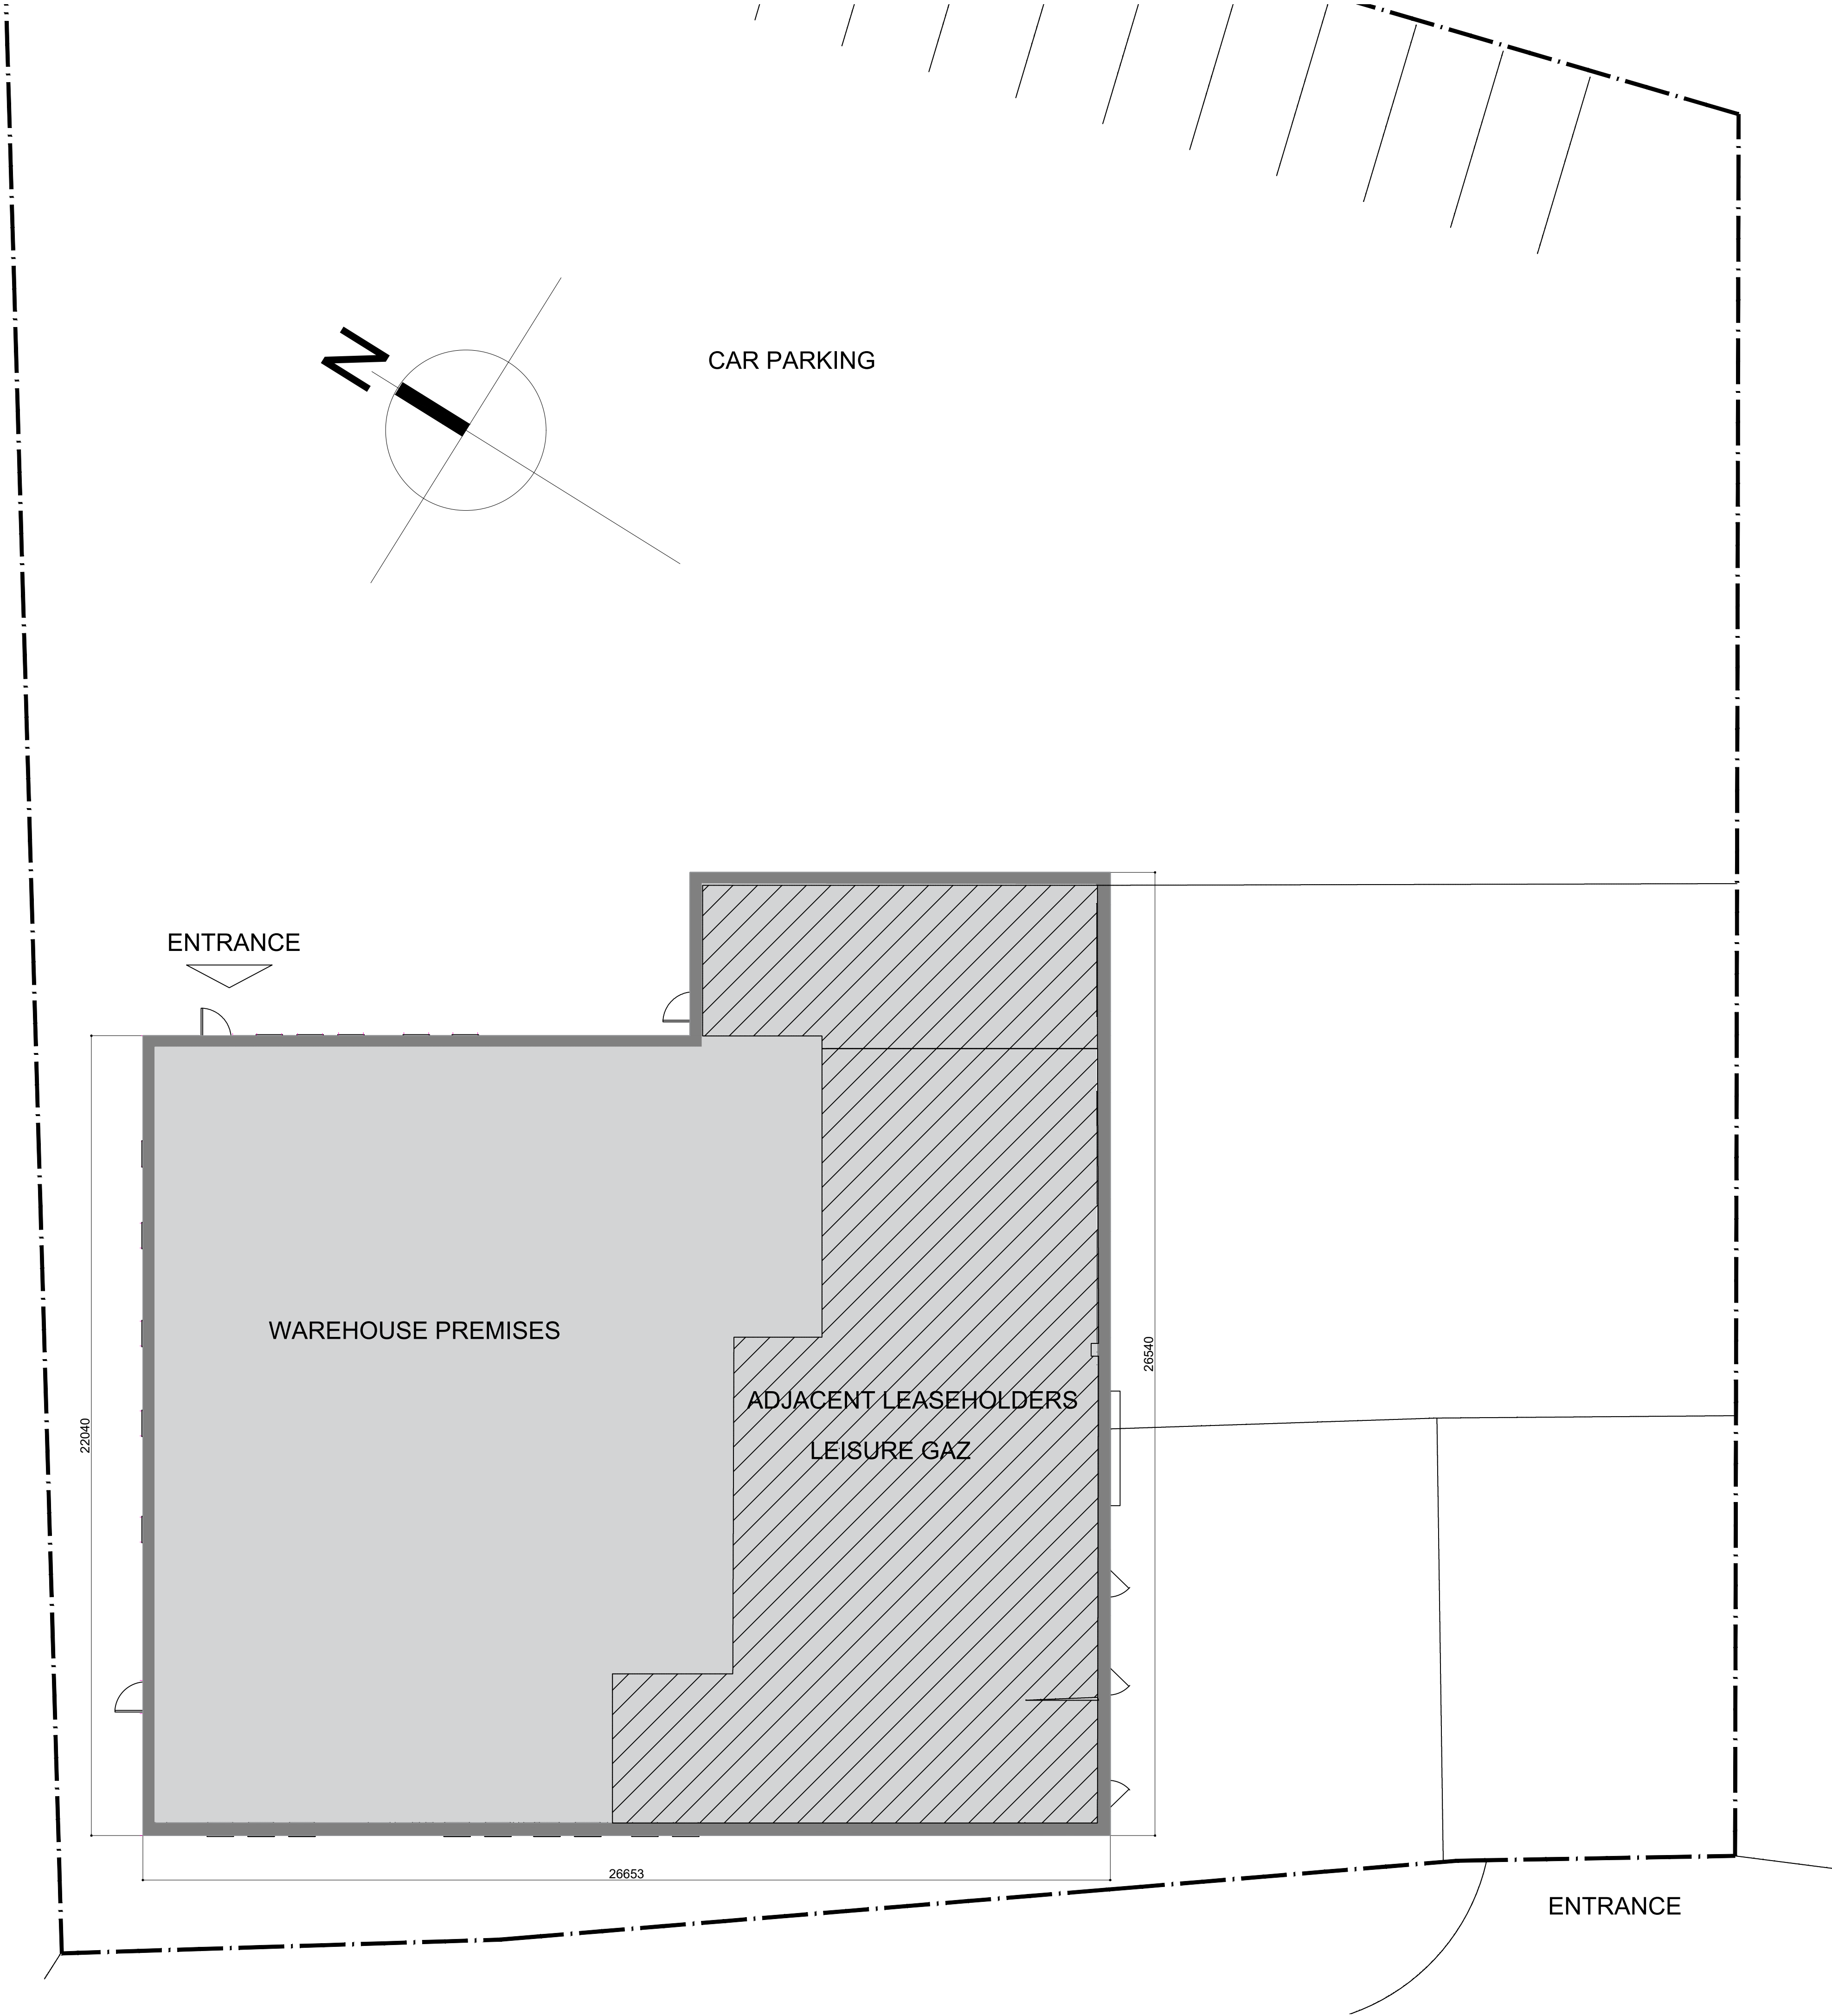

rev	date	name	chk	note
-----	------	------	-----	------

A MAC Design Consultancy Services Ltd,
7 Harp Lane, 7th Floor
London, EC3R 6DP

A MAC Design Consultancy Services Ltd,
Bell House
Seabrook Place, Knowlhill
Milton Keynes MK5 8FX
T: 01908 231297

W: www.maconconsultingtd.com
E: contact@maconconsultingtd.com

A1
Original Sheet Size

STATUS

- © MAC DESIGN CONSULTANCY SERVICE LTD.
- No part of this drawing may be reproduced without written consent.
- Where dimensions are not given, drawings must not be scaled and the matter referred to MAC.
- In the event of any dimensional conflict between MAC drawings, the matter must be referred to MAC for clarification.
- All contractors must visit site and be responsible for taking and checking all dimensions relating to the work. Any discrepancies in dimensions or details on or between these drawings/specifications should be drawn to the attention of the MAC and/or the engineer in writing for clarification.
- Do not scale from this drawing and work from figured dimensions only.

HUYTON AMBULANCE STATION
1-2 STRETTON WAY, HUYTON, LIVERPOOL

NORTH WEST AMBULANCE SERVICE NHS TRUST

DRAWING TITLE
LOCATION PLAN & EXISTING SITE PLAN

SCALE	DATE	DRAWN	CHK
1:100/1250 @ A1	January 2025	ss	nm
DRAWING NUMBER		REVISION	
58020-PL -100		-	

scale bar 1:100 @ A1

