

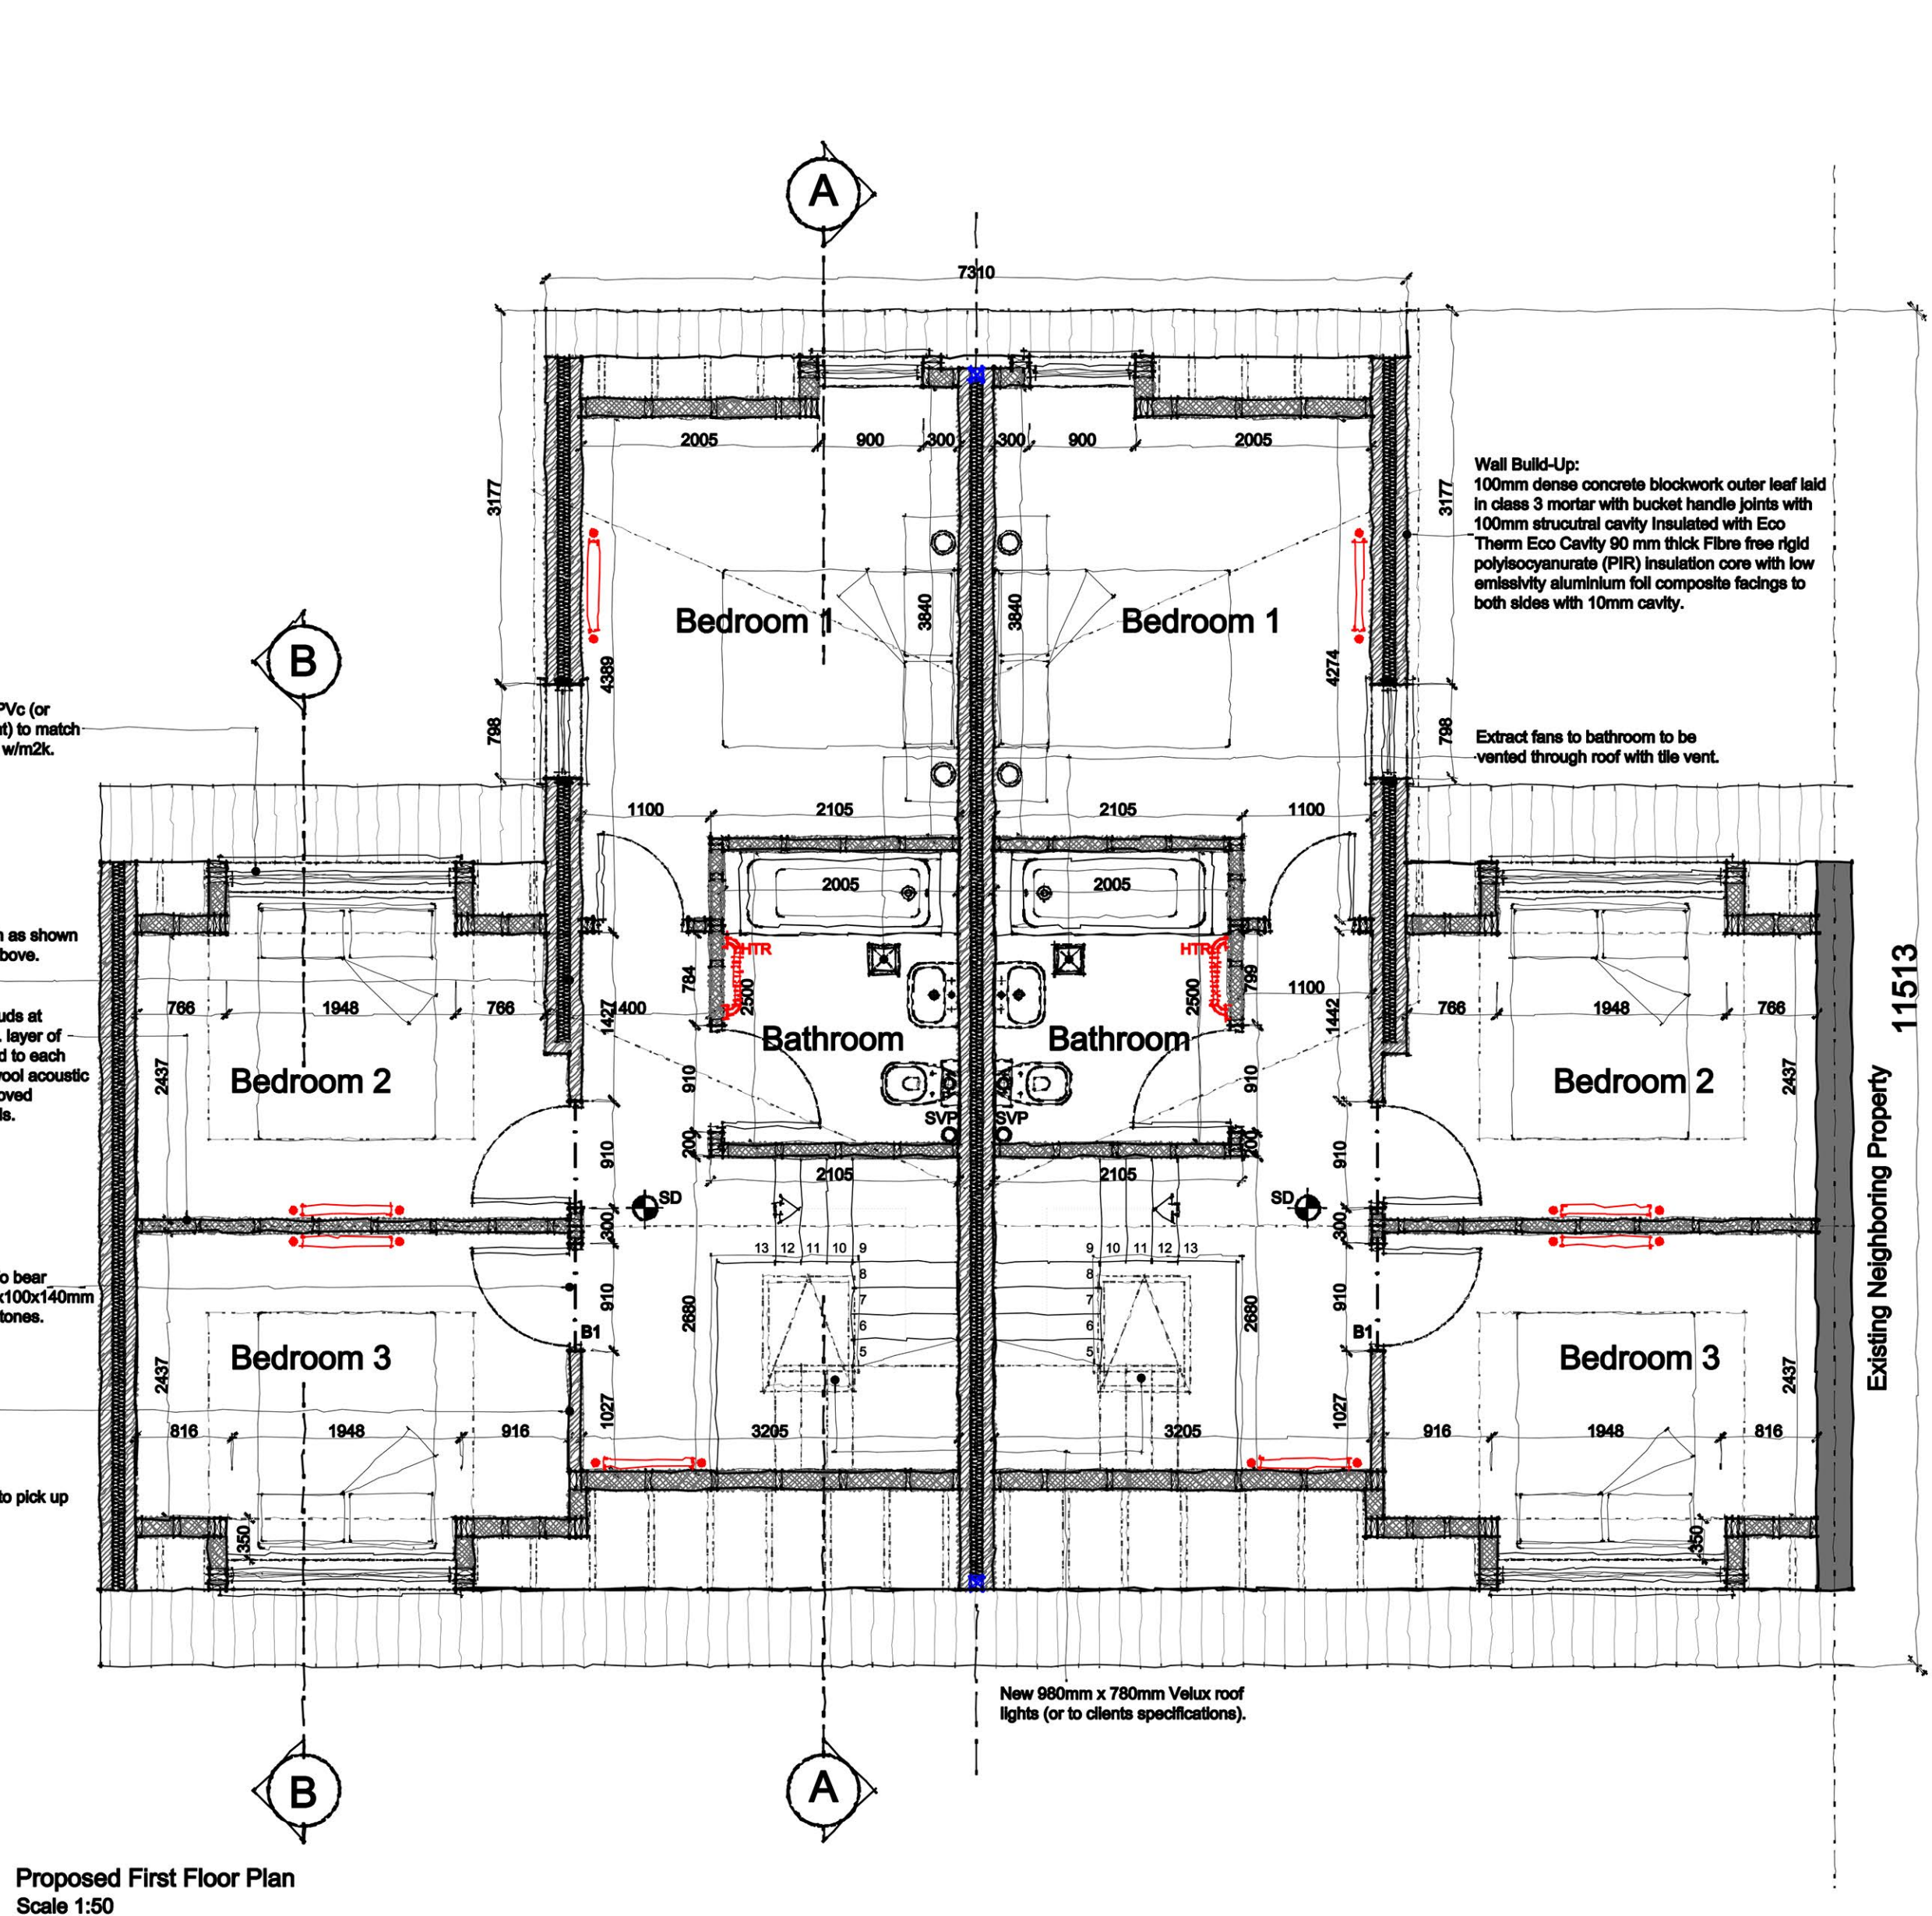


NOTES
All dimensions to be checked on site. Figured dimensions to be read in preference to scaled. Keith Davidson Partnership accepts no responsibility for any unauthorised amendments to the drawing and does not permit unauthorised copying of the drawing. This drawing is copyright and remains the property of Keith Davidson Partnership unless otherwise agreed.


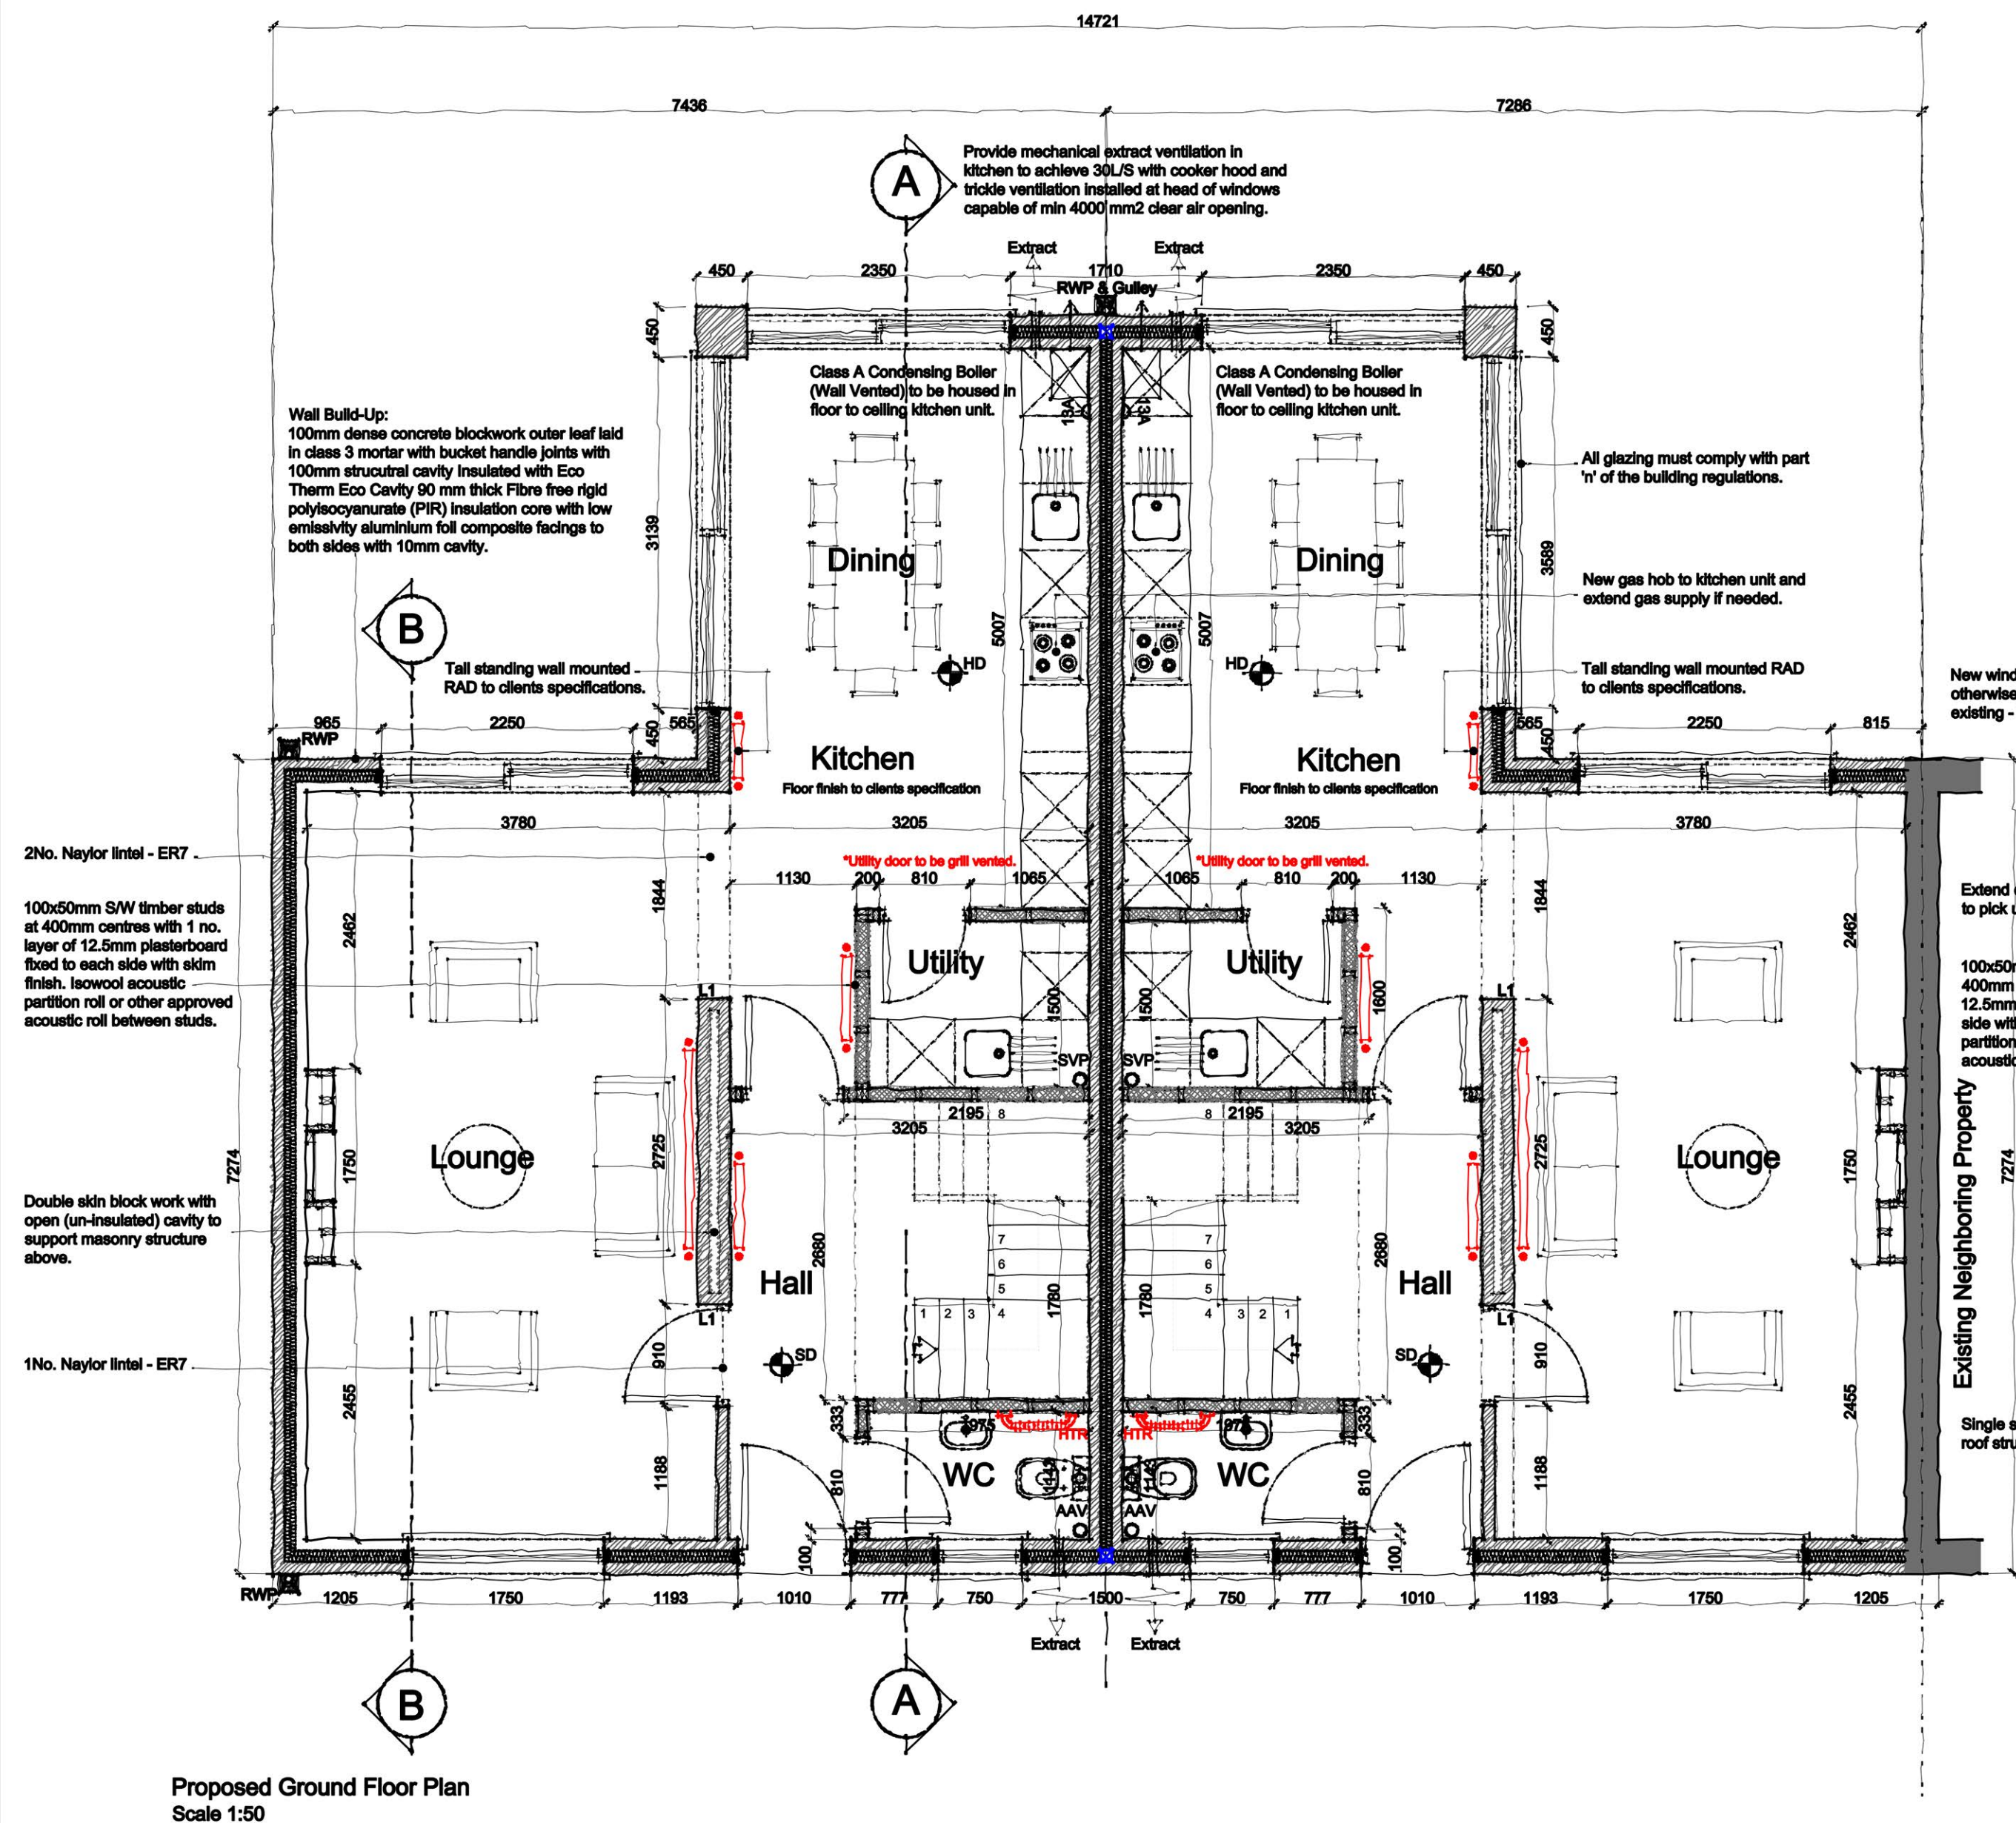


ACCESSIBLE CONTROLS

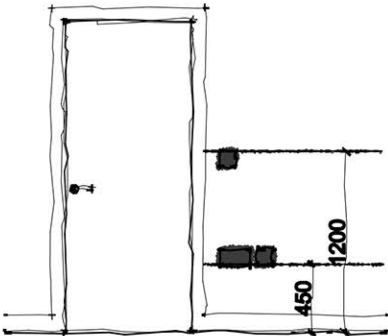

ELECTRICAL LEGEND

SYMBOL	DESCRIPTION
	Consumer Unit
	Telephone Point
	Television Point
	Double Socket 450mm above floor
	Double Socket 1050mm above floor
	Single Socket 450mm above floor
	Switched Fused Spare 1050mm above floor
	Light Switch 1200mm above floor
	Drop Pendant Light Fitting
	Spot Light
	Directional Spot Light
	Extract Fan (Bathroom & W.C. to have Isolator switch above doorway)
	Duct through Roof with Slate Vent
	Class A Condensing Boiler (Wall Vented)
	Thermostat
	Heat Detector
	Smoke Detector interlinked at ground and first floor
	External / Internal Wall Mounted Light Fitting
	Sodium Floor Light fitted with Time Clock
	Radiator
	Heated towel rail
	Megaflo 300 Litre Hot & Water Storage

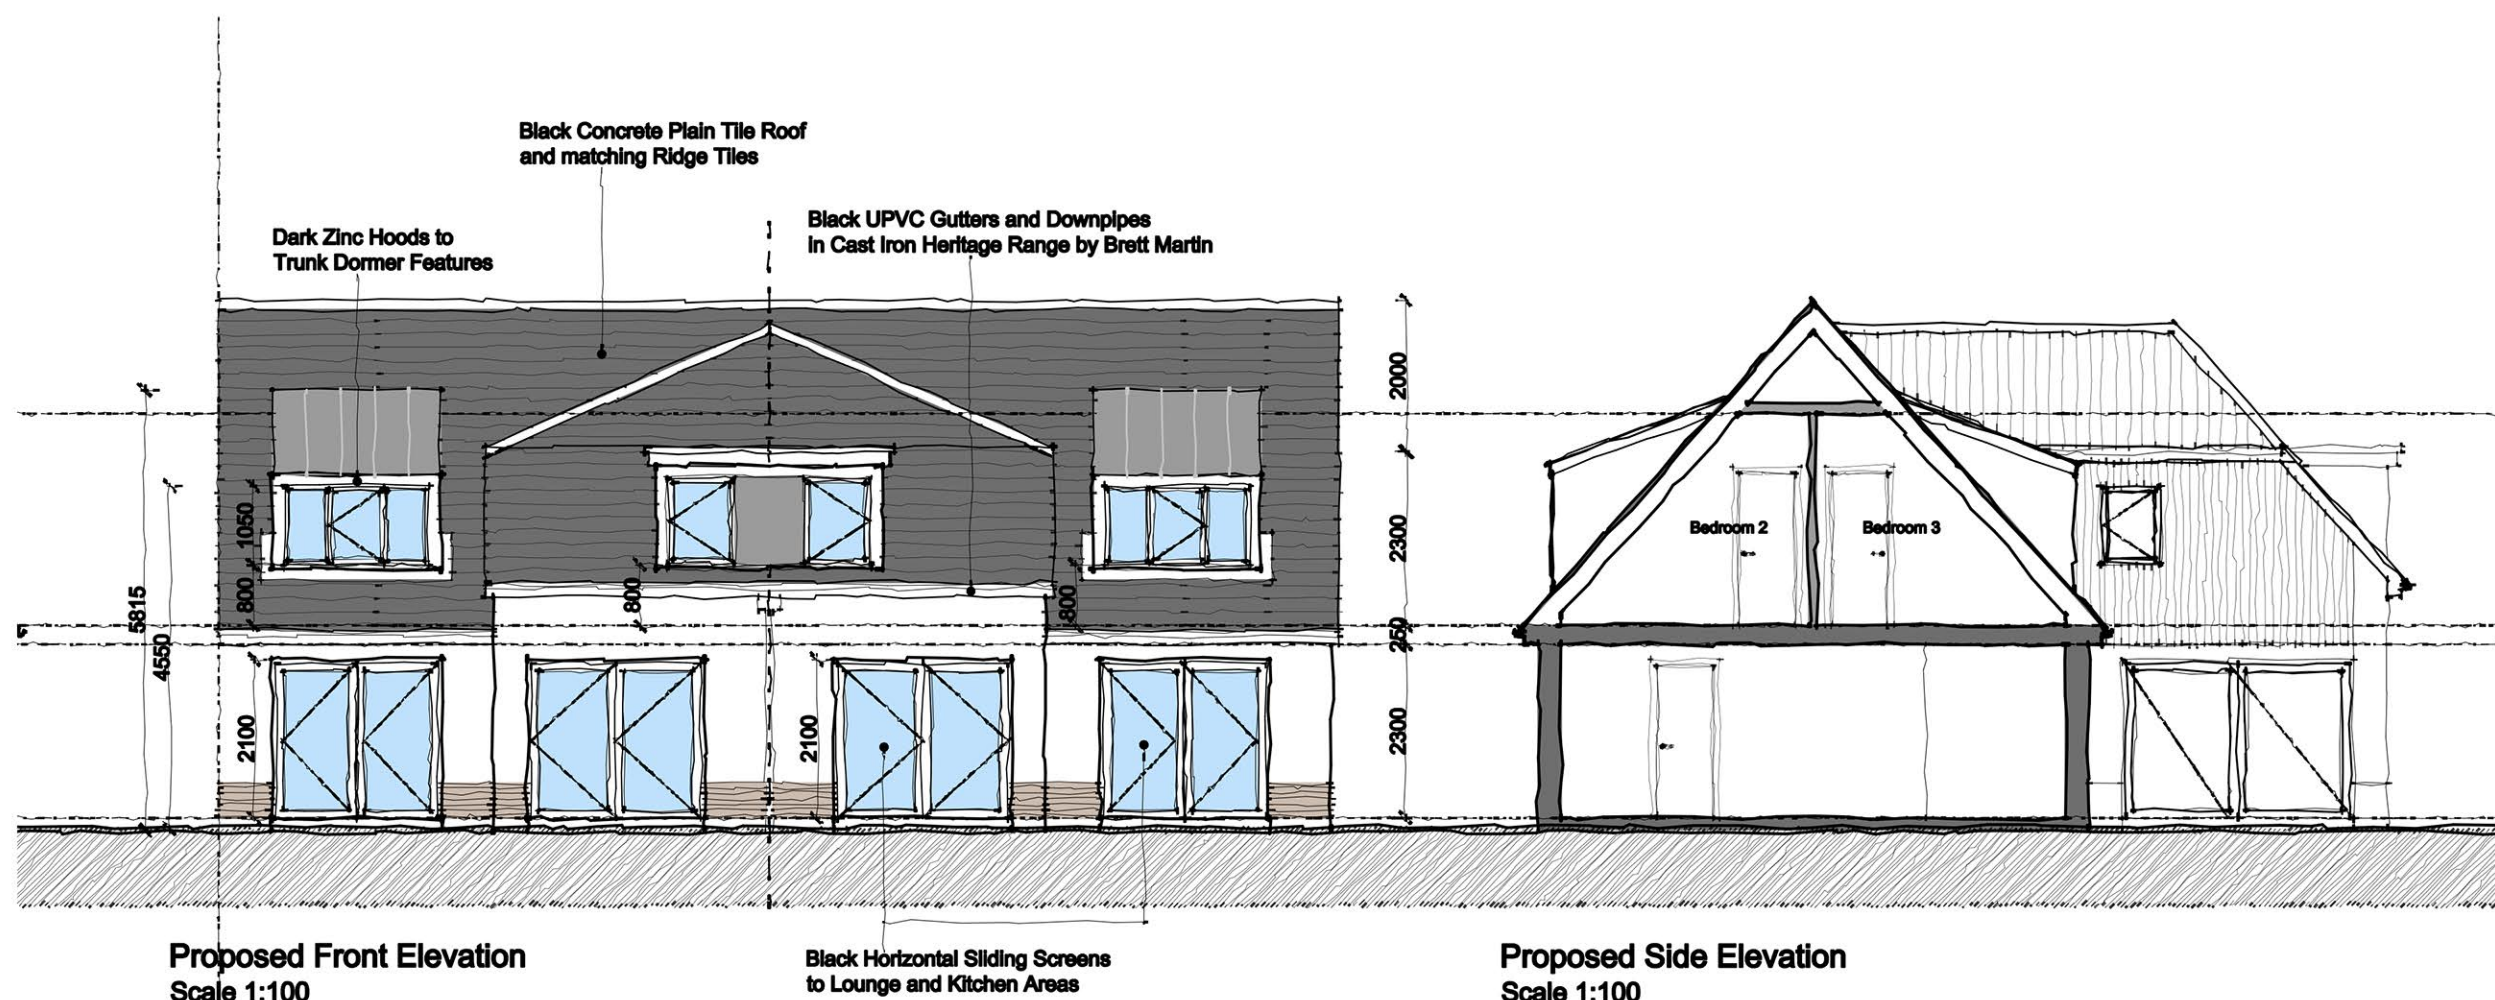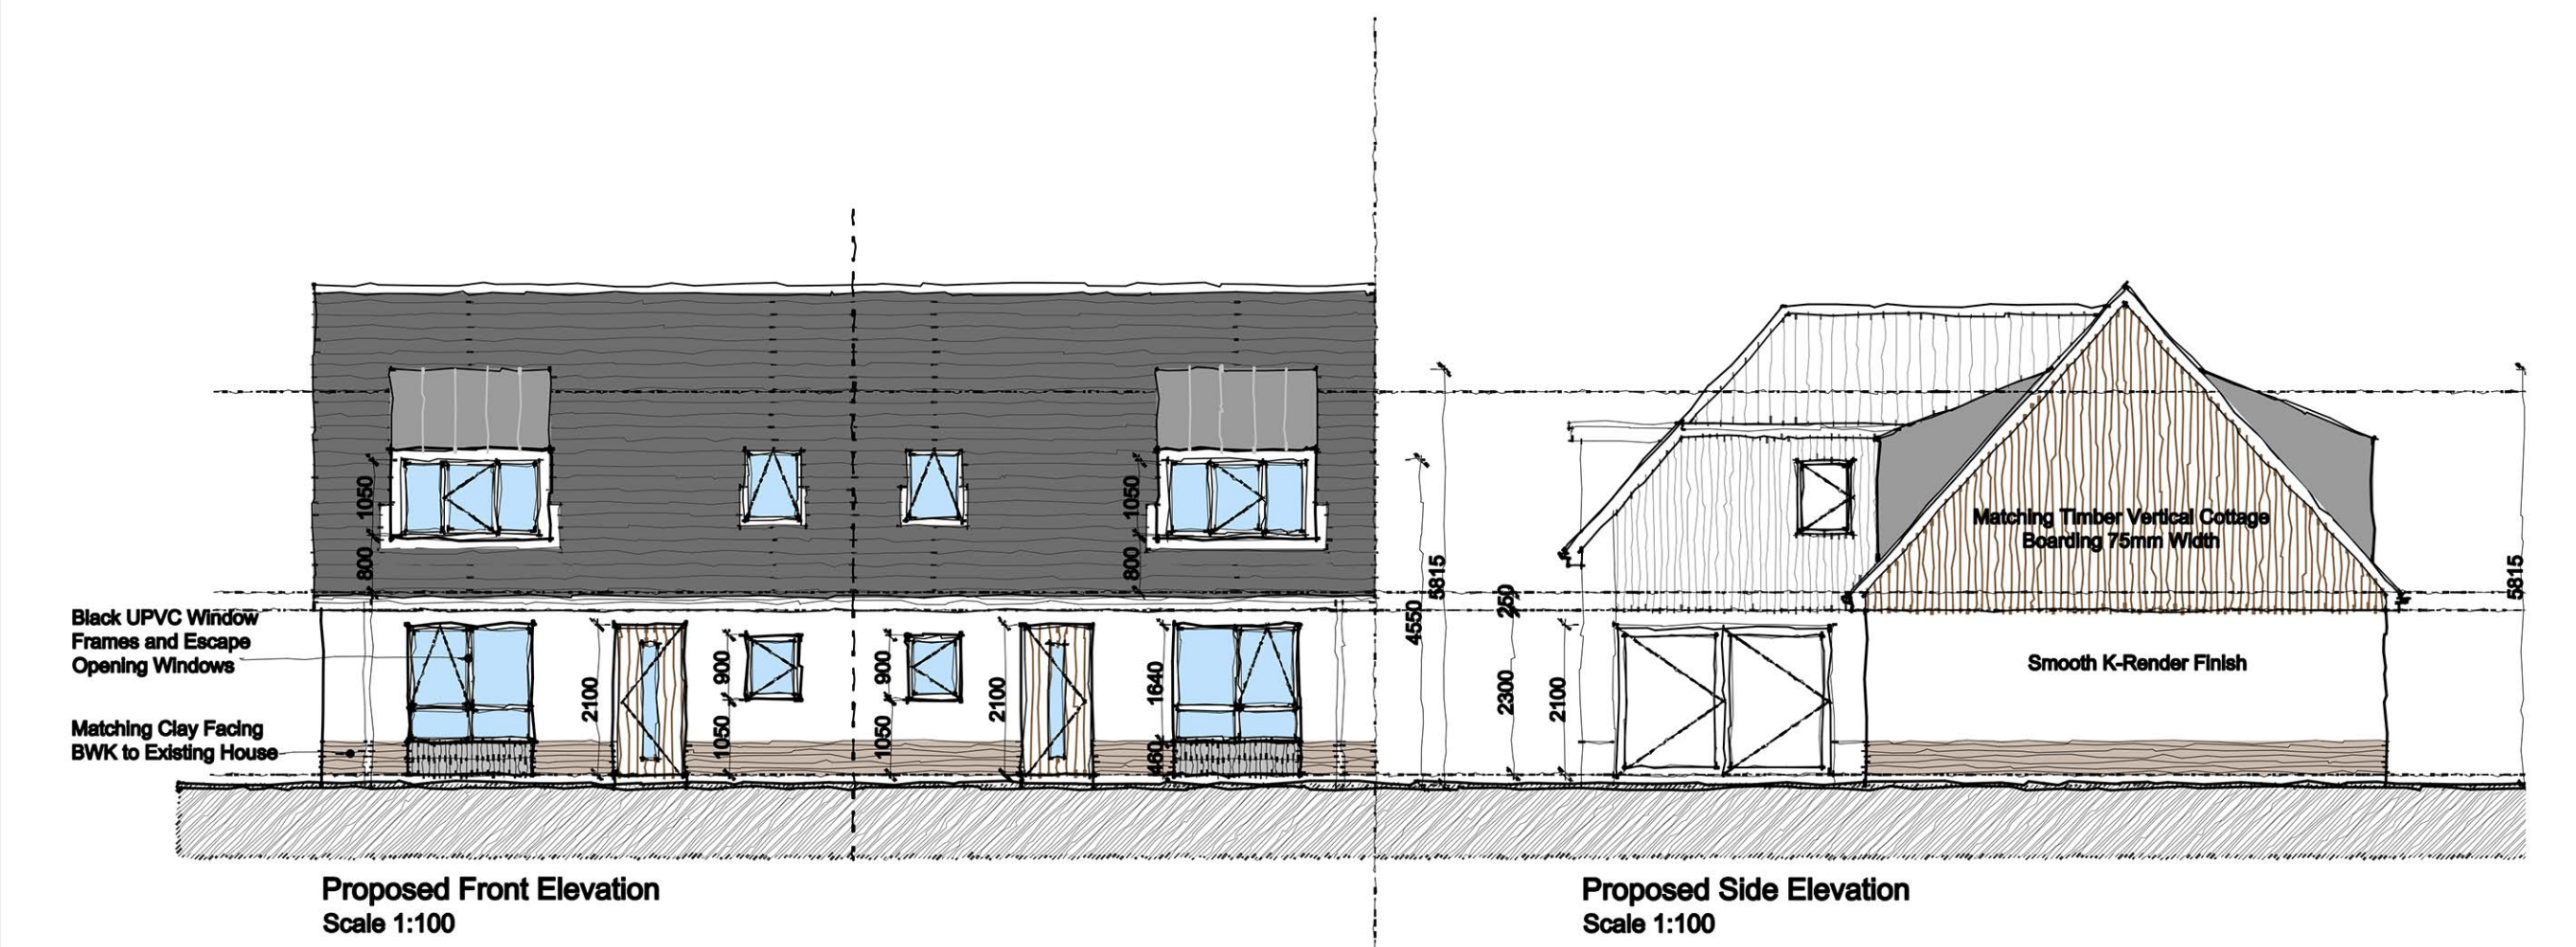

Version | Amendment | Drawn & Date | Checked & Date | Approved & Date

KeithDavidsonPartnership

13 Seymour Terrace
Seymour Street
Liverpool
L3 5PE

Telephone : +44 (0) 151 709 1777
Email : info@keithdavidsonpartnership.com
Web : keithdavidsonpartnership.com

Internal Project Number
GEN-SC
Client
TBC
Project Name
Smithy Close, Cronton

Drawing Title
Existing & Proposed Plans

Scale 1:100/1:50	Original Size A1	Planning	
Date 28.09.20	Drawn CW	Checked GNP	Approved GNP
Drawing Number		Status	Revision

200