
 


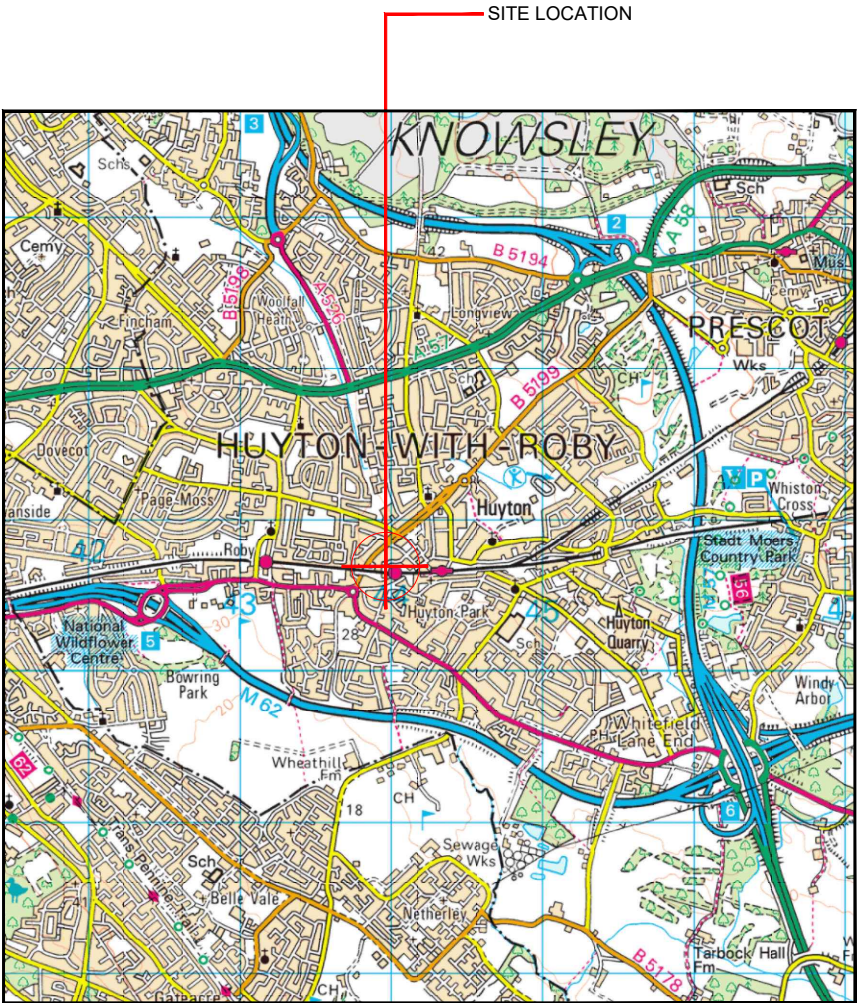


SITE AREA PLAN

Scale 1:50,000




SITE PHOTOGRAPH

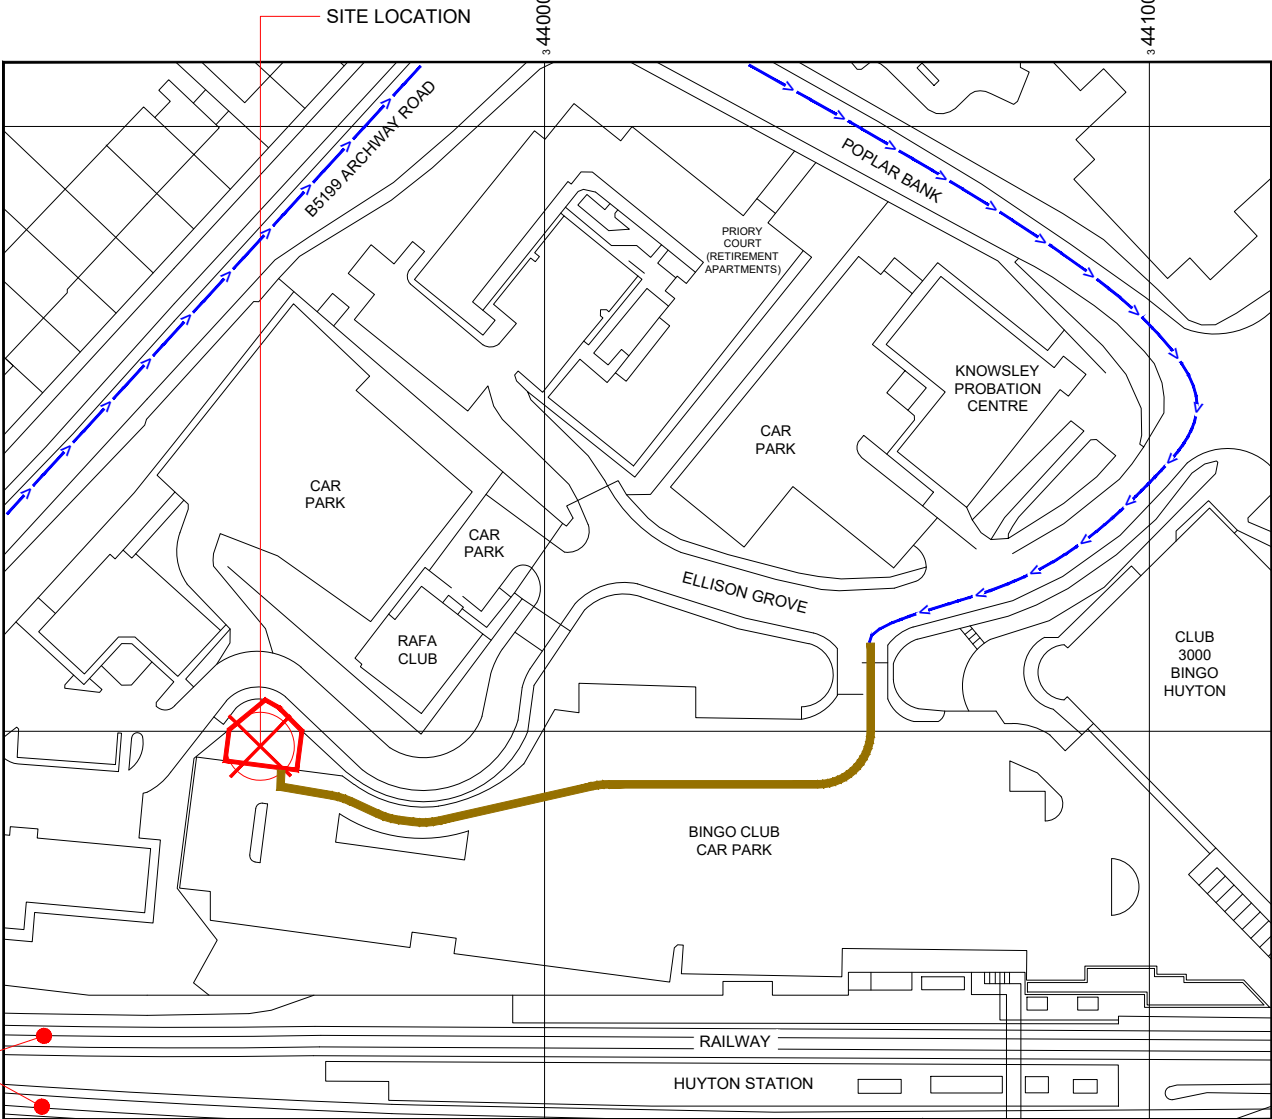

SITE LOCATION PLAN

 Scale 1:1250



GOOGLE MAPS QR CODE

GOOGLE MAP - Hyperlink to map of the site

GOOGLE STREETVIEW - Hyperlink to streetview of the site

NOTES:

1. ALL DIMENSIONS IN MM UNLESS OTHERWISE NOTED.

From M62 junction 5 take the A5080 towards Huyton. At the first roundabout turn left onto the B5199. At the traffic lights turn right onto Poplar Bank. Take the first right onto Ellison Grove. Take the first left into the Bingo club car park and turn right. The site is located at the far end of the car park on the right.

Site Provider's
Property Boundary:
Access Route To Site:
Access Route:



Master:	MBNL / EE / H3G:	Project:	Purpose of Issue:	Issue:
M001	MBNL	NTQ	Planning	A
Date:	14/04/22	Revision / Upgrade Description:		
Drawn:	J. BOOTE	First Issue		
Checked:	J. STOCKDALE			
Approved:	J. STOCKDALE			
 Hutchison 3G UK Limited Star House, 20 Grenfell Road Maidenhead, SL6 1EH Tel: 01628 765 900 Fax: 01628 765 901 H3G Base Station Information line: 0845 6043000 Available from 8pm Monday to Friday		 Hatfield Business Park Hatfield Hertfordshire AL10 9BW Tel: 01707 315000 Fax: 01707 319001		



Mobile Broadband Network Limited
Sixth Floor, Thames Tower, Station Road, Reading, RG1 1LX

Design Consultant & Principal Contractor:



WHP Telecoms
Unit 1 Maple Park,
Low Fields Avenue, Leeds
LS12 6HH

Tel: 01133023550
e-mail: info@whptelecoms.com

Site Name:	CLUB 3000 BINGO HUYTON		
Site ID:	1668316		
Address:	CLUB 3000 BINGO HUYTON, POPLAR BANK, HUYTON, LIVERPOOL, MERSEYSIDE, L36 9US		
Title:	002 SITE LOCATION PLAN		
Project:	NTQ		
Purpose of Issue:	GENERAL ARRANGEMENT		
EE Cell ID:	96147	MBNL Cell ID:	KSY093
3UK Cell ID:			-
Master Drawing No:	1668316_KSY093_96147_M001		Issue: A

Asset Reference	Asset Description:	Asset Status:	Antenna / Dish / MHA / RRU / Equipment Access Description:	Asset Reference	Asset Description:	Asset Status:	Antenna / Dish / MHA / RRU / Equipment Access Description:
A1-A2	Antenna	Proposed	Rigger access only	RA1-8	RRU	Proposed	Rigger access only
B1-B2	Antenna	Proposed	Rigger access only	RB1-8	RRU	Proposed	Rigger access only
C1-C2	Antenna	Proposed	Rigger access only	RC1-8	RRU	Proposed	Rigger access only
CAB1-7	Cabinet	Proposed	Unrestricted access	AMPA1-3	MHA	Proposed	Rigger access only
TD1	Dish	Proposed	Rigger access only	AMPB1-3	MHA	Proposed	Rigger access only
TD2	Dish	Proposed	Rigger access only	AMPC1-3	MHA	Proposed	Rigger access only
TD3	Dish	Proposed	Rigger access only	BT1-6	BOB Top	Proposed	Rigger access only
TD4	Dish	Proposed	Rigger access only	BB1-5	BOB Bottom	Proposed	Unrestricted access
				AR1-12	Active Router	Proposed	Rigger access only
				PR1-6	Passive Router	Proposed	Unrestricted access

NOTES:
1. ALL DIMENSIONS IN MM UNLESS OTHERWISE NOTED.

SHARED CONFIGURATION SITE

RF CONFIG

H3a

Master:	MBNL / EE / H3G:	Project:	Purpose of Issue:	Issue:
M001	MBNL	NTQ	Planning	A
Date:	14/04/22	Revision / Upgrade Description:		
Drawn:	J. BOOTE	First Issue		
Checked:	J. STOCKDALE			
Approved:	J. STOCKDALE			



Hutchison 3G UK Limited
Star House, 20 Grenfell Road
Maidenhead, SL6 1EH
Tel: 01628 765 000
Fax: 01628 765 001

H3G Base Station Information line:
0845 6043000
Available 8am-8pm Monday to Friday



Hatfield Business Park
Hatfield
Hertfordshire
AL10 9BW

Tel: 01707 315000
Fax: 01707 319001



Mobile Broadband Network Limited
Sixth Floor, Thames Tower, Station Road, Reading, RG1 1LX

Design Consultant & Principal Contractor:



WHP Telecoms
Unit 1 Maple Park,
Low Fields Avenue, Leeds
LS12 6HH

Tel: 01133023550
e-mail: info@whptelecoms.com

Site Name:
CLUB 3000 BINGO HUYTON

Site ID:
1668316

Address:
CLUB 3000 BINGO HUYTON,
POPLAR BANK,
HUYTON, LIVERPOOL,
MERSEYSIDE,
L36 9US

Title:
003 ACCESS PLAN

Project:
NTQ


Purpose of Issue:
GENERAL ARRANGEMENT

EE Cell ID:	MBNL Cell ID:	3UK Cell ID:
96147	KSY093	-

Master Drawing No:	Issue:
1668316_KSY093_96147_M001	A

ACCESS PLAN


 
Scale 1:100




100mm

50mm

10mm

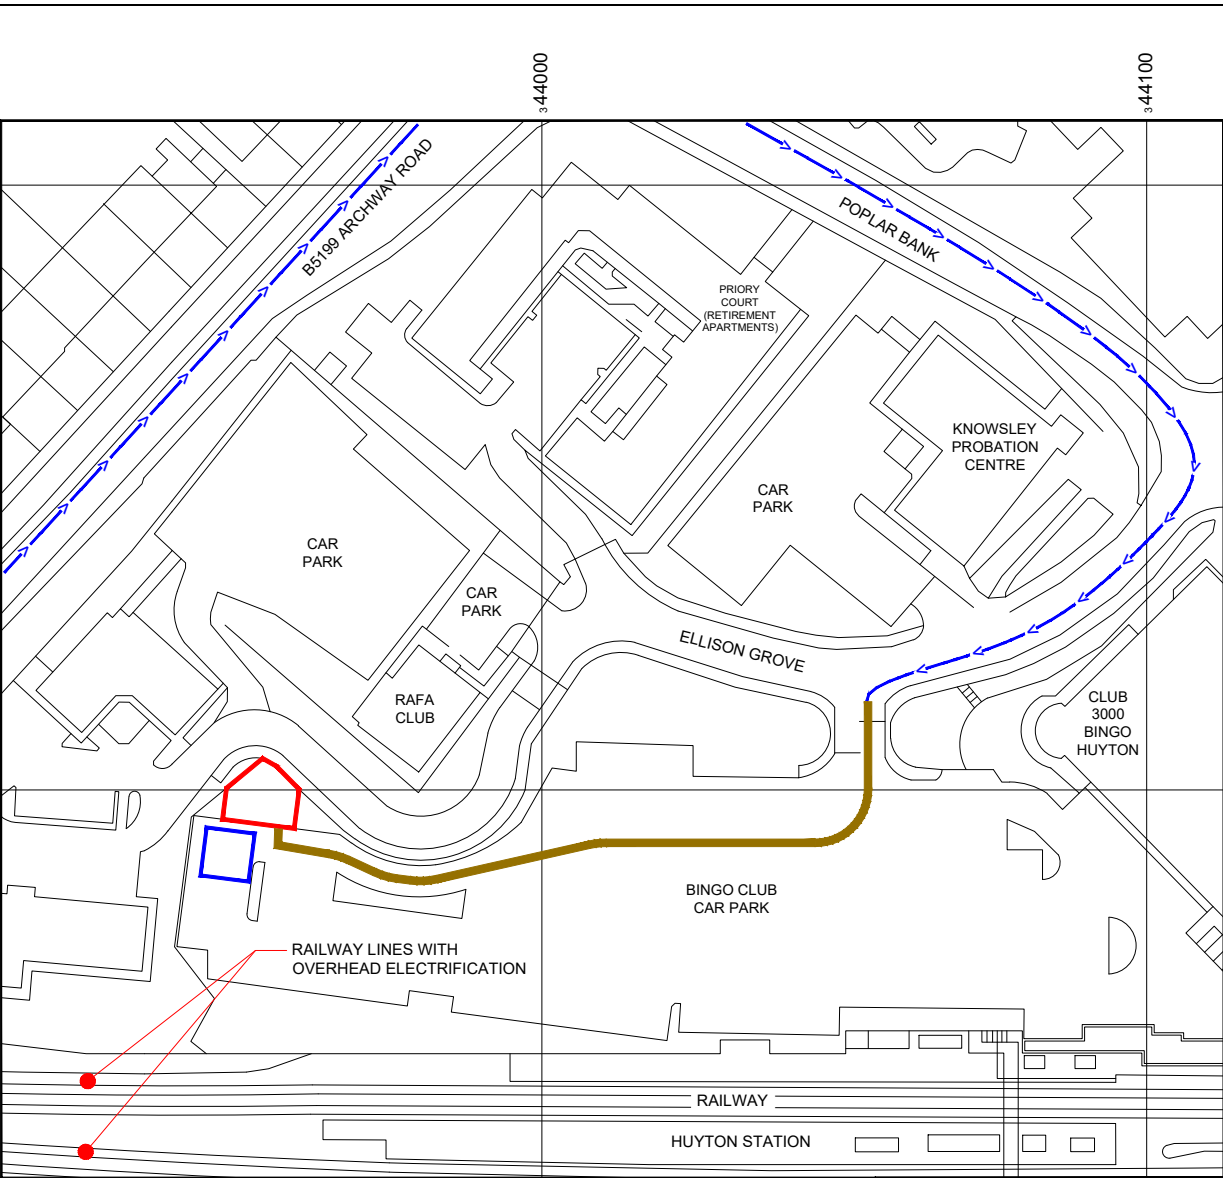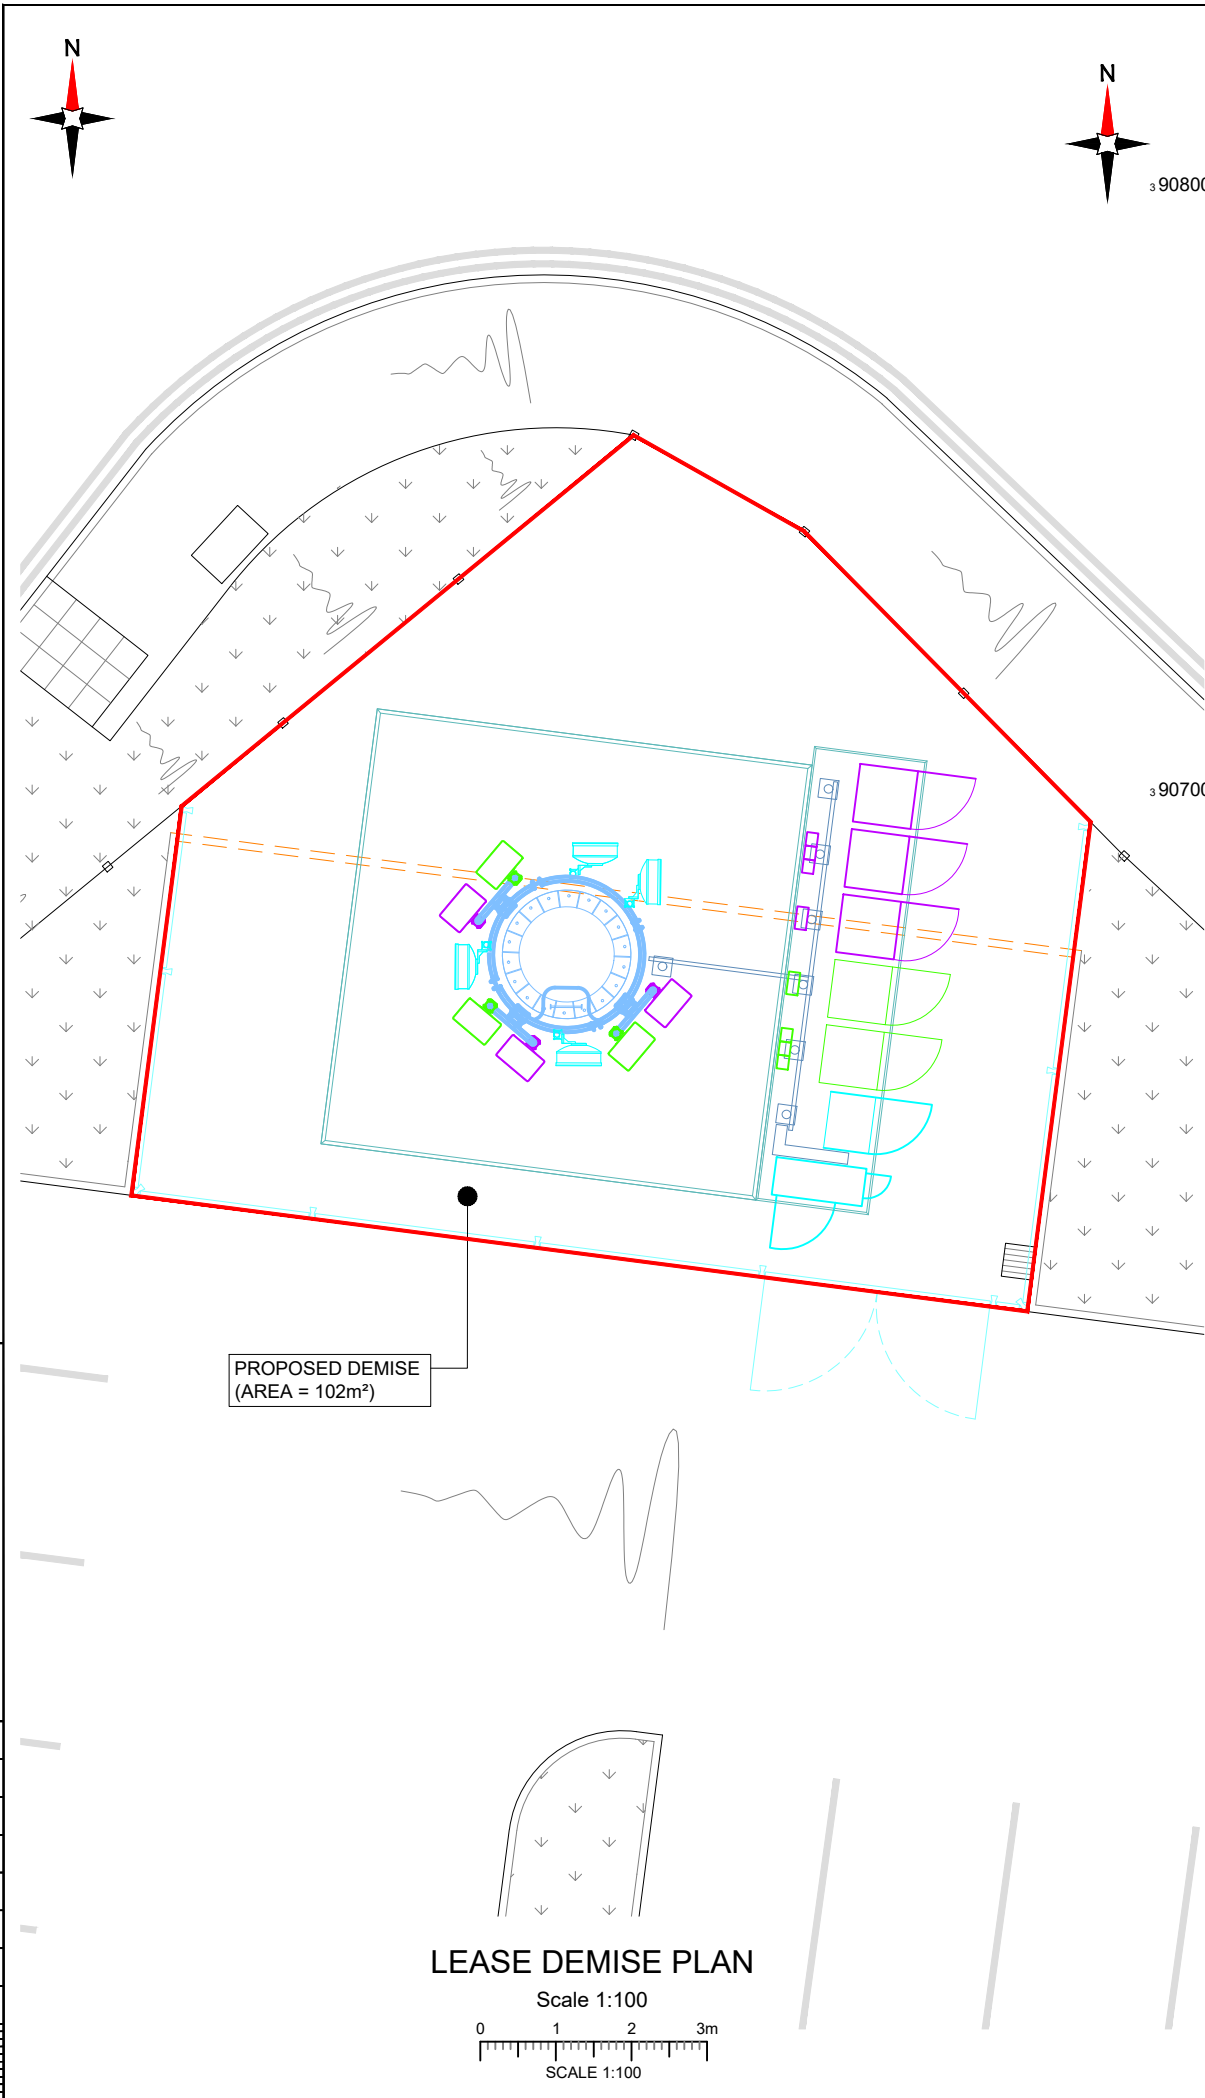

NEW CODE:				
Demise:	Outlined in Red			
Access Route:	Solid Brown			
Set Down Area:	Outlined in Blue			

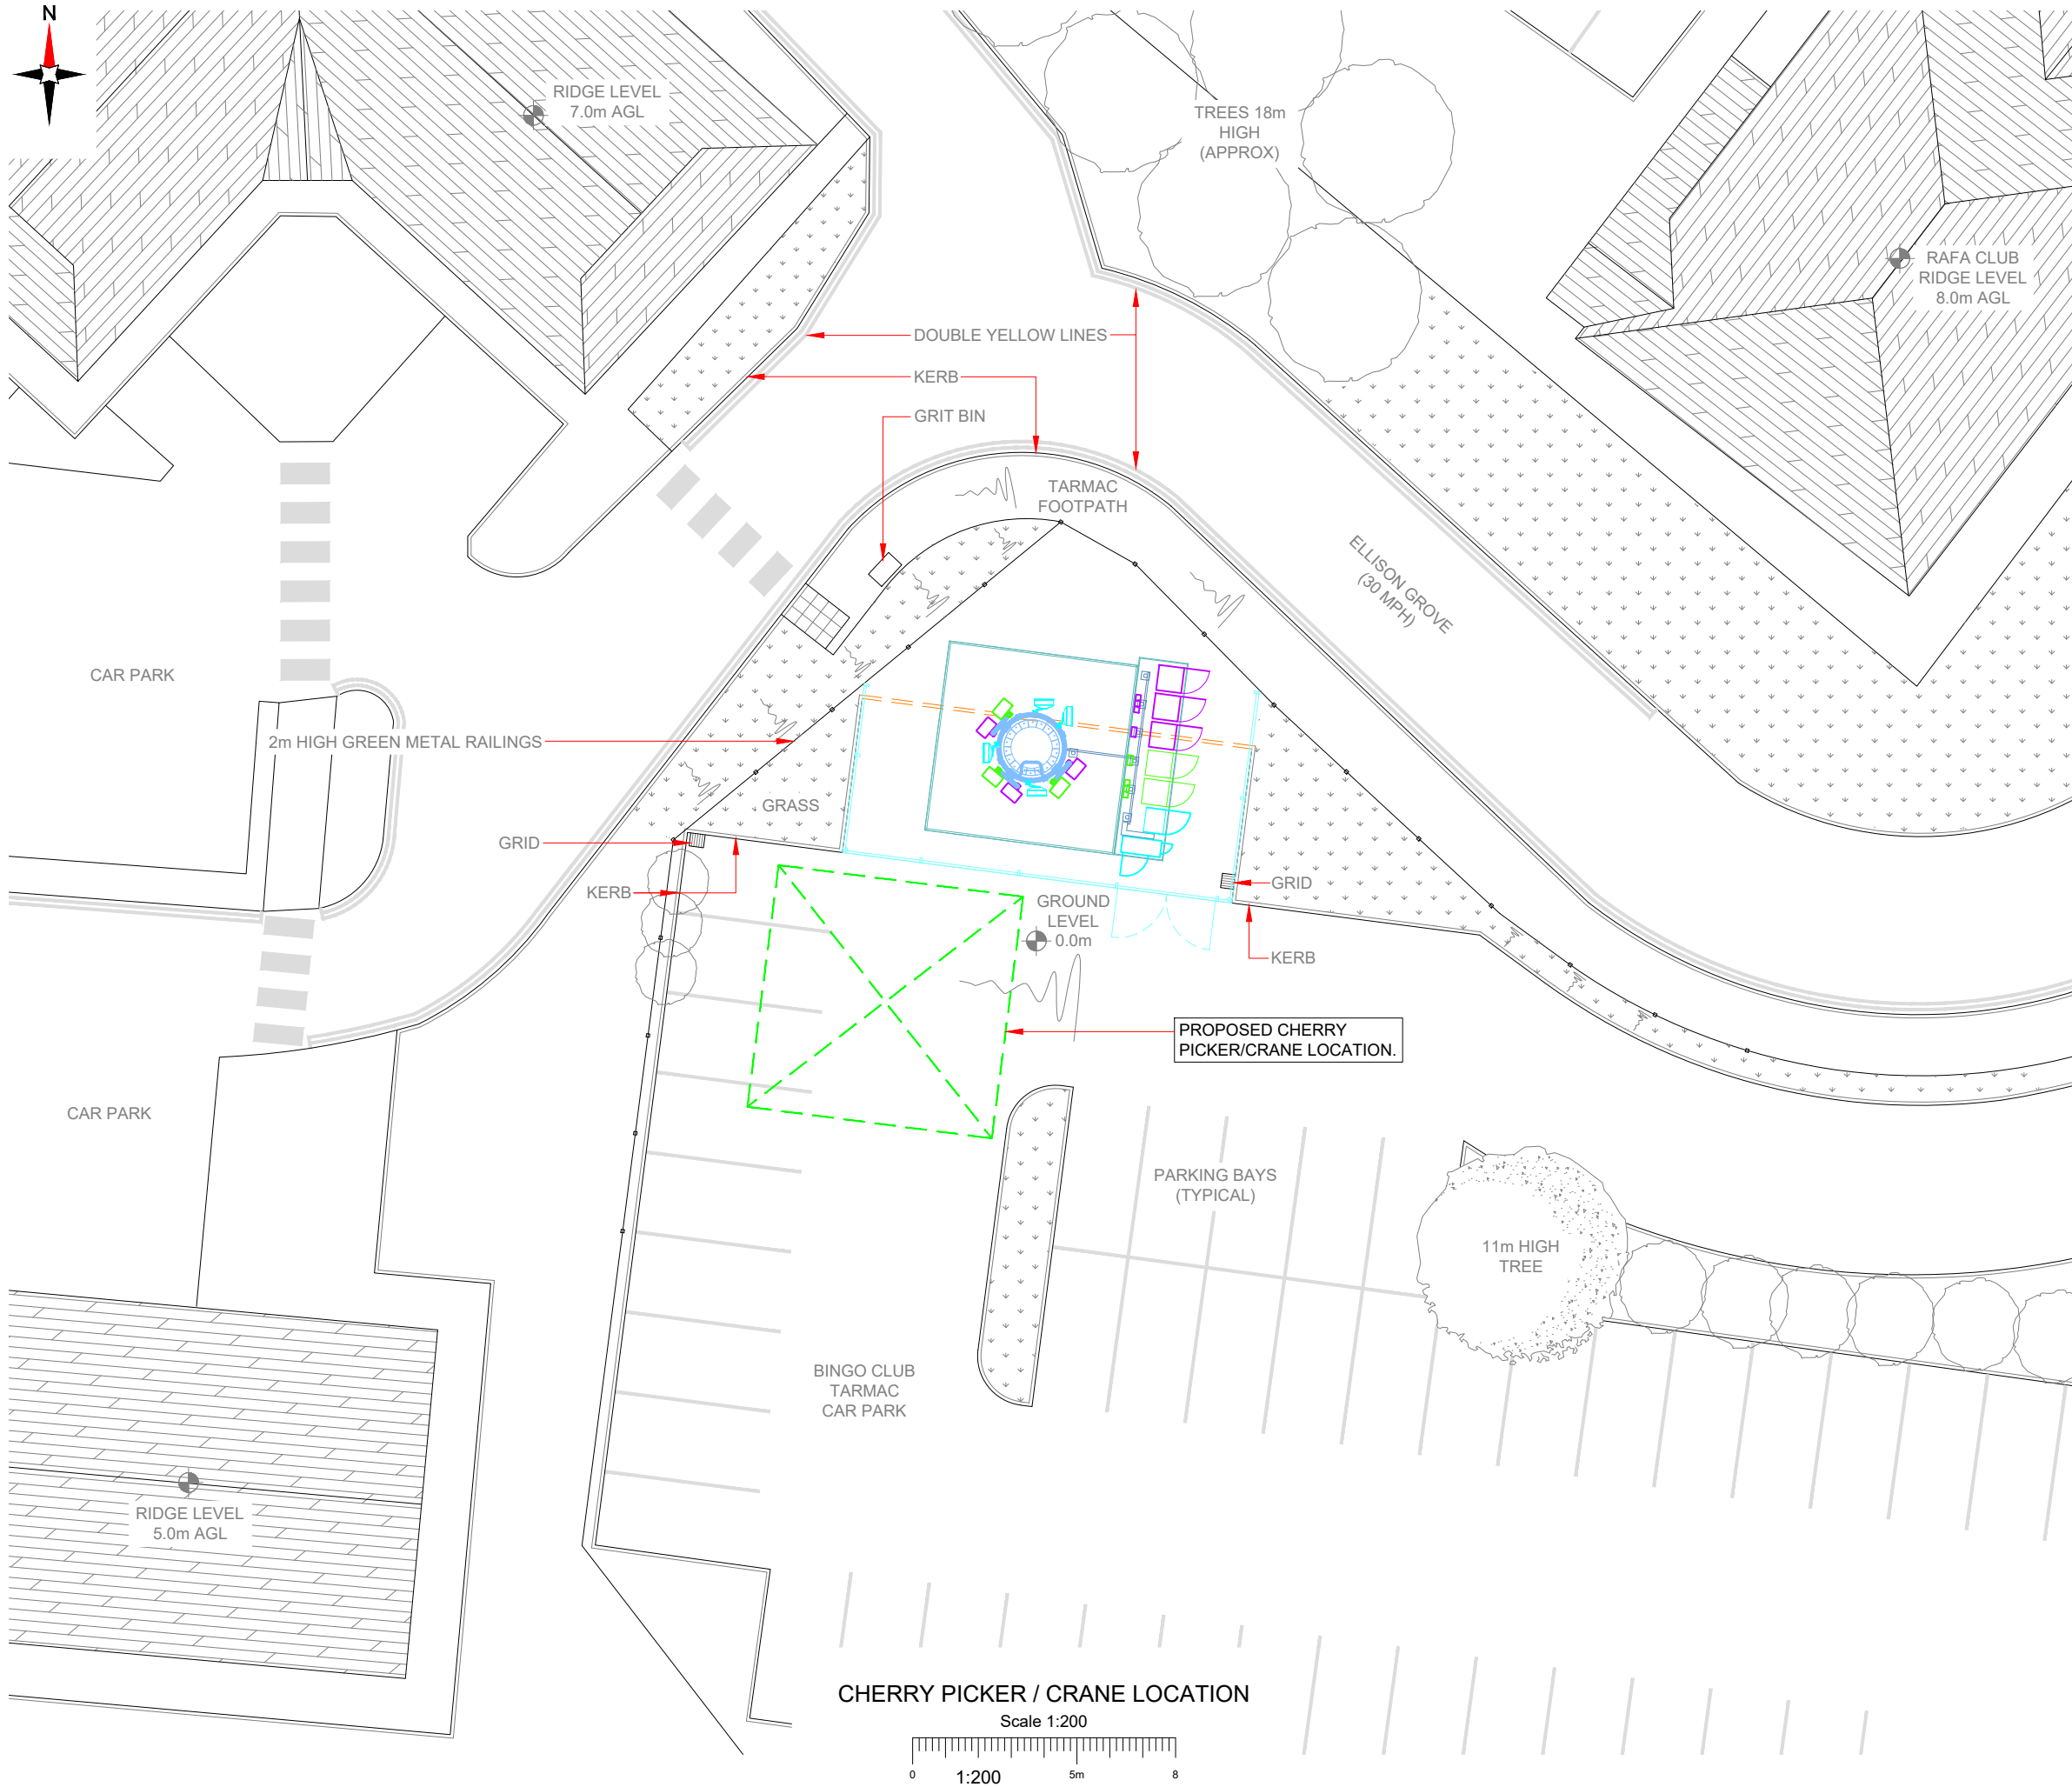

NOTES:

1. ALL DIMENSIONS IN MM UNLESS OTHERWISE NOTED.

PROPOSED CRANE OR CHERRY PICKER LOCATION:

Master:	MBNL / EE / H3G:	Project:	Purpose of Issue:	Issue:
M001	MBNL	NTQ	Planning	A
Date:	14/04/22	Revision / Upgrade Description:		
Drawn:	J. BOOTE	First Issue		
Checked:	J. STOCKDALE			
Approved:	J. STOCKDALE			

Hutchison 3G UK Limited
Star House, 20 Grenfell Road
Maidenhead, SL6 1EH
Tel: 01628 765 000
Fax: 01628 765 001

H3G Base Station Information line:
0845 6043000
Available 8am-8pm Monday to Friday

Hatfield Business Park
Hatfield
Hertfordshire
AL10 9BW

Tel: 01707 315000
Fax: 01707 319001

Mobile Broadband Network Limited
Sixth Floor, Thames Tower, Station Road, Reading, RG1 1LX

Design Consultant & Principal Contractor:

WHP Telecoms
Unit 1 Maple Park,
Low Fields Avenue, Leeds
LS12 6HH

Tel: 01133023550
e-mail: info@whptelecoms.com

Site Name:

CLUB 3000 BINGO HUYTON

Site ID:

1668316

Address:

CLUB 3000 BINGO HUYTON,
POPLAR BANK,
HUYTON, LIVERPOOL,
MERSEYSIDE,
L36 9US

Title:

005 CHERRY PICKER & CRANE LOCATION

Project:

NTQ

Purpose of Issue:

GENERAL ARRANGEMENT


EE Cell ID:	MBNL Cell ID:	3UK Cell ID:
96147	KSY093	-

Master Drawing No:

1668316_KSY093_96147_M001

Issue:

A

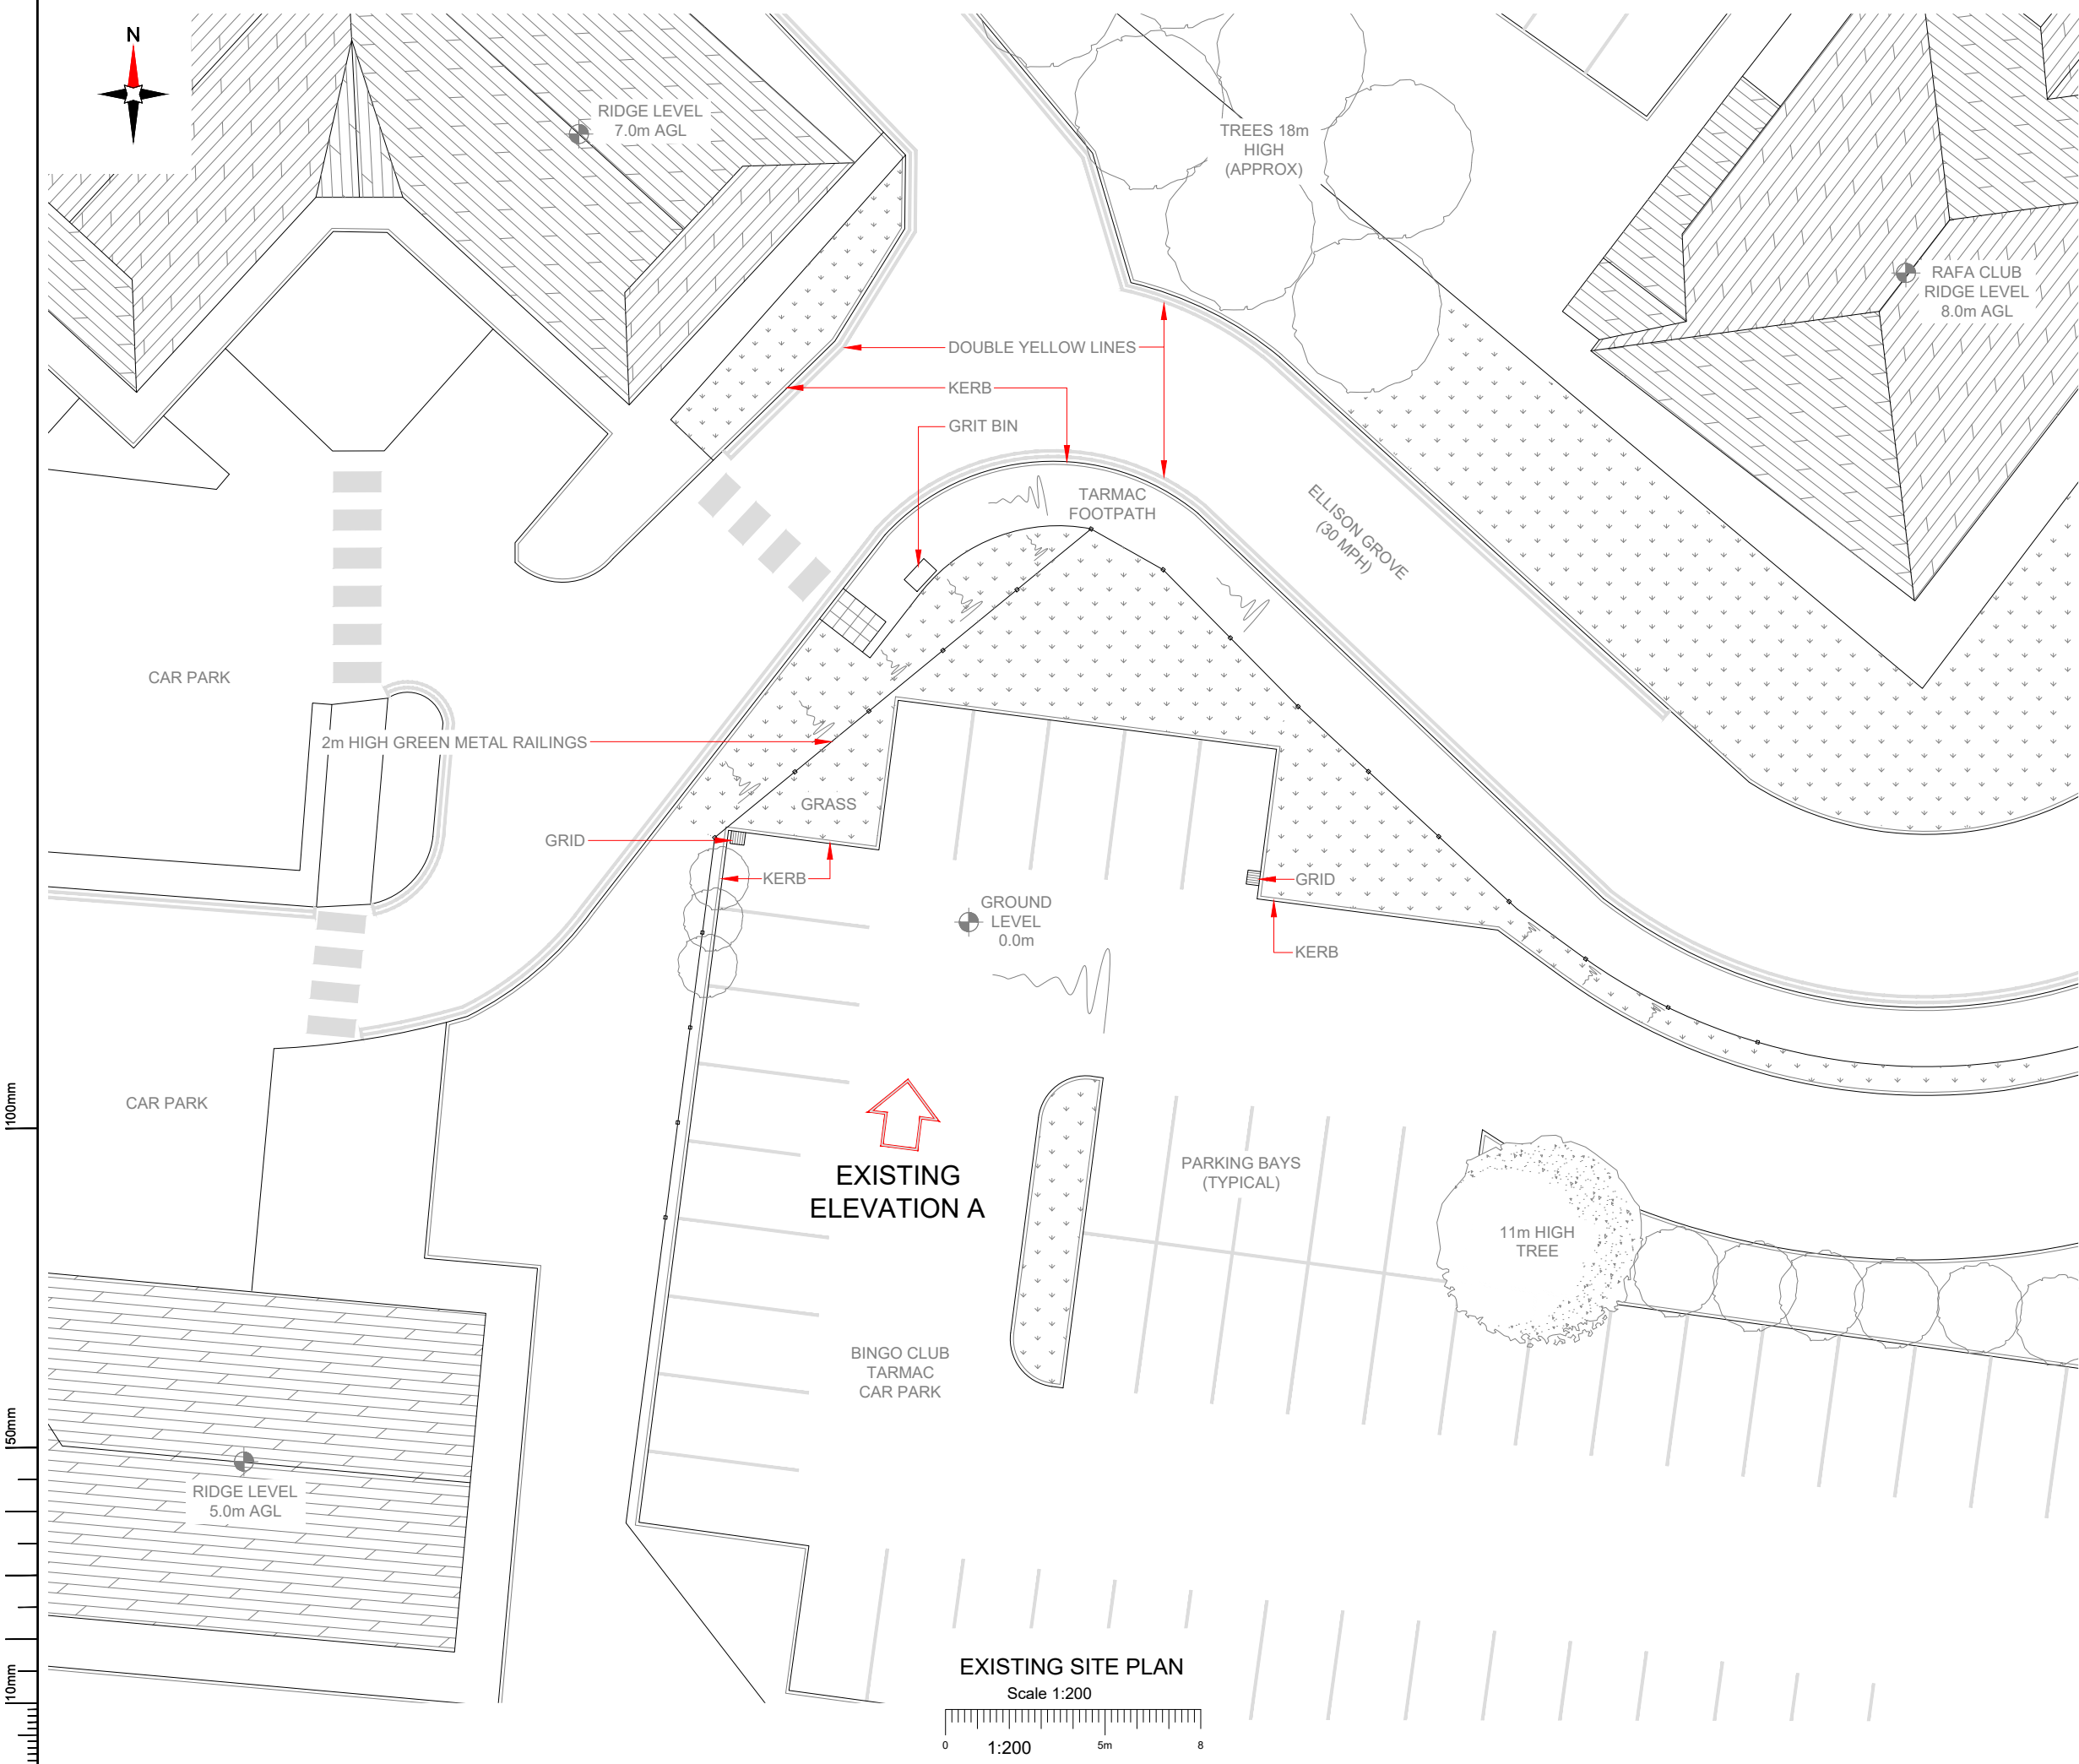

- NOTES:
- ALL DIMENSIONS IN MM UNLESS OTHERWISE NOTED.

Master:	MBNL / EE / H3G:	Project:	Purpose of Issue:	Issue:
M001	MBNL	NTQ	Planning	A
Date:	14/04/22	Revision / Upgrade Description:		
Drawn:	J. BOOTE	First Issue		
Checked:	J. STOCKDALE			
Approved:	J. STOCKDALE			



Hutchison 3G UK Limited
Star House, 20 Grenfell Road
Maidenhead, SL6 1EH
Tel: 01628 765 000
Fax: 01628 765 001



Hatfield Business Park
Hatfield
Hertfordshire
AL10 9BW
Tel: 01707 315000
Fax: 01707 319001



Mobile Broadband Network Limited
Sixth Floor, Thames Tower, Station Road, Reading, RG1 1LX

Design Consultant & Principal Contractor:


 **WHP Telecoms**
Unit 1 Maple Park,
Low Fields Avenue, Leeds
LS12 6HH
Tel: 01133023550
e-mail: info@whptelecoms.com

Site Name:	CLUB 3000 BINGO HUYTON		
Site ID:	1668316		
Address:	CLUB 3000 BINGO HUYTON, POPLAR BANK, HUYTON, LIVERPOOL, MERSEYSIDE, L36 9US		
Title:	100 EXISTING SITE PLAN		
Project:	NTQ		
Purpose of Issue:	GENERAL ARRANGEMENT		
EE Cell ID:	96147	MBNL Cell ID:	KSY093
3UK Cell ID:	-		
Master Drawing No:	1668316_KSY093_96147_M001		
Issue:	A		

100mm

50mm

10mm

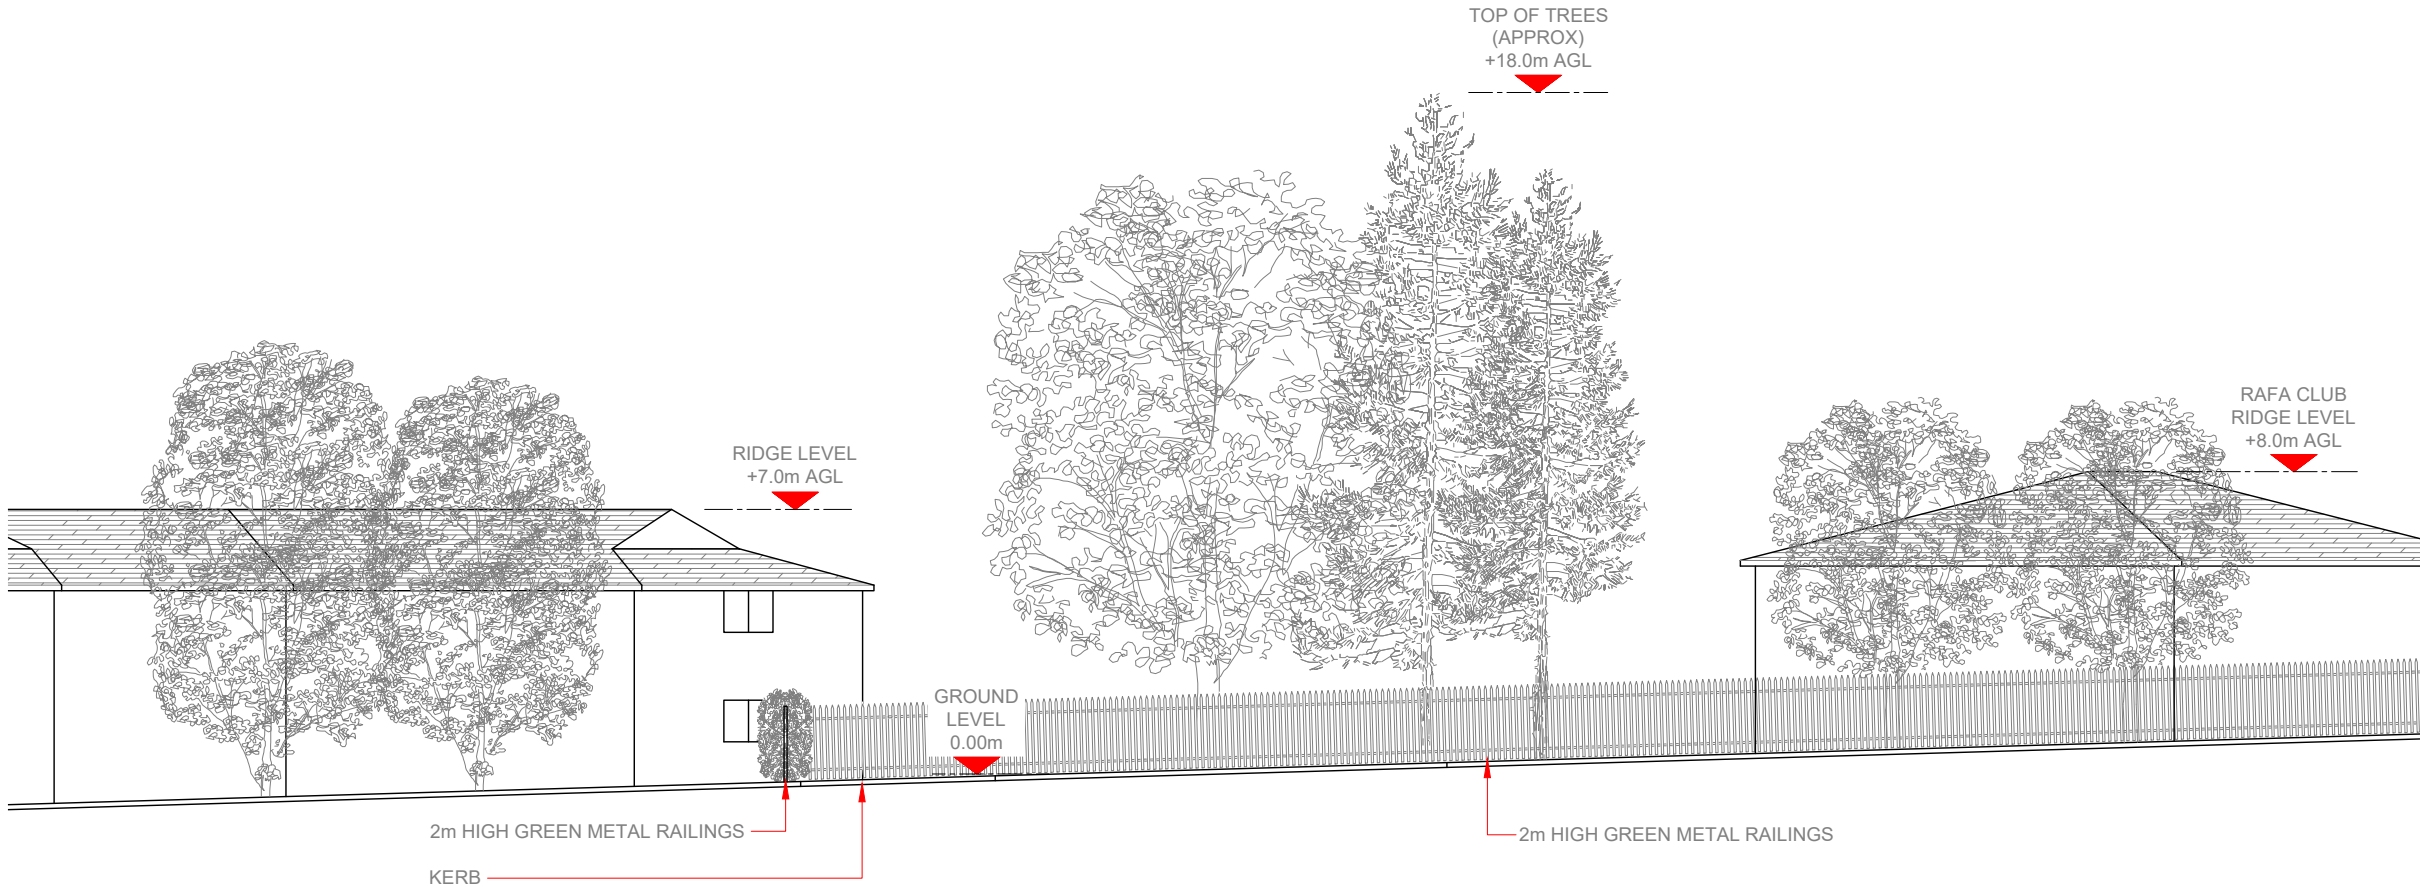

EXISTING ELEVATION A

Scale 1:200



NOTES:

1. ALL DIMENSIONS IN MM UNLESS OTHERWISE NOTED.

Master:	MBNL / EE / H3G:	Project:	Purpose of Issue:	Issue:
M001	MBNL	NTQ	Planning	A
Date:	14/04/22	Revision / Upgrade Description:		
Drawn:	J. BOOTE	First Issue		
Checked:	J. STOCKDALE			
Approved:	J. STOCKDALE			



Hutchison 3G UK Limited
Star House, 20 Grenfell Road
Maidenhead, SL6 1EH
Tel: 01628 765 000
Fax: 01628 765 001

H3G Base Station Information line:
0845 6043000
Available 8am-8pm Monday to Friday



Hatfield Business Park
Hatfield
Hertfordshire
AL10 9BW

Tel: 01707 315000
Fax: 01707 319001



Mobile Broadband Network Limited
Sixth Floor, Thames Tower, Station Road, Reading, RG1 1LX

Design Consultant & Principal Contractor:



WHP Telecoms
Unit 1 Maple Park,
Low Fields Avenue, Leeds
LS12 6HH

Tel: 01133023550
e-mail: info@whptelecoms.com

Site Name:
CLUB 3000 BINGO HUYTON

Site ID:
1668316

Address:
CLUB 3000 BINGO HUYTON,
POPLAR BANK,
HUYTON, LIVERPOOL,
MERSEYSIDE,
L36 9US


Title:
150 EXISTING ELEVATION A

Project:
NTQ

Purpose of Issue:
GENERAL ARRANGEMENT

EE Cell ID:	MBNL Cell ID:	3UK Cell ID:
96147	KSY093	-

Master Drawing No:	Issue:
1668316_KSY093_96147_M001	A

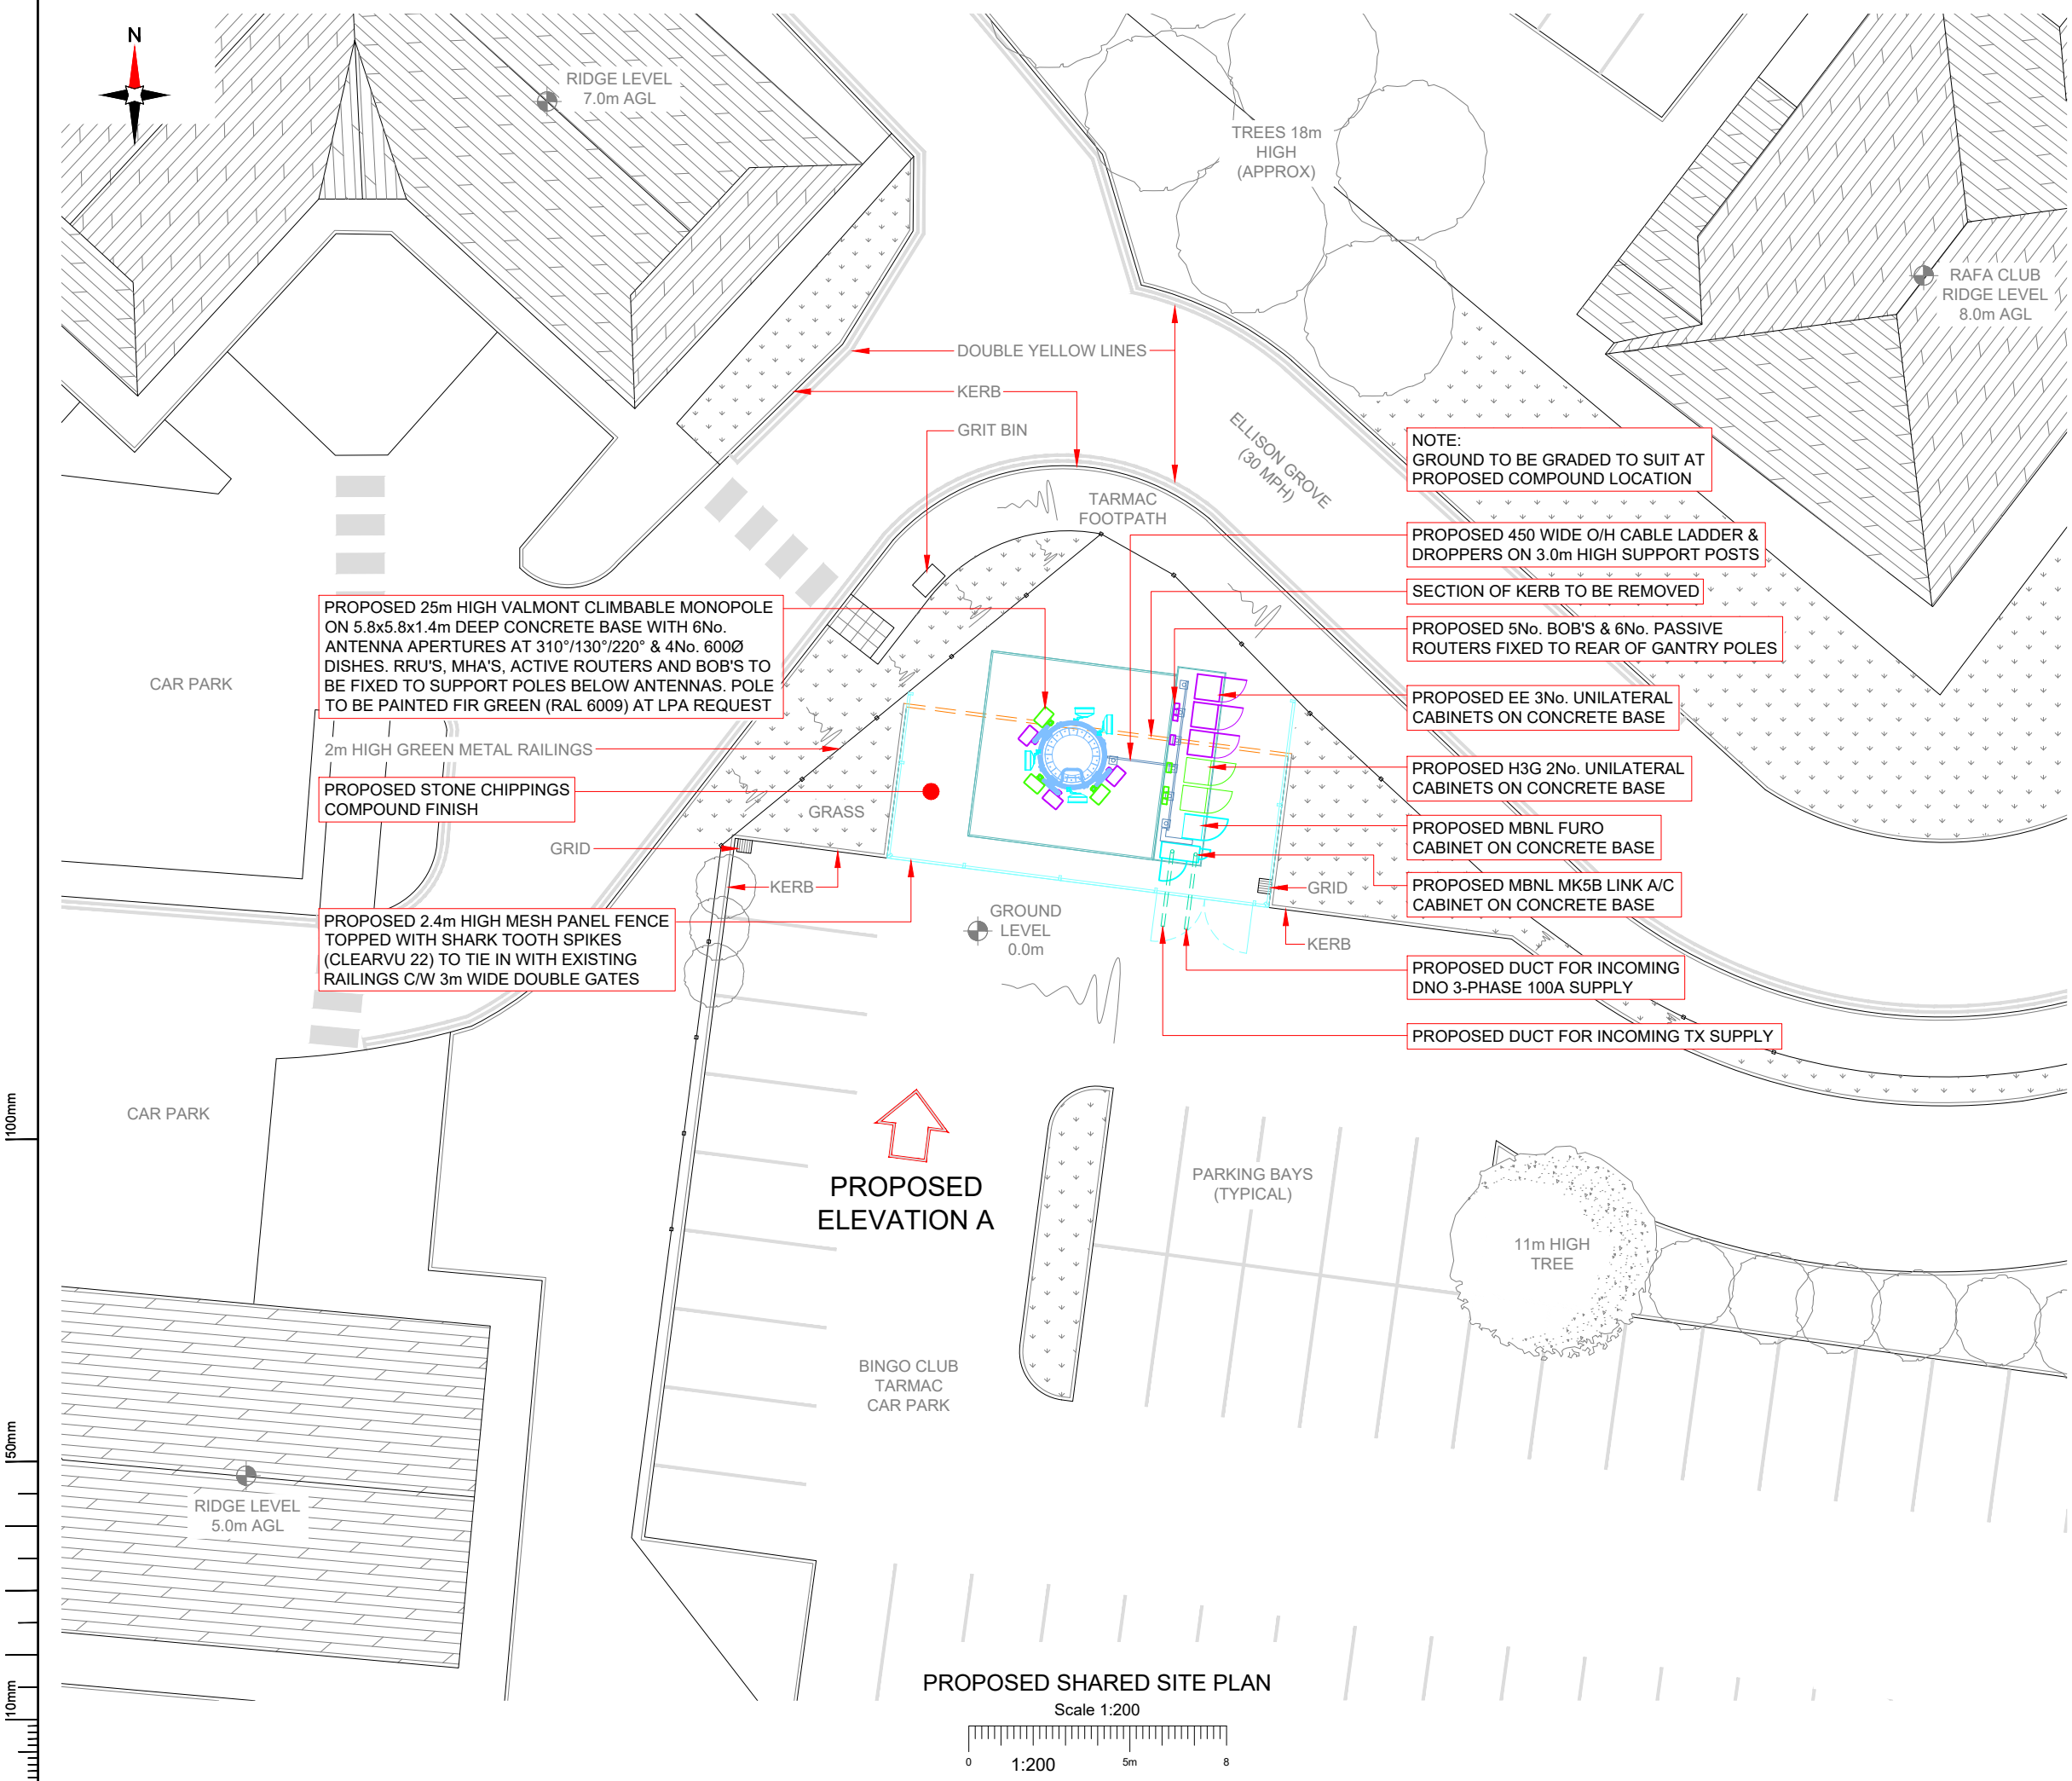

- NOTES:
- ALL DIMENSIONS IN MM UNLESS OTHERWISE NOTED.

SHARED CONFIGURATION SITE

RF CONFIG

H3a

Master:	MBNL / EE / H3G:	Project:	Purpose of Issue:	Issue:
M001	MBNL	NTQ	Planning	A
Date:	14/04/22	Revision / Upgrade Description:		
Drawn:	J. BOOTE	First Issue		
Checked:	J. STOCKDALE			
Approved:	J. STOCKDALE			



Hutchison 3G UK Limited
Star House, 20 Grenfell Road
Maidenhead, SL6 1EH
Tel: 01628 765 000
Fax: 01628 765 001
H3G Base Station Information line:
0845 6043000
Available 8am-8pm Monday to Friday



Hatfield Business Park
Hatfield
Hertfordshire
AL10 9BW
Tel: 01707 315000
Fax: 01707 319001



Mobile Broadband Network Limited
Sixth Floor, Thames Tower, Station Road, Reading, RG1 1LX

Design Consultant & Principal Contractor:



WHP Telecoms
Unit 1 Maple Park,
Low Fields Avenue, Leeds
LS12 6HH

Tel: 01133023550
e-mail: info@whptelecoms.com

Site Name:
CLUB 3000 BINGO HUYTON

Site ID:
1668316

Address:
**CLUB 3000 BINGO HUYTON,
POPLAR BANK,
HUYTON, LIVERPOOL,
MERSEYSIDE,
L36 9US**

Title:
200 PROPOSED SHARED SITE PLAN

Project:
NTQ

Purpose of Issue:
GENERAL ARRANGEMENT


EE Cell ID:	MBNL Cell ID:	3UK Cell ID:
96147	KSY093	-

Master Drawing No:	Issue:
1668316_KSY093_96147_M001	A

100mm

50mm

10mm

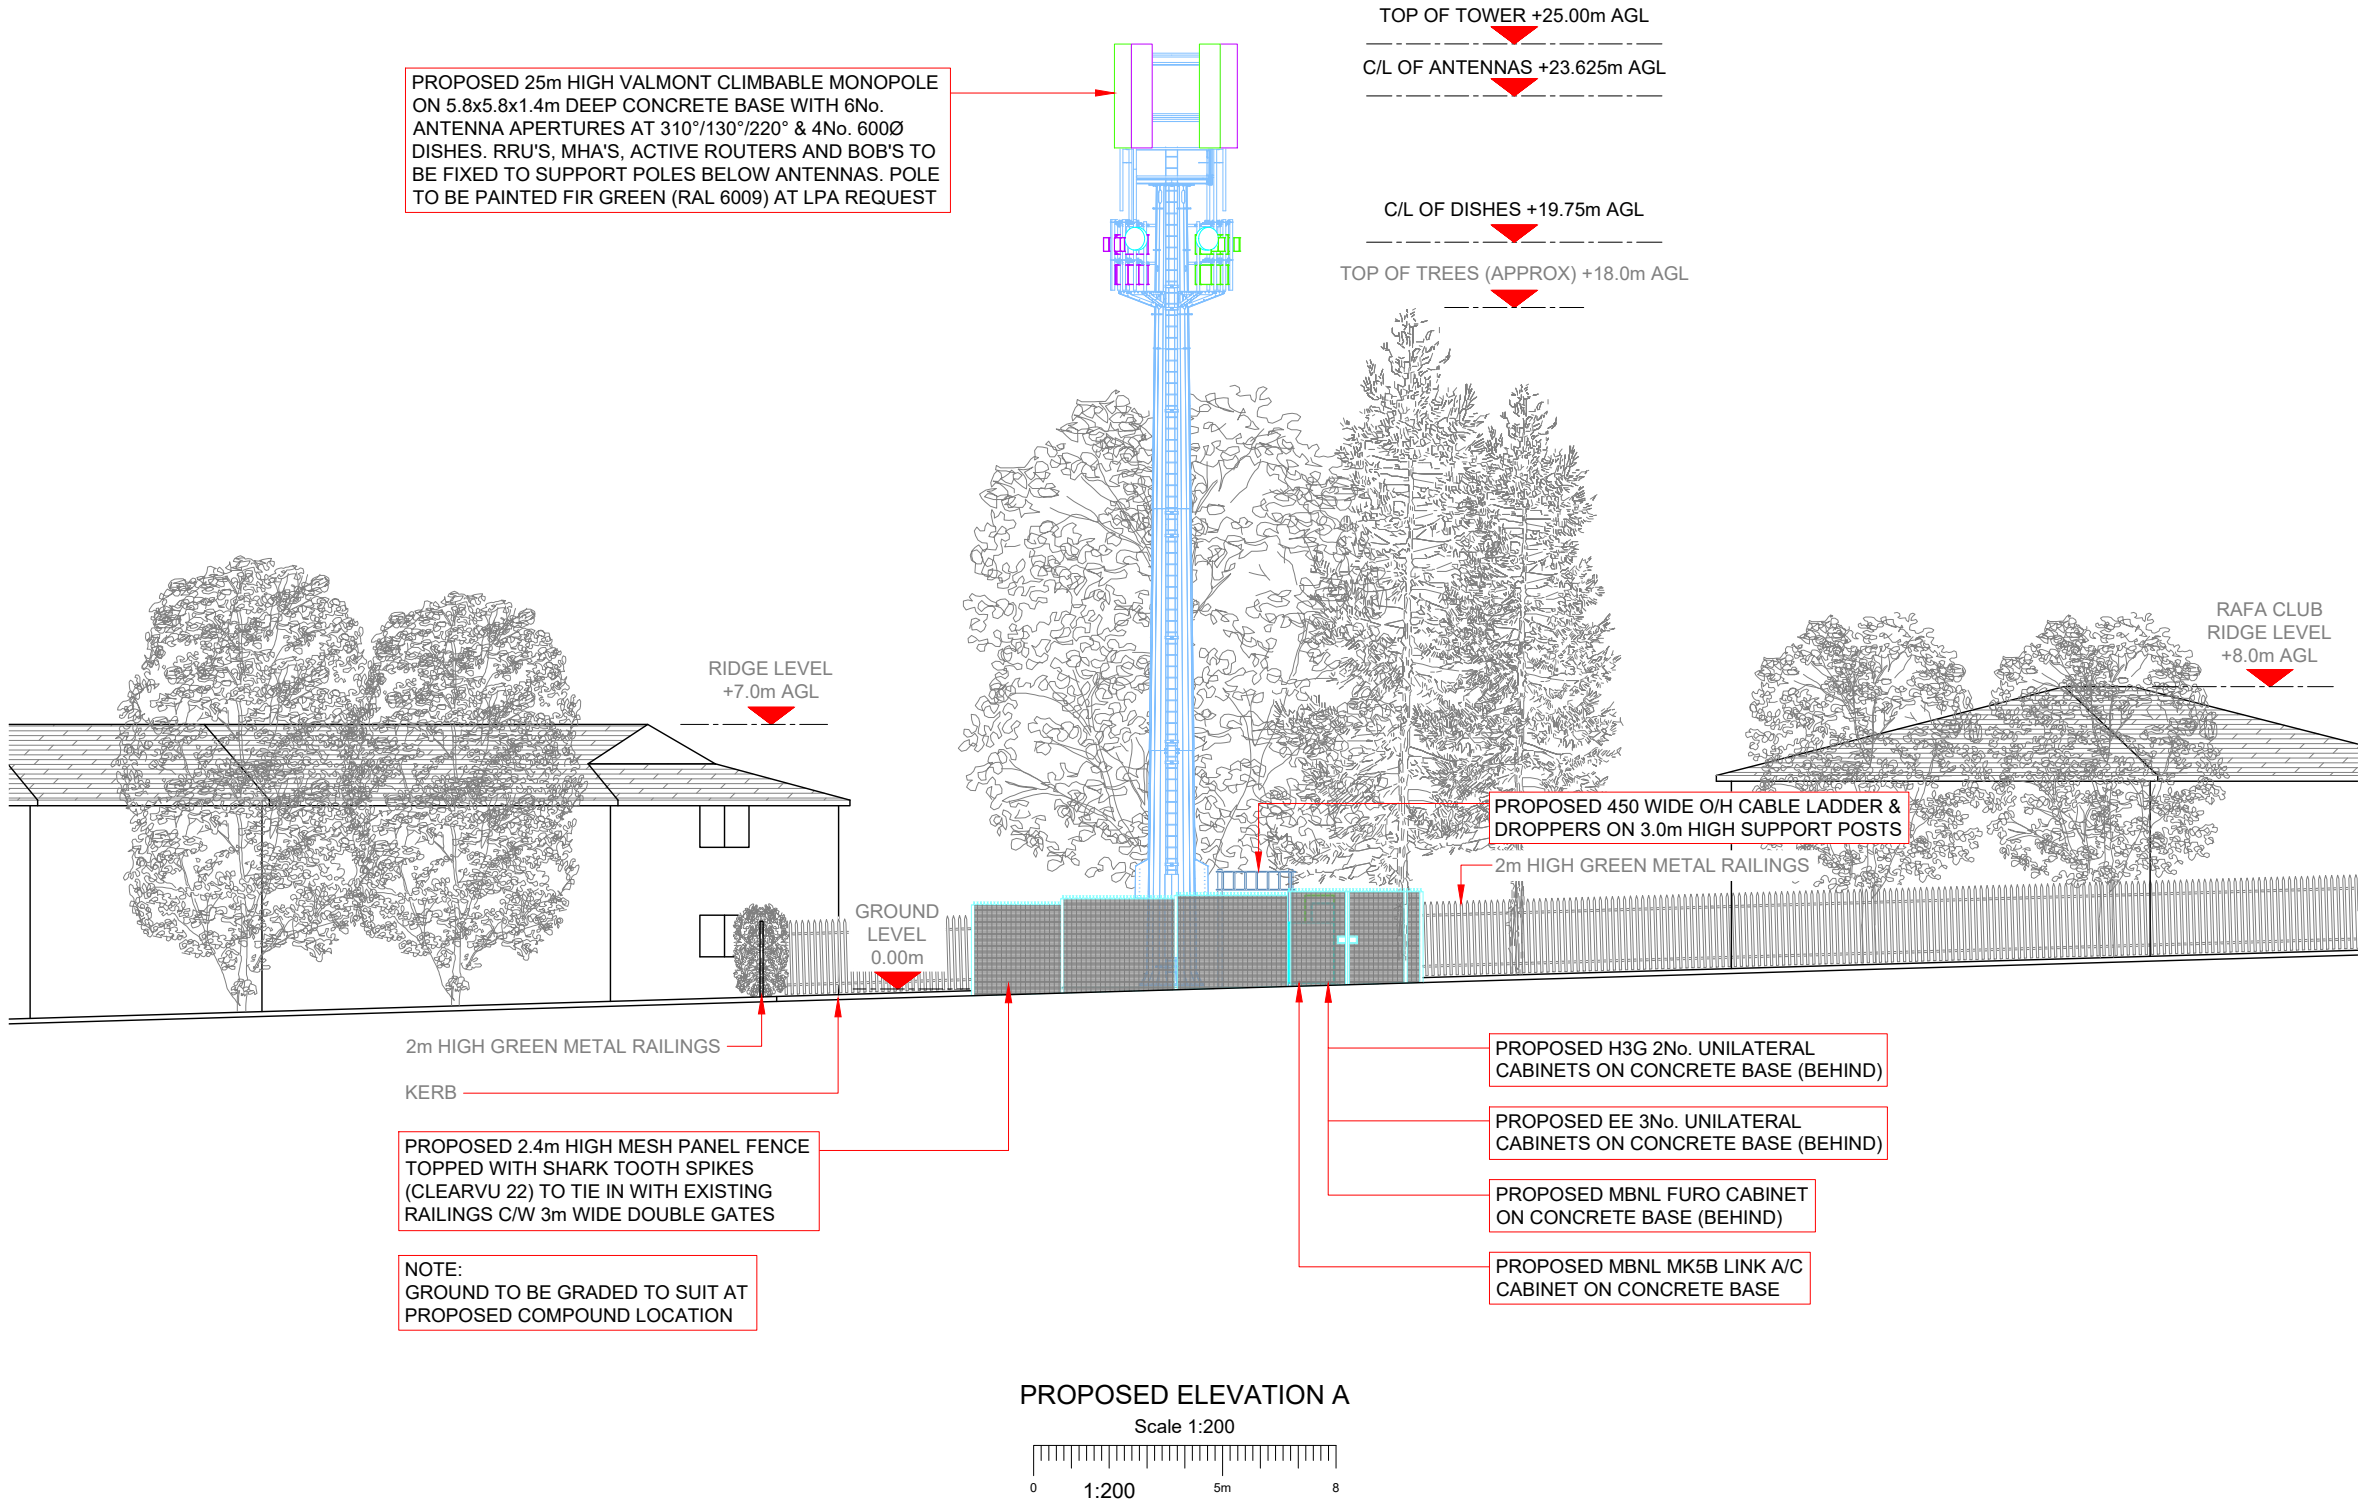

NOTES:
1. ALL DIMENSIONS IN MM UNLESS OTHERWISE NOTED.

SHARED CONFIGURATION SITE
RF CONFIGH3a

Master: M001	MBNL / EE / H3G: MBNL	Project: NTQ	Purpose of Issue: Planning	Issue: A
Date: 14/04/22	Drawn: J. BOOTE	Revision / Upgrade Description: First Issue		
Checked: J. STOCKDALE	Approved: J. STOCKDALE			

Hutchison 3G UK Limited
Star House, 20 Grenfell Road
Maidenhead, SL6 1EH
Tel: 01628 765 000
Fax: 01628 765 001
H3G Base Station Information line:
0845 6043000
Available 8am-8pm Monday to Friday

Hatfield Business Park
Hatfield
Hertfordshire
AL10 9BW
Tel: 01707 315000
Fax: 01707 319001

Mobile Broadband Network Limited
Sixth Floor, Thames Tower, Station Road, Reading, RG1 1LX

Design Consultant & Principal Contractor:

WHP Telecoms
Unit 1 Maple Park,
Low Fields Avenue, Leeds
LS12 6HH
Tel: 01133023550
e-mail: info@whptelecoms.com

Site Name: CLUB 3000 BINGO HUYTON

Site ID: 1668316

Address: CLUB 3000 BINGO HUYTON,
POPLAR BANK,
HUYTON, LIVERPOOL,
MERSEYSIDE,
L36 9US

Title: 250 PROPOSED SHARED ELEVATION A

Project: NTQ

Purpose of Issue: GENERAL ARRANGEMENT

EE Cell ID: 96147	MBNL Cell ID: KSY093	3UK Cell ID: -
-------------------	----------------------	----------------

Master Drawing No: 1668316_KSY093_96147_M001

Issue: A

Max Configuration Antenna Aperture Schedule & RF Equipment Capacity																	
Antenna Aperture ID	Antenna Aperture Size (Length x Width x Depth)	Aperture Height C/L	Aperture Max Weight (kg)	Proposed Bearing	Tech:	Operator: Shared/ EE/H3G	Antenna Aperture Coordinates		RRU No. Max Size & Weight L=300mm W=400mm D=150mm Weight=25kg	MHA No. Max Size & Weight L=300mm W=300mm D=150mm Weight=10kg	Main Feeder			BOB Max Size & Weight (300x300x250mm & 5kg)		Active Router No. Max Size & Weight (370x260x150mm & 10kg)	Passive Router No. Max Size & Weight (350x220x150mm & 10kg)
							Eastings	Northings			Size	Length	No.	No. Top	No. Bottom		
A1	2750x550x350mm	23.625m	130kg	310°	2G/3G/4G/5G	EE	-	-	4	2	LDF7-50	30.0m	4	1	1	2	1
A2	2750x550x350mm	23.625m	130kg	310°	3G/4G/5G	H3G	-	-	4	1	LDF7-50	30.0m	2	1	1	2	1
B1	2750x550x350mm	23.625m	130kg	130°	2G/3G/4G/5G	EE	-	-	4	2	LDF7-50	30.0m	4	1	1	2	1
B2	2750x550x350mm	23.625m	130kg	130°	3G/4G/5G	H3G	-	-	4	1	LDF7-50	30.0m	2	1	1	2	1
C1	2750x550x350mm	23.625m	130kg	220°	2G/3G/4G/5G	EE	-	-	4	2	LDF7-50	30.0m	4	1	1	2	1
C2	2750x550x350mm	23.625m	130kg	220°	3G/4G/5G	H3G	-	-	4	1	LDF7-50	30.0m	2	1	-	2	1

NOTE:
THERE MAY BE UP TO 2 ANTENNAS PER APERTURE
SUBJECT TO SITE SPECIFIC RADIO DESIGN

Passive Infrastructure Equipment Capacity		
A	B	C
H3a	H3a	H3a

STATUS KEY:

Installed: Existing
Retain: Existing and to remain
Relocate: Existing and to be relocated
Remove: Existing to be removed from site
Proposed: New on site

Master:	MBNL / EE / H3G:	Project:	Purpose of Issue:	Issue:
M001	MBNL	NTQ	Planning	A
Date:	14/04/22	Revision / Upgrade Description:		
Drawn:	J. BOOTE	First Issue		
Checked:	J. STOCKDALE			
Approved:	J. STOCKDALE			



Hutchison 3G UK Limited
Star House, 20 Grenfell Road
Maidenhead, SL6 1EH
Tel: 01628 765 000
Fax: 01628 765 001

H3G Base Station Information line:
0845 6043000
Available 8am-8pm Monday to Friday



Hatfield Business Park
Hatfield
Hertfordshire
AL10 9BW

Tel: 01707 315000
Fax: 01707 319001



Mobile Broadband Network Limited
Sixth Floor, Thames Tower, Station Road, Reading, RG1 1LX

Design Consultant & Principal Contractor:



WHP Telecoms
Unit 1 Maple Park,
Low Fields Avenue, Leeds
LS12 6HH

Tel: 01133023550
e-mail: info@whptelecoms.com

Site Name:	CLUB 3000 BINGO HUYTON		
Site ID:	1668316		
Address:	CLUB 3000 BINGO HUYTON, POPLAR BANK, HUYTON, LIVERPOOL, MERSEYSIDE, L36 9US		
Title:	301 PROPOSED SHARED ANTENNA SCHEDULE & LINE CONFIGURATION		
Project:	NTQ		
Purpose of Issue:	GENERAL ARRANGEMENT		
EE Cell ID:	MBNL Cell ID:	3UK Cell ID:	
96147	KS Y093	-	
Master Drawing No:			
1668316_KSY093_96147_M001			
Issue:			A

Support Structure Schedule										
Structure ID	Status	Equipment Description / Type	Structure Manufacturer	Height AGL (m)	Colour (RAL Colour)	Headframe Details	Foundation / Support Grillage / Host Structure Details	Support Bolt Details	MBNL Ref:	Comments
ST1	Proposed	MONOPOLE	VALMONT	25m	RAL 6009	TYPE 1	5.8m x 5.8m x 1.4m RC base	-	-	TO BE INSTALLED ON A NEW RC PAD FOUNDATION (SUBJECT TO STAGE 2 BOREHOLE INVESTIGATION)

--	--	--	--	--	--	--	--	--	--	--

Equipment Schedule										
--------------------	--	--	--	--	--	--	--	--	--	--

Equipment ID	Quantity	Status	Equipment Description / Type	Equipment Manufacturer	Dimensions (W x D x H)	Weight (kg)	Colour (RAL Colour)	Material	Location	Power	Power cable length (m)	MBNL Ref:	Comments
CAB1	1	PROPOSED	MK5B LINK AC	-	1200x600x1600	-	GREY	STEEL	OUTDOOR	-	-	-	ON CONCRETE BASE
CAB2	1	PROPOSED	EE/H3G - FURO	ICD	750x600x2100	-	GREY	STEEL	OUTDOOR	-	-	-	ON CONCRETE BASE
CAB3	1	PROPOSED	EE - UNILATERAL	TBC	770x770x2200	-	GREY	STEEL	OUTDOOR	-	-	-	ON CONCRETE BASE
CAB4	1	PROPOSED	EE - UNILATERAL	TBC	770x770x2200	-	GREY	STEEL	OUTDOOR	-	-	-	ON CONCRETE BASE
CAB5	1	PROPOSED	EE - UNILATERAL	TBC	770x770x2200	-	GREY	STEEL	OUTDOOR	-	-	-	ON CONCRETE BASE
CAB6	1	PROPOSED	H3G - UNILATERAL	TBC	770x770x2310	-	GREY	STEEL	OUTDOOR	-	-	-	ON CONCRETE BASE
CAB7	1	PROPOSED	H3G - UNILATERAL	TBC	770x770x2310	-	GREY	STEEL	OUTDOOR	-	-	-	ON CONCRETE BASE

--	--	--	--	--	--	--	--	--	--	--

POWER SCHEDULE										
----------------	--	--	--	--	--	--	--	--	--	--

Supply Status	Type	Supplier	Supply Type	Location	Comments
PROPOSED	DNO	TBC	3 Phase 100A (69 kVA)	MK5B LINK/AC CABINET	-

--	--	--	--	--	--	--	--	--	--	--

STATUS KEY:

Installed:

Existing

Retain:

Existing and to remain

Relocate:

Existing and to be relocated

Remove:

Existing to be removed from site

Proposed:

New on site

LOCATION KEY:

Outdoor:

Located outside

Indoor:

Located within an equipment cabin or equipment room

Internal:

located inside a cabinet or item of equipment

Master: M001

MBNL / EE / H3G: MBNL

Project: NTQ

Purpose of Issue: Planning

Issue: A

Date: 14/04/22

Drawn: J. BOOTE

Checked: J. STOCKDALE

Approved: J. STOCKDALE

Revision / Upgrade Description: First Issue



Hutchison 3G UK Limited

Star House, 20 Grenfell Road

Maidenhead, SL6 1EH

Tel: 01628 765 000

Fax: 01628 765 001

H3G Base Station Information line:

0845 6043000

Available 8am-8pm Monday to Friday



Hatfield Business Park

Hatfield

Hertfordshire

AL10 9BW

Tel: 01707 315000

Fax: 01707 319001



Mobile Broadband Network Limited

Sixth Floor, Thames Tower, Station Road, Reading, RG1 1LX

Design Consultant & Principal Contractor:



WHP Telecoms

Unit 1 Maple Park,

Low Fields Avenue, Leeds

LS12 6HH

Tel: 01133023550

e-mail: info@whptelecoms.com

Site Name:

CLUB 3000 BINGO HUYTON

Site ID:

1668316

Address:

CLUB 3000 BINGO HUYTON,

POPLAR BANK,

HUYTON, LIVERPOOL,

MERSEYSIDE,

L36 9US

Title:

305 EQUIPMENT SCHEDULE & SUPPORT STRUCTURE DETAILS

Project:

NTQ

Purpose of Issue:

GENERAL ARRANGEMENT

EE Cell ID: 96147

MBNL Cell ID: KSY093

3UK Cell ID: -

Master Drawing No: 1668316_KSY093_96147_M001

Issue: A

100mm

50mm

10mm

100mm

50mm

10mm

100mm

50mm

10mm