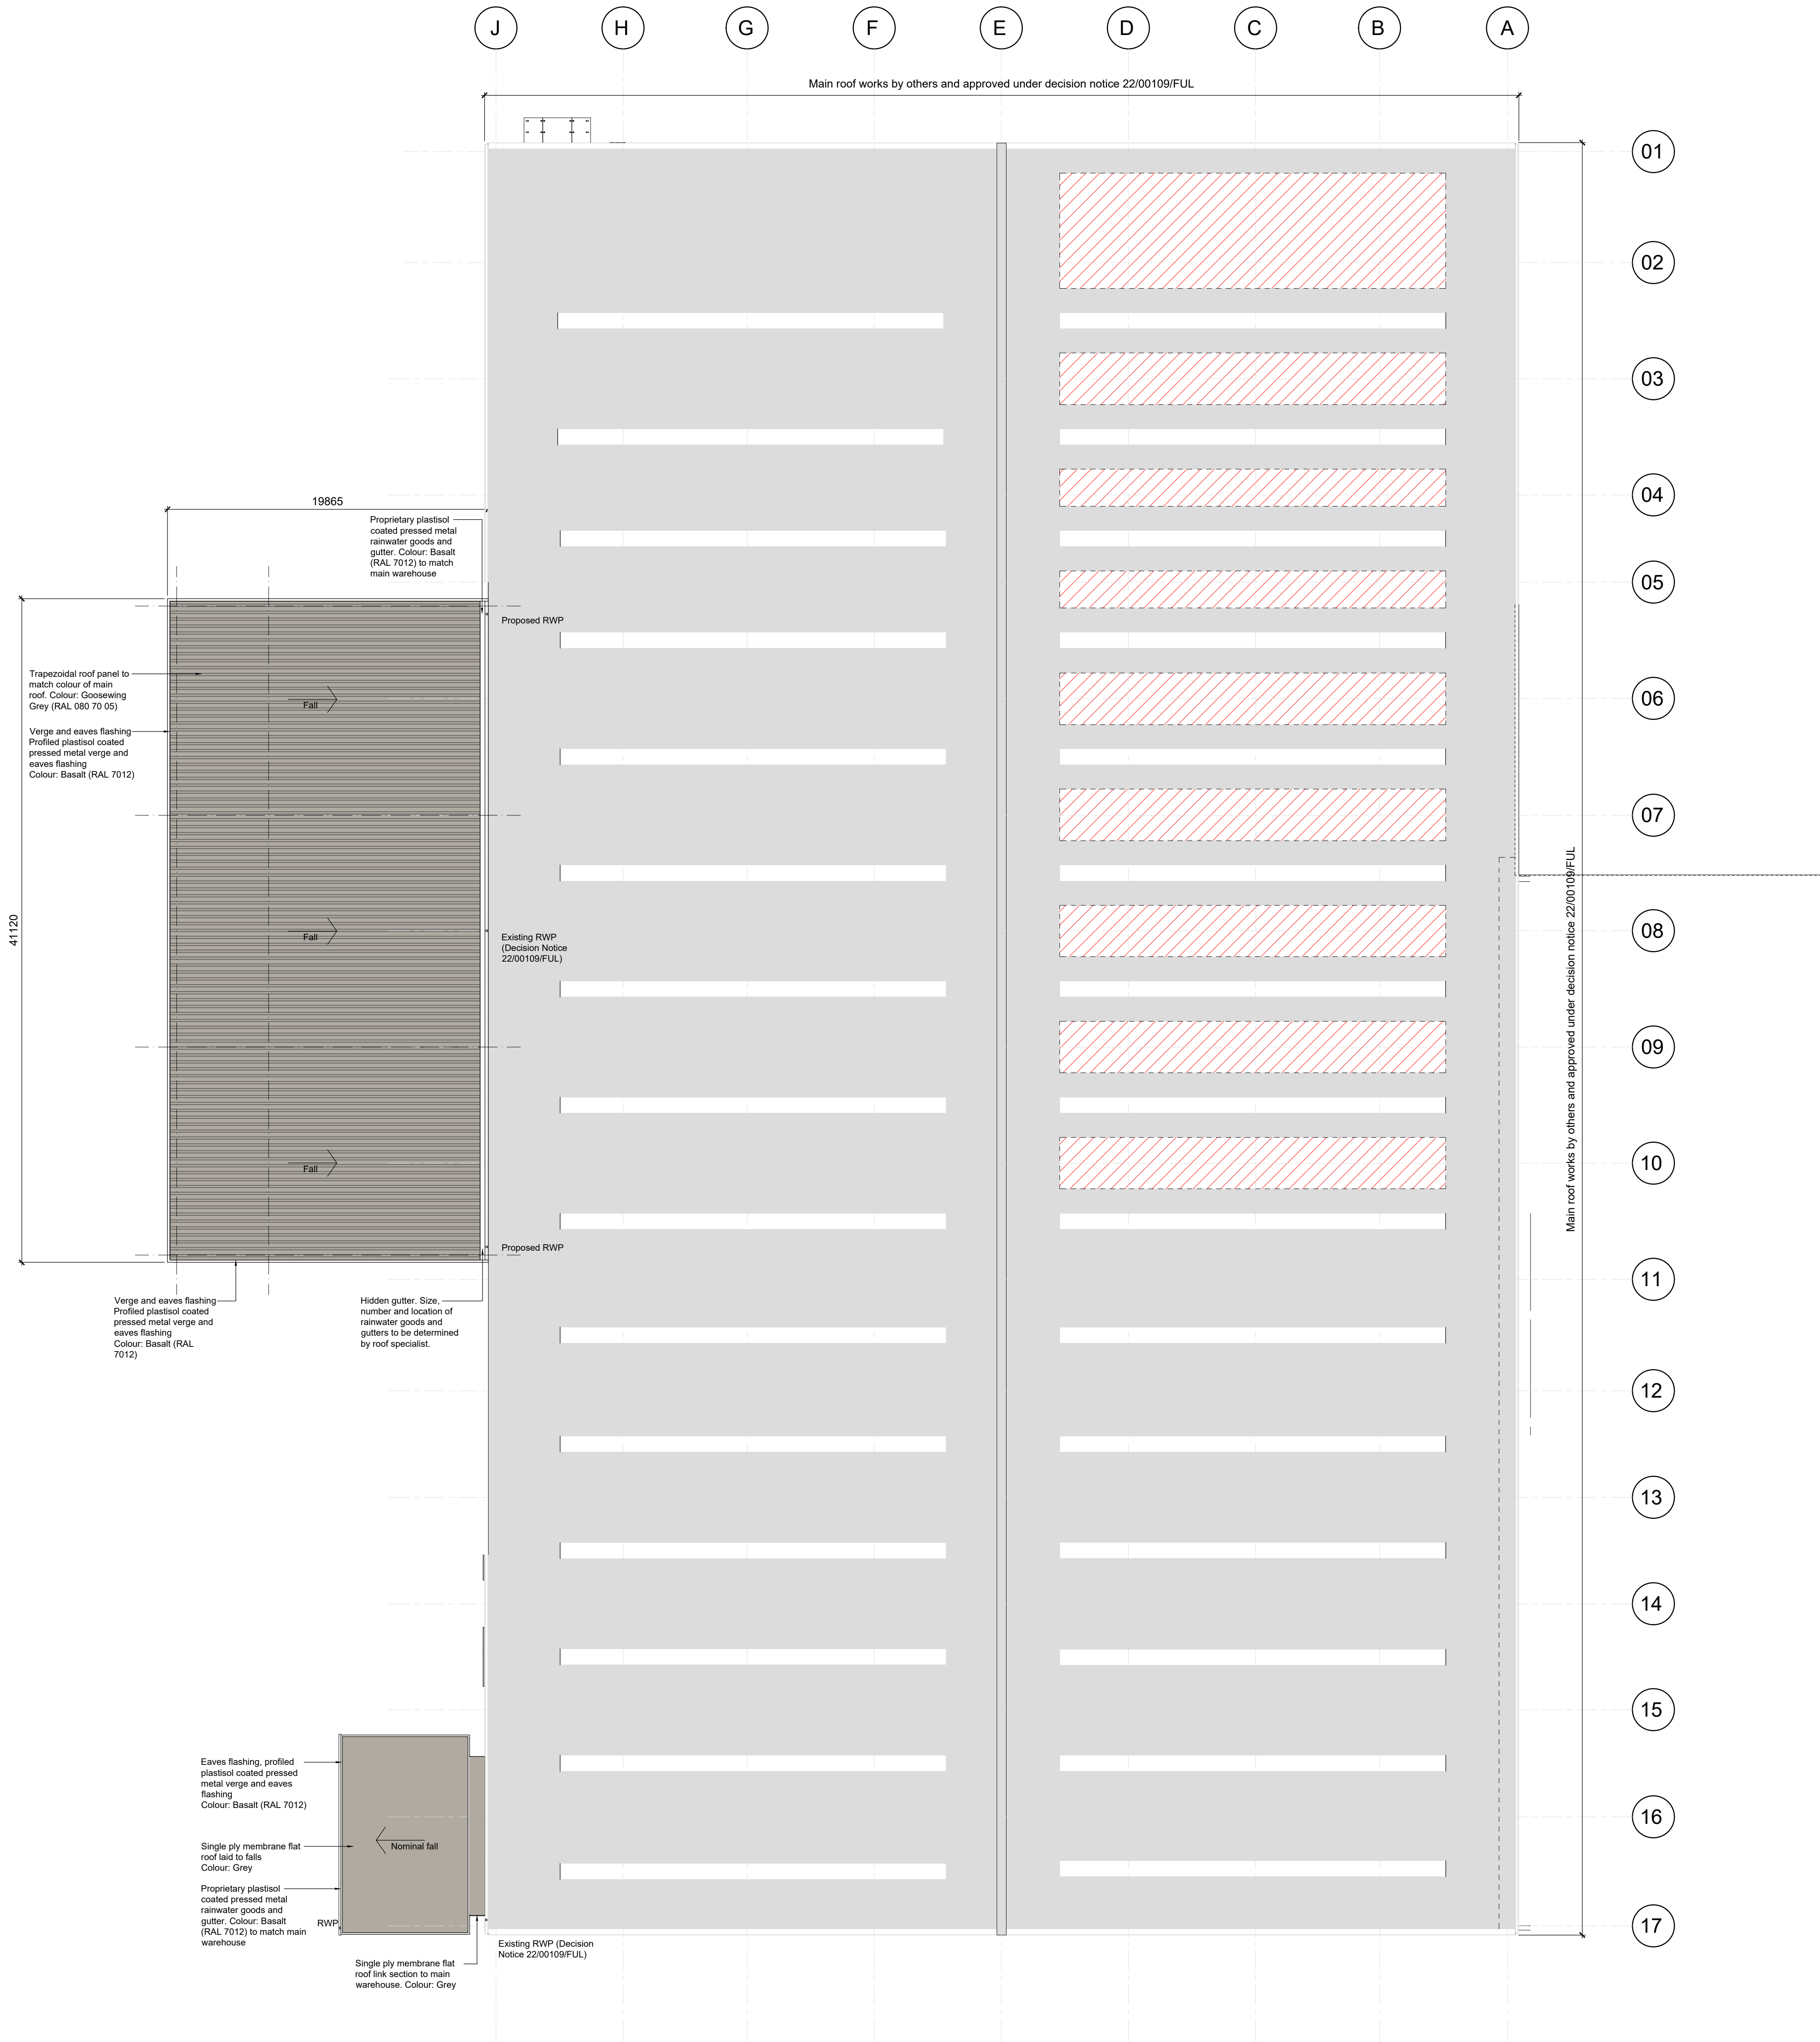


0m 2m 10m 20m
1:200

P02 P01 REV.	23/04/2024 11/04/2024 DATE	Planning team Final team AMENDMENT
 WPL Consulting LLP 1 Airport West, Lancaster Way, Leeds, LS19 7ZA Tel: 0113 202 9444 Fax: 0113 202 9333 E-mail: mail@wplconsulting.co.uk		
PROJECT TITLE Unit C Huyton Phase 1 Sovereign Industrial Park		
DRAWING TITLE Proposed Roof Plan showing External Canopy and Pump House / Compressor Room		
PROJECT No: 10187 SCALE: 1:200 @ A0	DRAWING No: 1015 DATE: April 2024	REVISION: P02 DRAWN BY: mj DATE:
CHECKED BY:		DATE: