


|      |              |     |       |
|------|--------------|-----|-------|
| Rev: | Description: | By: | Date: |
|------|--------------|-----|-------|

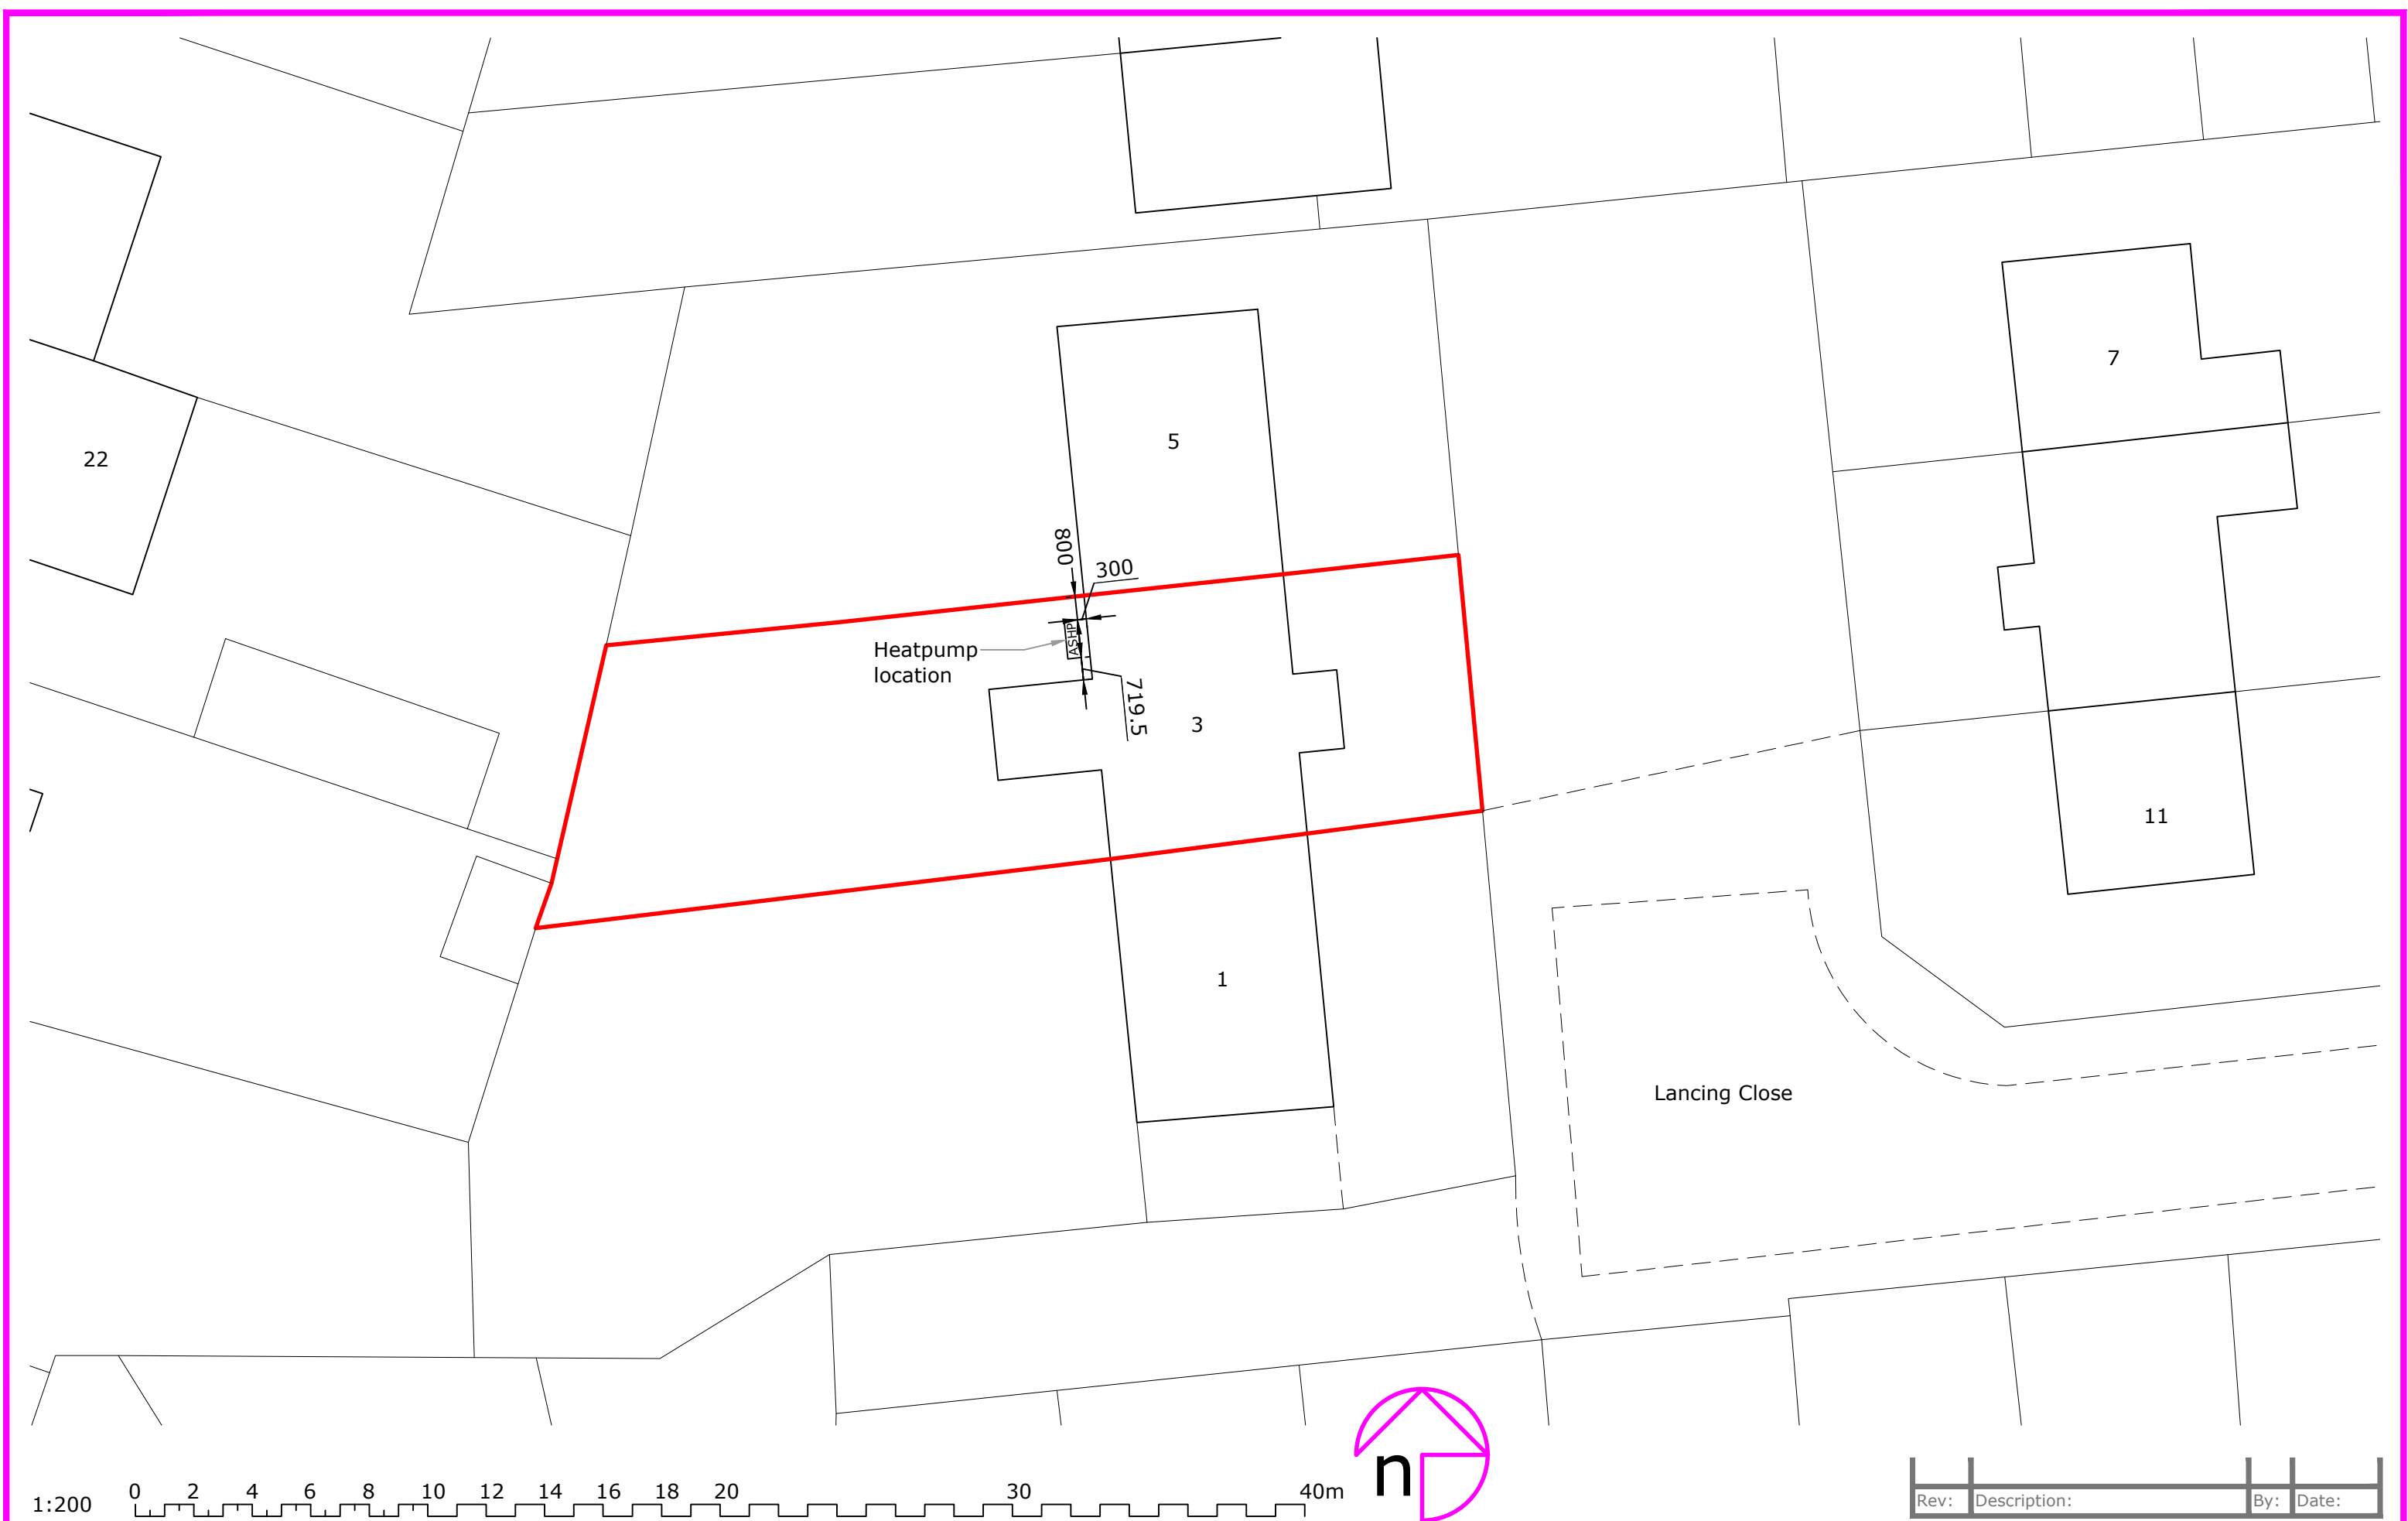

octopusenergy  
services

Accredited by:



|                                                                            |                                                                                                               |
|----------------------------------------------------------------------------|---------------------------------------------------------------------------------------------------------------|
| Client/Project:<br>Liam McNeilis,<br>3 Lancing Close,<br>Halewood, L25 9PZ | Project status:<br>PLANNING (installation of air source heat pump)<br>Drawing title:<br>Site plan as proposed |
|----------------------------------------------------------------------------|---------------------------------------------------------------------------------------------------------------|

|                           |                   |                    |                       |
|---------------------------|-------------------|--------------------|-----------------------|
| Scale:<br>1:200           | Paper Size:<br>A3 | Drawn:<br>A Walton | Checked:<br>E Odejobi |
| Project ID:<br>J-6F66E44C | Drawing No:<br>03 | Revision:          | Date:<br>17.06.2024   |