
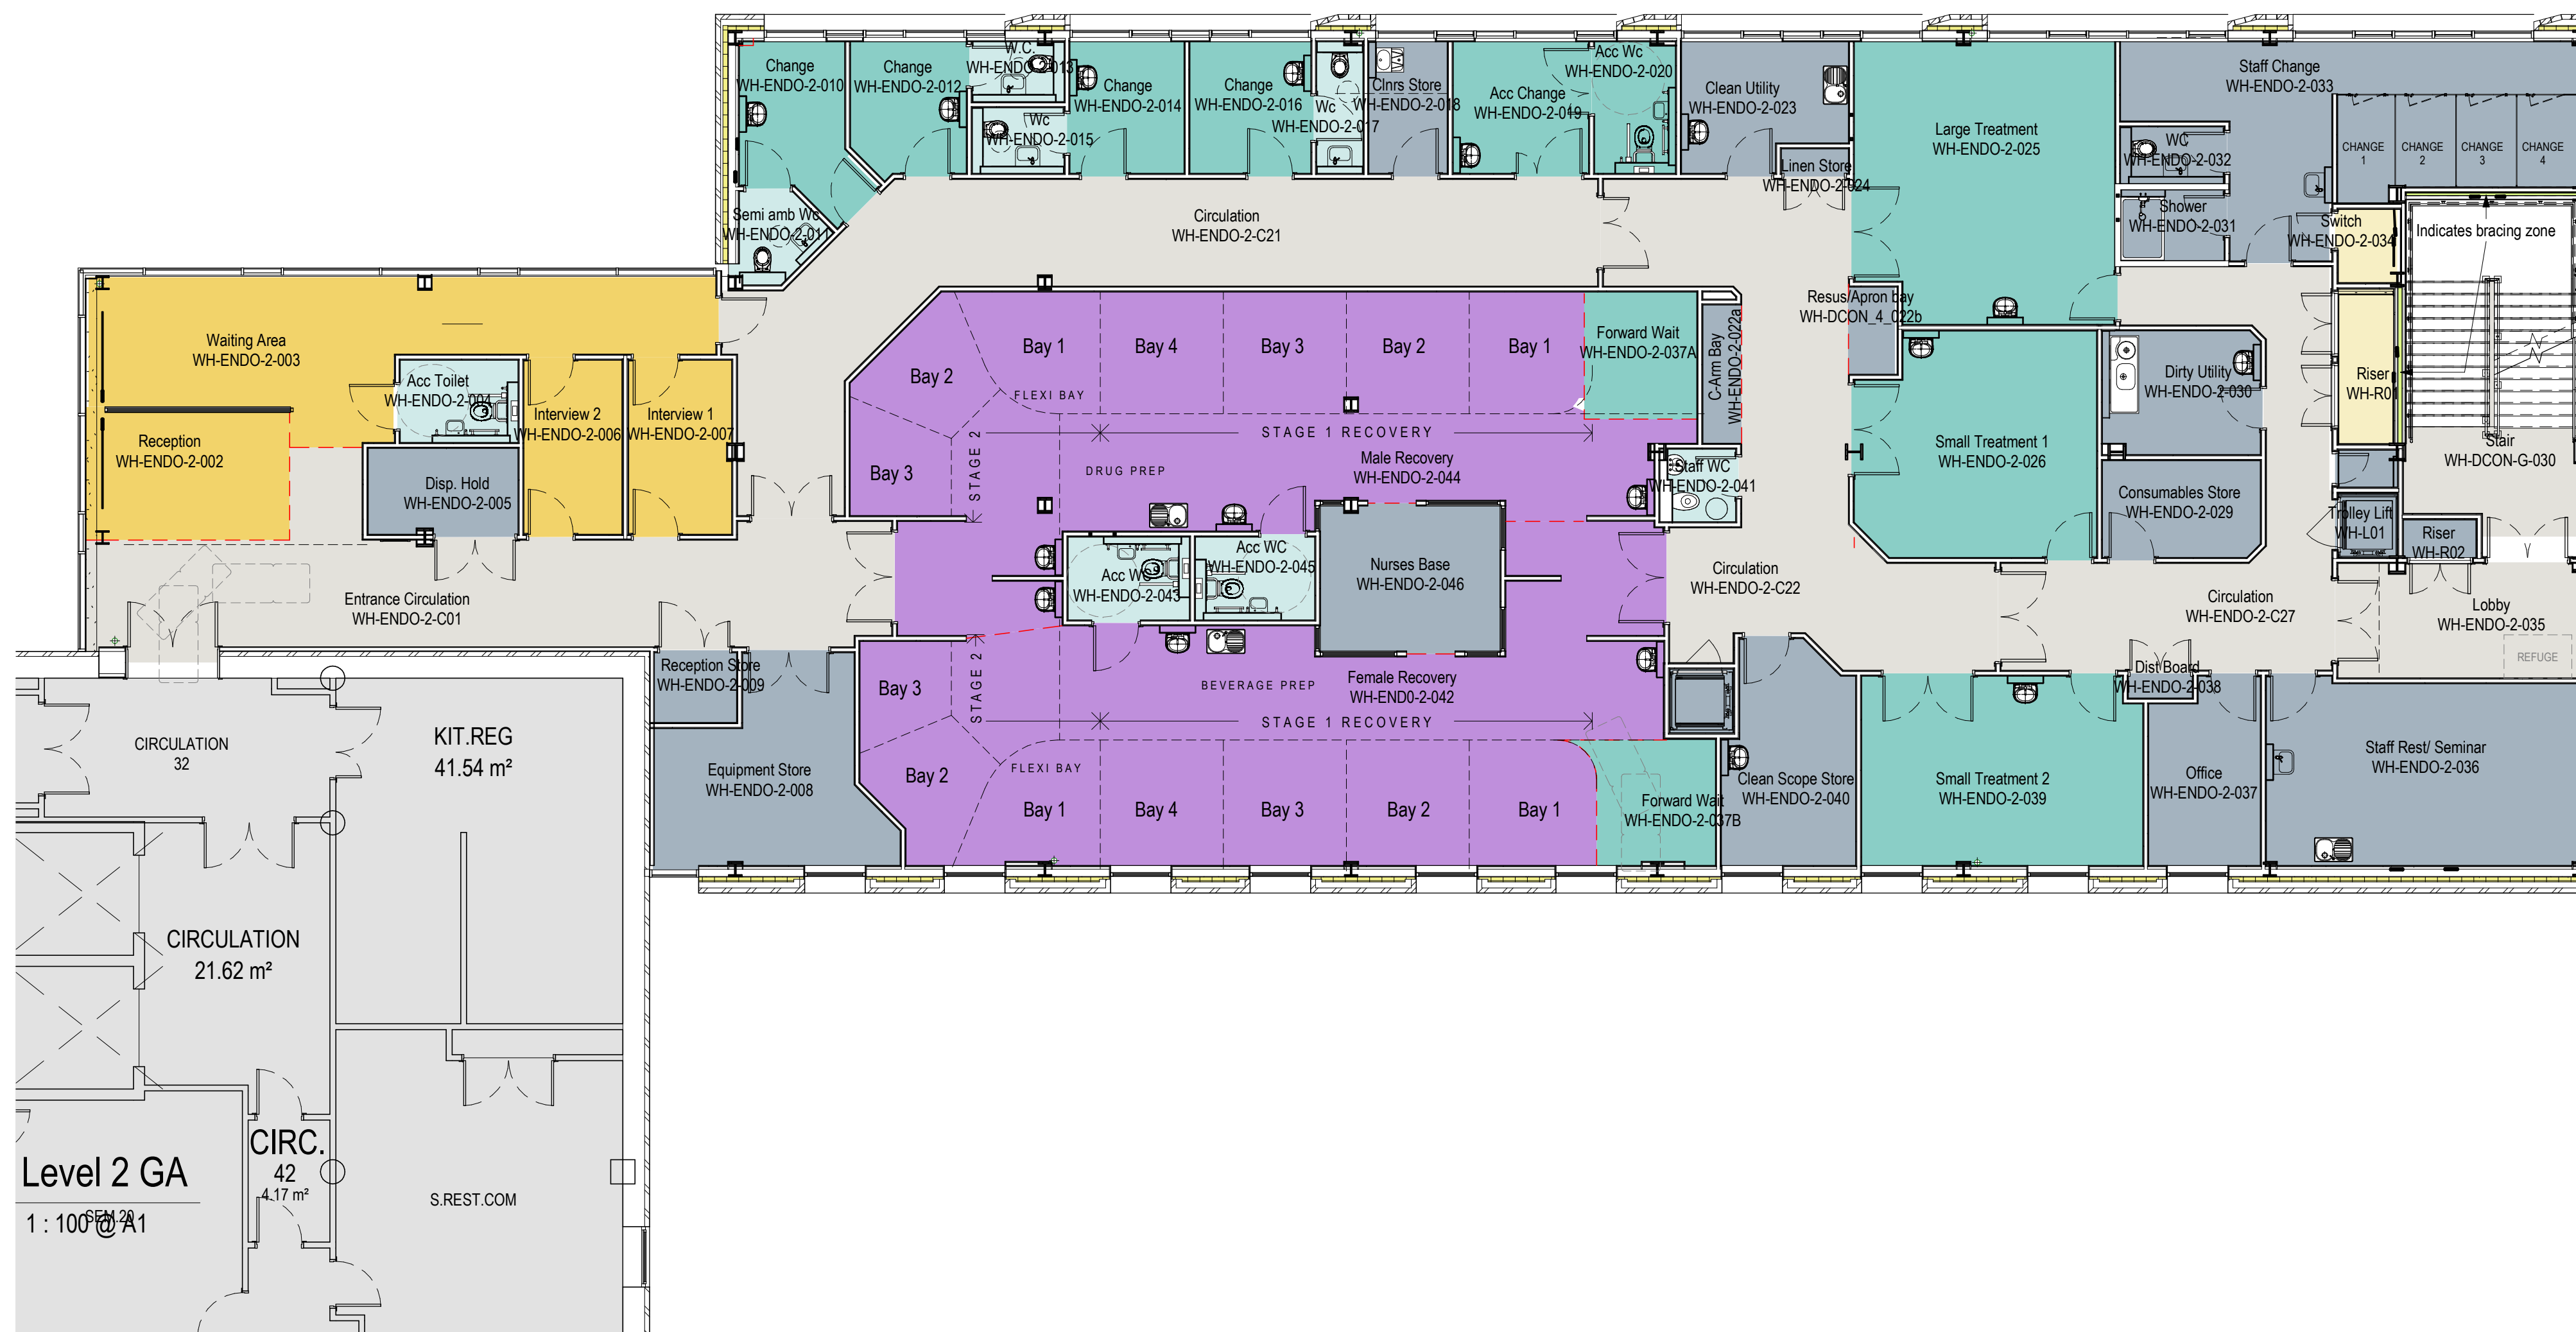
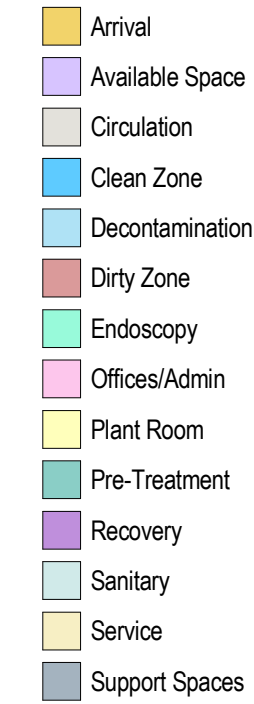


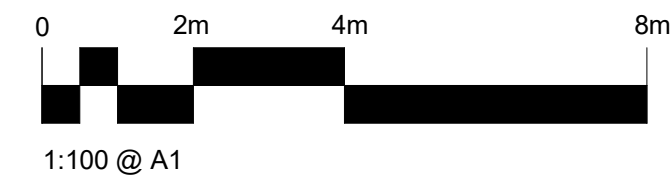

G	Windows updated in line with planning feedback	20.07.23	TM	OC
F	Scale Bar and North Arrow added.	24.04.23	PC	TM
E	Stage 3 issued for information	13.10.22	TM	OC
D	Plan updated to allow for mattress evacuation.	29.06.22	PC	TM
C	Plan footprint increased and revised inline with clients comments.	19.05.22	CB	TM
B	Plan updated with room & door numbers.	14.12.21	CB	TM
A	Plan updated in line with client comments.	02.12.21	CB	TM
-	First issue. For Comment/Approval.	-	-	-
PRELIMINARY				
Revision	Description	Date	Drawn	Checked

Halliday Meecham Architects Limited

111 Piccadilly Manchester M1 2HY
+44 (0)161 661 5566

4 Devonshire Street London W1W 5DT
+44 (0)203 440 5175

hma@hallidaymeecham.com
www.hallidaymeecham.com



Client:		Vinci			
Project:		Endoscopy Suite Extension			
Phase/ Location:		Whiston Hospital, Warrington Rd, Prescott, L35 5DR			
Drawing:		Proposed Level 02 Floor Plan			
Scale @ A1 1:100	Scale @ A3 1:200	Date: 17.10.21	Drawn: CB	Checked: TM	Job No. 5293
Drawing No.					00203
Drawing Ref.					Revision
5293-HMA-ES-L2-DR-A-00203					G