


- Arrival
- Available Space
- Circulation
- Clean Zone
- Decontamination
- Dirty Zone
- Endoscopy
- Offices/Admin
- Plant Room
- Pre-Treatment
- Recovery
- Sanitary
- Service
- Support Spaces

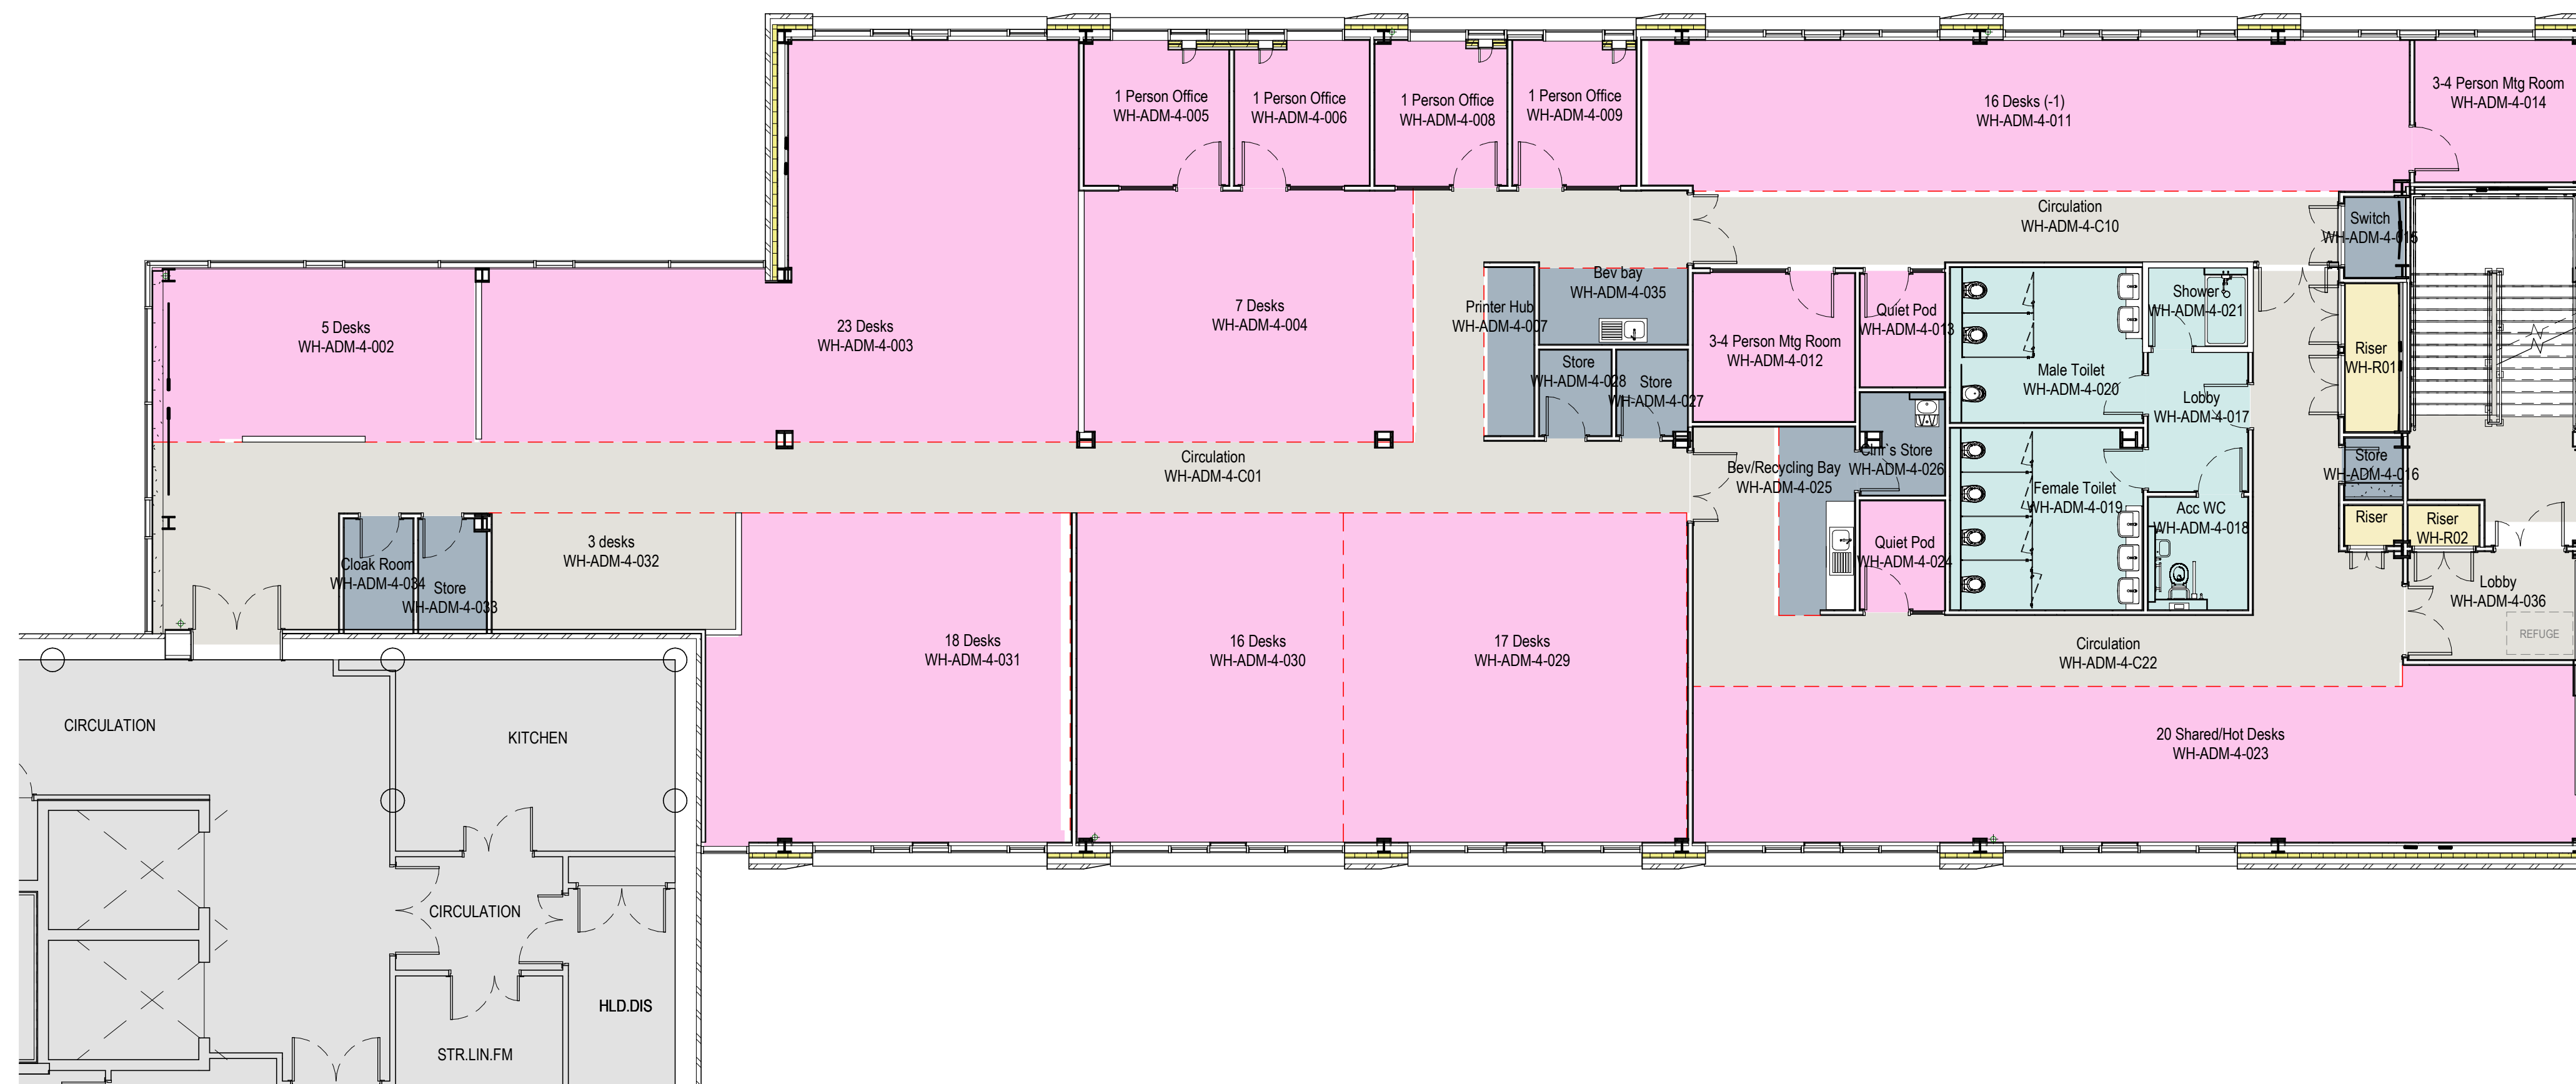

Level 4 GA

1 : 100 @ A1

I	Windows updated in line with planning feedback	20.07.23	TM	OC
H	Scale Bar and North Arrow added.	24.04.23	PC	TM
G	Stage 3 issued for information	13.10.22	TM	OC
F	Accommodation updated to reflect feedback	21.07.22	TM	OC
E	Accommodation updated to reflect revised client brief	14.07.22	TM	OC
D	Plan footprint increased and revised inline with clients comments.	19.05.22	CB	TM
C	Plan updated in line with client comments.	12.01.22	CB	TM
B	Plan updated with room & door numbers.	14.12.21	CB	TM
-	First issue. For Comment/Approval.	-	-	-
PRELIMINARY				
Revision	Description	Date	Drawn	Checked

Halliday Meecham Architects Limited

111 Piccadilly Manchester M1 2HY
+44 (0)161 661 5566

4 Devonshire Street London W1W 5DT
+44 (0)203 440 5175

hma@hallidaymeecham.com
www.hallidaymeecham.com



Client:		Vinci			
Project:		Endoscopy Suite Extension			
Phase/ Location:		Whiston Hospital, Warrington Rd, Prescott, L35 5DR			
Drawing:		Proposed Level 04 Floor Plan			
Scale @ A1	Scale @ A3	Date:	Drawn	Checked:	Job No.
1:100	1:200	17.10.21	CB	TM	5293
Drawing Ref.					Drawing No.
5293-HMA-ES-L4-DR-A-00205					00205
					Revision
					1