

LEGEND

SPOT LEVEL 99.99
FLOOR LEVEL FL99.99
CEILING LEVEL CL99.99
SUSPENDED CEILING LEVEL SUS99.99
UNDERSIDE OF BEAM USB99.99
DOOR HEIGHT DH99.99
SILL LEVEL SB9.99
LINTEL LEVEL L99.99
ARCH TOP LEVEL AT99.99
ARCH BOTTOM LEVEL AB99.99


SOLID WALLS
PARTITION WALLS
BOILER
BUILDING CANOPIES
BUILDINGS
CABLES
CLADDING
COLUMN
DIMENSIONS
DOORS
DUCTING

ELEVATION DATUM
ELEVATIONS STRUCTURAL
ELEVATIONS DETAIL
FENCES
HANDRAILS
HATCH
INSPECTION COVERS
KITCHEN FURNITURE
LADDERS
LEVELS
LIGHTING
BEAMS
CEILING DETAIL
PIPES
RADIATORS
SEATING
SECTIONS
SERVICES
SKYLIGHTS
STEELWORK
STEPS STAIRS
SURFACE CHANGES
TANKS
VENTS
WALLS
SANITARY FITTINGS
WINDOWS
WORKTOPS
HIDDEN DETAIL

LEVEL MARKER 99.99
LEVEL MARKER 99.99
STAIRS/RAMP
DIRECTION
SLOPING CEILING
DIRECTION
BREAK LINE

TOILET
SHOWER
BATH
URINAL
WASH BASIN
KITCHEN SINK
DOOR SWING

TV AERIAL SOCKET AER
ALARM SENSOR AS
ALARM AL
SINGLE COMPUTER SOCKET CPS
DOUBLE COMPUTER SOCKET CPS
TRIPLE COMPUTER SOCKET CPS
EXTRACTOR FAN EXF
FIRE ALARM FA
FIRE ALARM SWITCH FAS
FLOOR SOCKET FS
HAND DRYER HD
SINGLE LIGHT SWITCH LS
DOUBLE LIGHT SWITCH LS
TRIPLE LIGHT SWITCH LS
SINGLE PLUG SOCKET PS
DOUBLE PLUG SOCKET PS
TRIPLE PLUG SOCKET PS
UNKNOWN SOCKET PS
SINGLE SWITCH SW
DOUBLE SWITCH SW
TRIPLE SWITCH SW
BOILER SWITCH BOS
EXTRACTOR FAN SWITCH EFS
SWITCH BOARD SWB
SINGLE PHONE SOCKET TEL
DOUBLE PHONE SOCKET TEL
TRIPLE PHONE SOCKET TEL
THERMOSTAT TH
WALL LIGHT WL
LIGHT LI
SMOKE DETECTOR SD
RADIATOR RAD

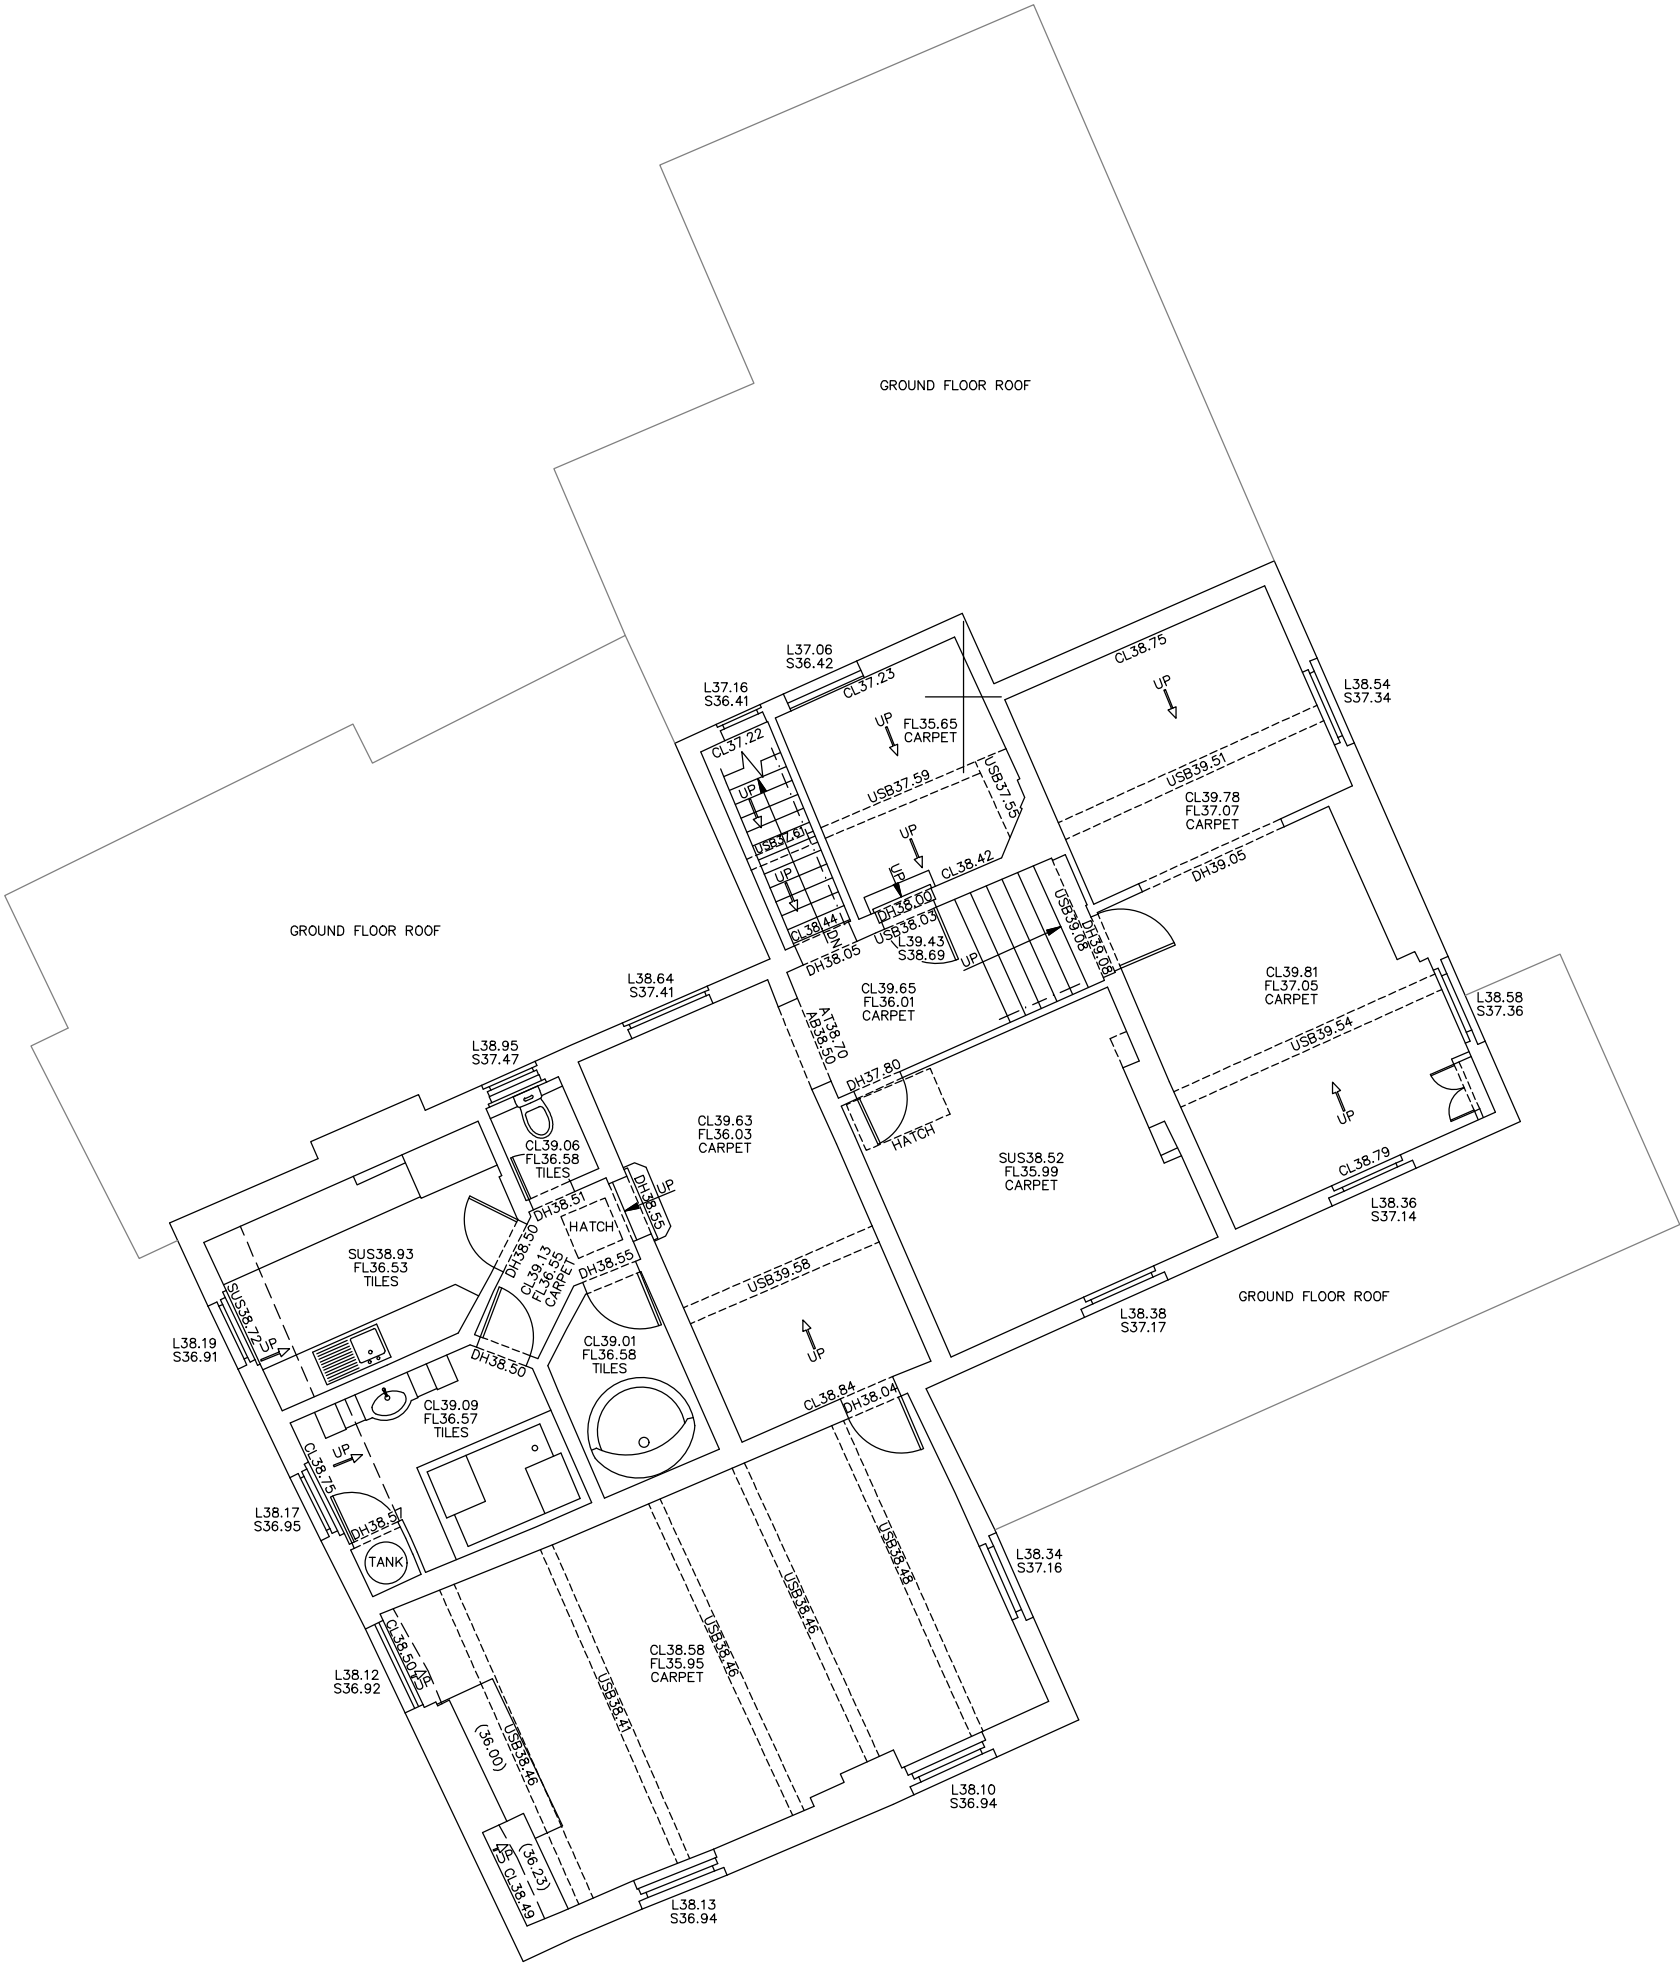

© Survey & Engineering Projects Ltd. 2023
Reproduction in whole or in part by any means is prohibited
without the prior permission of Survey & Engineering Projects Ltd.
T. (01695) 729835 F. (01695) 725566 W. www.sepsurvey.com E. info@sepsurvey.com

 


PLAN GRID NORTH

File Name: S24858-1F.dwg

NOTES:

All levels relate to O.S (Newlyn) Datum, Established using network RTK.
Survey plotted on a plane local grid, orientated to National Grid.



REV	DATE	DESCRIPTION



Client
Revival Architecture
Suite 203
Queens Dock Business Centre
67-83 Norfolk Street
Liverpool
L1 0BG

Project Title
First Floor Plan at:
The Unicorn Public House
Cronton Road
Widnes
WA8 5QF

Surveyed I.Bryning	Drawn B.Carr	Checked R.Critchley
Scale 1:100	Date Nov 23	Drawing Ref. S24858-1F
No. 01	Size A2	Rev --