



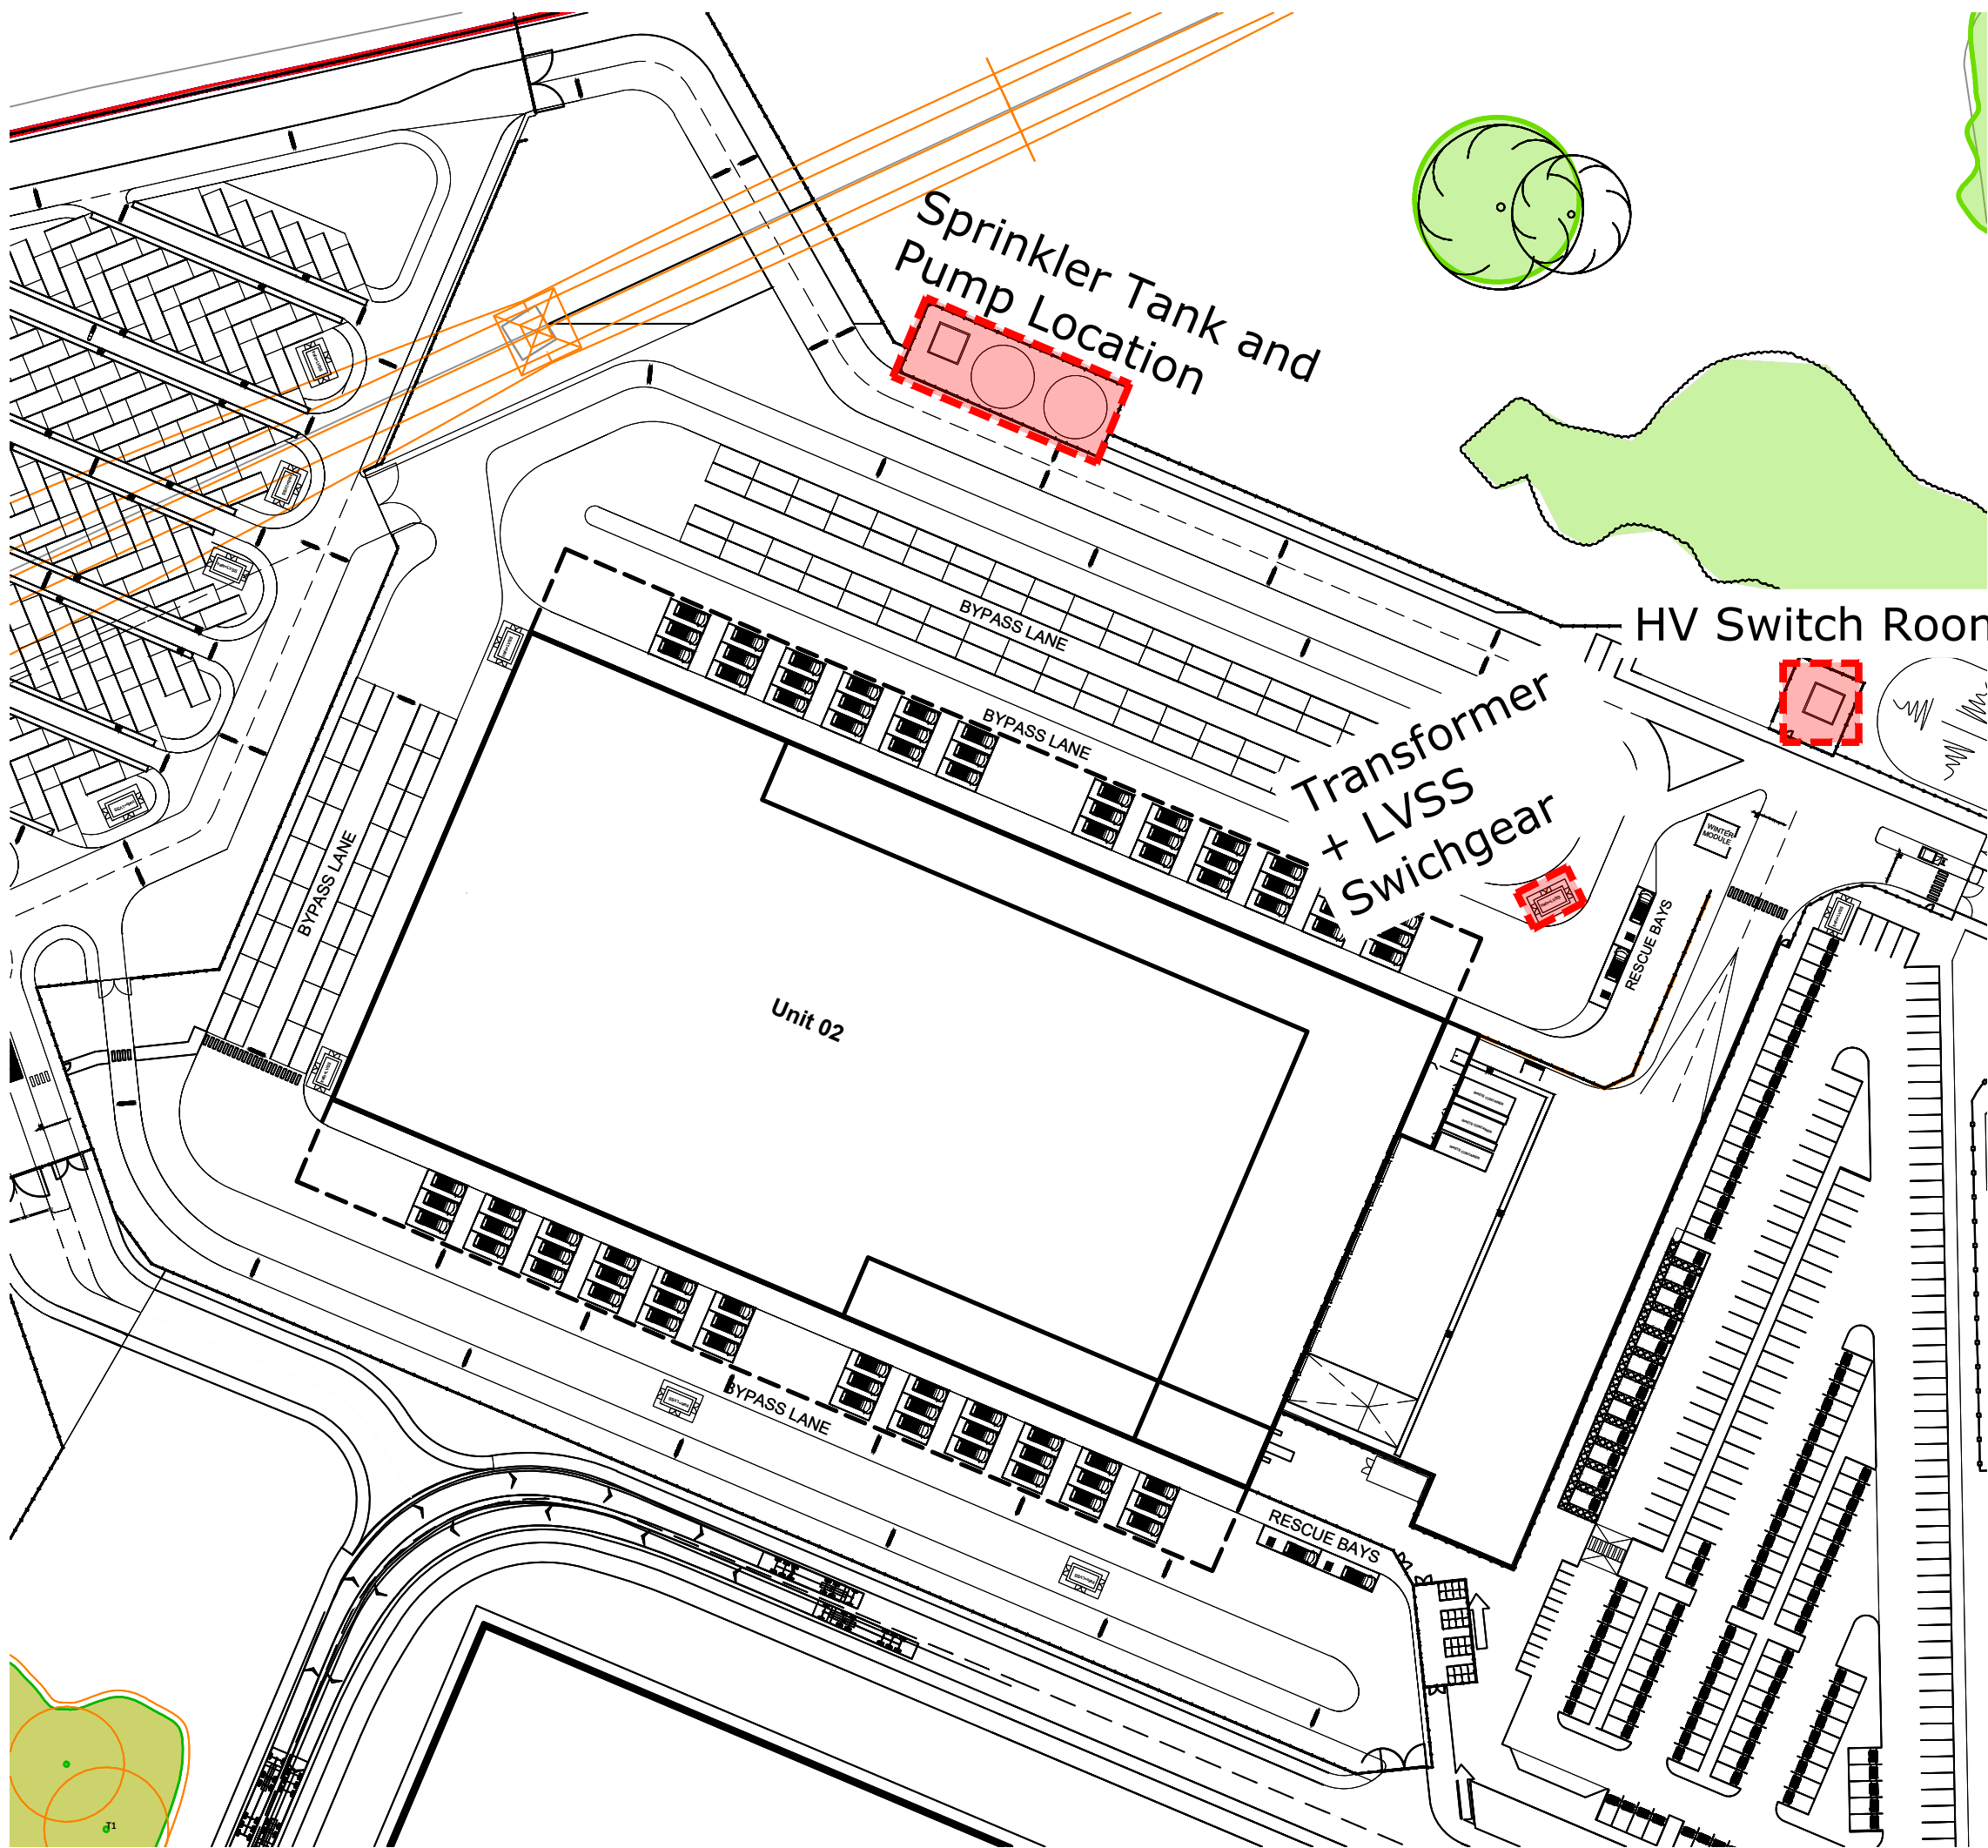


Site Plan @ 1:1000


New Substation and Future Transformer Design @ 1:20

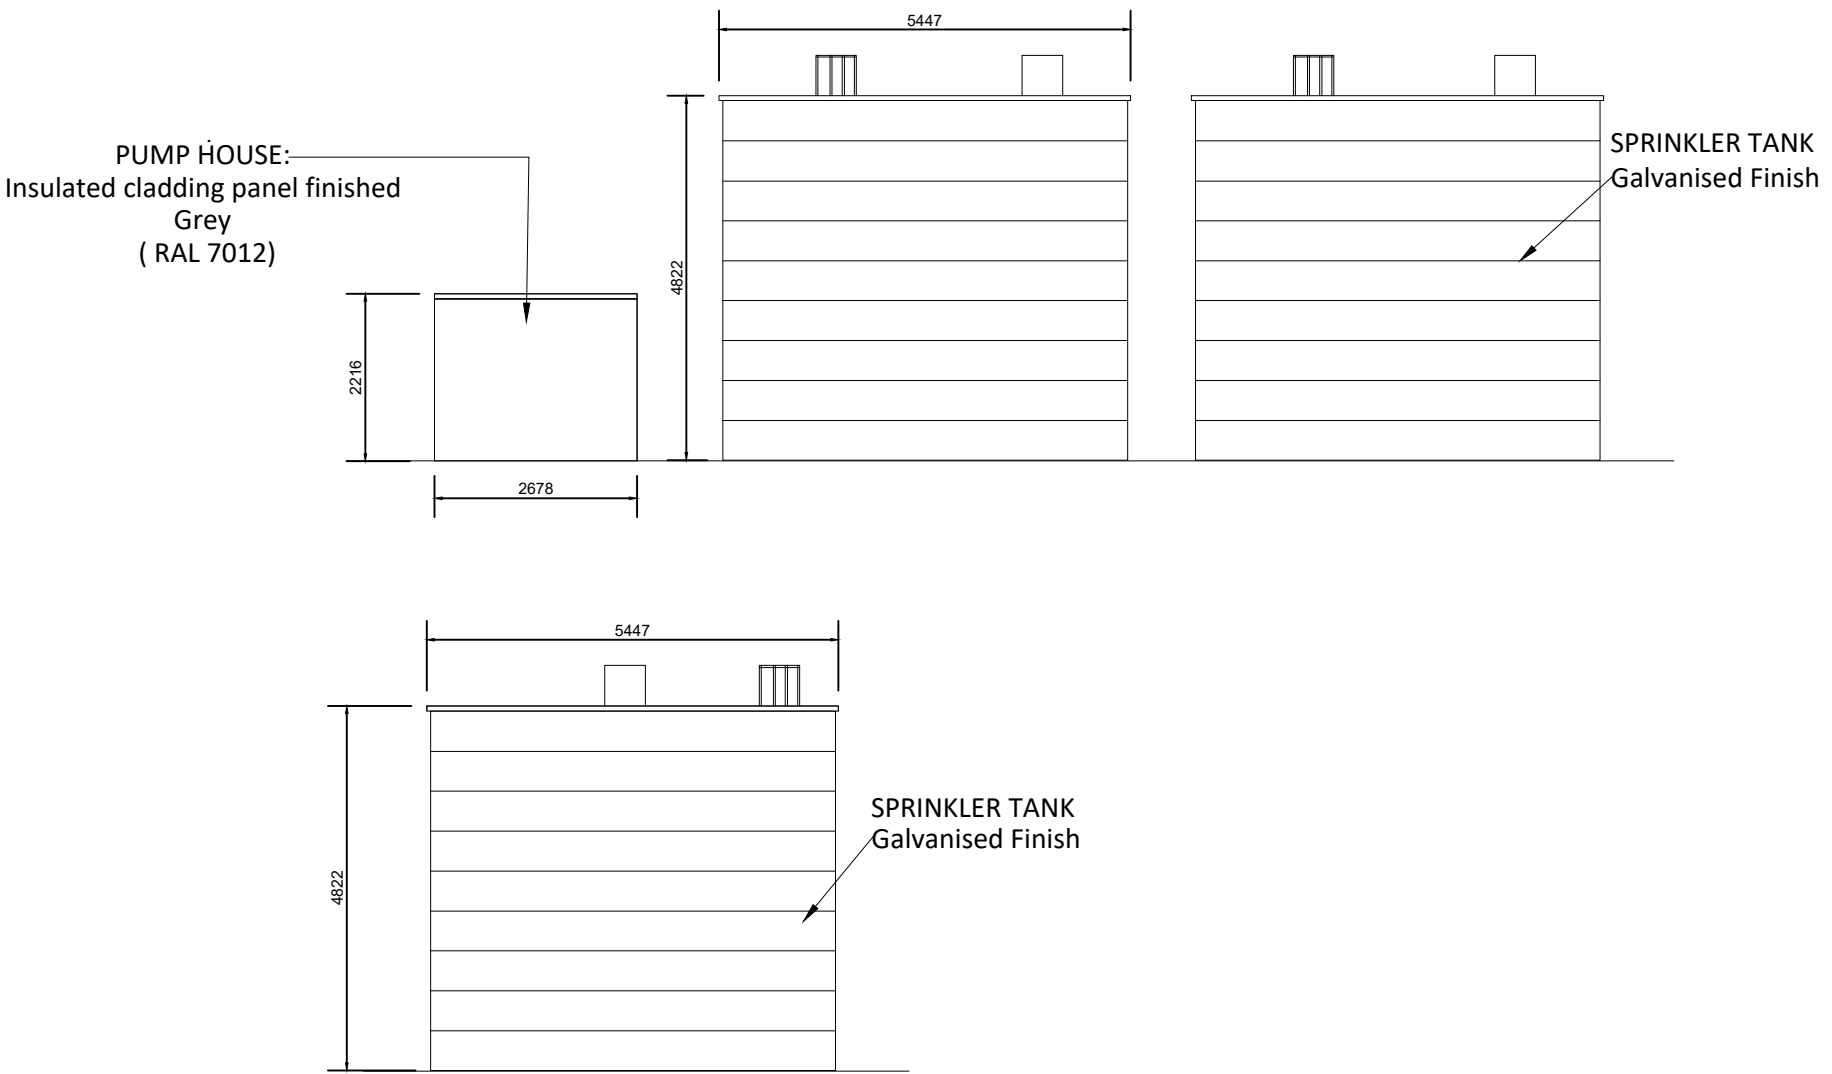



Proposed Sprinkler Tank and Pump @ 1:100

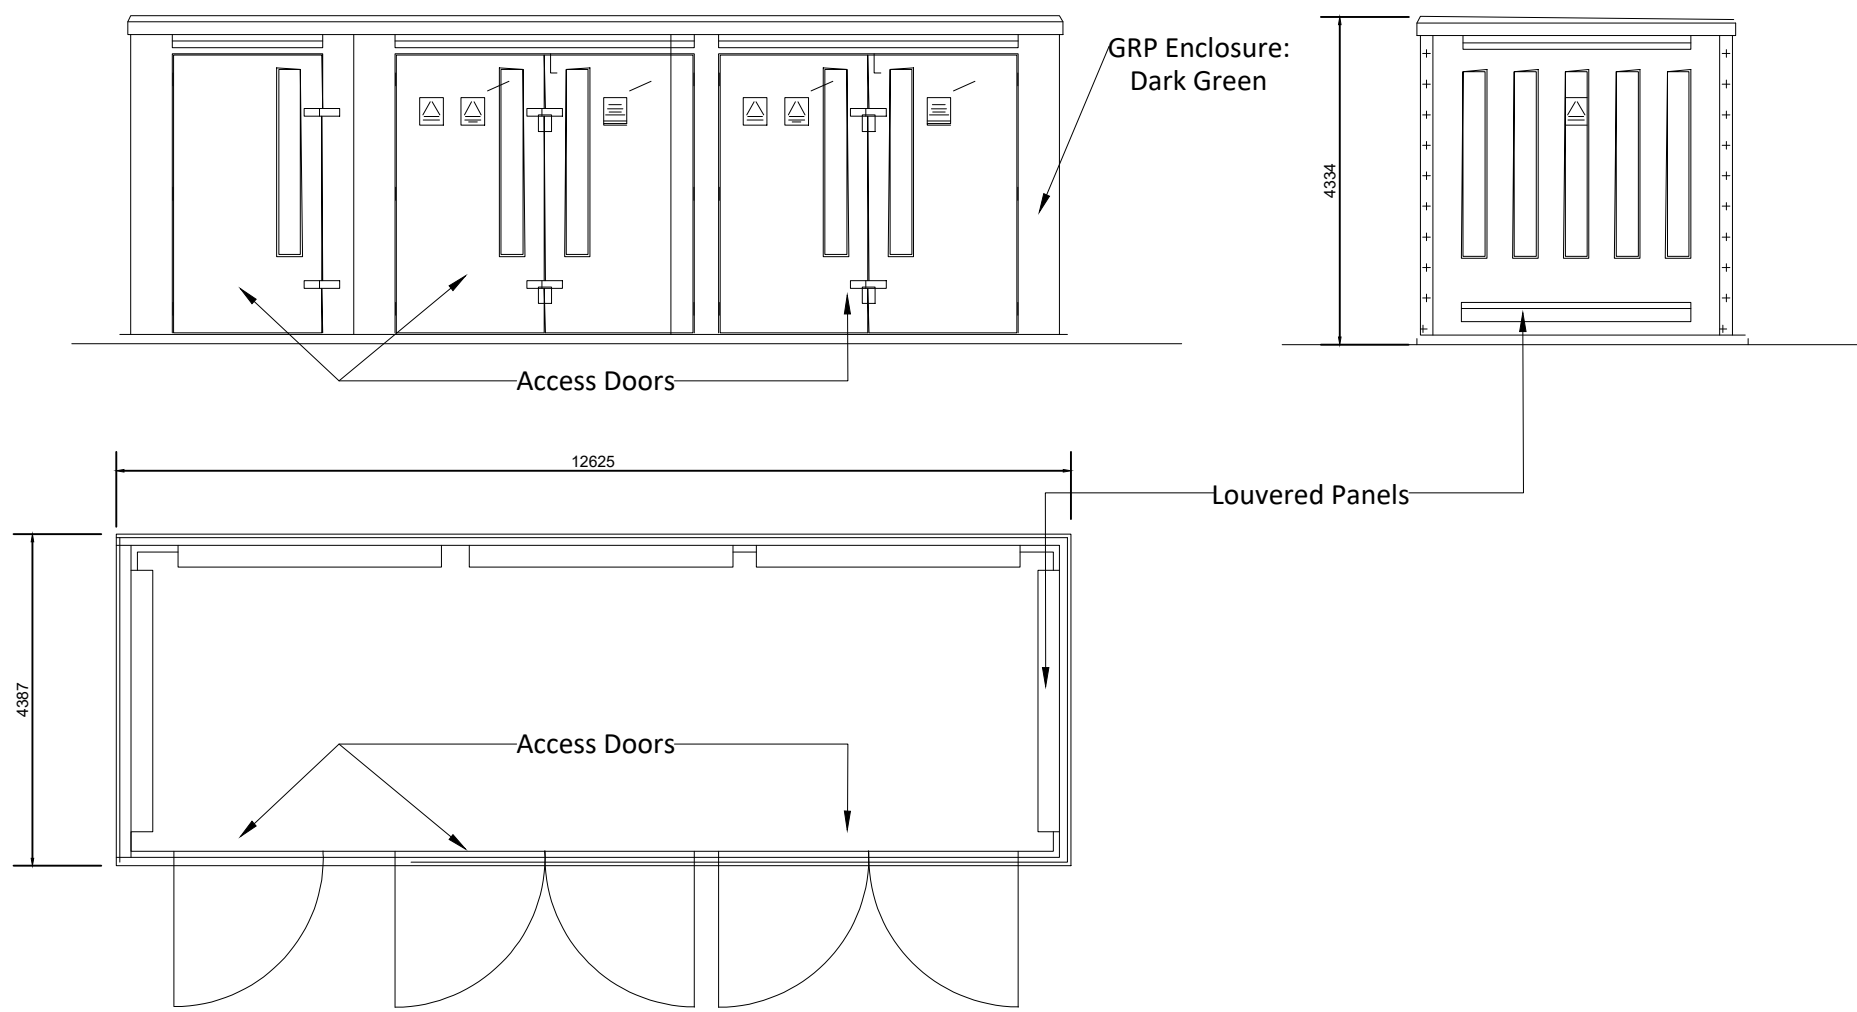

11KV Switchroom @ 1:100

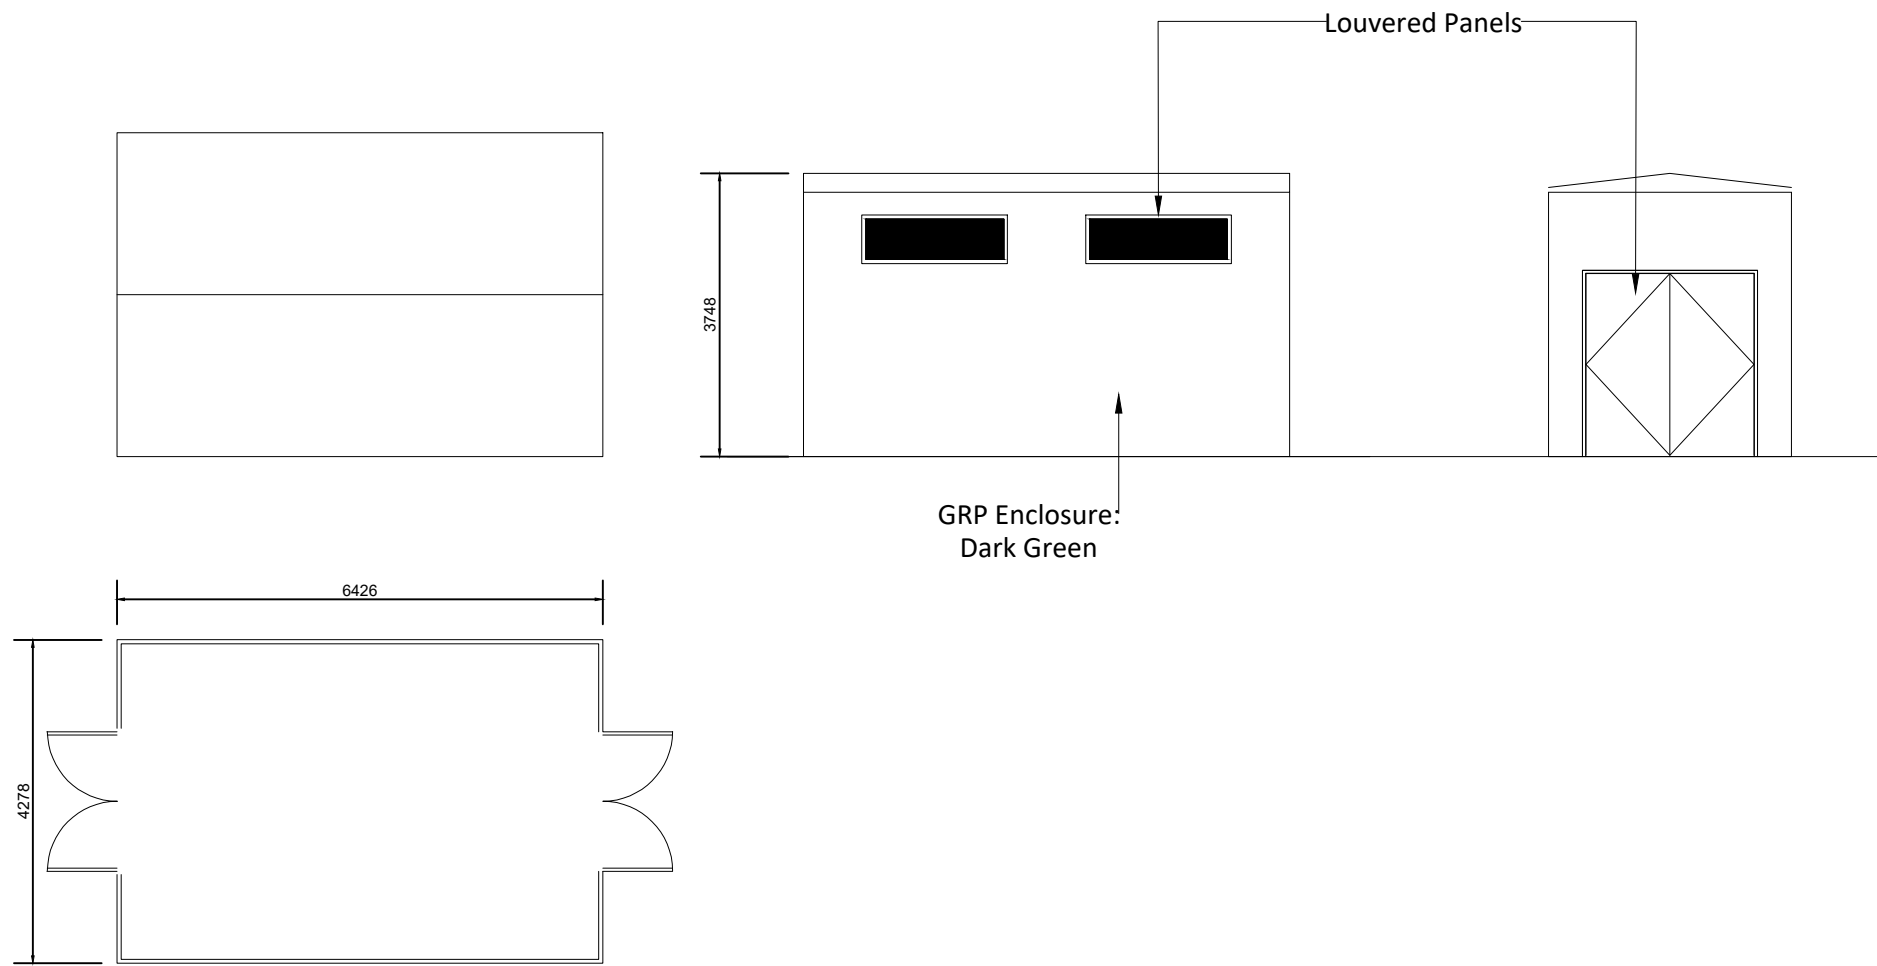

Future EV LV Switchgear @ 1:100

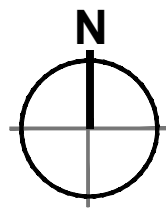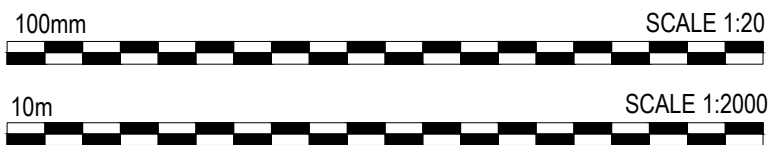

- Masterplan Boundary
- Existing Overhead Power Lines
- Application Boundary
- Location

Dimensions are in millimeters, unless stated otherwise.
Scaling of this drawing is not recommended.
It is the recipients responsibility to print this document to the correct scale.
All relevant drawings and specifications should be read in conjunction with this drawing.

PLANNING
THIS DRAWING IS FOR PLANNING CONSIDERATION ONLY
AND SHOULD NOT BE USED FOR ANY OTHER PURPOSE

rev	amendments	by	ckd	date
Phase 2, Symmetry Park, Merseyside				
Unit 2-Sprinkler Tank and Switch Room Details				
TRITAX SYMMETRY A TRITAX BIG BOX COMPANY				
umc architects 3rd Floor, Manchester Club, 81 King Street, Manchester, M2 4AH t: +44 (0)161 413 0590 e: info@umcarchitects.com				
Drawing Status:		Planning		
Drawn / Checked:		MY / DEB		
Date:		13/11/2020		
Scale:		As Noted @A1		
Drawing no:		Revision:		
21351 P0707		H		