




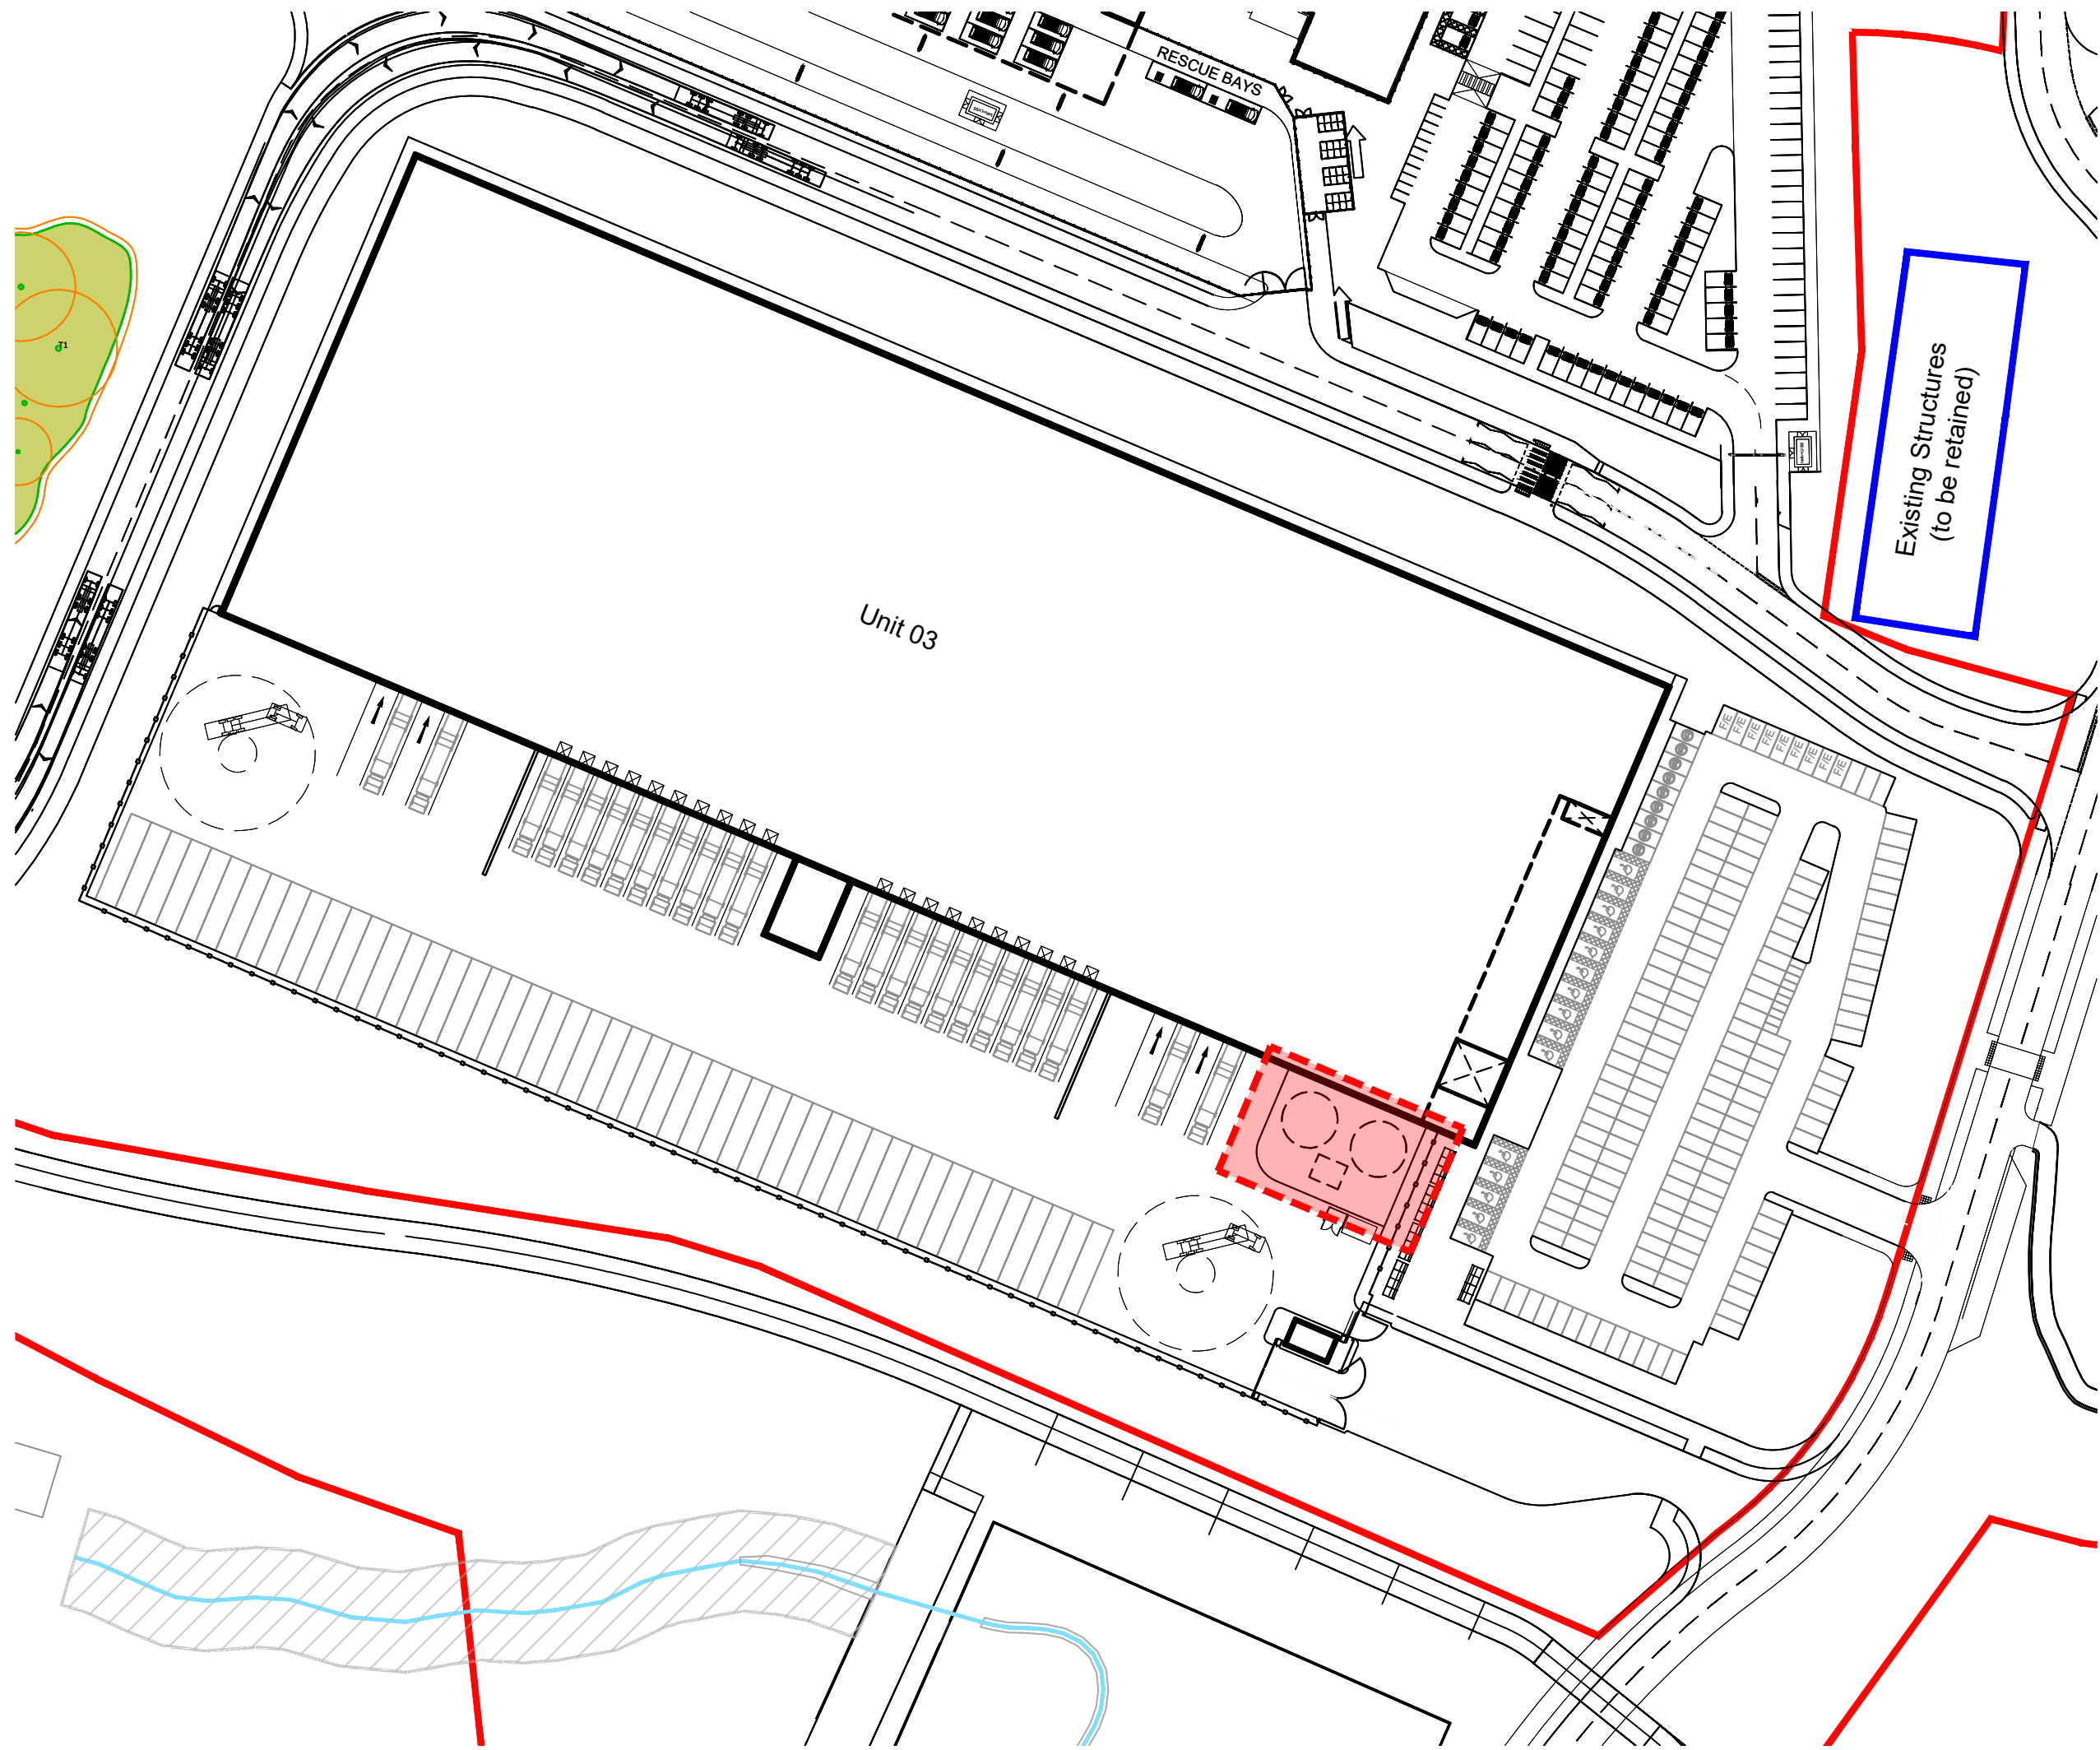


Site Plan Scale 1:1000

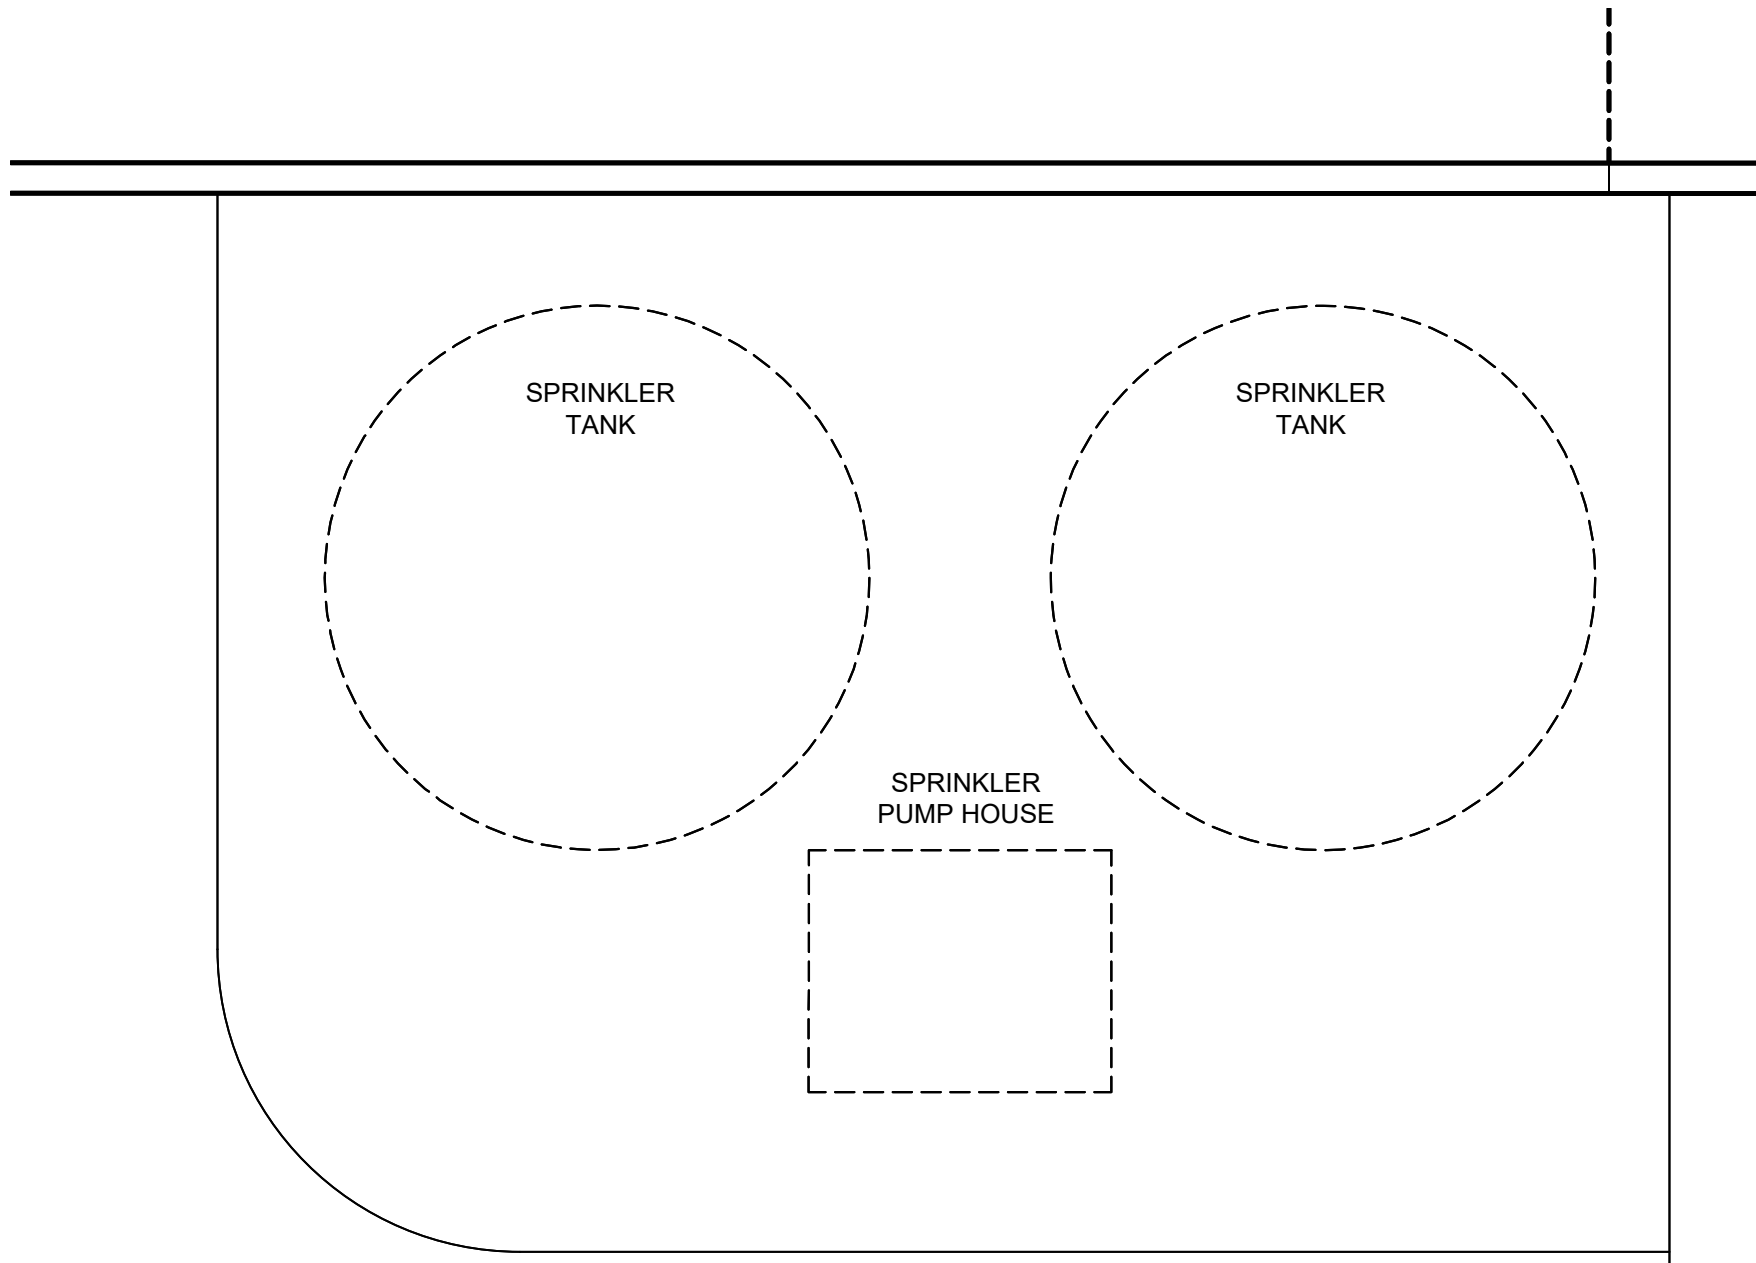

Sprinkler Tanks and Pump House Layout Scale 1:100

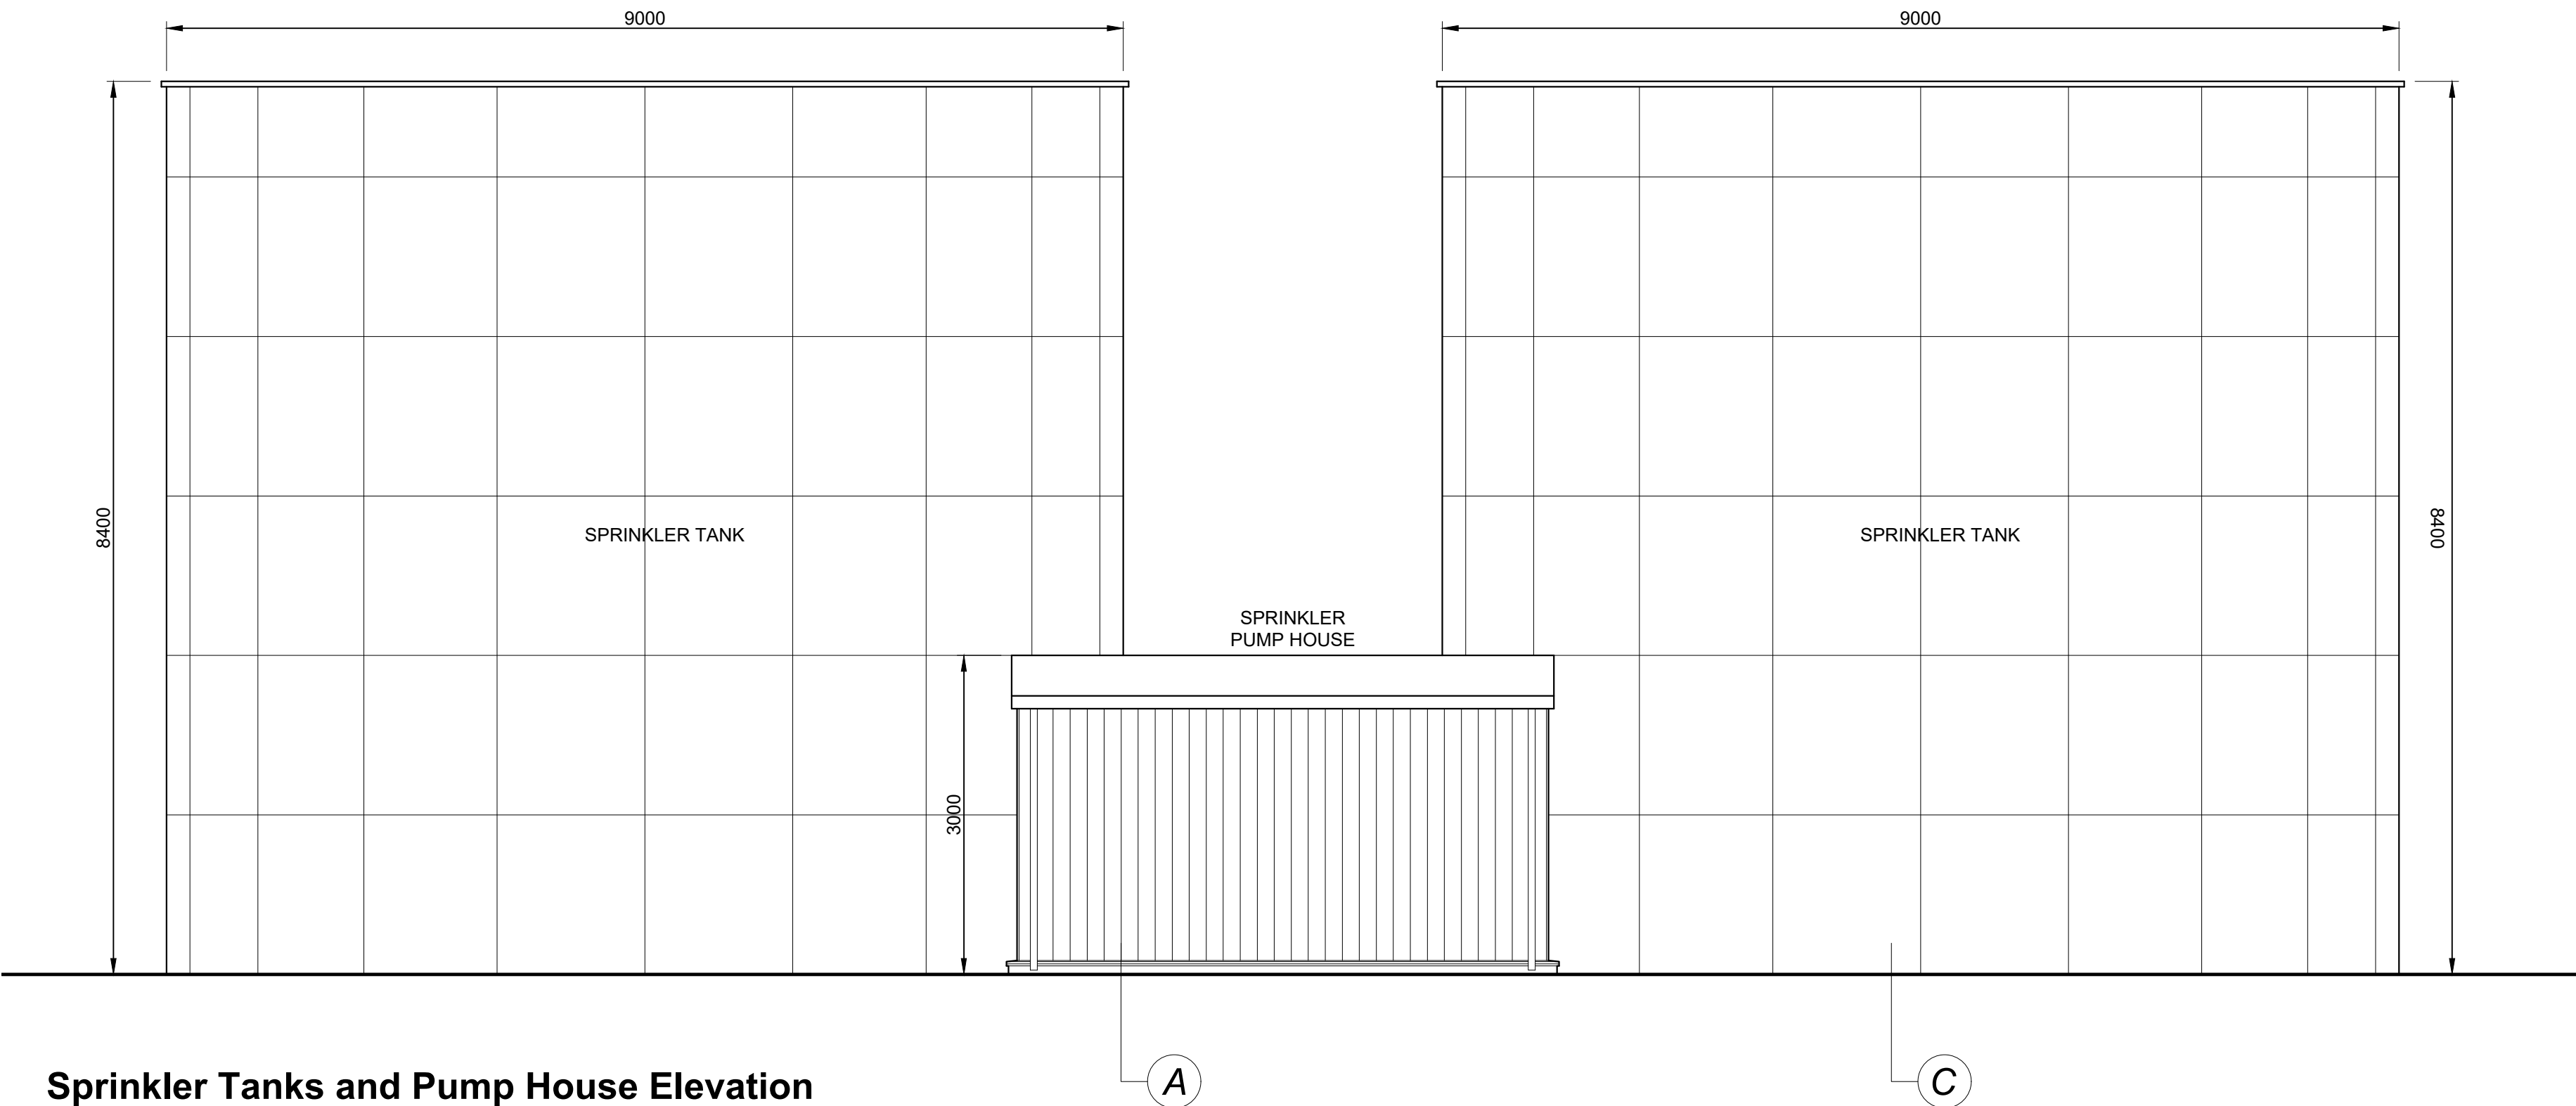

Sprinkler Tanks and Pump House Elevation Scale 1:50

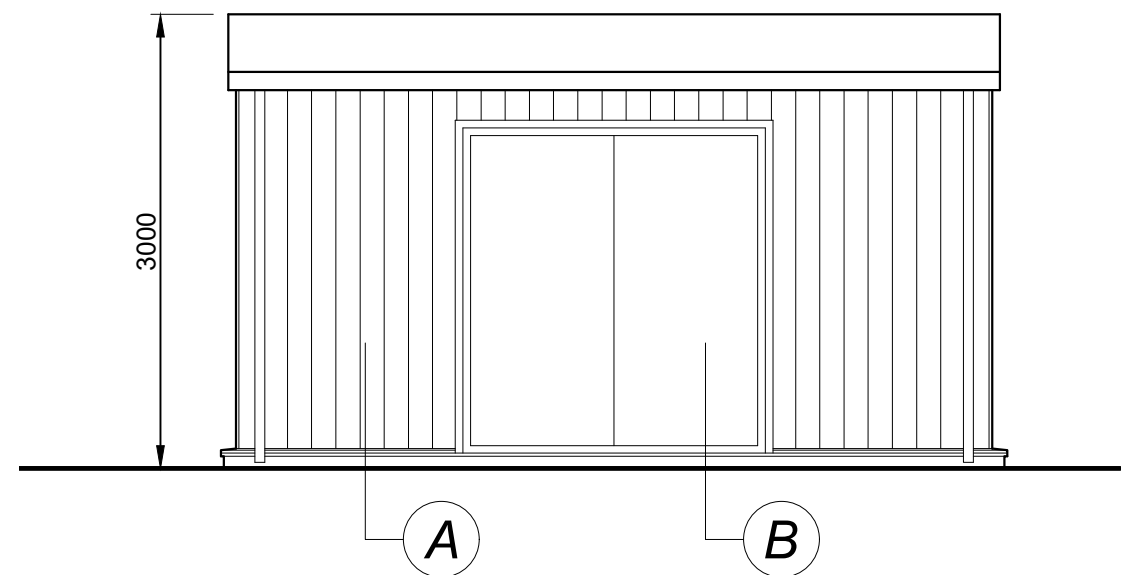


Pump House Elevation

Scale 1:50


External Finishes

- A** Vertically laid  
Profiled wall cladding system.  
Finish: Tata Colorcoat HPS 200 Ultra.  
Colour: Alaska Grey (RAL 7000)
- B** Steel insulated personnel door & frame  
Finish: Factory applied polyester powder  
coat paint finish.  
Colour: Anthracite (RAL 7016)
- C** Galvanised steel water storage tanks  
Finish: Factory applied polyester powder  
coat paint finish  
Colour: Metallic Silver (RAL 9006)

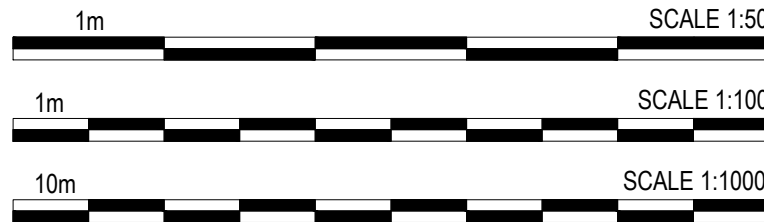

**PLANNING**  
THIS DRAWING IS FOR PLANNING CONSIDERATION ONLY  
AND SHOULD NOT BE USED FOR ANY OTHER PURPOSE

· Dimensions are in millimeters, unless stated otherwise.  
· Scaling of this drawing is not recommended.  
· It is the recipients responsibility to print this document to the correct scale.  
· All relevant drawings and specifications should be read in conjunction with this drawing.

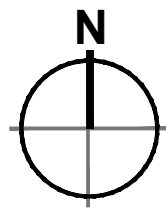

- Application Boundary
- Smoking Shelter Location

Phase 2, Symmetry Park,  
Merseyside  
Unit 3 - Sprinkler Tank and Pump House

**TRITAX SYMMETRY**  
A TRITAX BIG BOX COMPANY

**umc architects**  
3rd Floor, Manchester Club, 81 King Street, Manchester, M2 4AH  
t: +44 (0)161 413 0590 e: info@umcarchitects.com

|                  |              |
|------------------|--------------|
| Drawing Status:  | Planning     |
| Drawn / Checked: | AP / DEB     |
| Date:            | 28/10/2021   |
| Scale:           | As Noted@ A1 |
| Drawing no:      | Revision:    |
| 21351 P2704      | F            |