


EV Charge Point Schedule		
7.4 kW EV Charge Parking Bays		
EV Parking	Quantity	Unit 03
EV Car Parking Bays	58	
Disabled EV Car Parking Bays	2	
Total EV Parking Bays	60	



7.4kW Type 2 Mode 3 EV Charge Point

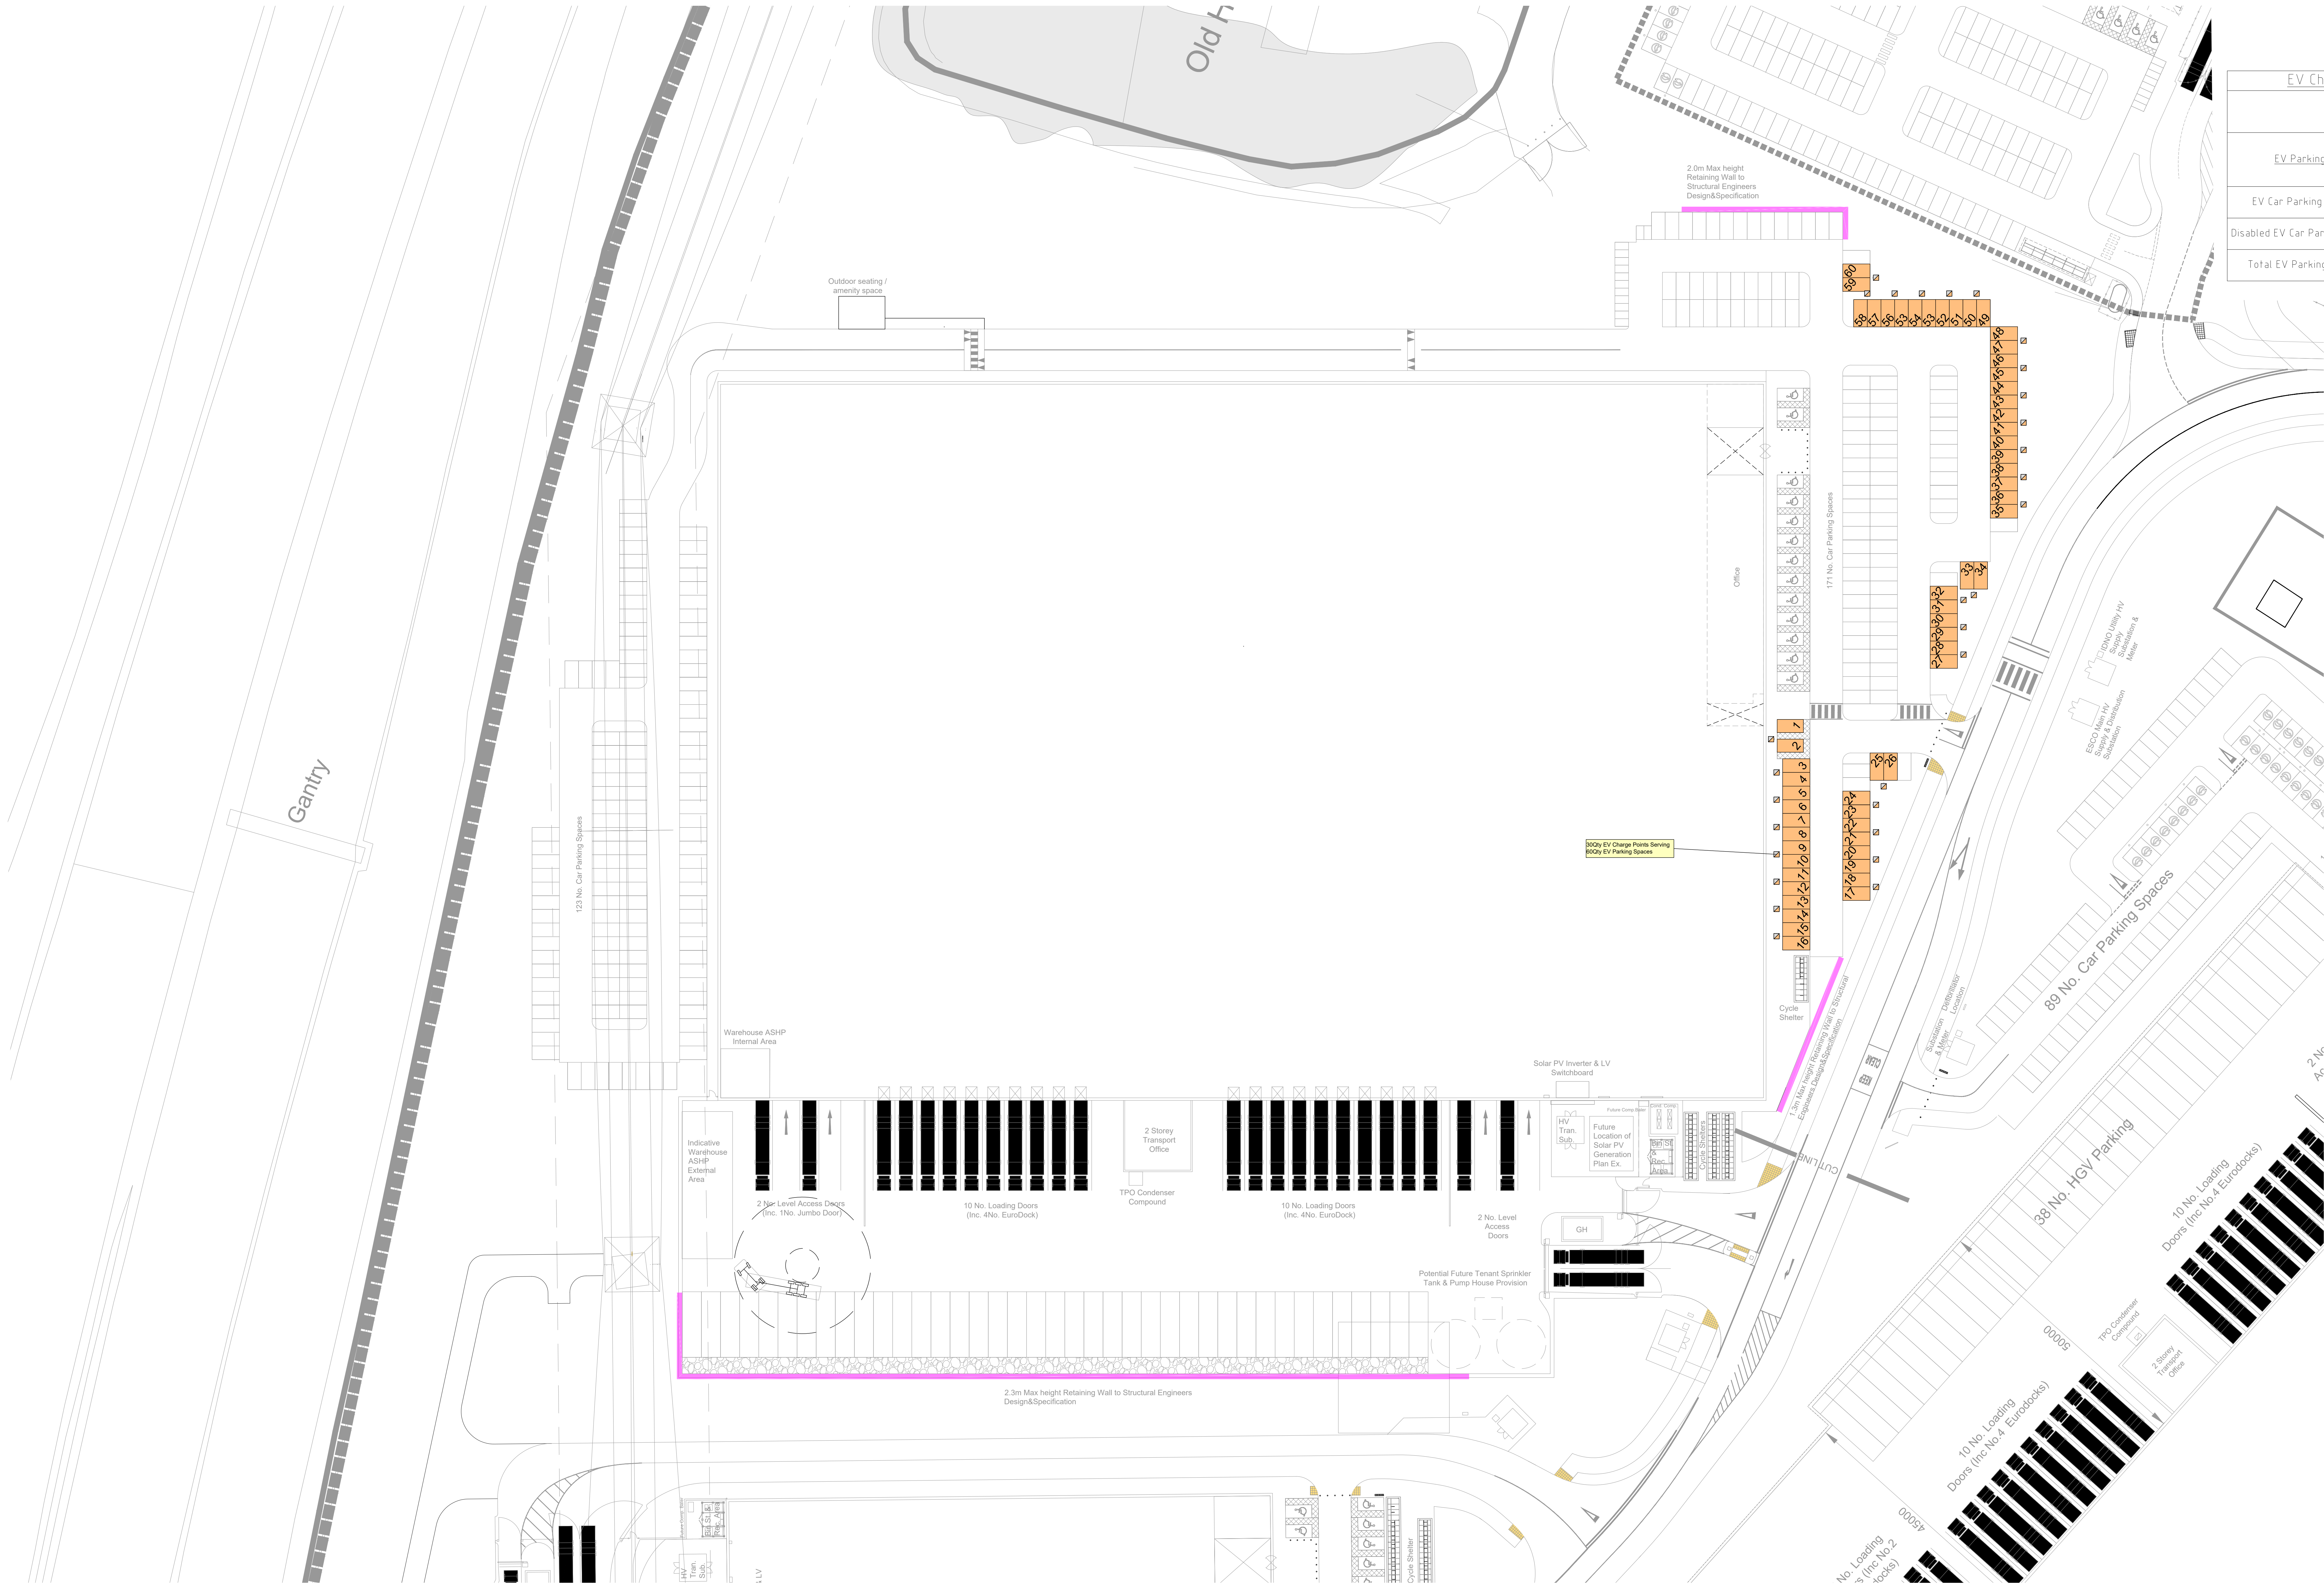

26	Updated To Sul Architects Masterplan Drawing Number	TRF	JW
03	2005-UMC-0000-SI-DPA-001-Illustrative Masterplan-POB		
24	FOR APPROVALS		
23	FOR APPROVALS	TRF	JW
11			
23			
1	Description	Issue	Revised

Hannan Associates
MEP Design Solutions

Hannan Associates Ltd
Beta House
Alphington Drive
Manchester Road
Denton
M4 5BH
Tel: +44 (0)161 337 2200
Email: info@hannan-uk.com
Web: www.hannan-uk.com



Project	
Symmetry Park Merseyside	
Design Stage	
Planning	
Drawing Title	
Site Plan - Unit 03 Electrical Services EV Charge Strategy	
IRN Project Number	Scale @ A3
4032	1:400
Drawing Number	
02514 - HAN - PL - 03 - DR - E - 009051	