


EV Charge Point Schedule		
	7.4 kW EV Charge Parking Bays	
<u>EV Parking</u>	<u>Quantity</u> <u>Unit 04</u>	
EV Car Parking Bays	38	
Disabled EV Car Parking Bays	2	
Total EV Parking Bays	40	

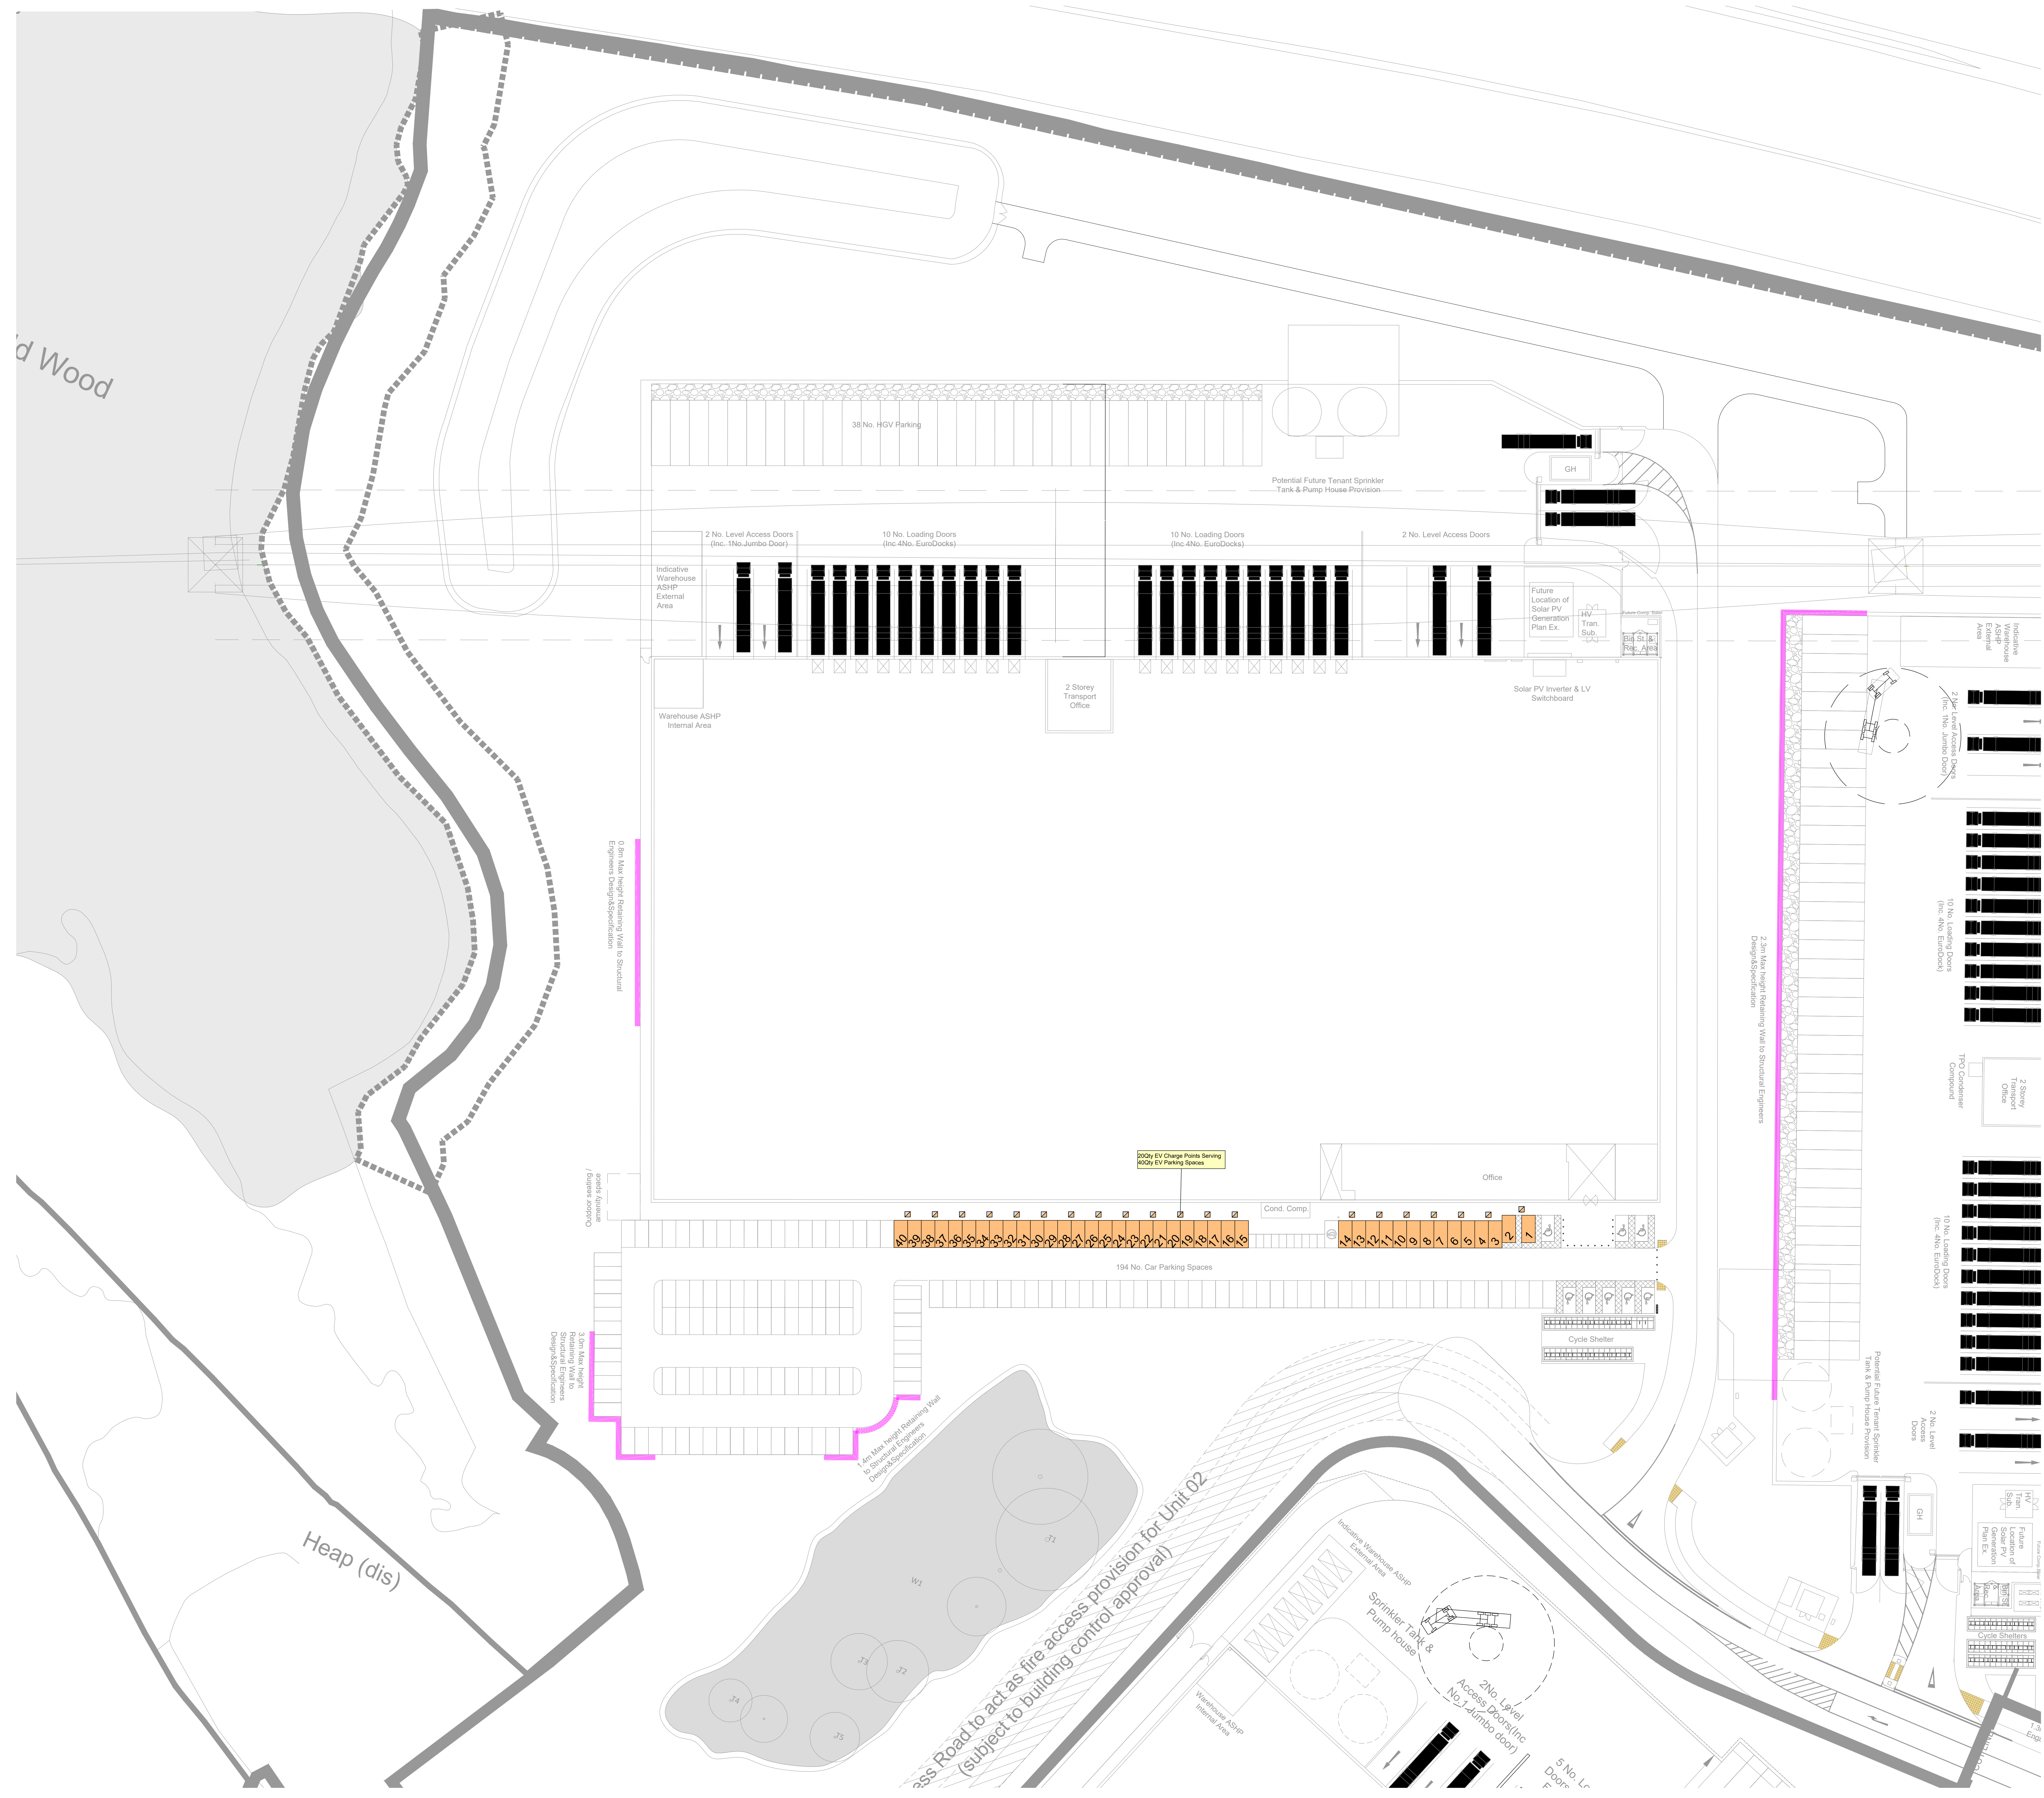

7.4kW Type 2 Mode 3
EV Charge Point



02	Updated To Suit Architects Masterplan Drawing Number 22065-ENR-XXXX-SB DR-A-0871-Illustrative Masterplan-P08 FOR APPROVALS	TFR	JAN
1	22 FOR APPROVALS	TFR	JAN
Date	Description	Location	Project
24			
Hannan Associates MEP Design Solutions		Hannan Associates Ltd Beta House Alphington Drive Manchester Road Derby M18 3SH Tel : +44 (0)161 337 2300 Email: info@hannan-uk.com Web: www.hannan-uk.com	
 A TRITAX BIG BOX COMPANY			
Project: Symmetry Park Merseyside			
Design stage: Planning			
Drawing Title: Site Plan - Unit 04 Electrical Services EV Charge Strategy			
DWG Project Number: 4032		Scale: (If A0) 1:400	
Drawing Number: 02514 - HAN - PL - 04 - DR - E - 009051			

This drawing is the property of Hannan Associates. It must be kept safe and used only for one project without the written consent of Hannan Associates, and must be returned upon request.