
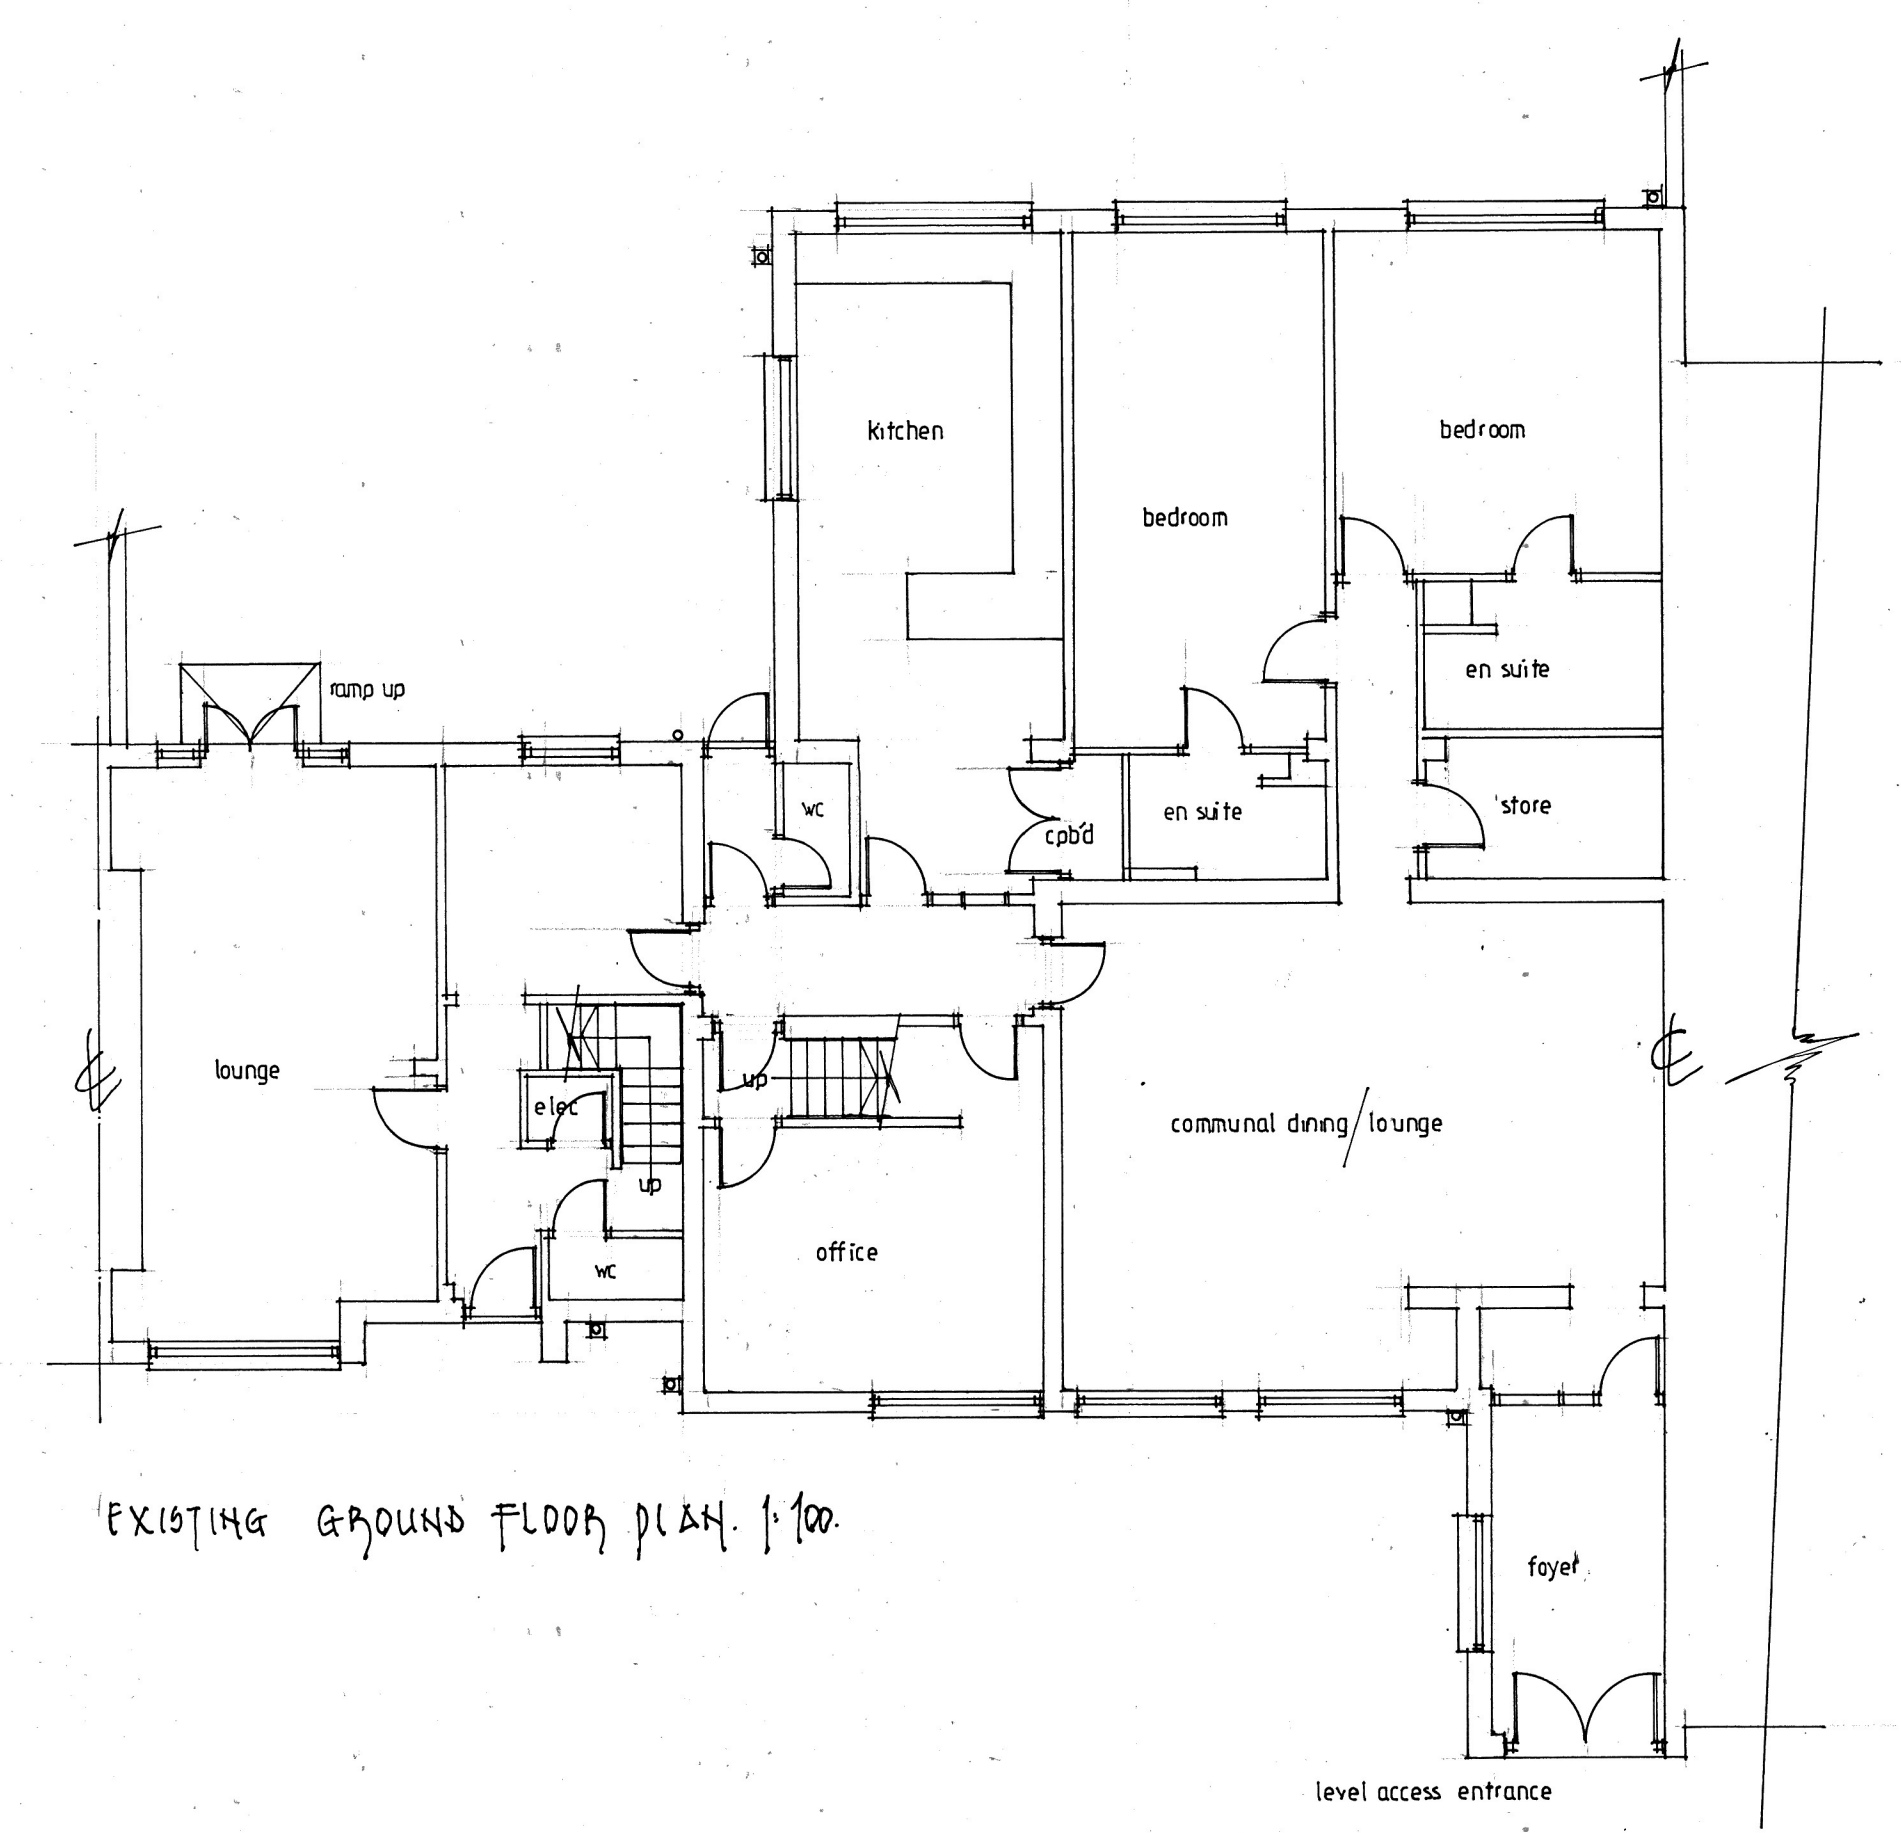


- FIRE GUIDANCE
- ILLUMINATED EXIT SIGN
 - ⊙ EMERGENCY LIGHT
 - ⊙ SMOKE DETECTOR
 - ⊙ HEAT DETECTOR
 - VP VISION PANEL
 - BREAK GLASS CALL POINT
 - WG JETTYPE WATER EXTINGUISHER
 - ⊙ PULV. POWDER FIRE EXTINGUISHER
 - fb WP FIRE BUCKET



ALL DETECTORS TO BE MOUNTED PER, ALIRED LINKED & WITH A BATTERY BACK-UP.

ALL DOORS TO ALL ROOMS, OTHER THAN W.C.'S & WET ROOMS TO BE SELF CLOSING FIRE DOORS.

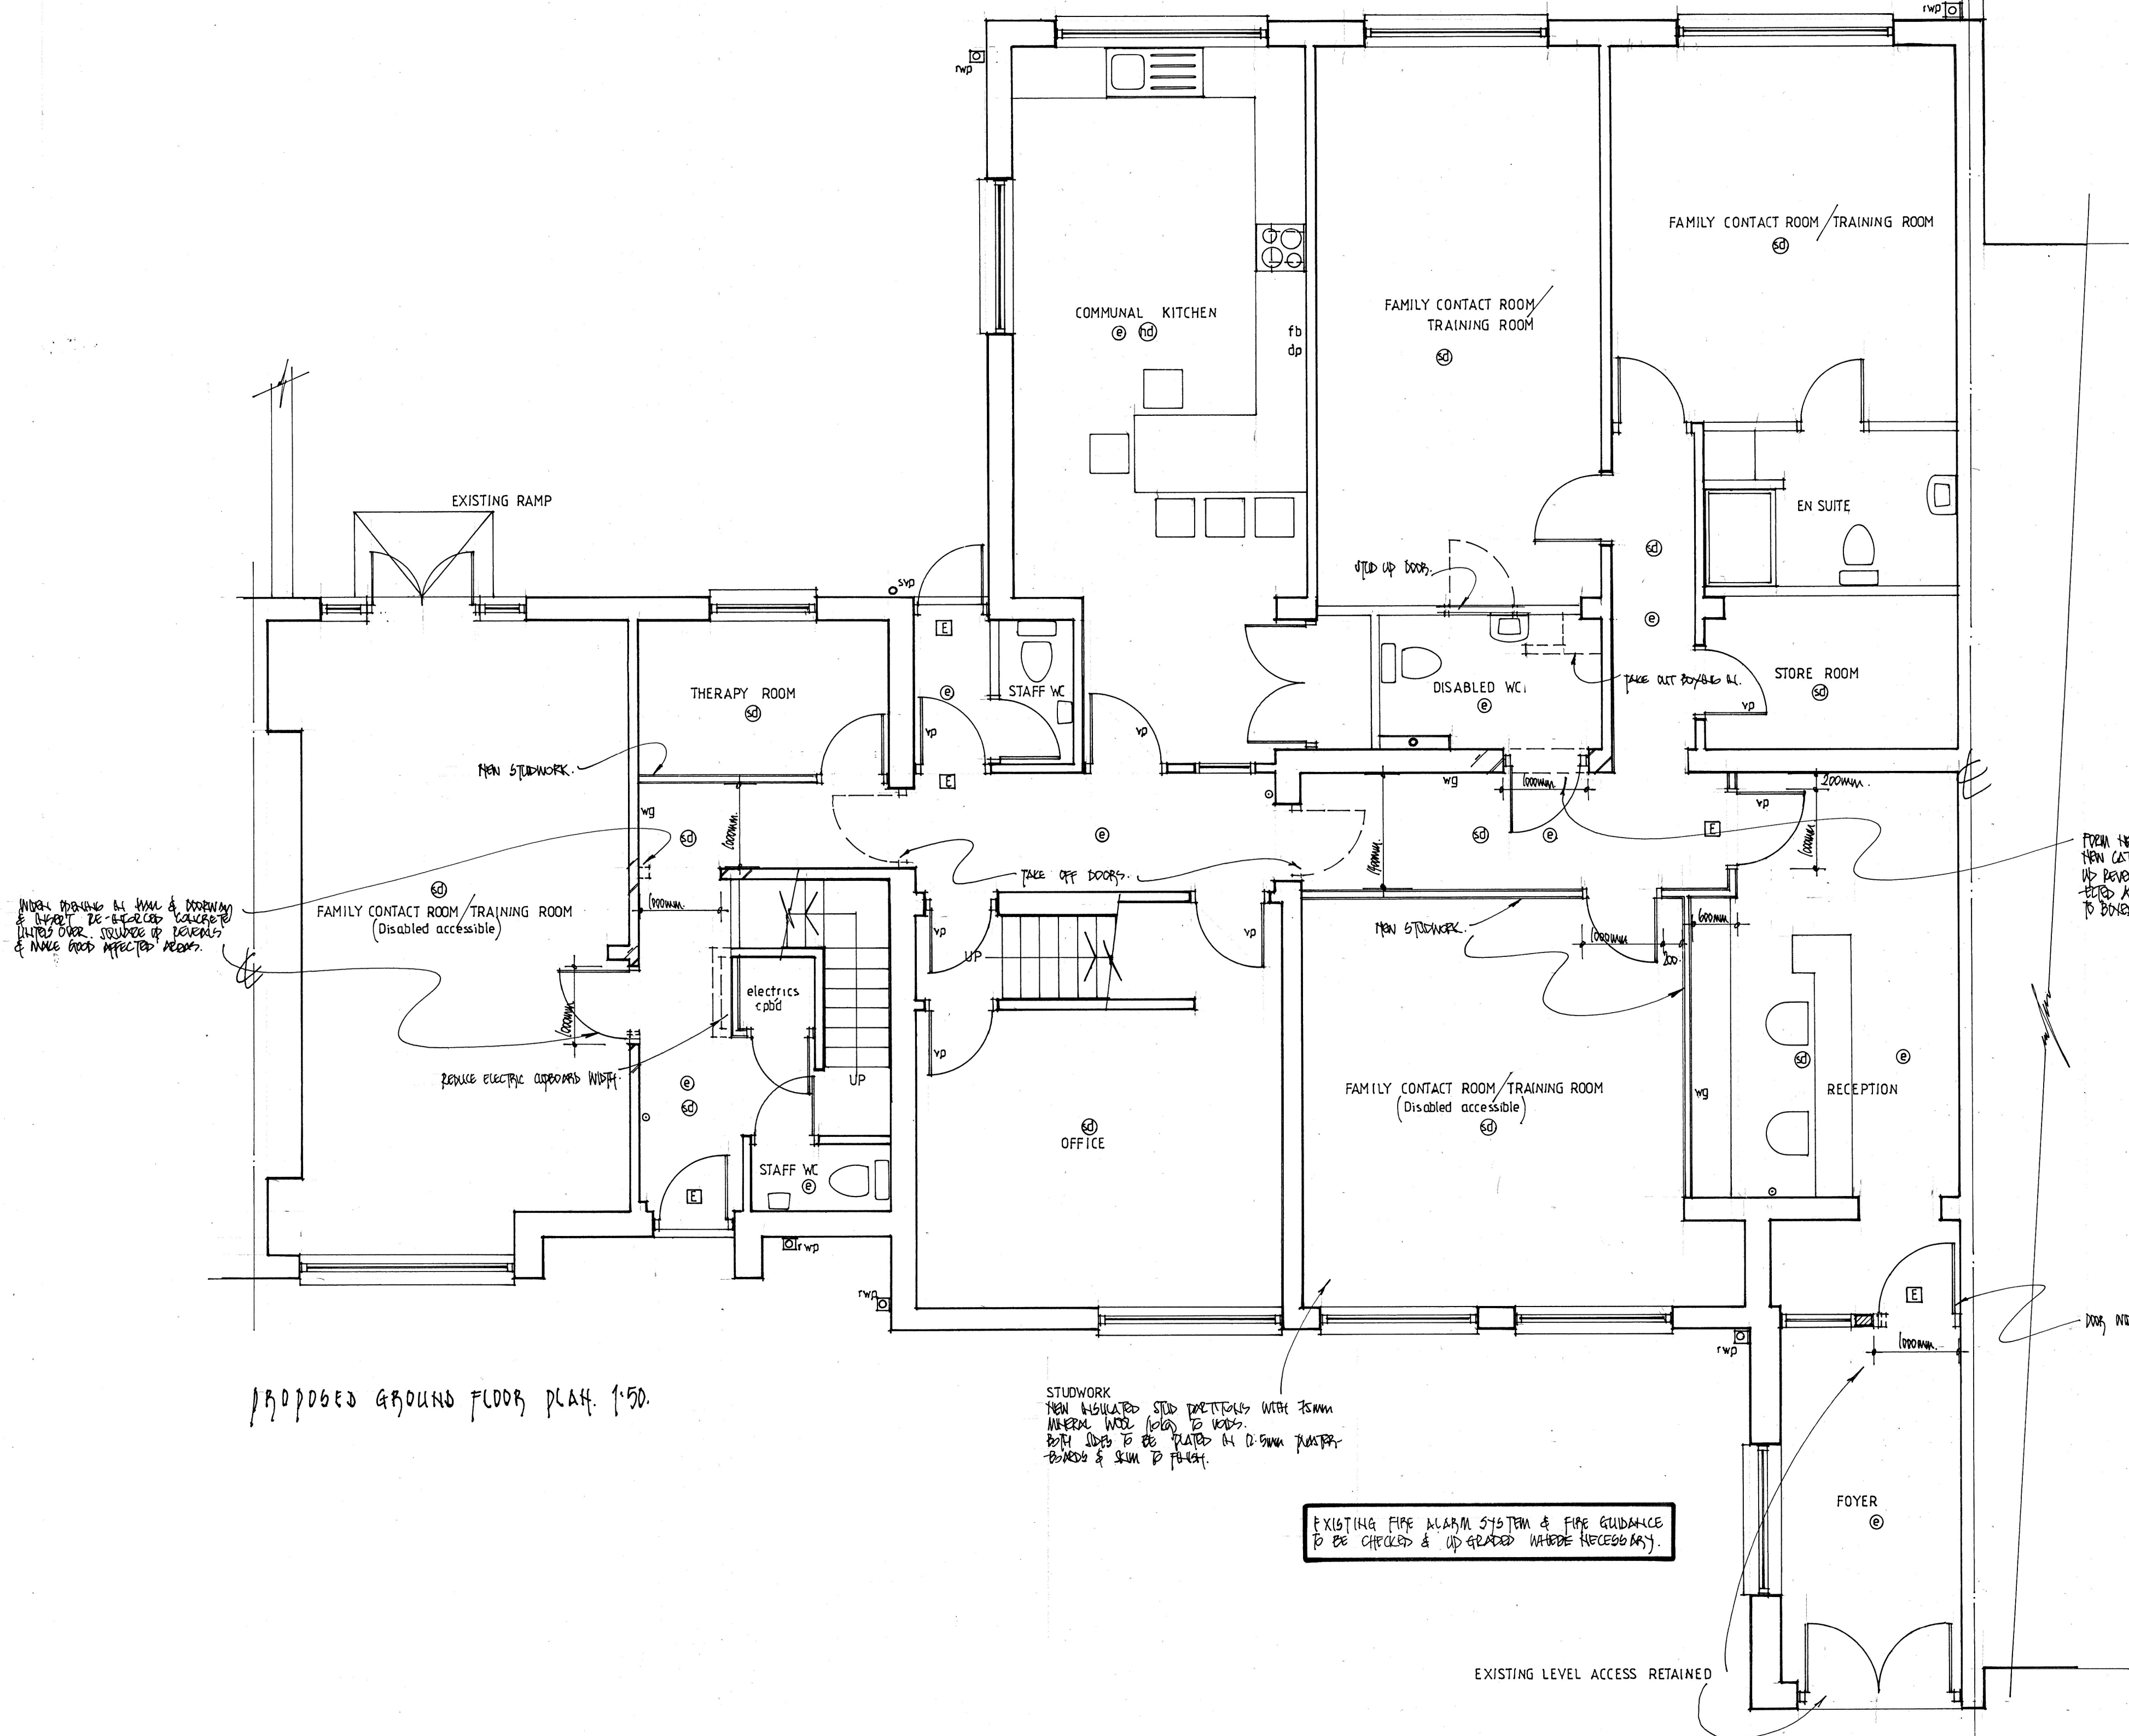

EXISTING GROUND FLOOR PLAN 1:100

THERE ARE NO EXTERNAL ALTERATIONS TO FRONT OR REAR.

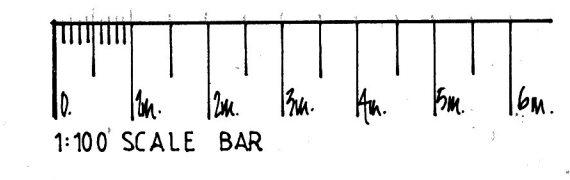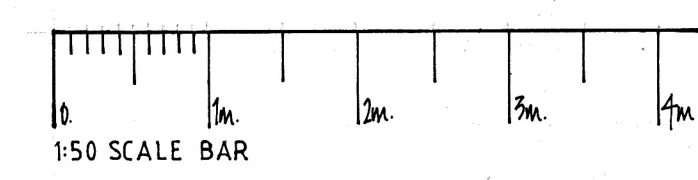

ALL DIMENSIONS TO BE CHECKED ON SITE.
ALL ELEMENTS OF STRUCTURE TO BE 311.
FIRE RESISTANCE.

AT PAPER SIZE.

REVISION	AMENDMENT	DATE
CLIENT HORIZONS OF HOPE CIC.		
DRAWING TITLE CHANGE OF USE FROM FORMER B&B TO FAMILY CONTACT CENTRE 51 TRENTHAM ROAD KIRKBY LS2 4UB.		
EXISTING & PROPOSED GROUND FLOOR PLANS.		
SCALE 1:50, 1:100.	DRAWING No. 01.	REV.
DATE MAY 2026.		