


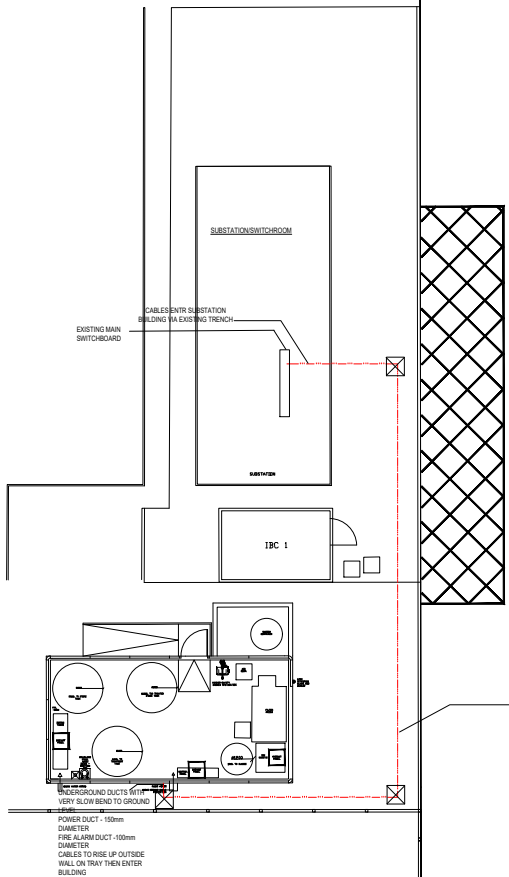
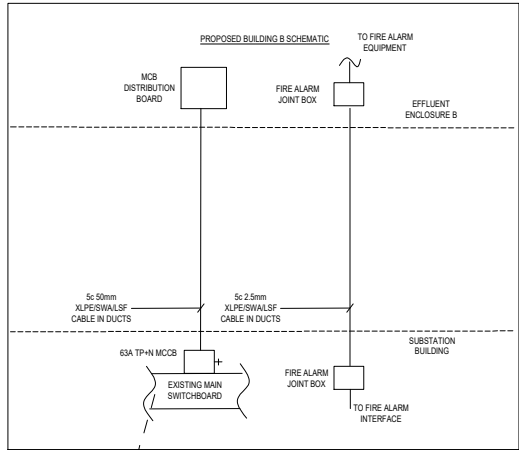


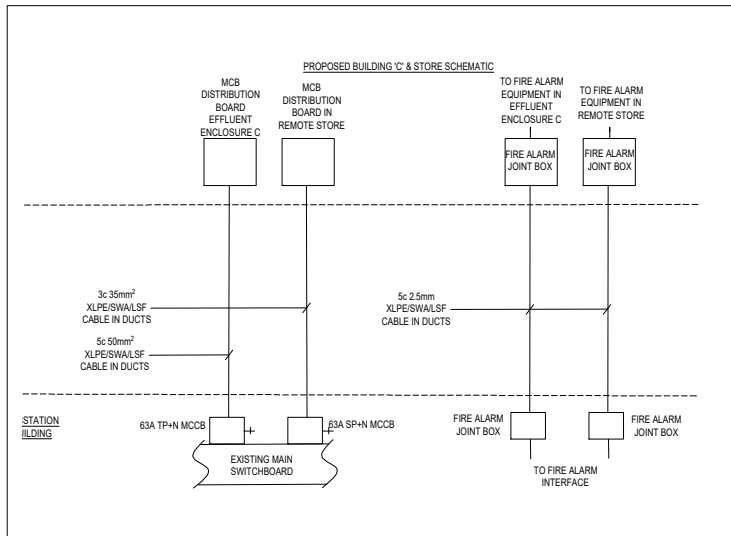

PROPOSED BUILDING B
(1:100)

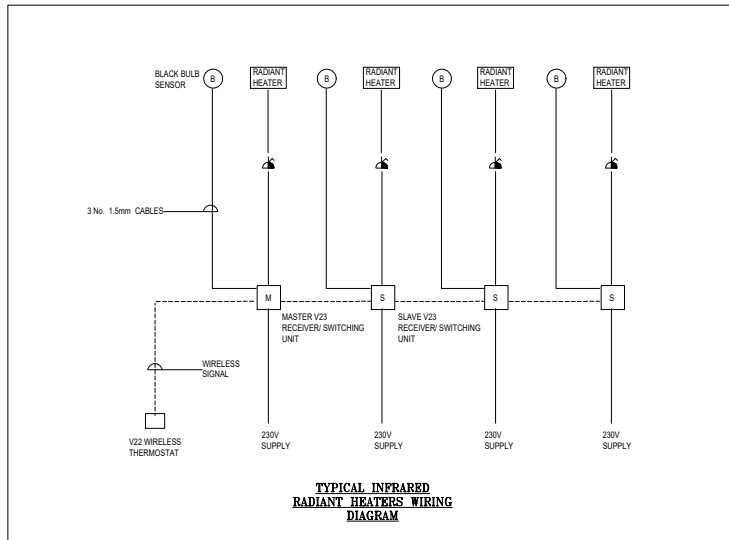

PROPOSED BUILDING C, COMPOUND AND STORE LAYOUT (1:100)

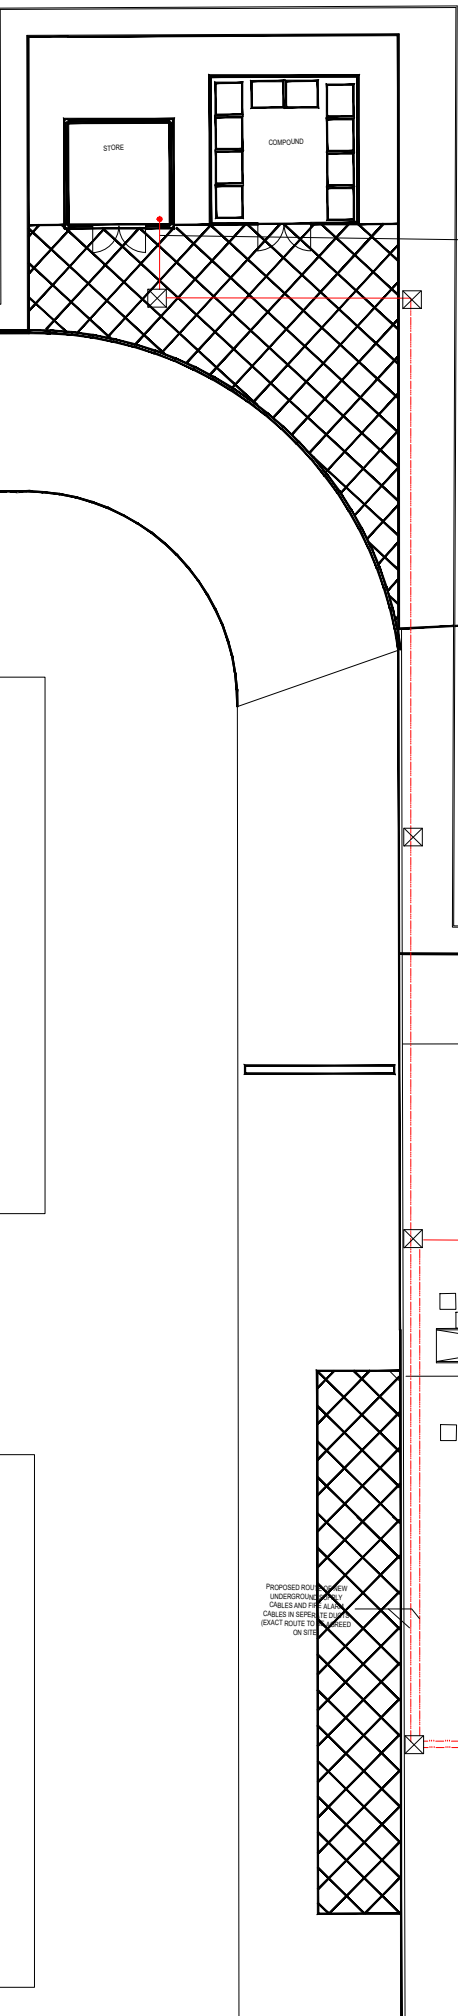

Disclaimer:
PDS Limited makes no representation or warranty, express or implied, with respect to the accuracy or reliability of the information, data or any part of it. The user agrees to use the information, data or any part of it at their own risk and without liability to PDS Limited. PDS Limited assumes no responsibility for actual or consequential damage incurred as a result of any user's reliance on this data.

LEGEND:
☒ CABLE CHAMBER

NOTE
1) ALL CABLE TO BE INSTALLED IN DUCTS
2) CONTRACTOR TO ALLOW FOR INSTALLING NEW MCCB UNITS TO MATCH EXISTING IN EXISTING MAIN SWITCHBOARDS

C2 SHMO OMITTED FROM BUILDINGS B AND C 22.09.25
C3 CONTRACT ISSUE 15.09.25

Rev. Description Date
1. Progressive Services Design Ltd
2. Building Services Consultancy

Client:
Alfred H Knight

Project:
JKL Waste Treatment Project

Drawn: P.O. Checked: S.P.O.
Scale: 1:100(A0) Date: MAY 25

Title:
Proposed Site Plan Layout

Drawing Number: 2273-E-61-00-01 Rev. C2