



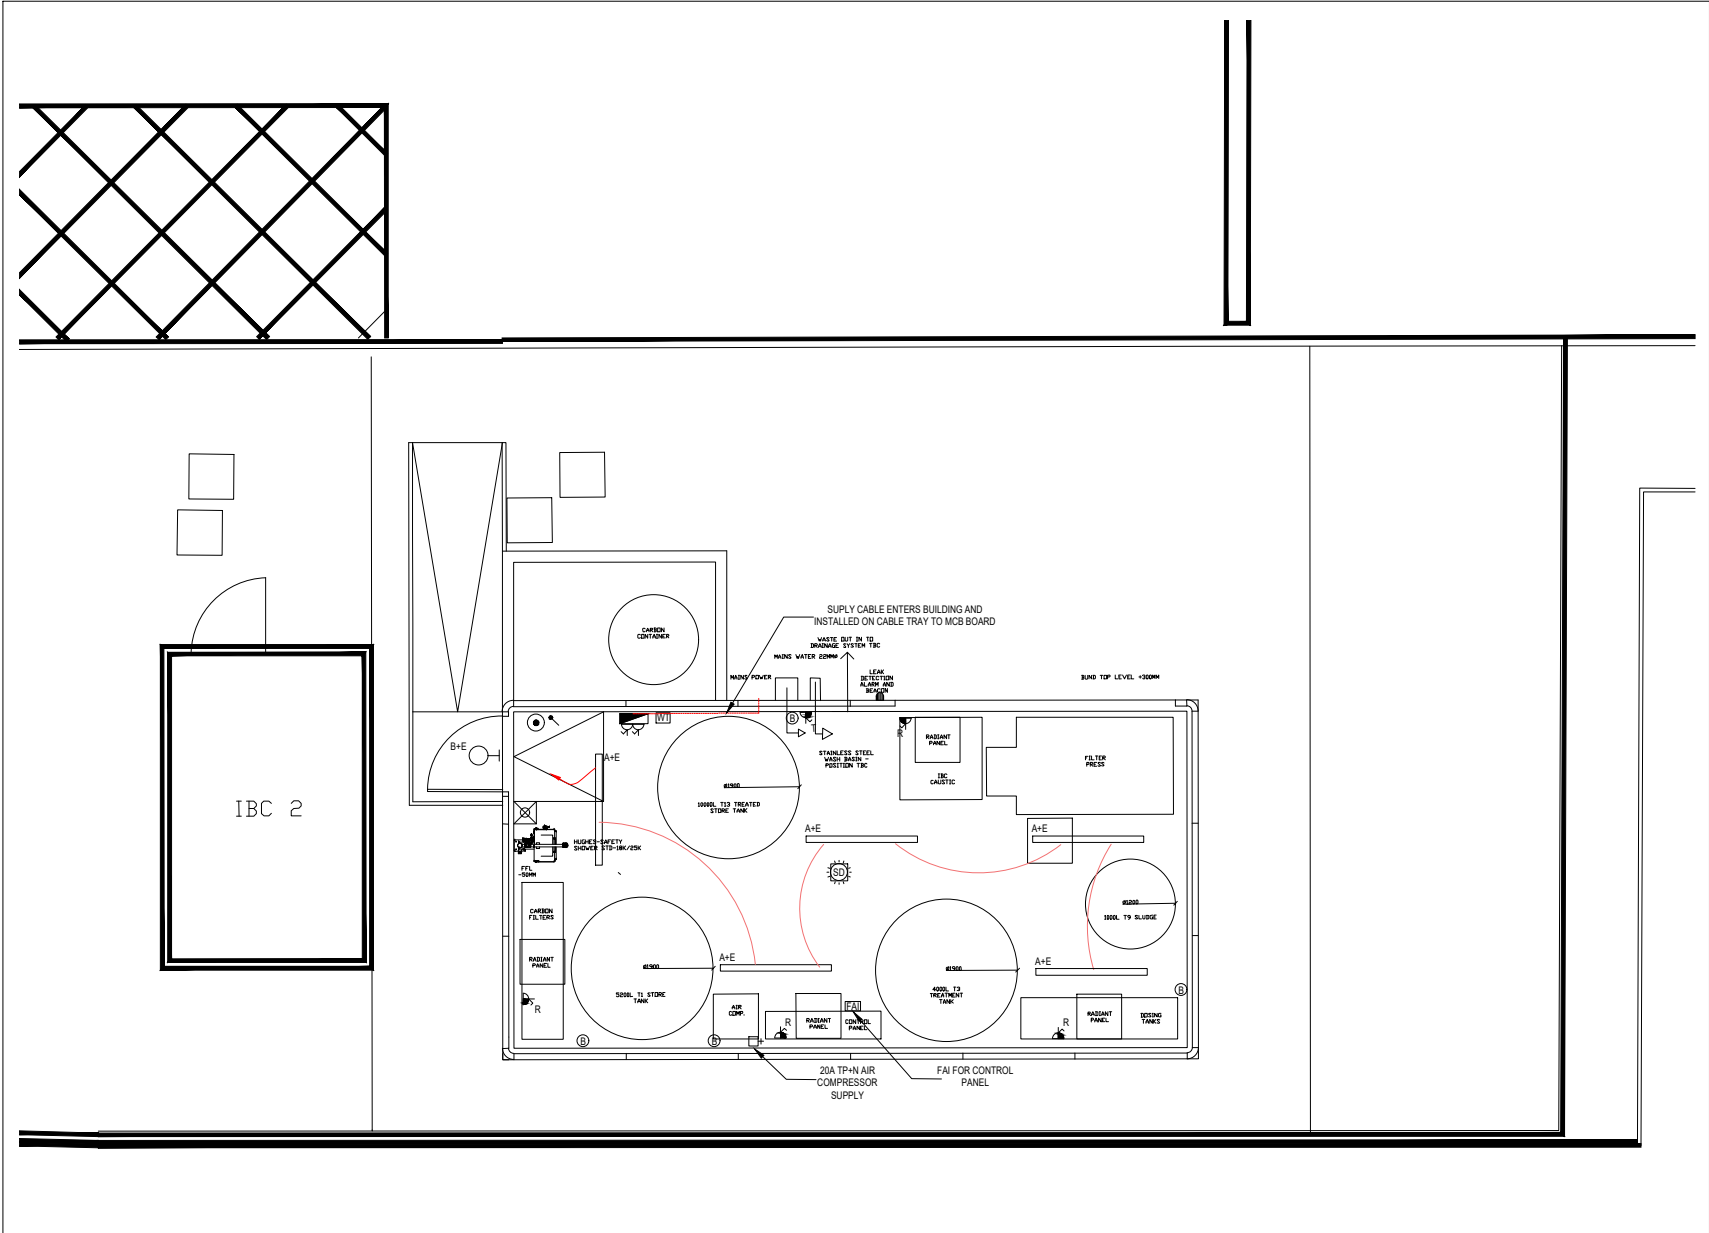

PROPOSED BUILDING C
(1:50)

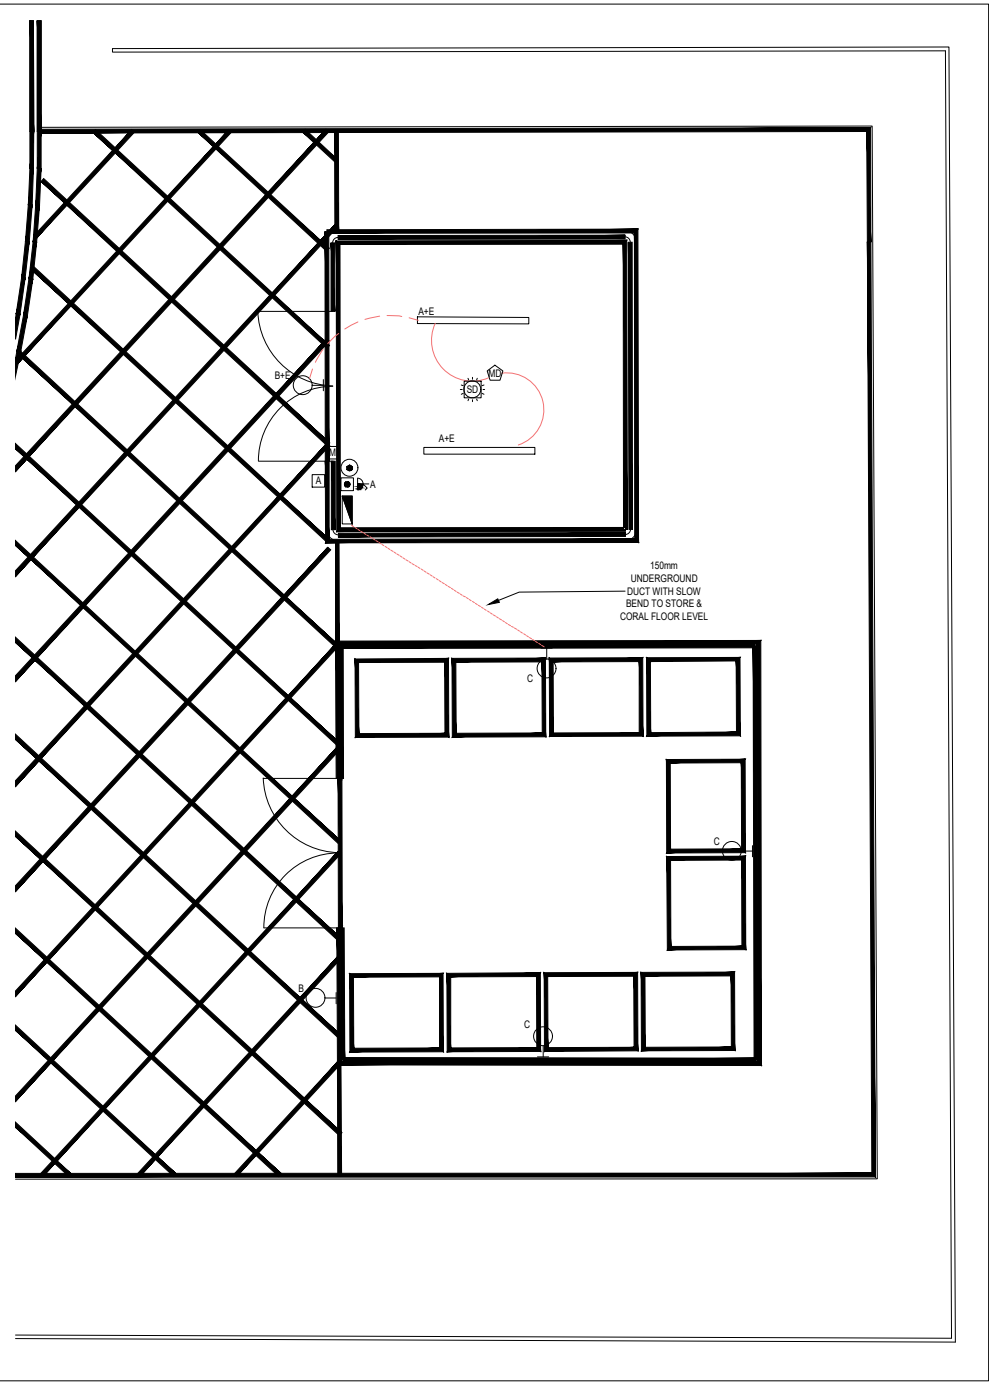

PROPOSED COMPOUND
AND STORE (1:50)

Disclaimer:
PSD Limited makes no representation or warranties, express or implied, with respect to the re-use of data provided hereafter, regardless of its format or the means of its transmission. There is no guarantee or representation to the user as to the accuracy, currency, suitability or reliability of this data for any purpose. The user accepts that data "as is", and assumes all risks associated with its use. By acceptance of this data, the user agrees not to transmit this data or provide access or any part of it to another party unless the user shall include with the data a copy of this disclaimer. PSD Limited assumes no responsibility for actual or consequential damage incurred as a result of any user's reliance on this data.

LEGEND:

SWITCHED 13A FUSED SPUR

TRACE HEATING SUPPLY

TWIN SWITCHED SOCKET OUTLET

ACCESS CONTROL SUPPLY

RADIANT HEATER SUPPLY

ISOLATOR

DISTRIBUTION BOARD/PANEL

MANUAL CALL POINT/BREAK GLASS

DISTRIBUTION BOARD/PANEL

ONE WAY LIGHT SWITCH

SMOKE DETECTOR WITH SOUNDER BEACON

LED WALL MOUNTED LIGHT FITTING

LED LINEAR LIGHT FITTING

WIRELESS THERMOSTAT

BLACK BULB SENSOR

ACCESS CONTROL

GREEN RELEASE PROXIMITY BUTTON

MAG LOCK OR LATCH LOCK

NOTE:

1)

LIGHT FITTING A TO BE SUSPENDED ON CONDUIT DROPS EXACT HEIGHT AND LOCATION TBC ONSITE.

2)

ELECTRICAL ACCESSORIES TO BE MK WATER SEAL PLUS IP66

3)

EXACT LOCATION OF BLACK BULB SENSORS TBC ON SITE

4)

CORAL LIGHTING SUPPLY TO BE VIA MULTICORE SWA CABLE THEN GALVANISED CONDUIT AND LSZH SINGLE IN CONDUIT IN CORAL

C2	SINK & WATER HEATER DELETED AND ACCESS CONTROL ADDED TO STORE	22.09.25
C1	CONTRACT ISSUE	15.09.25
Rev.	Description	Date

PS

PROGRESSIVE SERVICES DESIGN LTD

21 Angyle Street
Barnstaple
Wend
Cred 11AD
Tel: 0151 647 0857
Fax: 0151 647 0858
E-mail: info@psdtd.co.uk

BUILDING SERVICES CONSULTANCY

Client:

Alfred H Knight

Project:

JKL Waste Treatment Project

Drawn: P.O.

Checked: S.P.O.

Scale: 1:50(A1)

Date: MAY 25

Title:

Proposed Building C Power,
Lighting and Emergency
Lighting Layout

Drawing Number:

2273-E-63-00-02

Rev:

C2