




PLANNING DRAWING

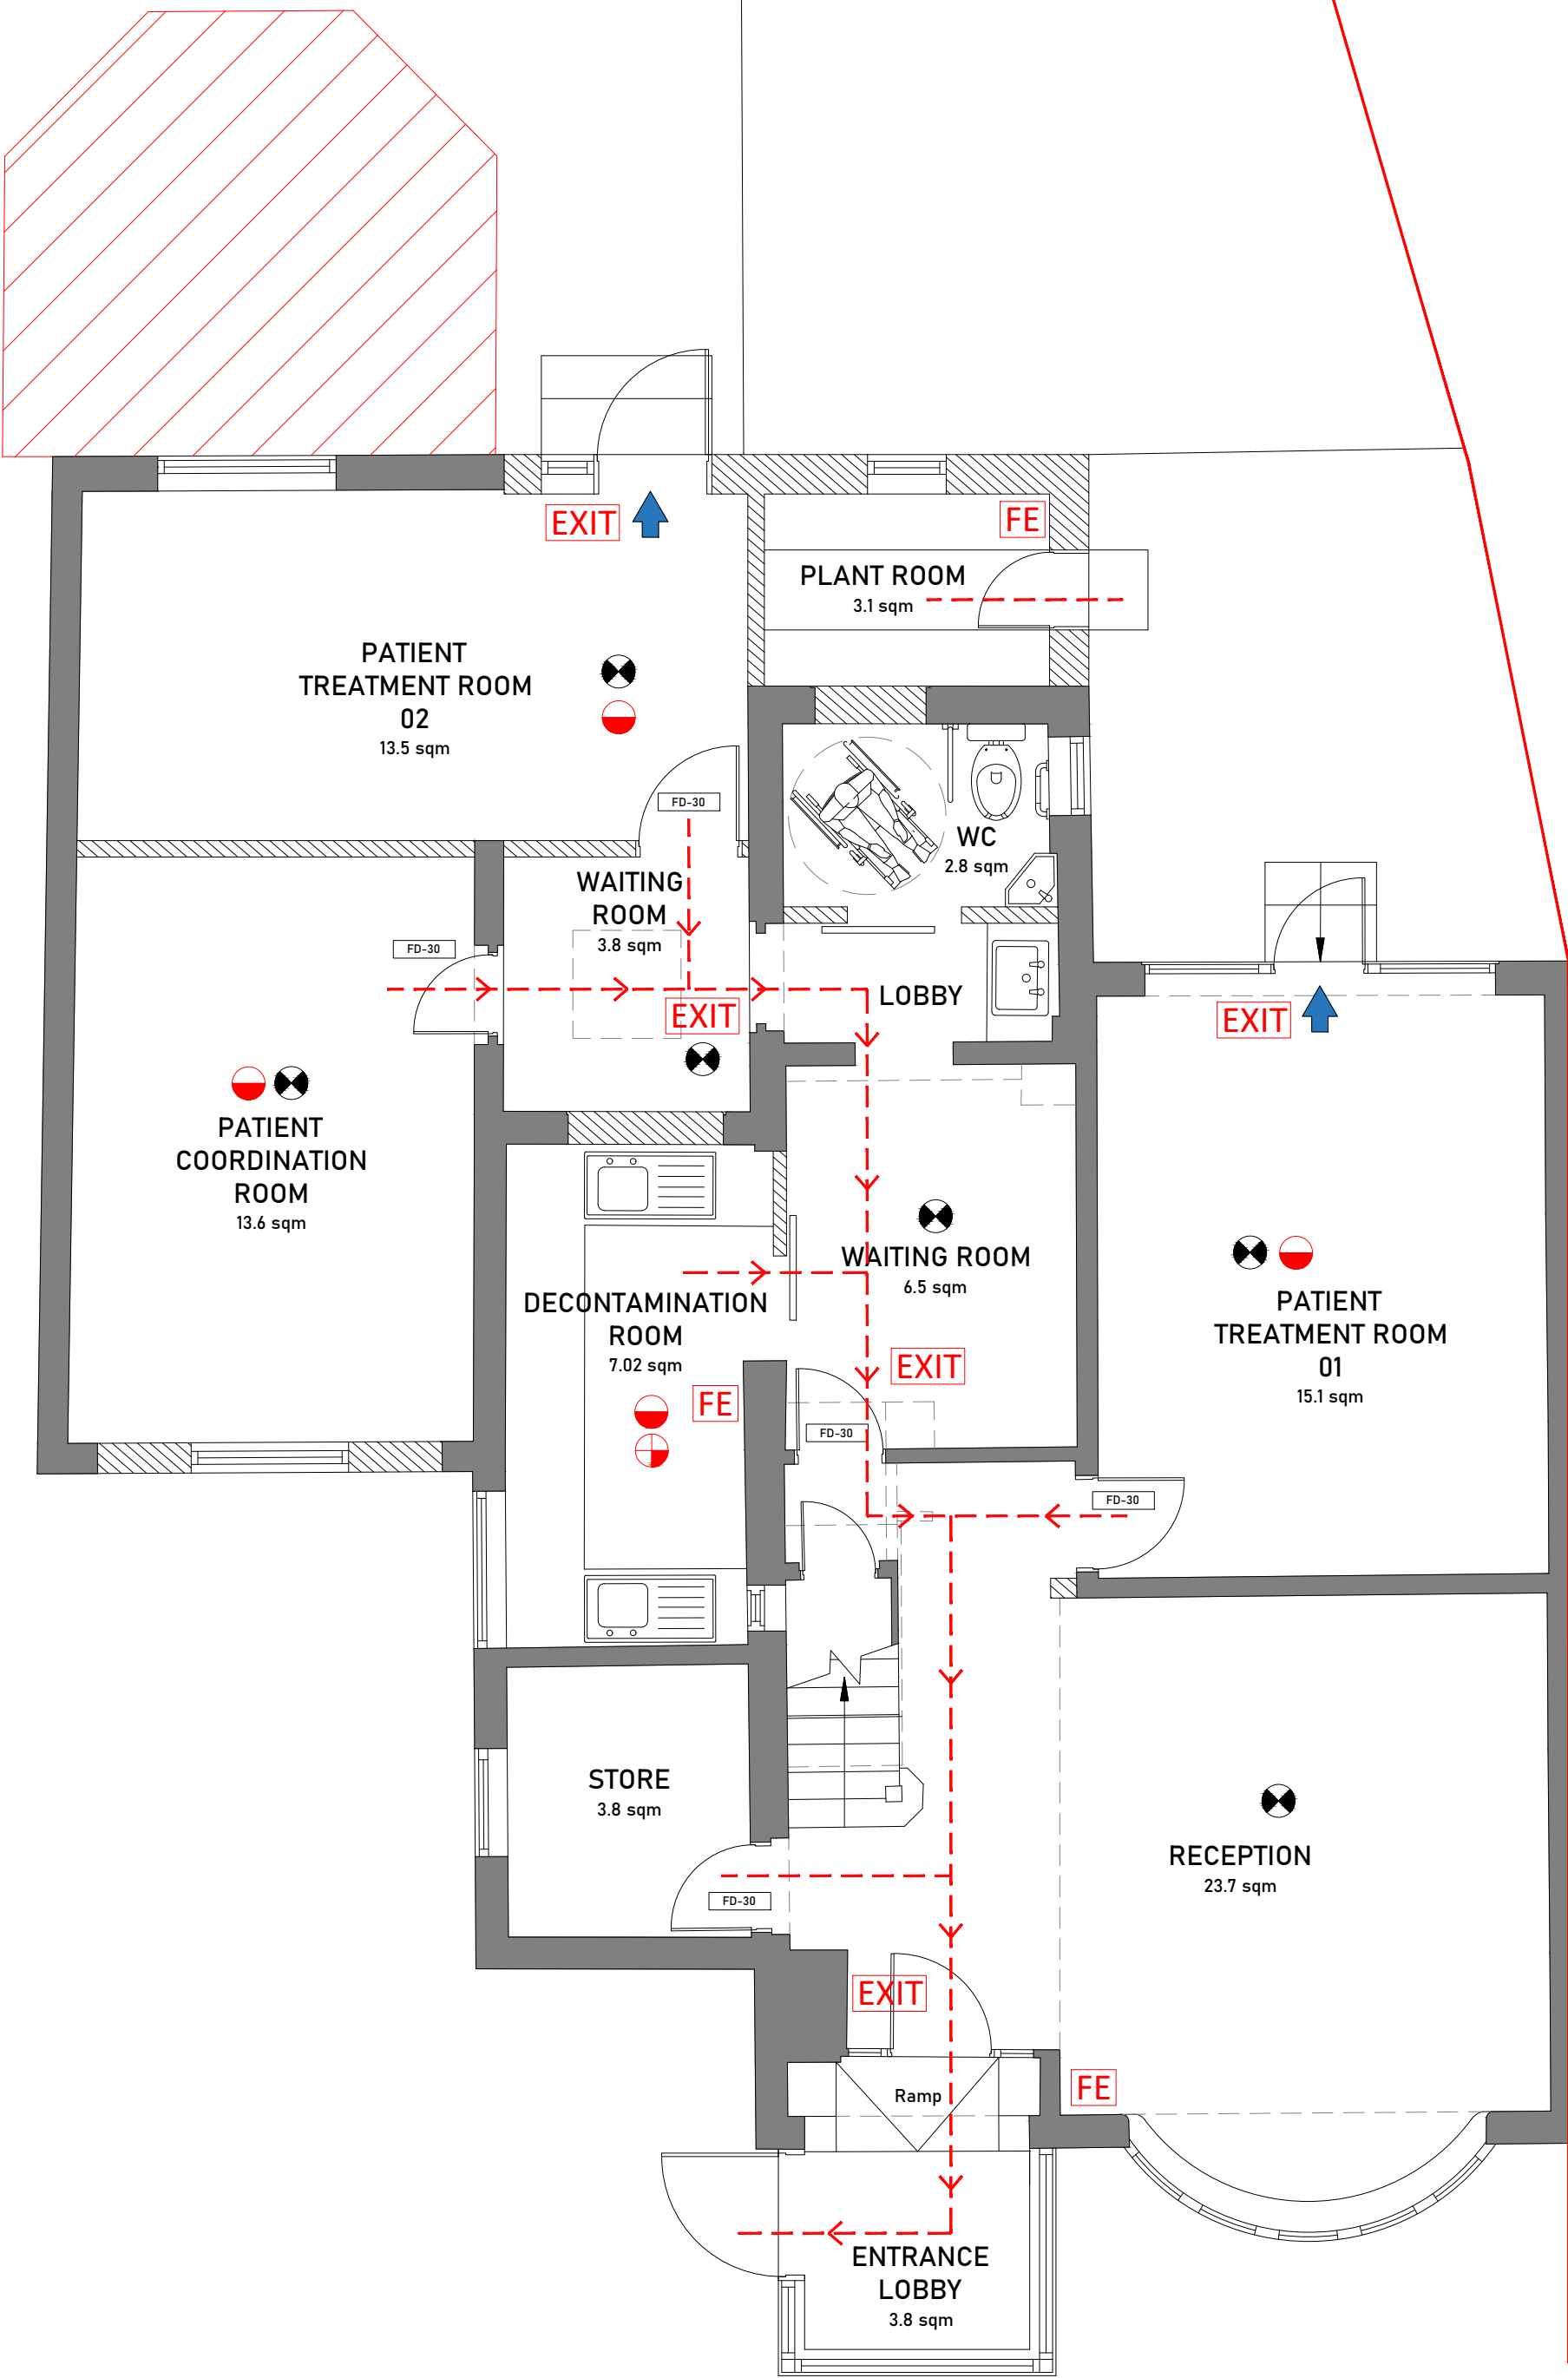

GROUND FLOOR PLAN
1:50

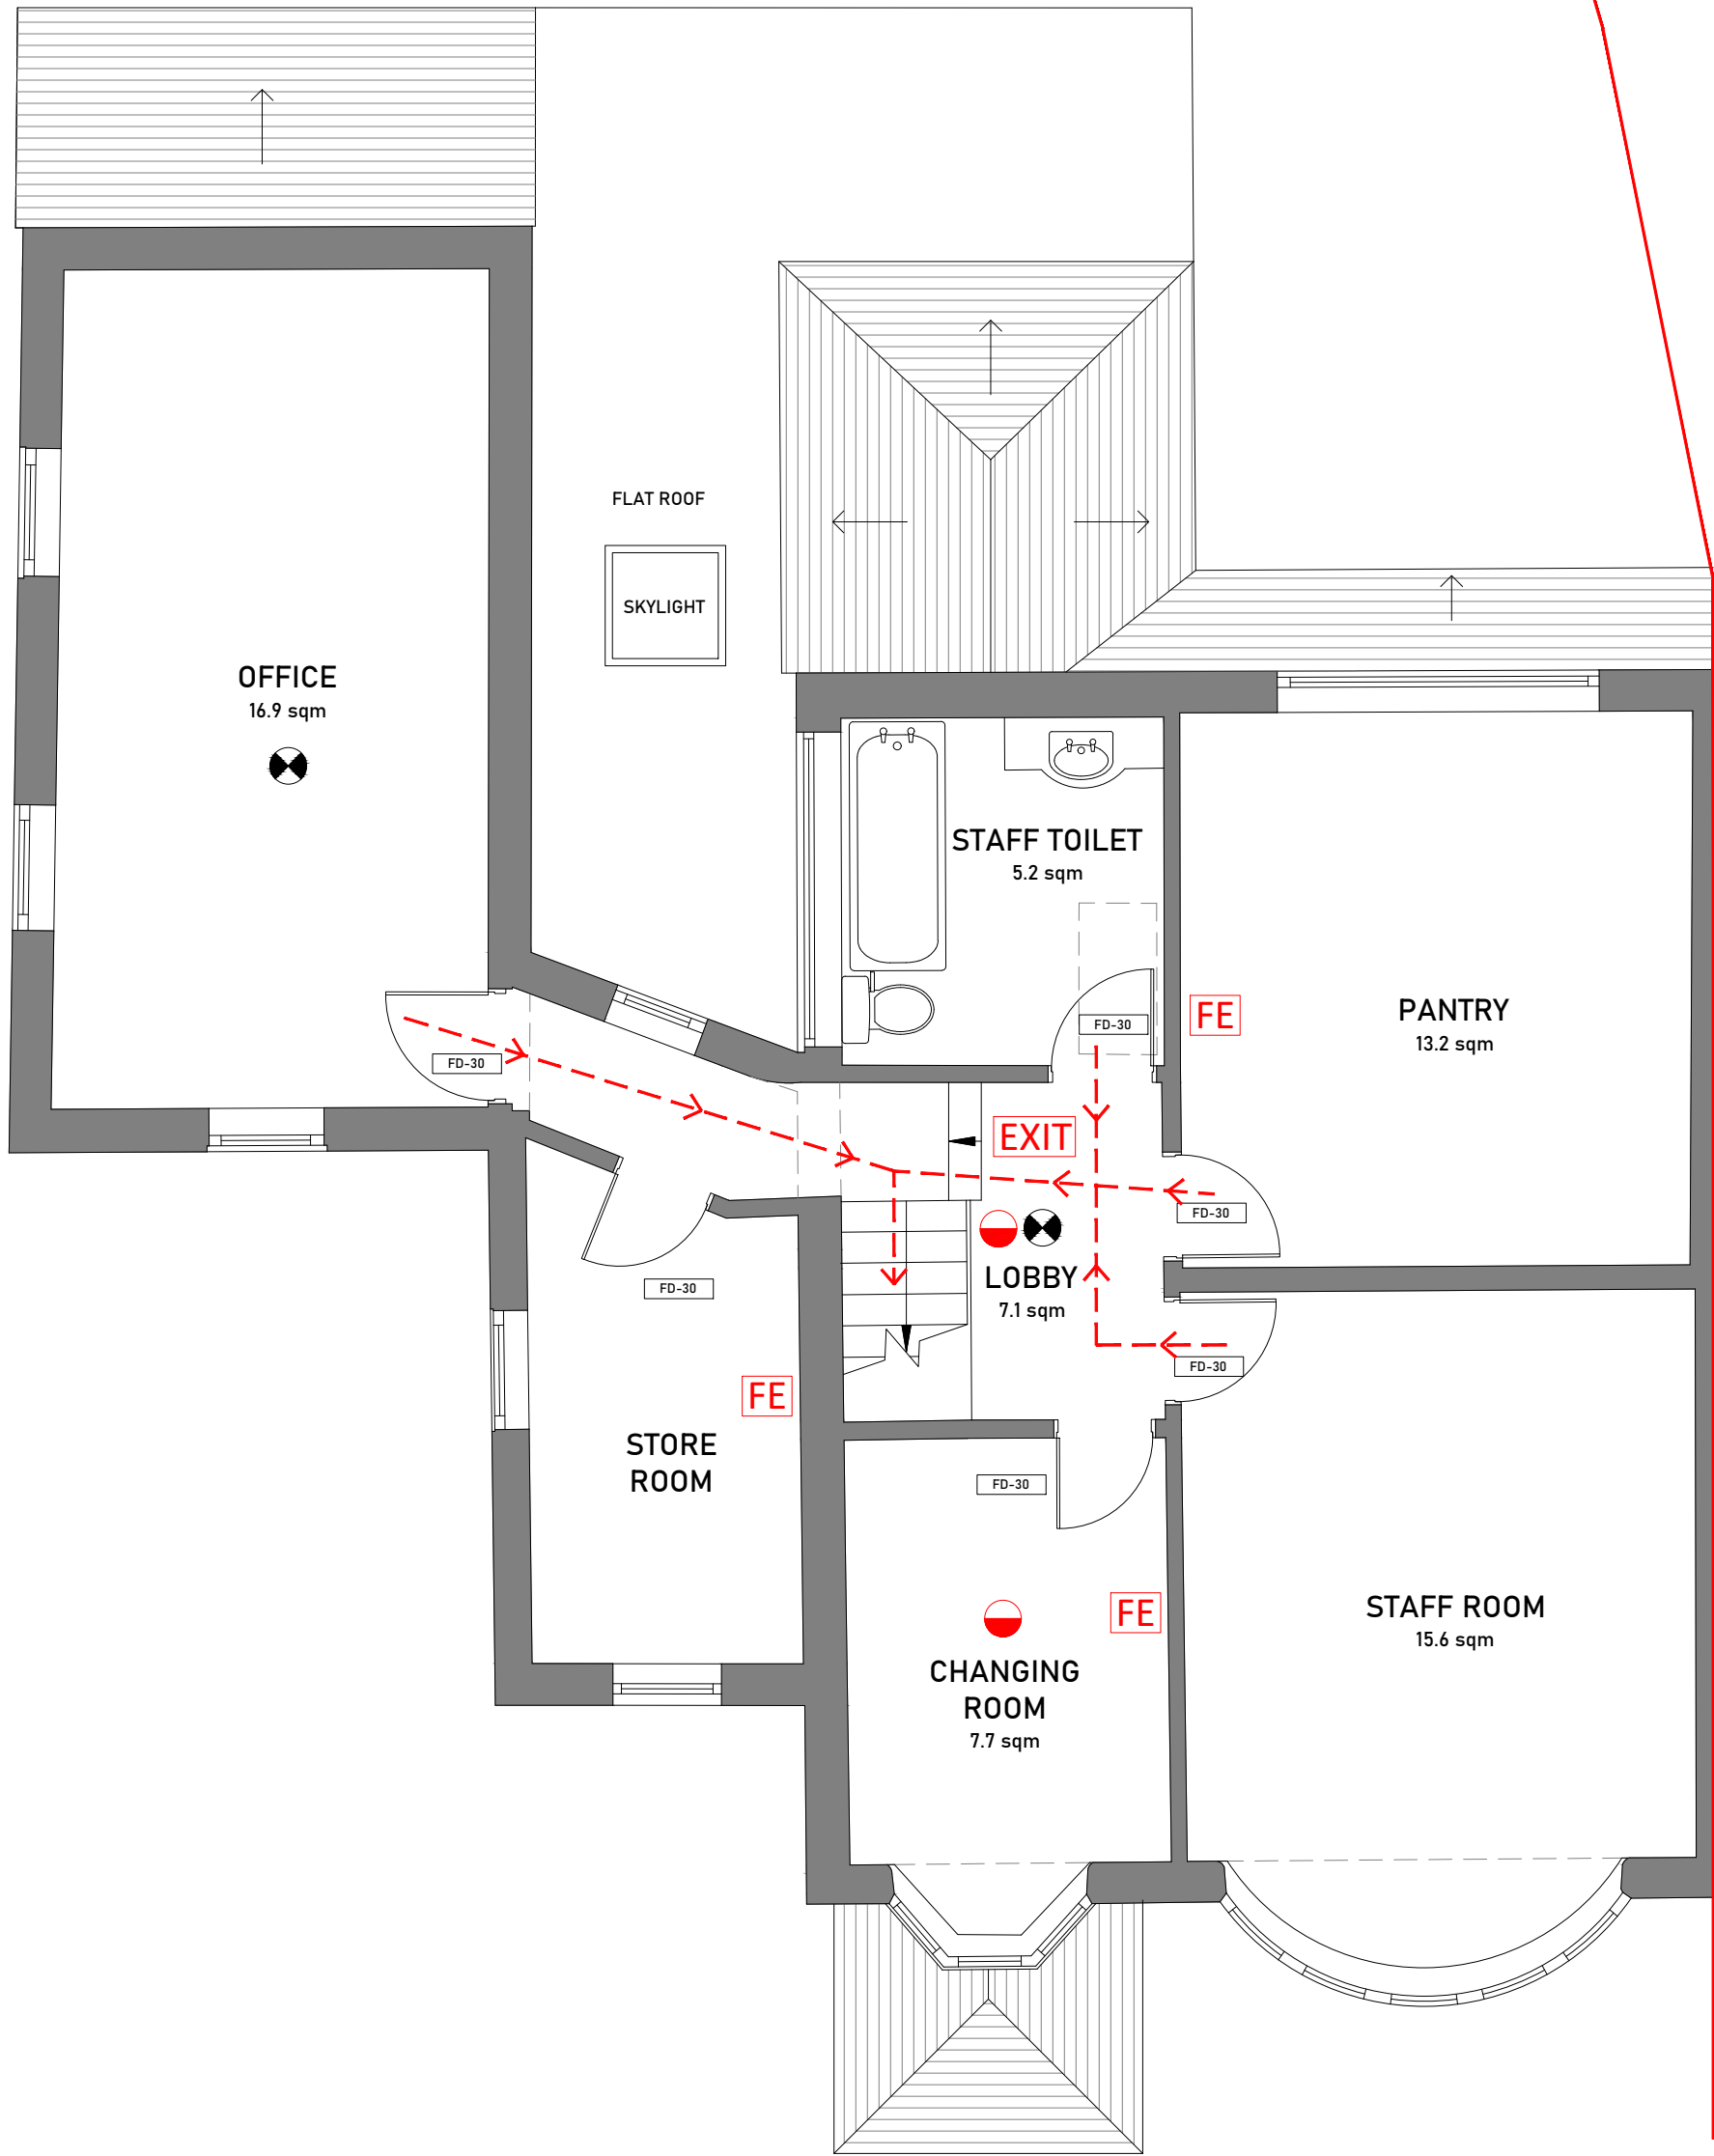

FIRST FLOOR PLAN
1:50

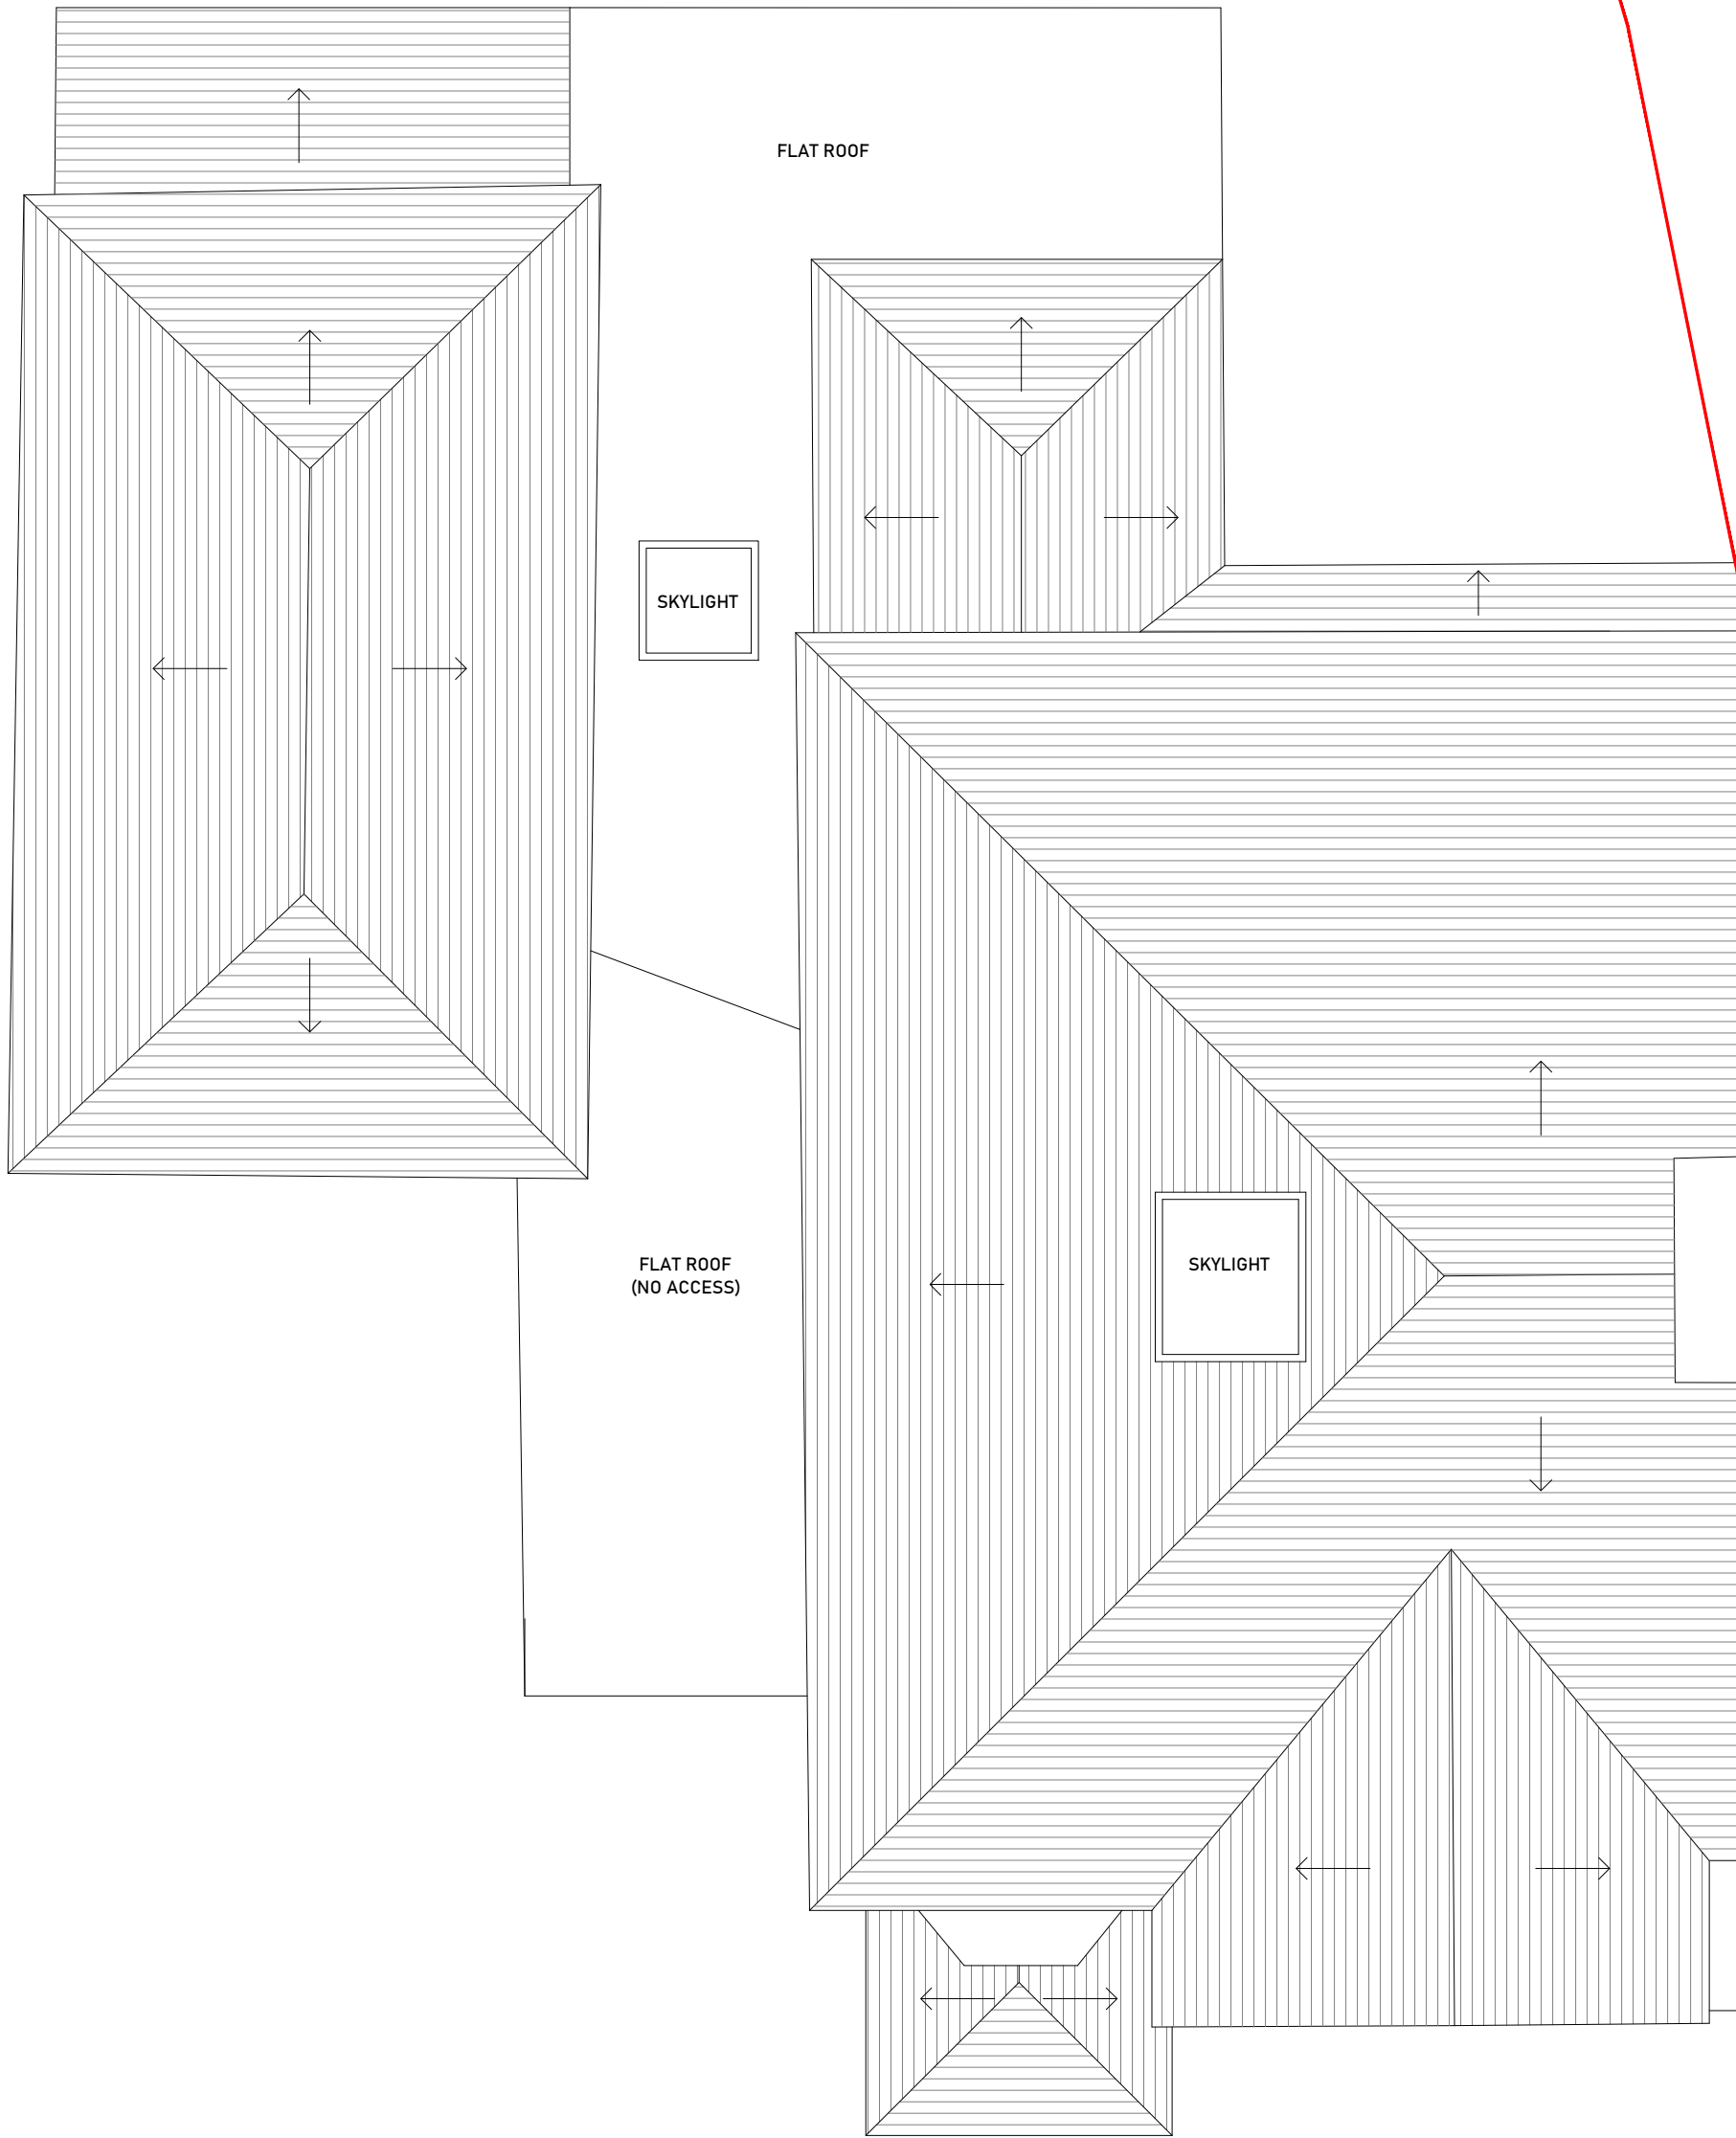

ROOF PLAN
1:50

LEGEND

- Heat detector and integrated sounder
- Smoke detector and integrated sounder
- FE Fire Extinguisher
- Fire escape route
- Alternative Fire Exit
- Emergency Light
- EXIT Fire exit signage
- FD-30 Fire door

NOTE TO BE ADDED:
Primary escape route via front entrance final exit.
Secondary escape routes provided via rear/side exits.
Escape routes to be maintained clear and unobstructed at all times.
FD30 doors required to protected escape routes, stair and lobby areas.
Fire alarm, emergency lighting and signage to be installed in accordance with the approved fire strategy during Building Regulation Stage.
Fire extinguishers shown are indicative and to be in accordance with BS 5306.
Occupants to proceed to the designated assembly point upon evacuation.
Final fire strategy, compartmentation and door ratings to be further confirmed at Building Regulations stage.

CLIENT	Bilal Khalid
ADDRESS	36 Archway Rd, Liverpool L36 9XE, UK
TITLE	PROPOSED FIRE EVACUATION LAYOUT
PROJECT STATUS	PLANNING DRAWING
DATE	JULY 2026
REVISION	
SCALE	As Indicate @A1
SHEET No.	BD007
REFERENCE	0010/20/FA
DRAWN BY	

