



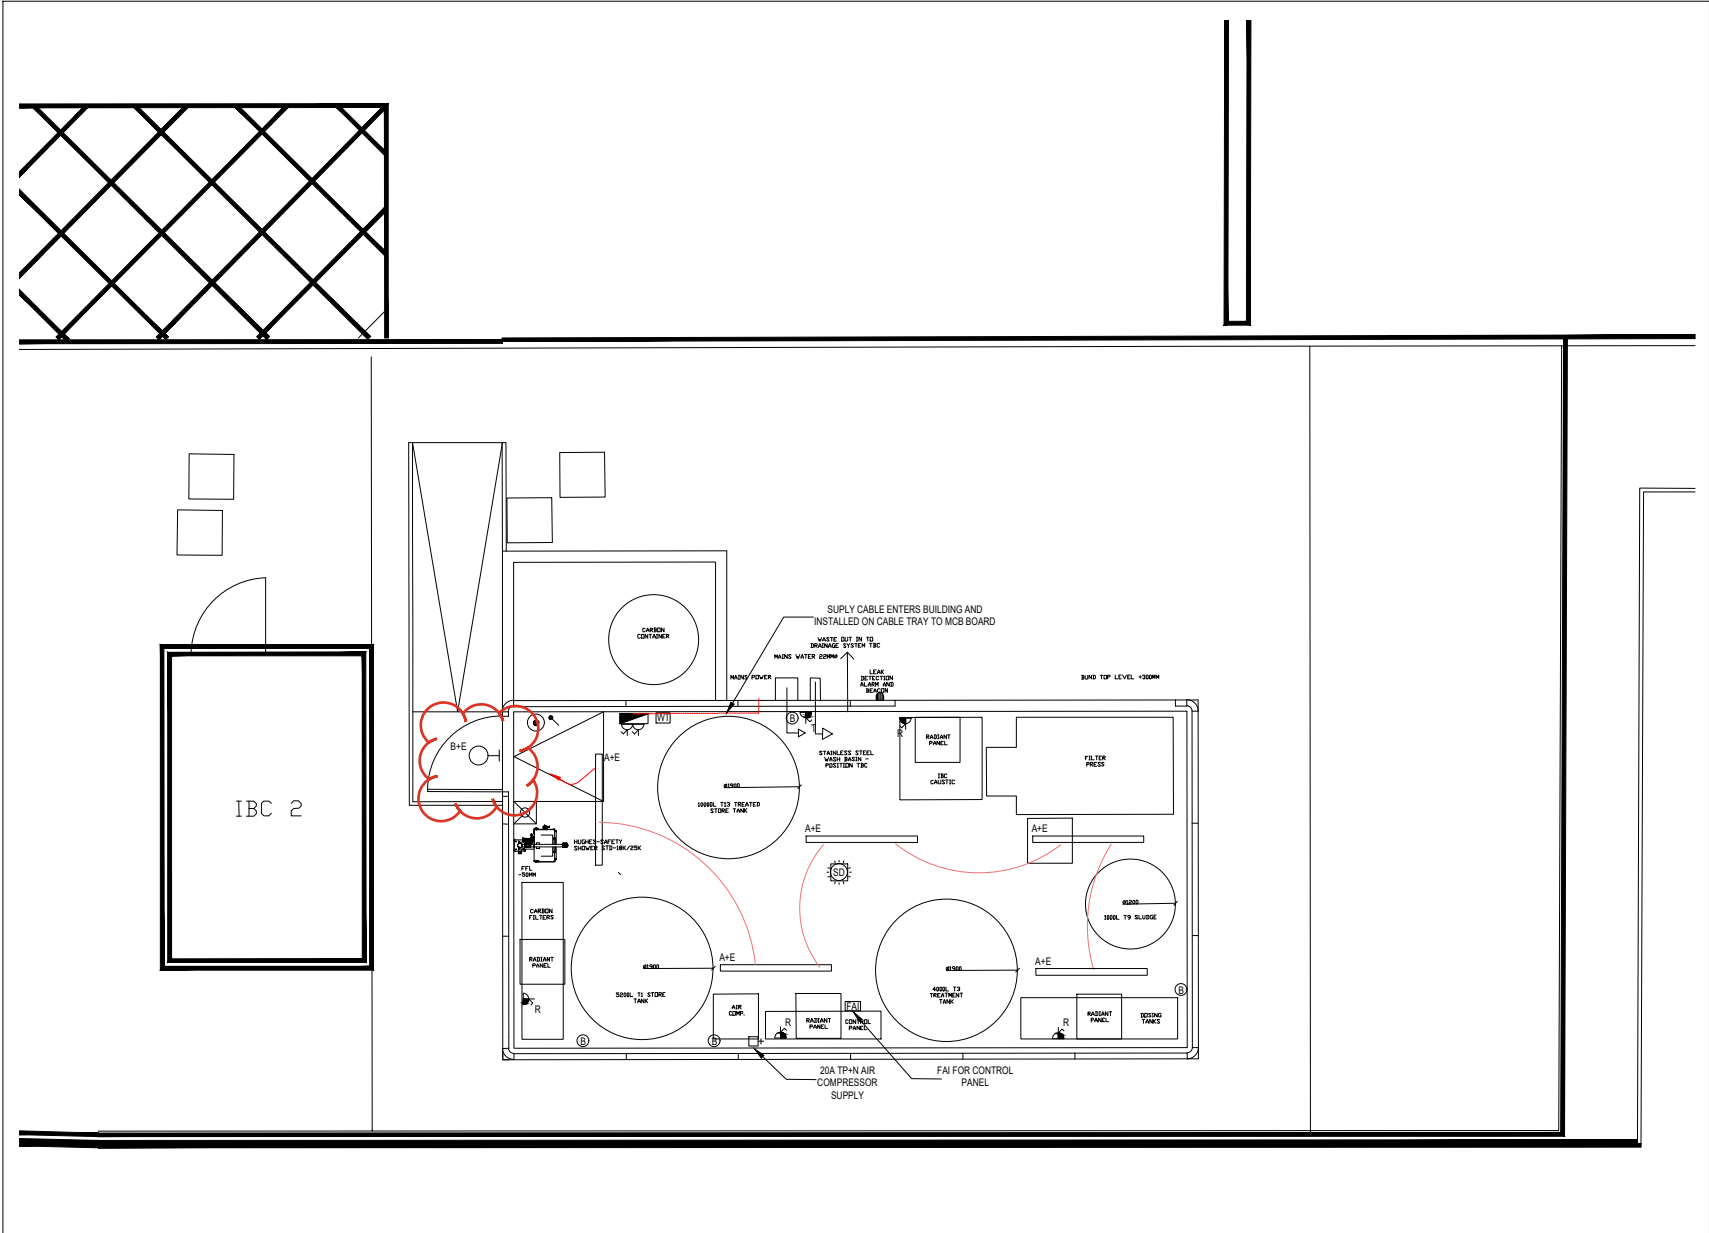

PROPOSED BUILDING C
(1:50)

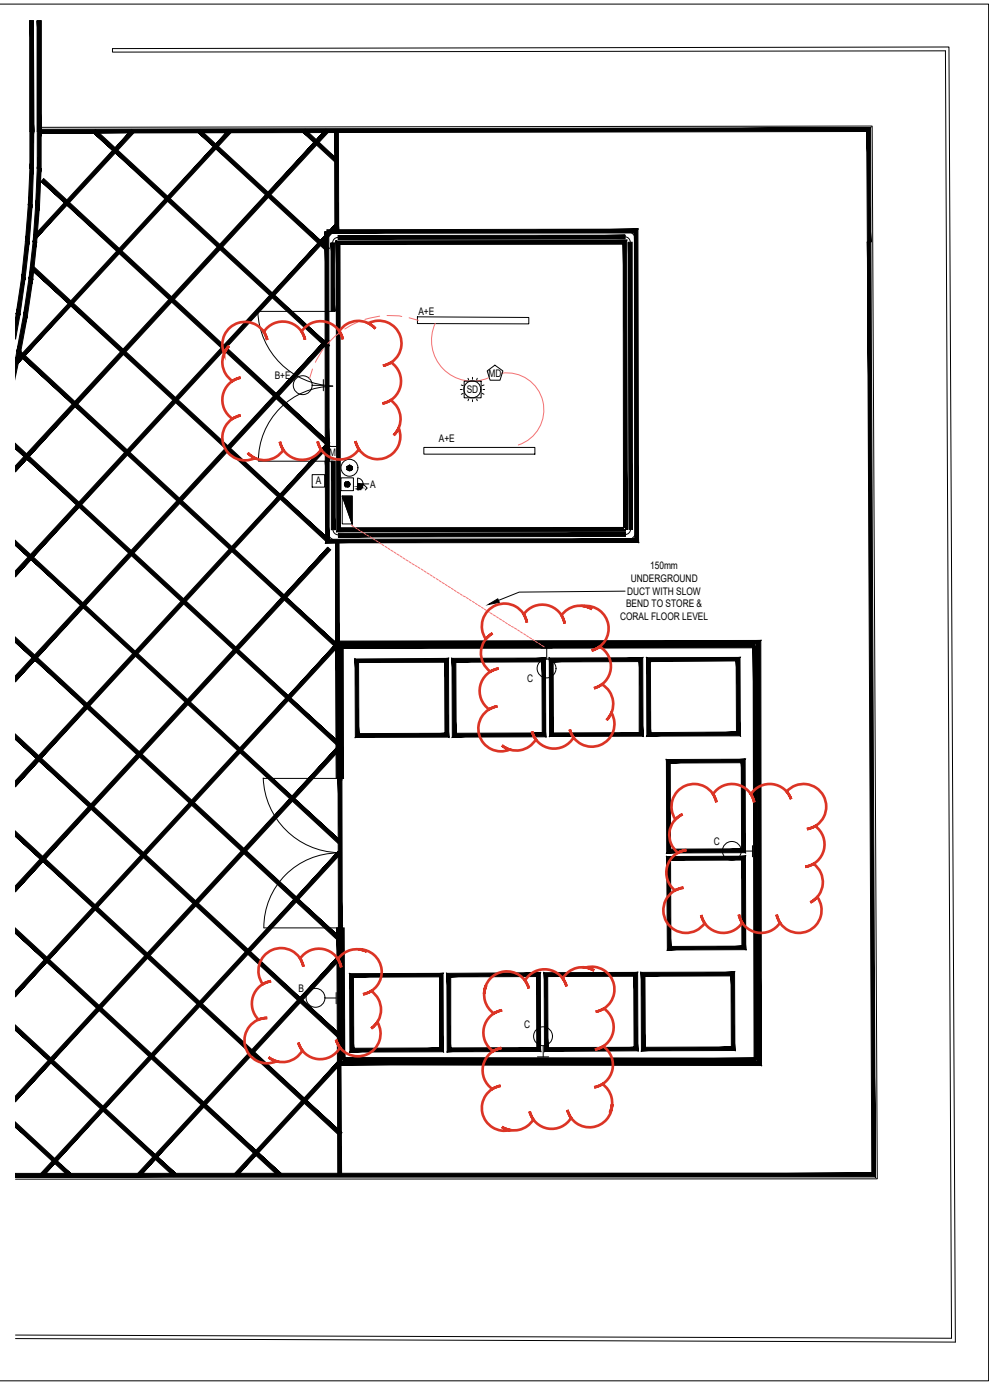

PROPOSED COMPOUND
AND STORE (1:50)

Disclaimer:
PSD Limited makes no representation or warranties, express or implied, with respect to the re-use of data provided hereafter, regardless of its format or the means of its transmission. There is no guarantee or representation to the user as to the accuracy, currency, suitability or reliability of this data for any purpose. The user accepts that data "as is", and assumes all risks associated with its use. By acceptance of this data, the user agrees not to transmit this data or provide access or any part of it to another party unless the user shall include with the data a copy of this disclaimer. PSD Limited assumes no responsibility for actual or consequential damage incurred as a result of any user's reliance on this data.

LEGEND:

- SWITCHED 13A FUSED SPUR
- TRACE HEATING SUPPLY
- TWIN SWITCHED SOCKET OUTLET
- ACCESS CONTROL SUPPLY
- RADIANT HEATER SUPPLY
- ISOLATOR
- DISTRIBUTION BOARD/PANEL
- MANUAL CALL POINT/BREAK GLASS
- DISTRIBUTION BOARD/PANEL
- ONE WAY LIGHT SWITCH
- SMOKE DETECTOR WITH SOUNDER BEACON
- LED WALL MOUNTED LIGHT FITTING
- LED LINEAR LIGHT FITTING
- WIRELESS THERMOSTAT
- BLACK BULB SENSOR
- ACCESS CONTROL
- GREEN RELEASE PROXIMITY BUTTON
- MAG LOCK OR LATCH LOCK

NOTE:

- 1) LIGHT FITTING A TO BE SUSPENDED ON CONDUIT DROPS EXACT HEIGHT AND LOCATION TBC ONSITE.
- 2) ELECTRICAL ACCESSORIES TO BE MK WATER SEAL PLUS IP66
- 3) EXACT LOCATION OF BLACK BULB SENSORS TBC ON SITE
- 4) CORAL LIGHTING SUPPLY TO BE VIA MULTICORE SWA CABLE THEN GALVANISED CONDUIT AND LSZH SINGLE IN CONDUIT IN CORAL

Rev.	Description	Date
C2	SINK & WATER HEATER DELETED AND ACCESS CONTROL ADDED TO STORE	22.09.25
C1	CONTRACT ISSUE	15.09.25

PS PROGRESSIVE SERVICES DESIGN LTD
21 Argyle Street
Glasgow G3 7JF
Tel: 0151 647 0857
Fax: 0151 647 0858
E-mail: sales@psd.co.uk

BUILDING SERVICES CONSULTANCY

Client: **Alfred H Knight**

Project: **JKL Waste Treatment Project**

Drawn: **P.O.** Checked: **S.P.O.**
Scale: **1:50(A1)** Date: **MAY 25**

Title: **Proposed Building C Power, Lighting and Emergency Lighting Layout**

Drawing Number: **2273-E-63-00-02** Rev: **C2**