



The diagram illustrates a multi-layered cable structure with concentric layers. The layers are labeled as follows from the outermost to the innermost:

- WATER**: The outermost layer, shown in blue.
- HV ELECTRIC**: The high-voltage electric layer, shown in yellow.
- LV ELECTRIC**: The low-voltage electric layer, shown in red.
- GAS**: The gas layer, shown in grey.
- TELECOMS**: The telecommunications layer, shown in yellow.
- GPR(BZ)**: The gas pressure regulator (BZ) layer, shown in red.



Cable & Telecommunications

Cignal Infrastructure UK Limited (formerly known as CK Hutchison Networks (UK) Limited) is a company registered in England and Wales with company number 12865914 at c/o Hutchison 3G UK Limited (a company registered in England & Wales with company number 03885486)

Green Park, 450 Longwater Avenue
Reading, RG2 6GF
Tel: 01628 765 000
Fax: 01628 765 001

H3G Base Station Information line:
0845 604300
Available 8am-8pm Monday to Friday


CLARKE
telecom

Unit 6, Madison Place, Northampton Road,
Manchester, M40 5AG
Tel: 0161 785 4500 Fax: 0161 785 4501
Web: www.clarke-telecom.com

Master Drawing No:	Issue:
KSJ25683_KSJ109_L1029_M001_H3G_DNSW_GA_A	A

110mm

150mm

10mm



NOTES:

1. ALL DIMENSIONS IN MM UNLESS OTHERWISE NOTED.

Sheet	MBNL Cell ID	Project	Purpose of Issue	Issue
M001	H3G	DENSIFICATION SW	Planning	A
Date	25/04/2023	Revision / Upgrade Description:		
Drawn	S.Booth	First Issue		
Checked	G.Thomas			
Approved	G.Thomas			



Signal Infrastructure UK Limited (formerly known as CK Hutchison Networks (UK) Limited) (a company registered in England and Wales with company number 12855914) c/o Hutchison 3G UK Limited (a company registered in England & Wales with company number 03855486)

Green Park, 450 Longwater Avenue
Reading, RG2 6GF
Tel: 01628 755 000
Fax: 01628 755 001

H3G Base Station Information line:
0845 6043000
Available 8am-8pm Monday to Friday

Design Consultant & Principal Contractor:

CLARKE
telecom

Unit E, Madison Place, Northampton Road,
Manchester, M40 5AG
Tel: 0161 785 4500 Fax: 0161 785 4501
Web: www.clarke-telecom.com

Site Name: **HORNHOUSE LANE**

Site ID: **KSY25683**

Address: **HORNHOUSE LANE
KNOWSLEY INDUSTRIAL ESTATE
KIRBY
LIVERPOOL
L33 7TZ**


Title: **150 EXISTING H3G ELEVATION**

Project: **H3G DENSIFICATION STREETWORKS**

Purpose of Issue: **PLANNING**

MBNL Cell ID	3UK Cell ID
KSY109	L1029


Master Drawing No: **KSY25683_KSY109_L1029_M001_H3G_DNSW_GA_A** Issue: **A**

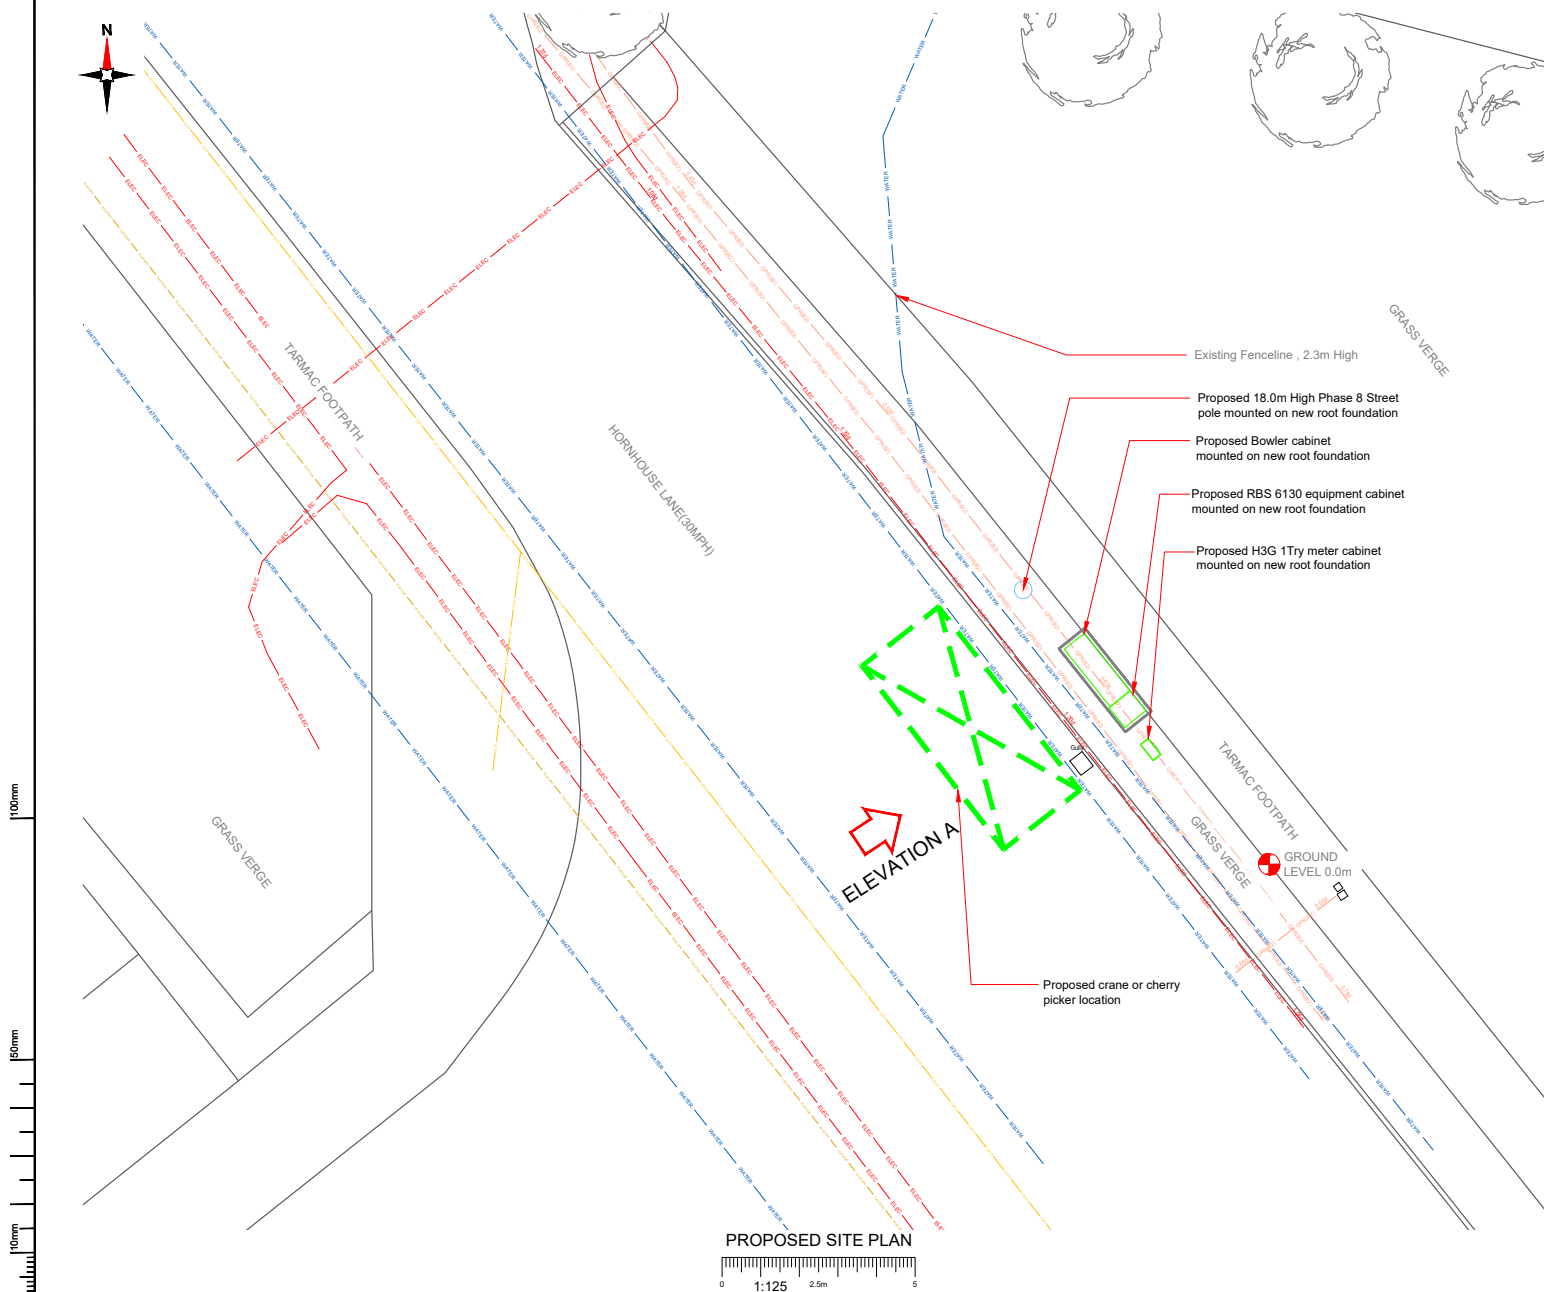

NOTES:

1. ALL DIMENSIONS IN MM UNLESS OTHERWISE NOTED.

SERVICES LEGEND

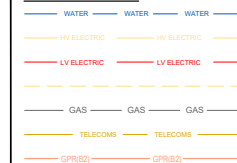

Sheet	MBNL Cell ID	Project	Proposed of Work	Issue
M001	H3G	DENSIFICATION SW	Planning	A
Drawn	25/04/2023	Revision / Upgrade Description:		
Checked	G. Booth	First Issue		
Approved	G. Thomas			

Signal Infrastructure UK Limited (formerly known as CK Hutchison Networks (UK) Limited) (a company registered in England and Wales with company number 1285914) c/o Hutchison 3G UK Limited (a company registered in England & Wales with company number 03855486)

Green Park, 450 Longwater Avenue
Reading, RG2 6GF
Tel: 01628 755 000
Fax: 01628 755 001

H3G Base Station Information line:
0845 6043000
Available 8am-8pm Monday to Friday

Design Consultant & Principal Contractor:

CLARKE
telecom

Unit E, Madison Place, Northampton Road,
Manchester, M40 5AG
Tel: 0161 785 4500 Fax: 0161 785 4501
Web: www.clarke-telecom.com

Site Name: HORNHOUSE LANE

Site ID: KSY25683

Address:
HORNHOUSE LANE
KNOWSLEY INDUSTRIAL ESTATE
KIRBY
LIVERPOOL
L33 7TZ

Title: 210 PROPOSED H3G SITE PLAN


Project: H3G DENSIFICATION STREETWORKS

Purpose of Issue: PLANNING

MBNL Cell ID: KS109	3UK Cell ID: L1029
-------------------------------	------------------------------

Master Drawing No:
KS109_KSY109_L1029_M001_H3G_DNSW_GA_A

Issue:
A

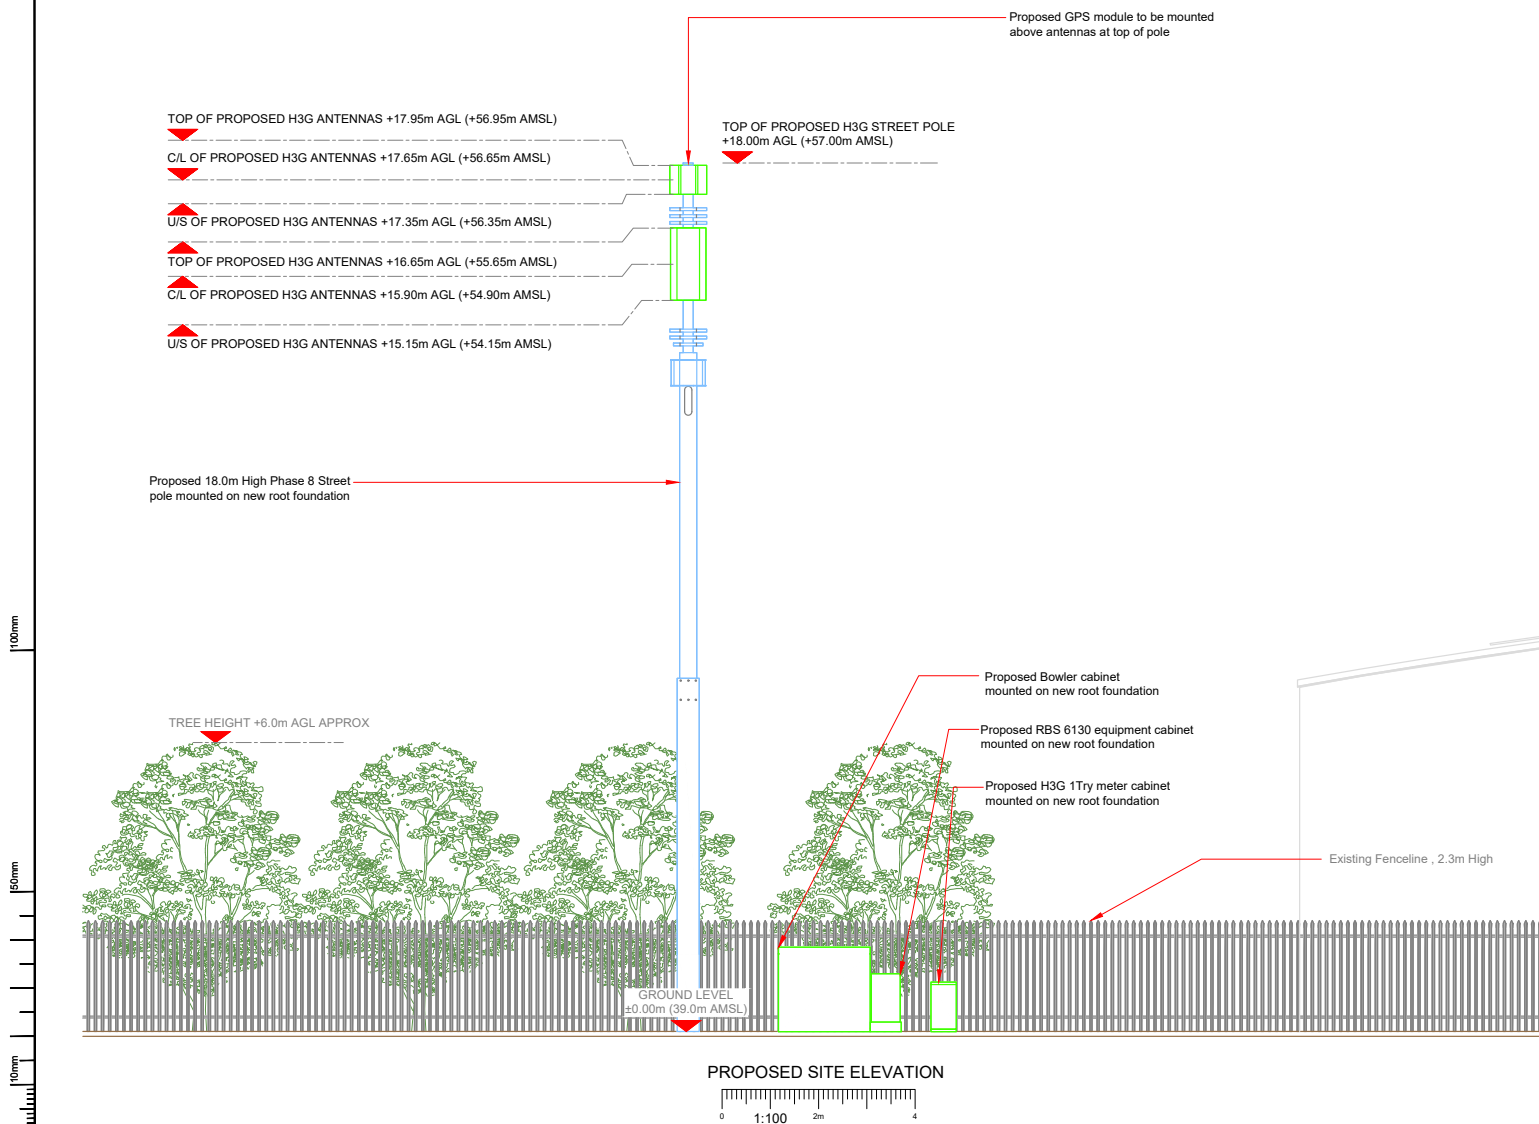

NOTES:

- ALL DIMENSIONS IN MM UNLESS OTHERWISE NOTED.

Sheet	MBNL Cell ID	Project	Proposed of Issue	Issue
M001	H3G	DENSIFICATION SW	Planning	A
Date	25/04/2023	Revision 1 Upgrade Description		
Drawn	S.Booth	First Issue		
Checked	G.Thomas			
Approved	G.Thomas			

3

Signal Infrastructure UK Limited (formerly known as CK Hutchison Networks (UK) Limited) (a company registered in England and Wales with company number 1285914) c/o Hutchison 3G UK Limited (a company registered in England & Wales with company number 03855486)

Green Park, 450 Longwater Avenue
Reading, RG2 6GF
Tel: 01628 755 000
Fax: 01628 755 001

H3G Base Station Information line:
0845 6043000
Available 8am-8pm Monday to Friday

Design Consultant & Principal Contractor:

CLARKE telecom

Unit E, Madison Place, Northampton Road,
Manchester, M40 5AG
Tel: 0161 785 4500 Fax: 0161 785 4501
Web: www.clarke-telecom.com

Site Name: **HORNHOUSE LANE**Site ID: **KSY25683**Address: **HORNHOUSE LANE
KNOWSLEY INDUSTRIAL ESTATE
KIRBY
LIVERPOOL
L33 7TZ**Title: **260 PROPOSED H3G ELEVATION**Project: **H3G DENSIFICATION STREETWORKS**Purpose of Issue: **PLANNING**

MBNL Cell ID	3UK Cell ID
KSY109	L1029

Master Drawing No:	Issue:
KSY25683_KSY109_L1029_M001_H3G_DNSW_GA_A	A