



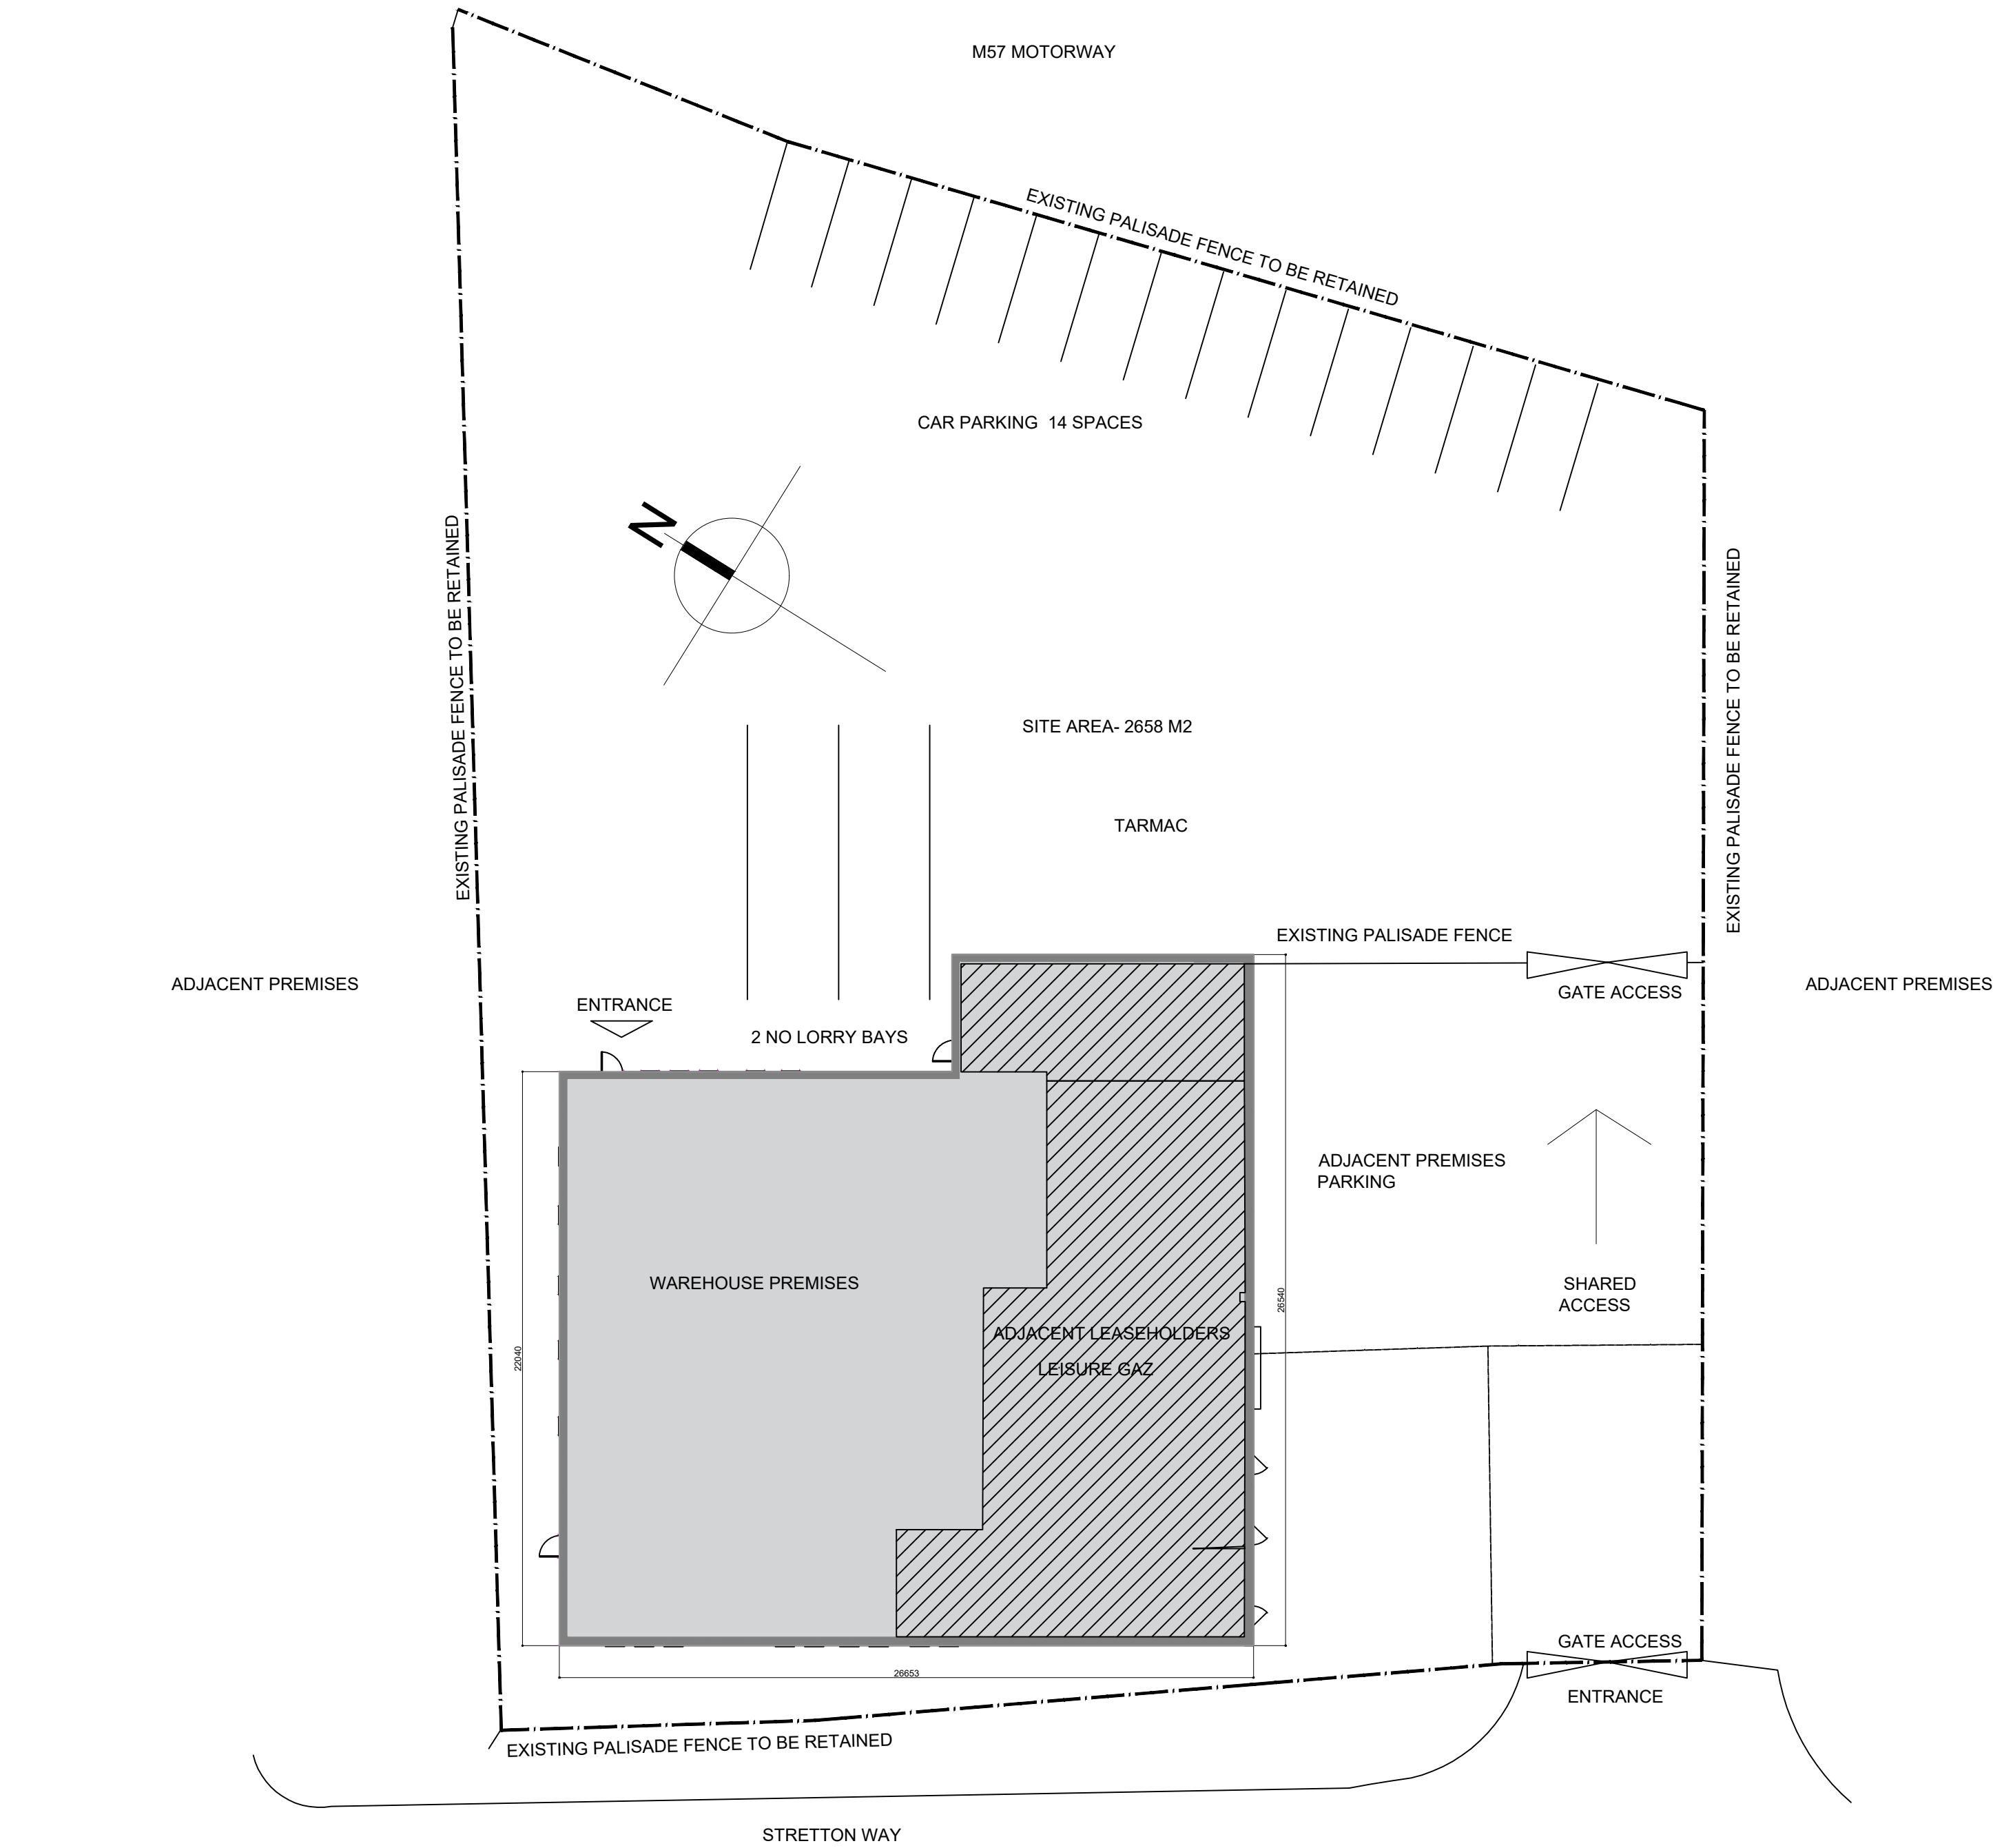

SITE PLAN AS EXISTING
scale bar 1:200 @ A1

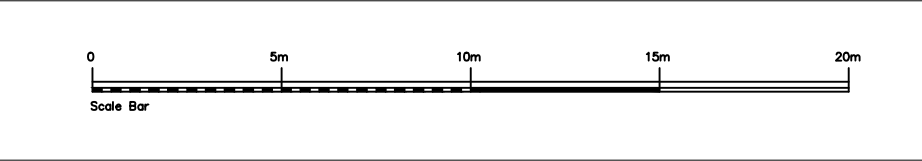

LOCATION PLAN 1:1250 @ A1

rev	date	name	chk	note
A MAC Design Consultancy Services Ltd, 7 Hesp Lane, 7th Floor London, EC3R 6DP A MAC Design Consultancy Services Ltd, Bell House, Seabrook Place, Knowlhill Milton Keynes MK5 8FR T: 01908 231297 W: www.maconconsultingtd.com E: contact@maconconsultingtd.com				

A1 Original Sheet Size STATUS PLANNING	© MAC DESIGN CONSULTANCY SERVICE LTD.
--	---------------------------------------

HUYTON AMBULANCE STATION
1-2 STRETTON WAY, HUYTON, LIVERPOOL

NORTH WEST AMBULANCE SERVICE NHS TRUST

DRAWING TITLE
SITE BLOCK PLAN AS EXISTING

SCALE	DATE	DRAWN	CHK
1: 200 @ A1	January 2025	ss	nm
DRAWING NUMBER	REVISION		
58020-PL -100	-		