
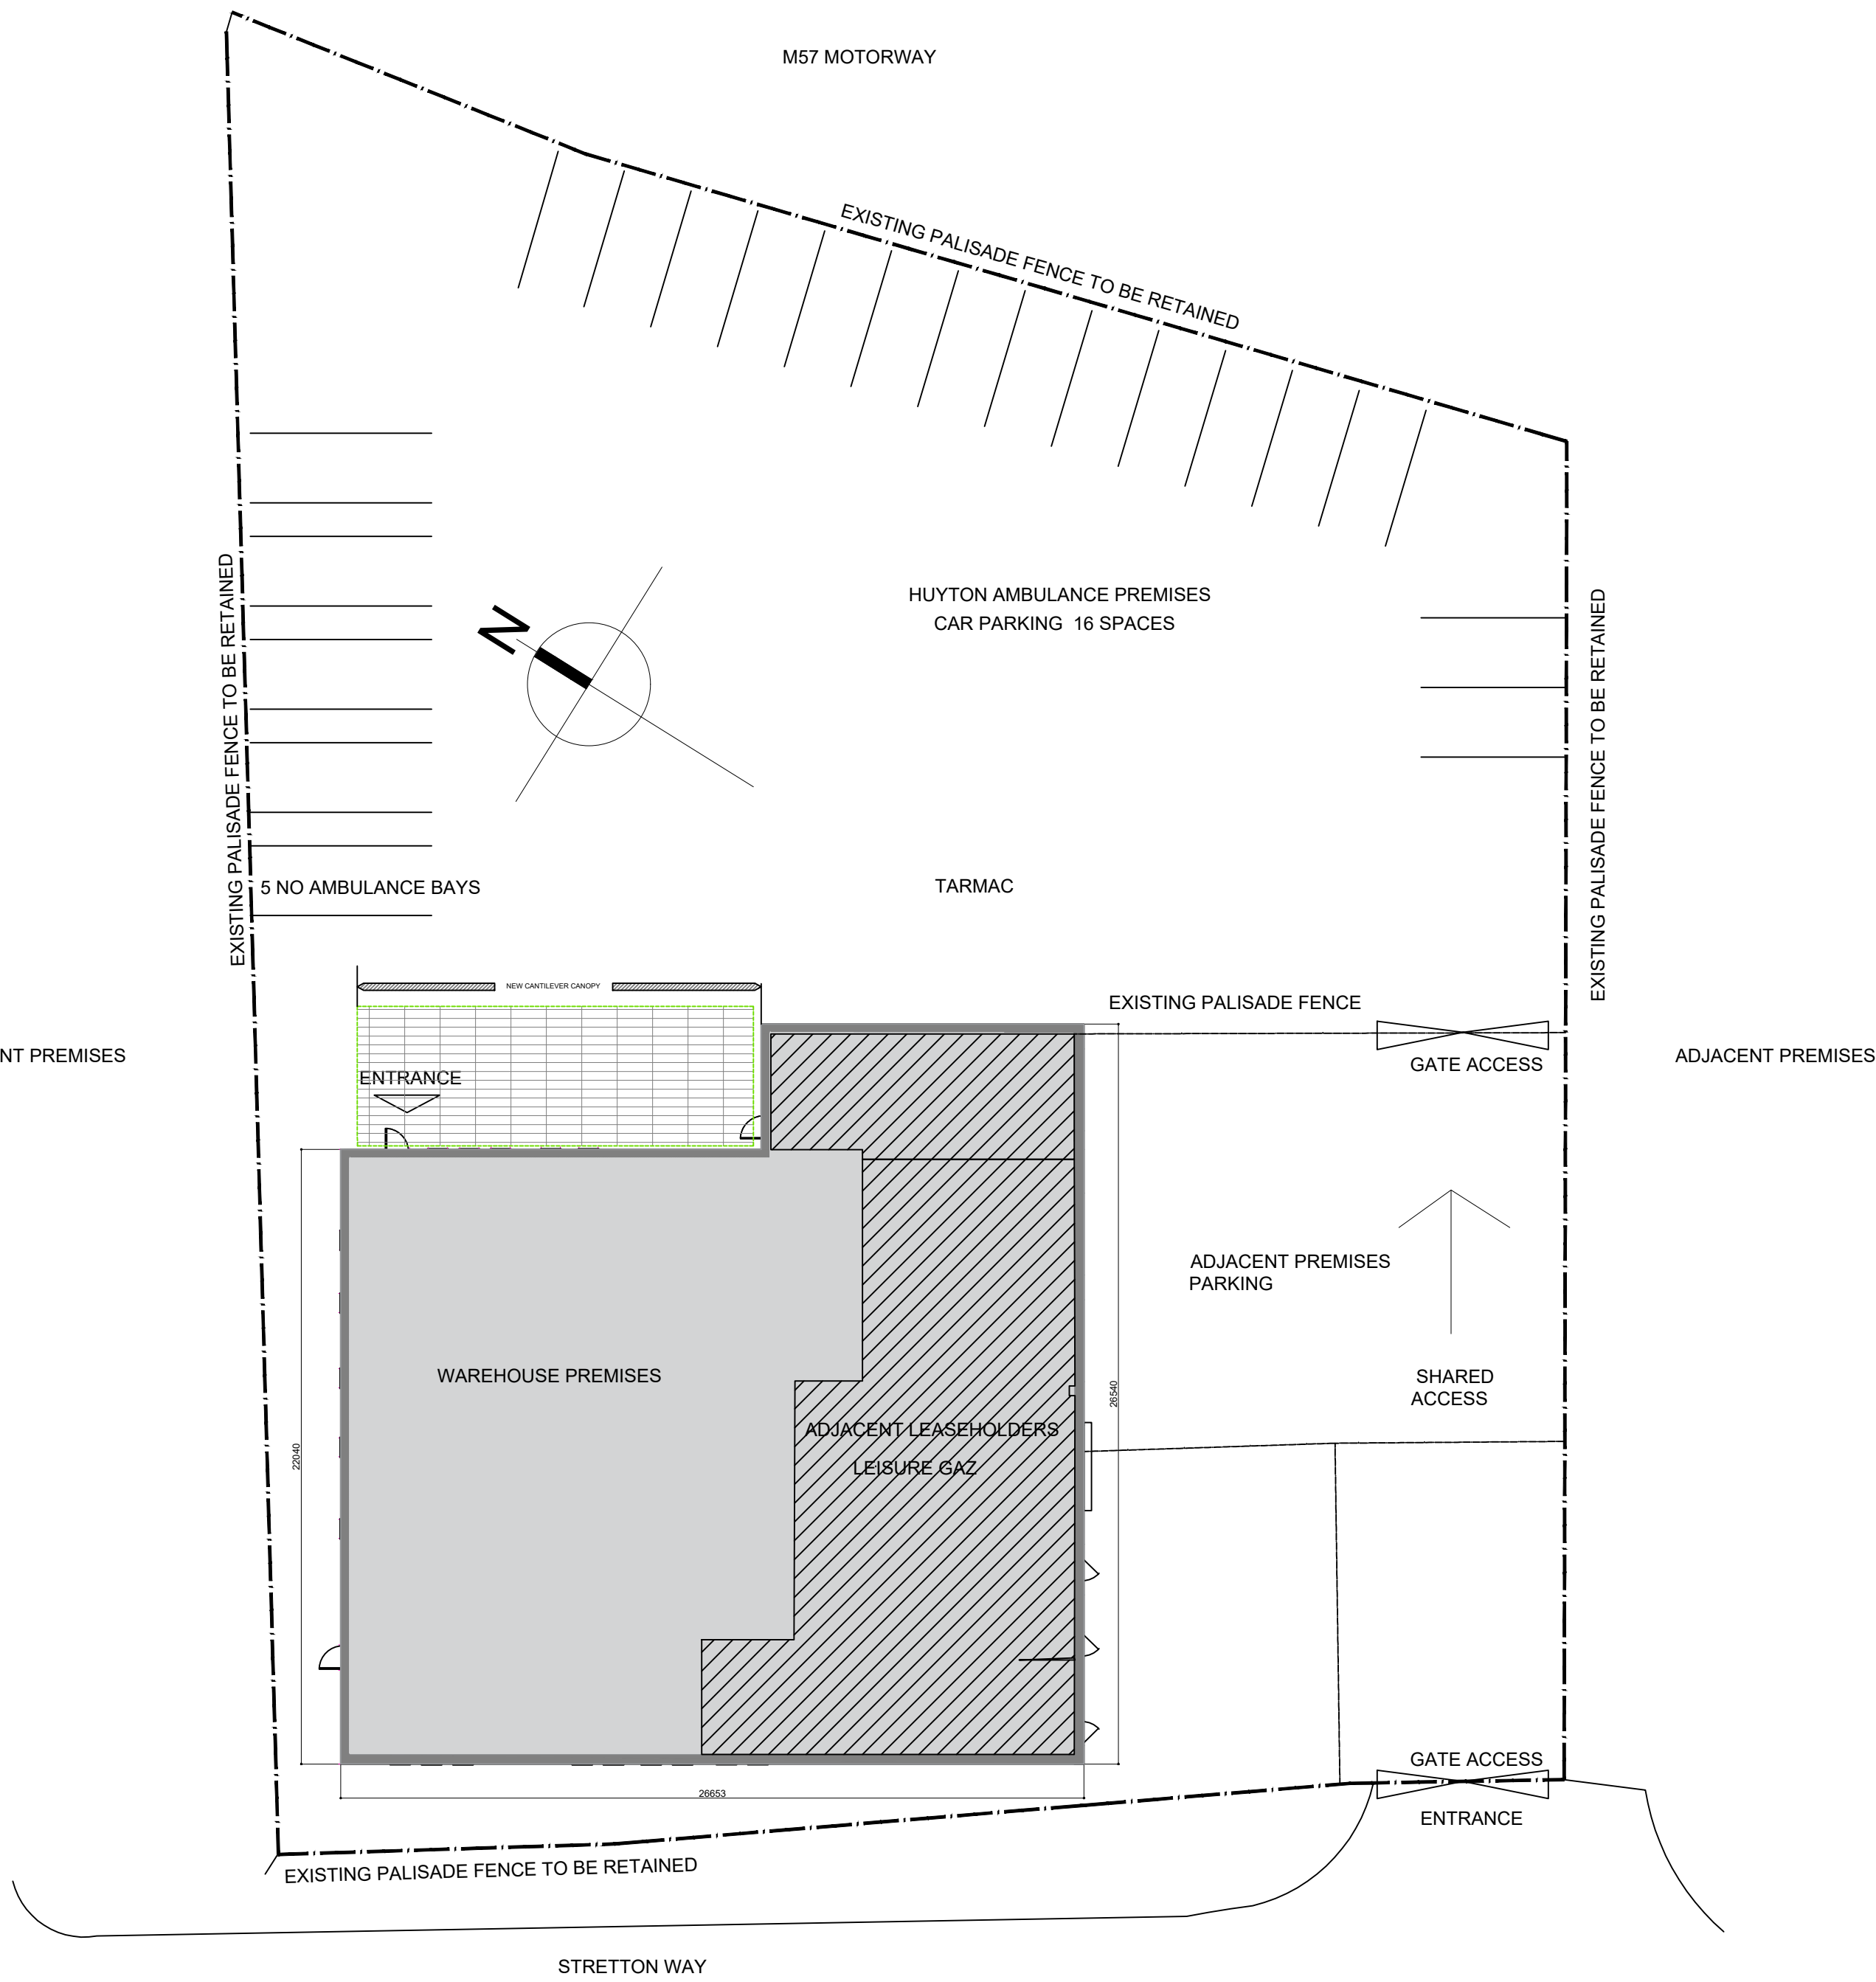


SITE PLAN AS PROPOSED
scale bar 1:200 @ A1

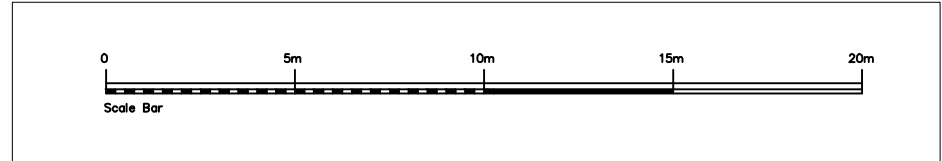

rev	date	name	chk	note
A. MAC Design Consultancy Services Ltd. 7 Hupp Lane, 7th Floor London, EC2R 6DP A. MAC Design Consultancy Services Ltd. Bell House, Seabrook Place Knowsall Milton Keynes MK3 8PR T: 01908 231257 W: www.maconconsultingltd.com E: contact@maconconsultingltd.com				

A1	© MAC DESIGN CONSULTANCY SERVICE LTD.
Original Sheet Size	
STATUS PLANNING	

HUYTON AMBULANCE STATION
1-2 STRETTON WAY, HUYTON, LIVERPOOL

NORTH WEST AMBULANCE SERVICE NHS TRUST

DRAWING TITLE
SITE BLOCK PLAN AS PROPOSED

SCALE	DATE	DRAWN	CHK
1: 100 @ A1	January 2025	ss	nm
DRAWING NUMBER			REVISION
58020-PL -104			-