
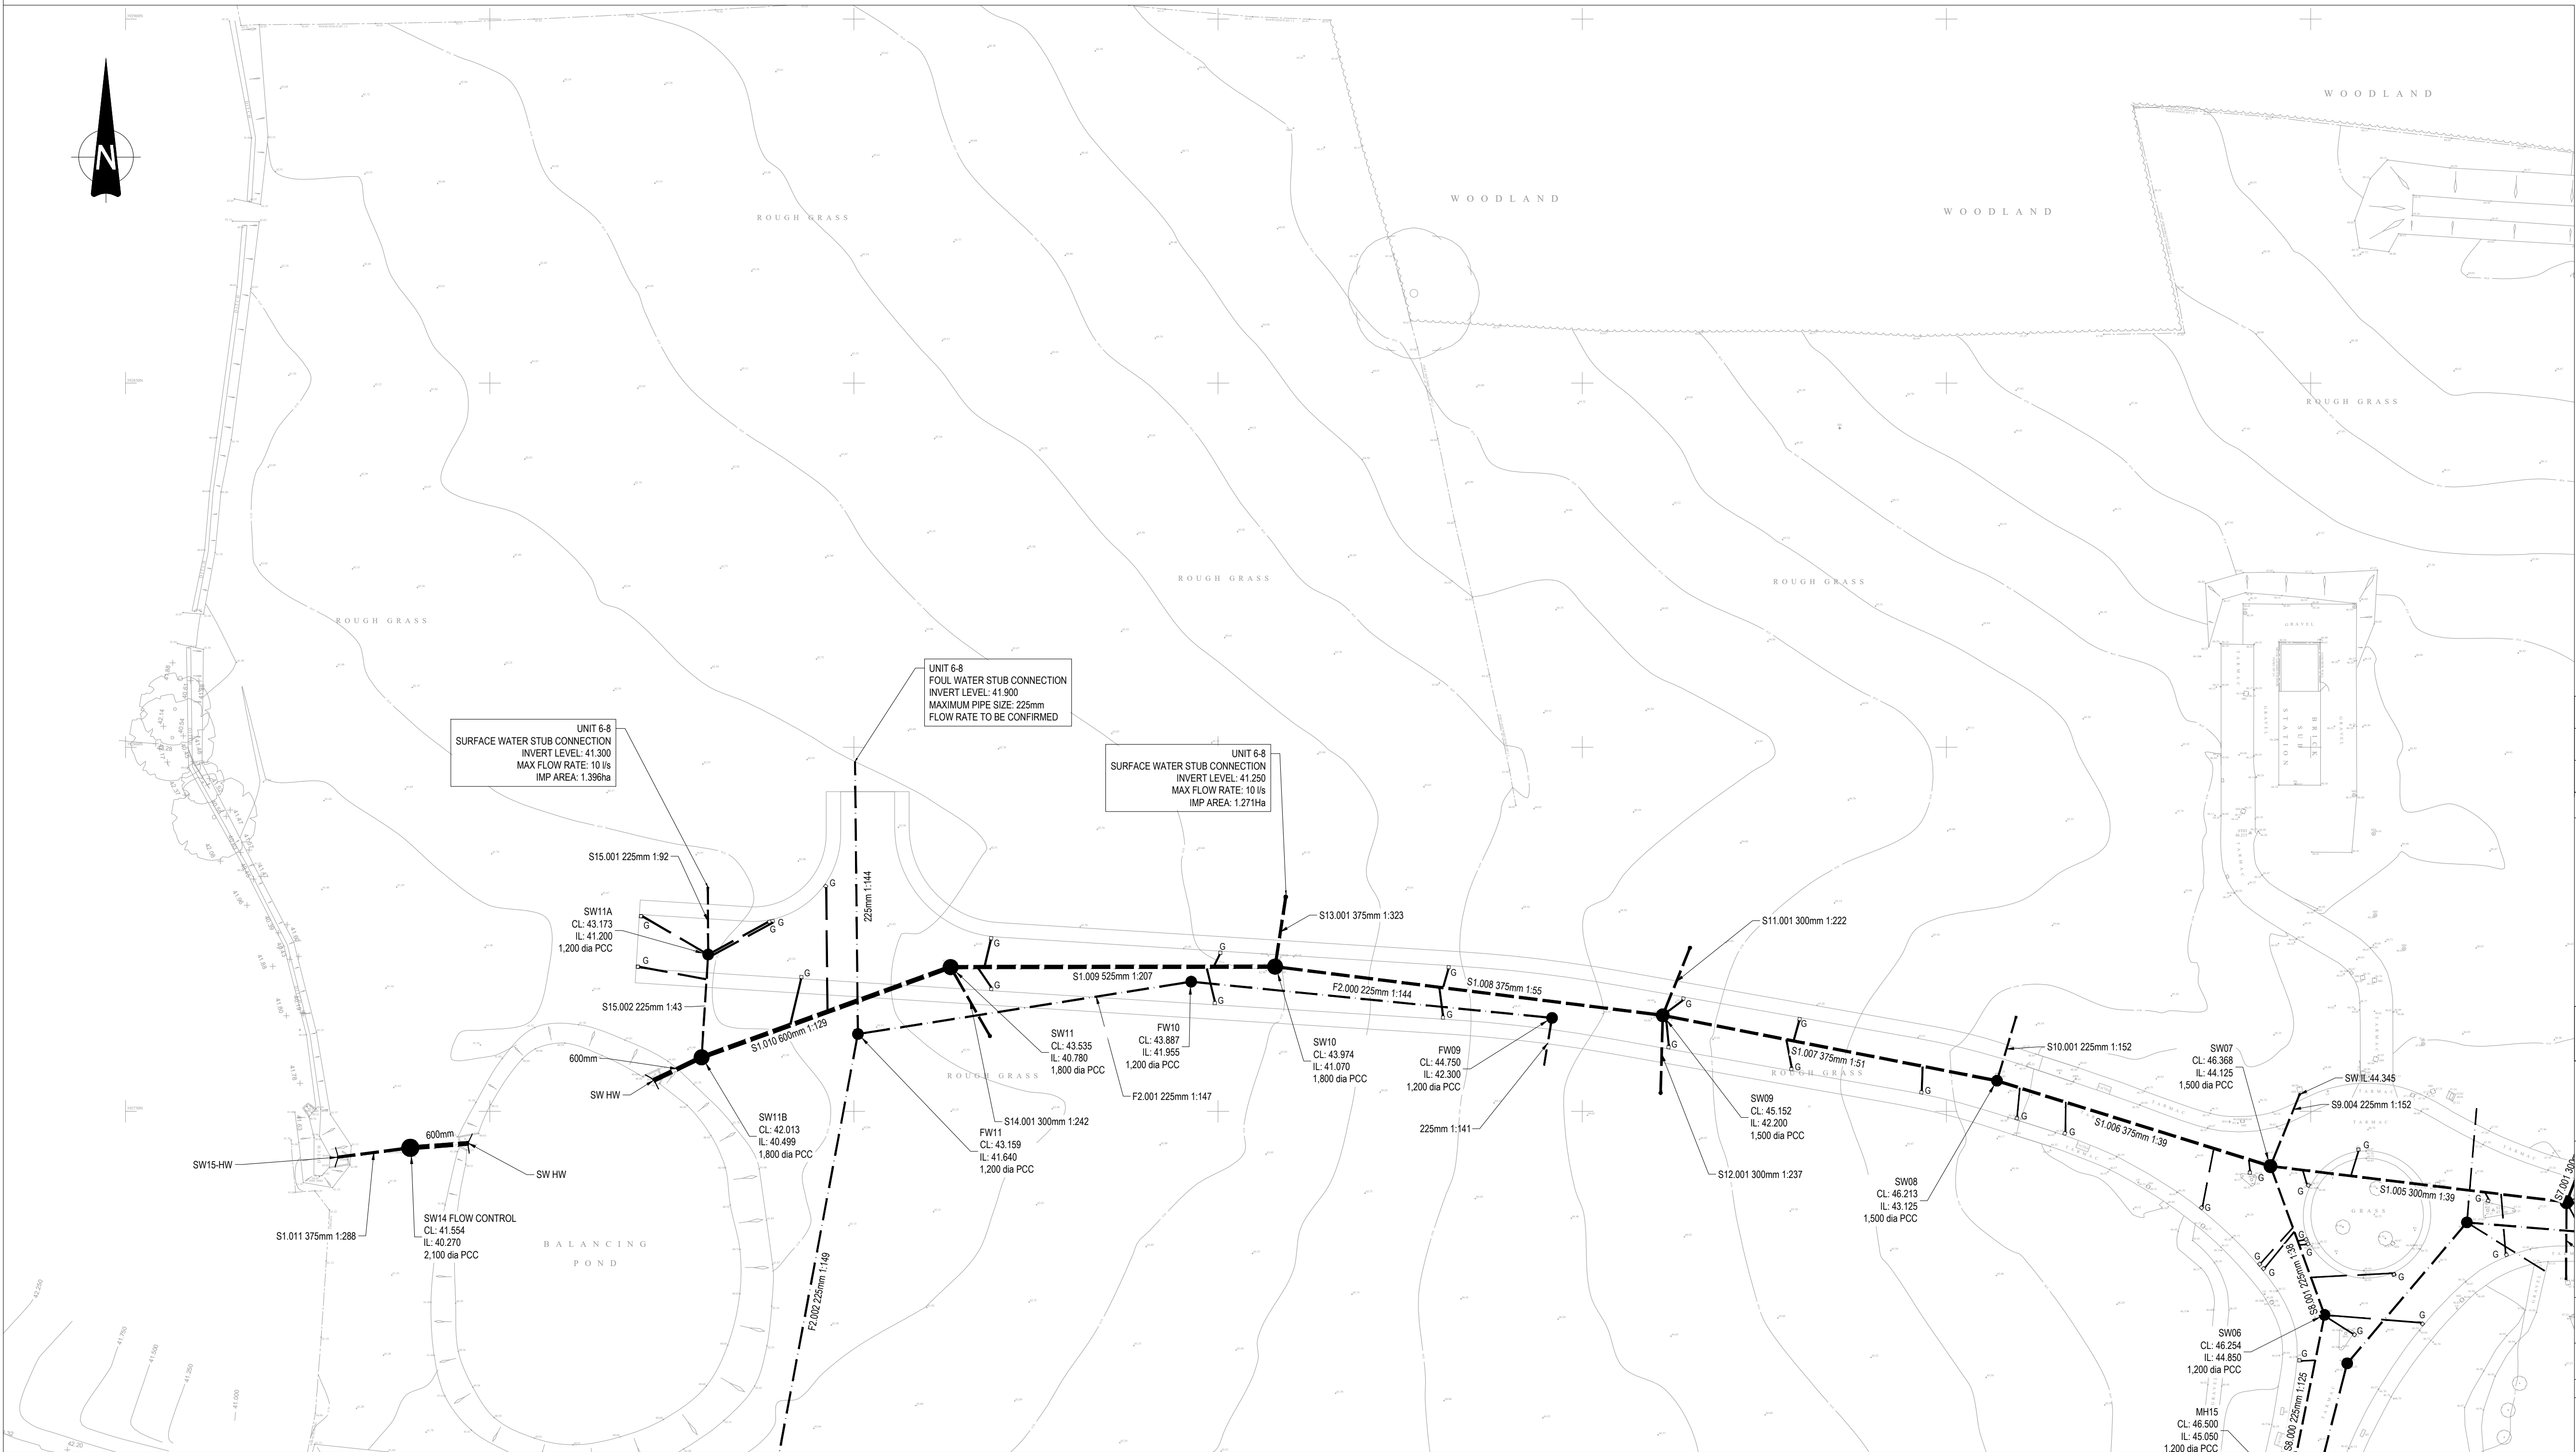


1. THIS DRAWING IS TO BE READ IN CONJUNCTION WITH ALL RELEVANT ARCHITECTS AND ENGINEERS DRAWINGS AND SPECIFICATIONS.
2. DO NOT SCALE THIS DRAWING. ANY AMBIGUITIES, OMISSIONS AND ERRORS ON DRAWING SHALL BE BROUGHT TO THE ENGINEERS ATTENTION IMMEDIATELY. ALL DIMENSIONS MUST BE CHECKED / VERIFIED ON SITE.
3. DESIGN BASED ON TOPOGRAPHICAL SURVEY AND CCTV SURVEY INFORMATION AVAILABLE AT THE TIME OF DESIGN.
4. ALL DIMENSIONS ARE IN METRES AND LEVELS IN METRES ABOVE ORDNANCE DATUM UNLESS OTHERWISE NOTED.
5. EXISTING SEWER LOCATIONS WHERE THE PROPOSED DRAINAGE IS TO CONNECT, ARE TO BE SURVEYED AND EXACT LEVELS CONFIRMED PRIOR TO CONSTRUCTION
6. ALL PIPE DIAMETERS GIVEN ARE NOMINAL INTERNAL PIPE DIAMETERS.
7. WHERE Foul SEWERS RUN ABOVE SURFACE SEWERS, CONCRETE PROTECTION MAY BE REQUIRED AT CROSSOVERS TO PREVENT ANY POTENTIAL CONTAMINATION.
8. ALL NEW CONNECTIONS INTO EXISTING MANHOLES (OR INTO EXISTING SEWERS) TO BE 'SOFFITS LEVEL' UNLESS OTHERWISE NOTED.
9. DRAWING IS FOR INFORMATION PURPOSES AND NOT TO BE USED FOR CONSTRUCTION.

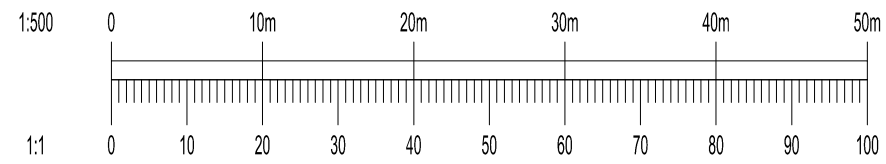

P03	DISPLAY INFORMATION UPDATED	21/06/22	JDB	JDB
P02	UPDATED MANHOLE DETAILS	07/02/22	LB	AF
P01	ISSUED	31/01/22	LB	AF
Rev:	Description:	Date:	By:	Chkd:

51-55 Tithebarn Street, Liverpool, L2 2SB
0151 726 2000
liverpool@curtins.com
www.curtins.com

Civils & Structures • Transport Planning • Environmental • Infrastructure • Geotechnical • Conservation & Heritage • Principal Designer
Birmingham • Bristol • Cambridge • Cardiff • Douglas • Dublin • Edinburgh • Glasgow • Kierdal • Leeds • Liverpool • London • Manchester • Nottingham

Status: 00

SUITABLE FOR INFORMATION **S2**

Project: EARLSFIELD PARK

Drg Title:

UNIT 6-8
DRAINAGE PLAN

Drawn By LB	Designed By LB	Checked By AF	
	Date 31/01/22	Scales @ A1 1:500	
Project No - Originator - Function - Spatial - Form - Discipline - Number			Revision
079708 - CUR - ZZ - XX - D - C - 92003			P03