


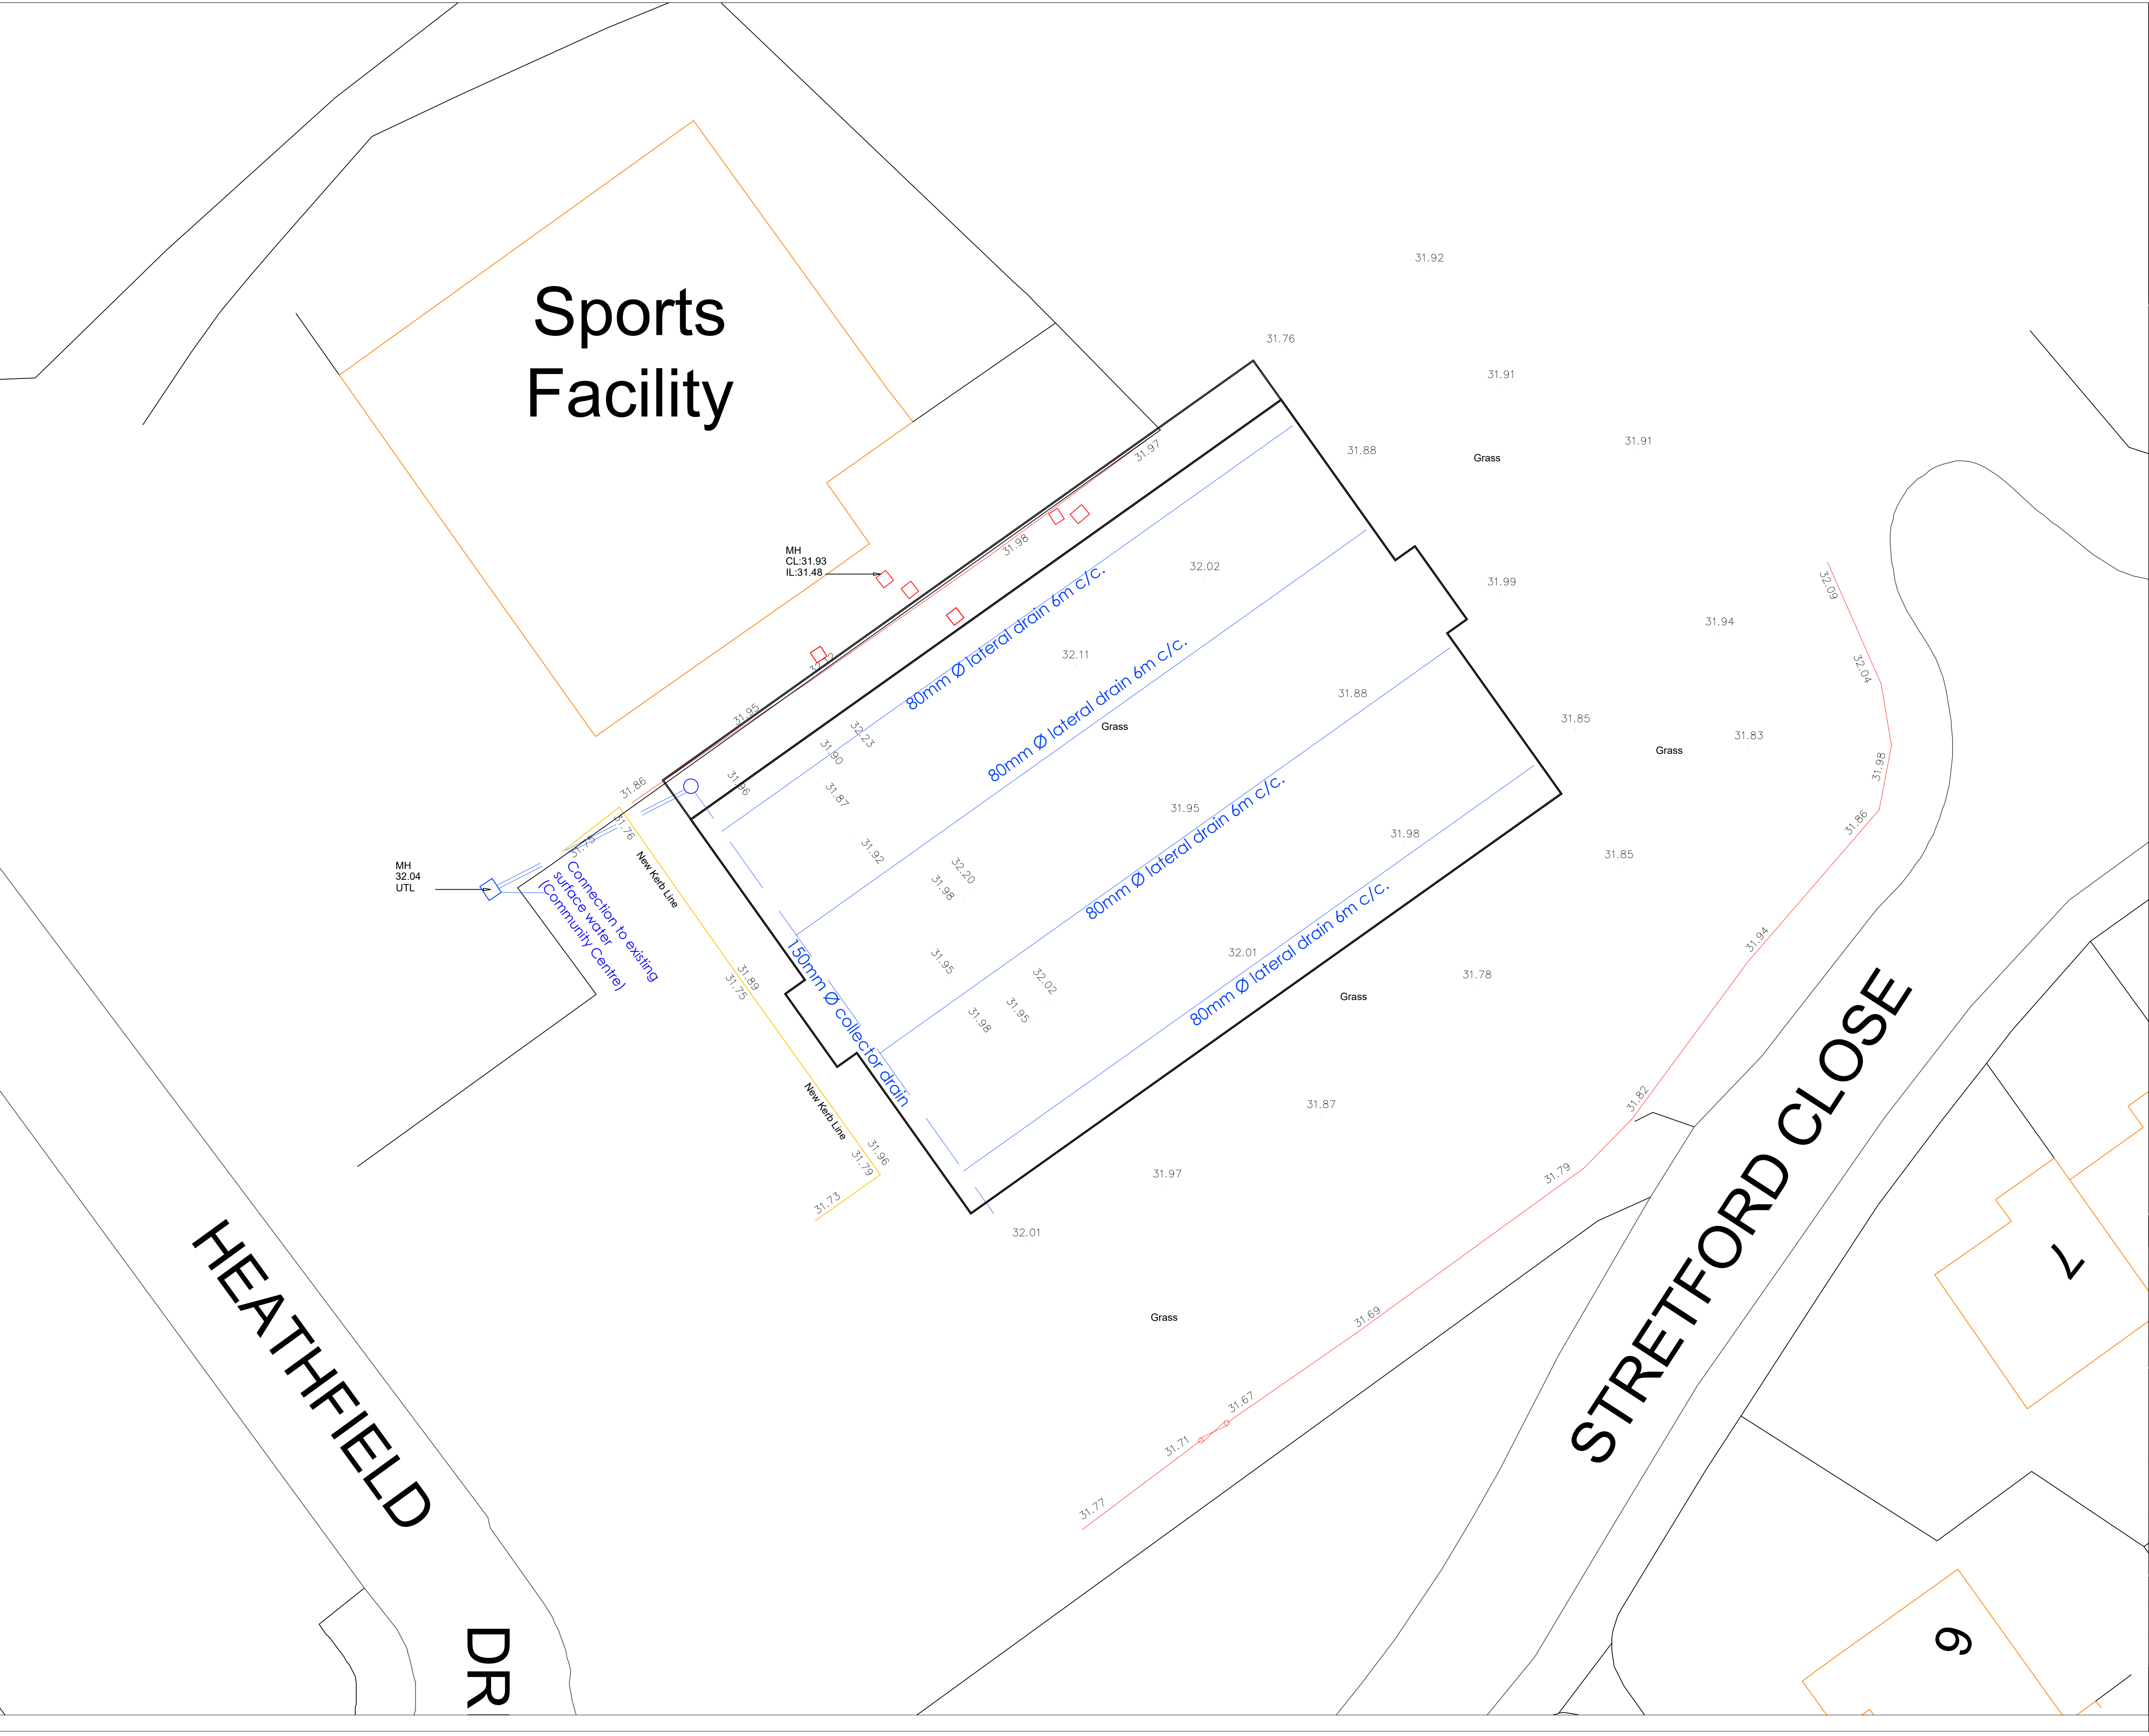

Notes

It is the contractors responsibility to check design levels and sizes for compliance. Any discrepancies or errors to be identified to the design team.

Drainage Details

- 80mm Ø perforated lateral pipes laid running the width of the pitch at 5.0m centres
- 150mm Ø perforated carrier pipe discharging in to new silt trap manhole

Key

- 80mm Ø Perforated Lateral Drain
- 150mm Ø Perforated Carrier Drain
- New Manhole
- New Rodding Eye
- Existing Manhole

Copyright Sports Labs Ltd 2026

Revision	Date	Description	By
Status			
Sports Labs 1 Adam Square Brucefield Industrial Estate Livingston info@sportslabs.co.uk			
Client Knowsley Council			
Site Tower Hill ABC, Heathfield Drive, Kirkby L33 1WU			
Drawing Title Drainage Layout			
Drawing No. 3450-DR-200-GA-R01			
Scale @ A1 1:100	Date 04/2026	Drawn By PM	Checked By CH
Scale Bar (metres) 			