




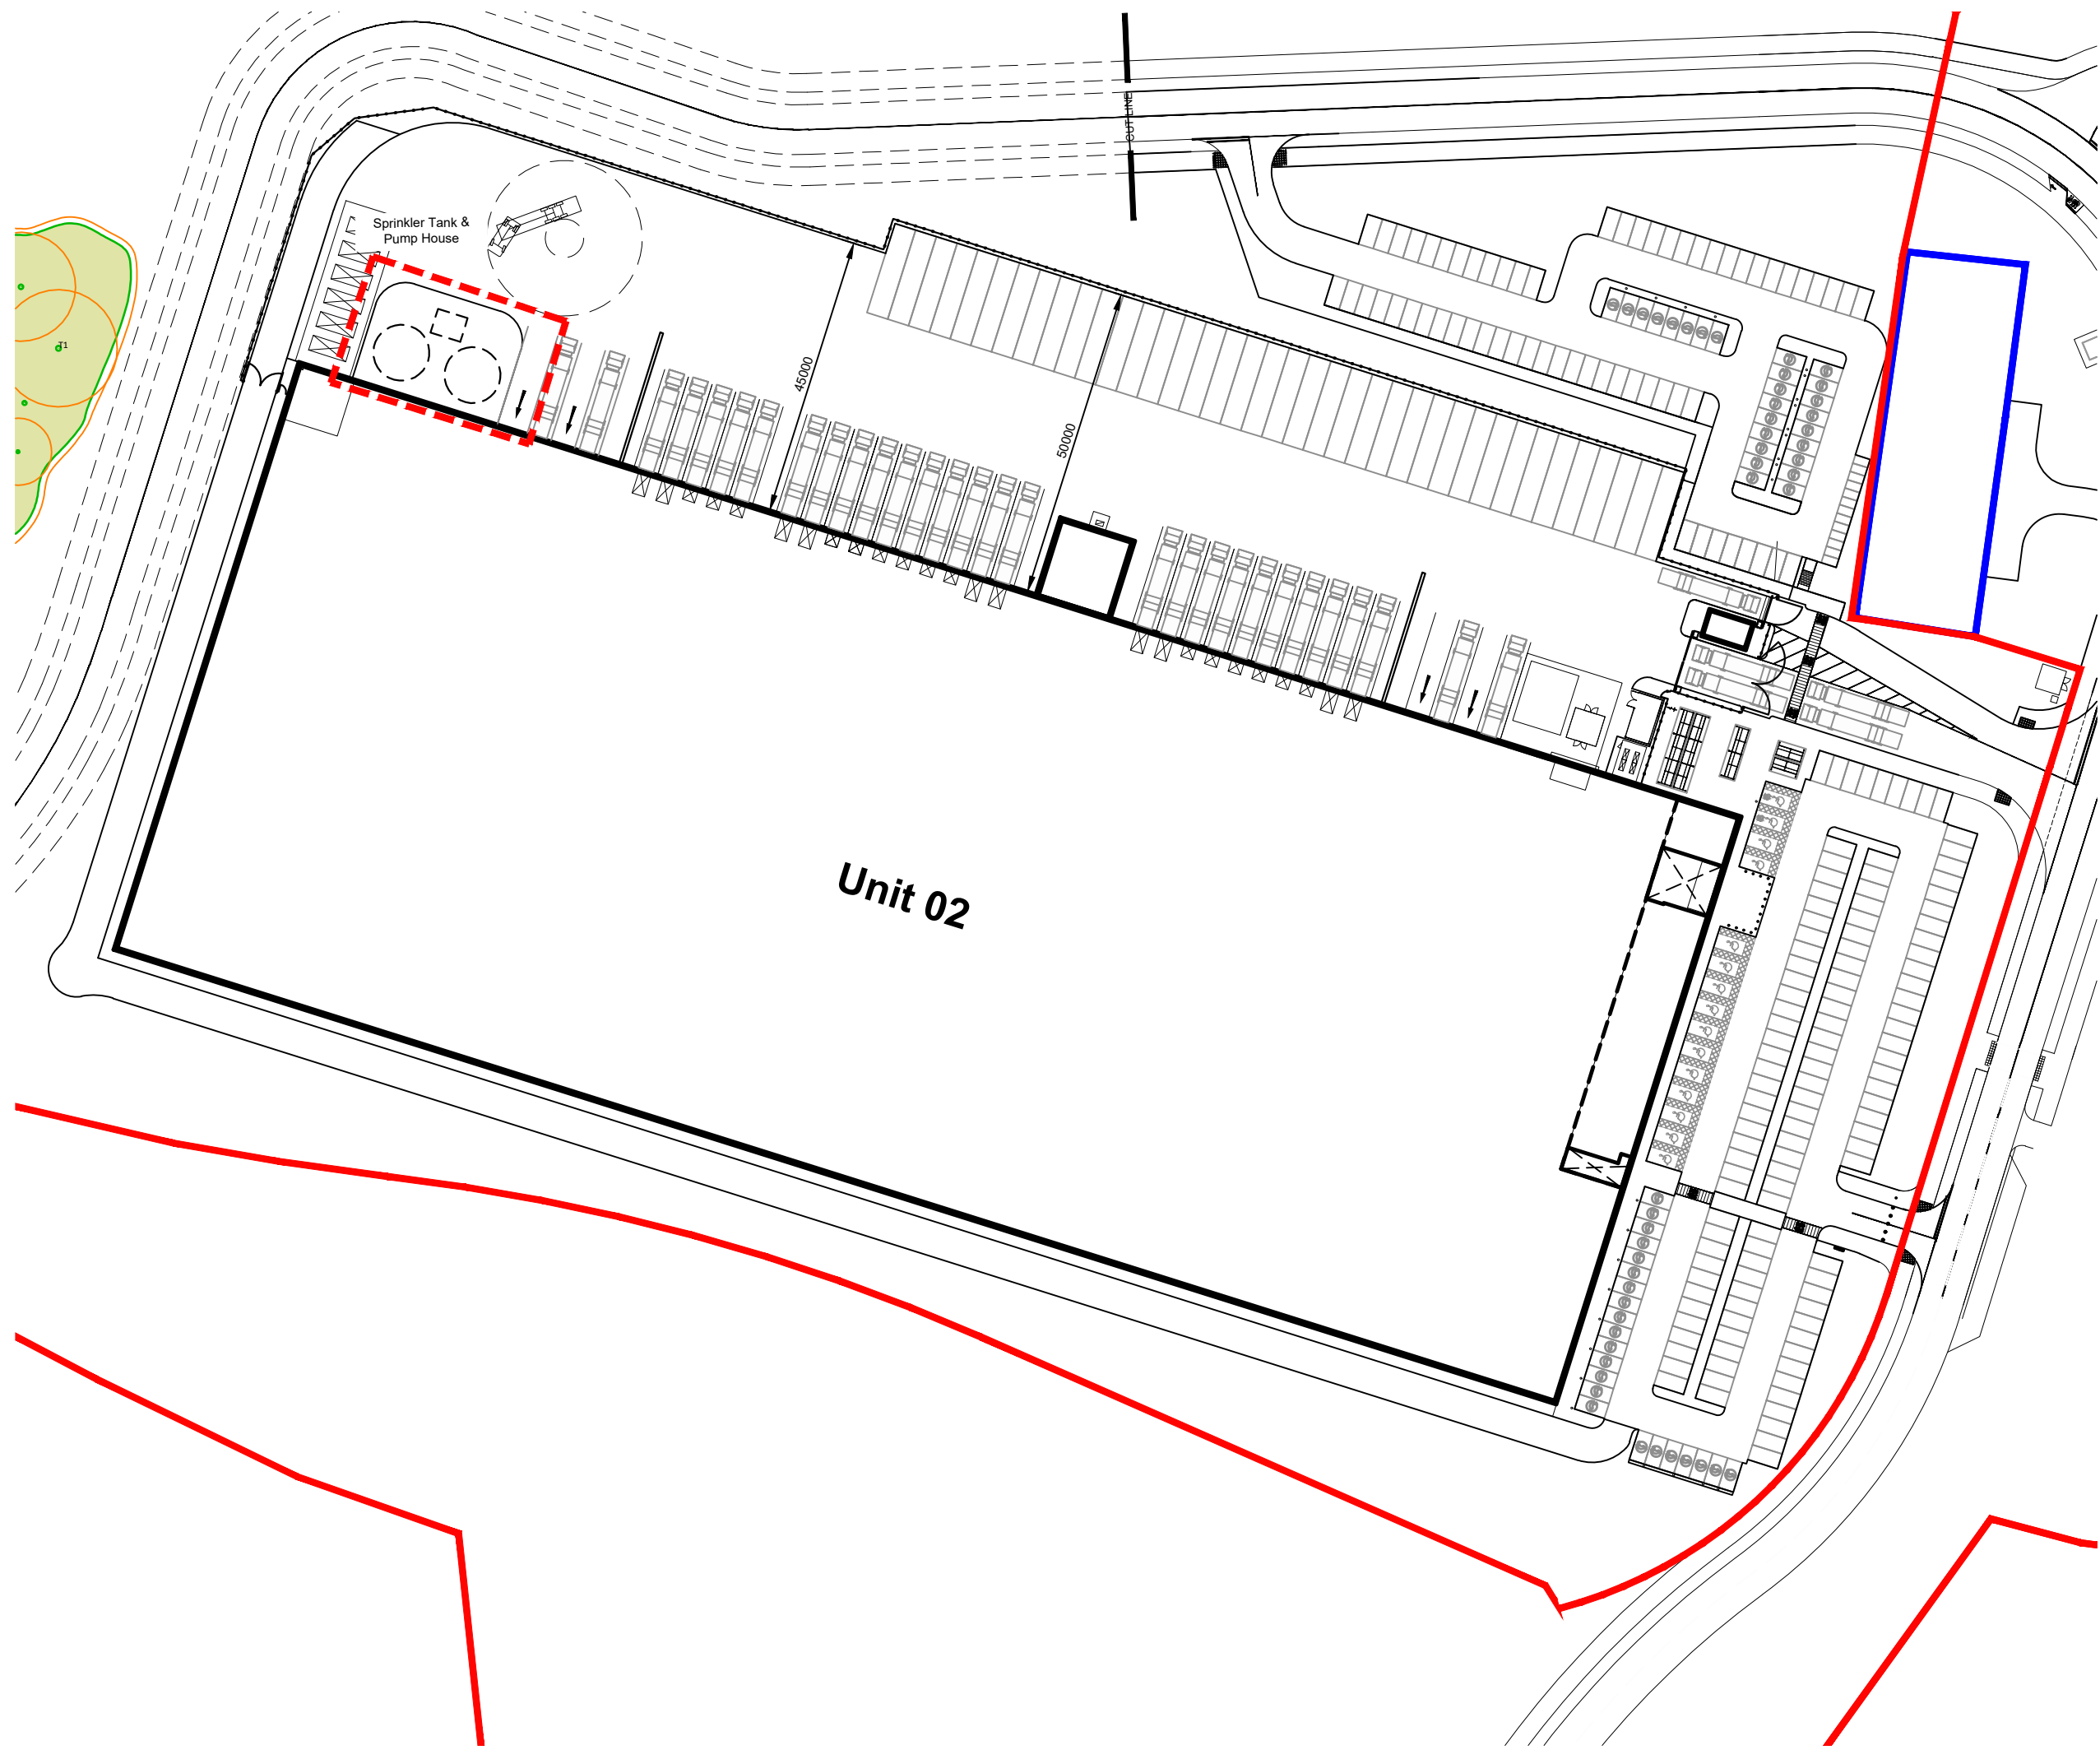


Site Plan Scale 1:1000

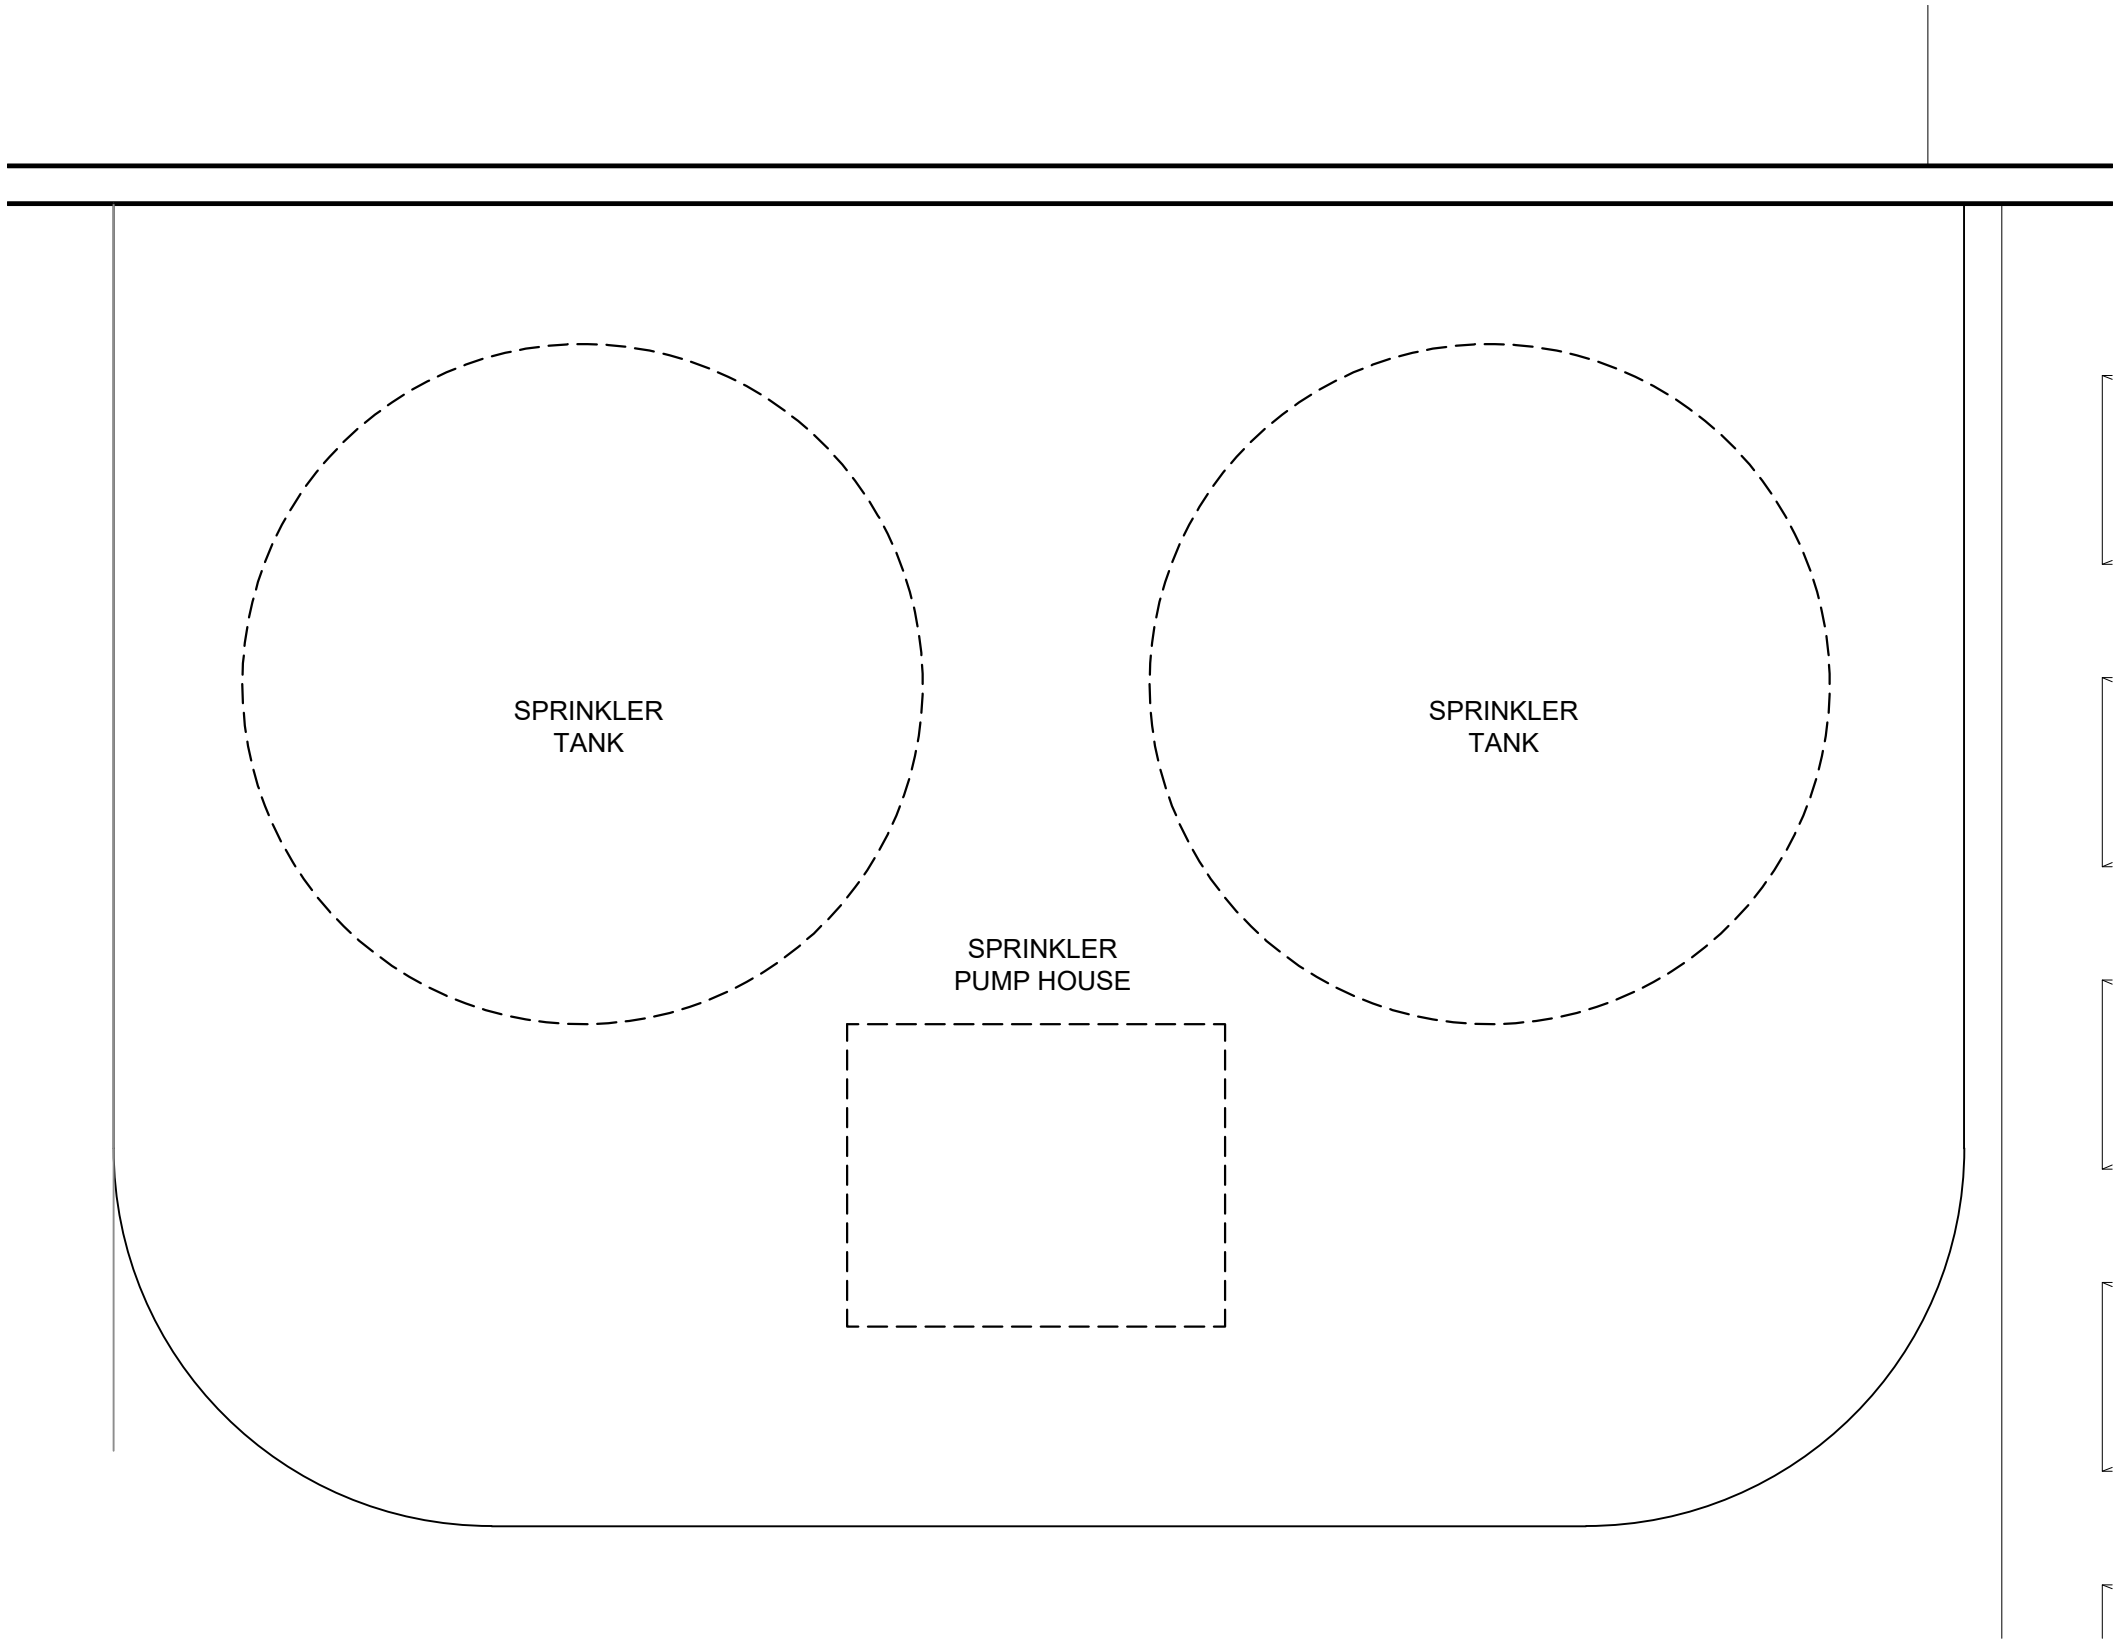

Sprinkler Tanks and Pump House Layout Scale 1:100

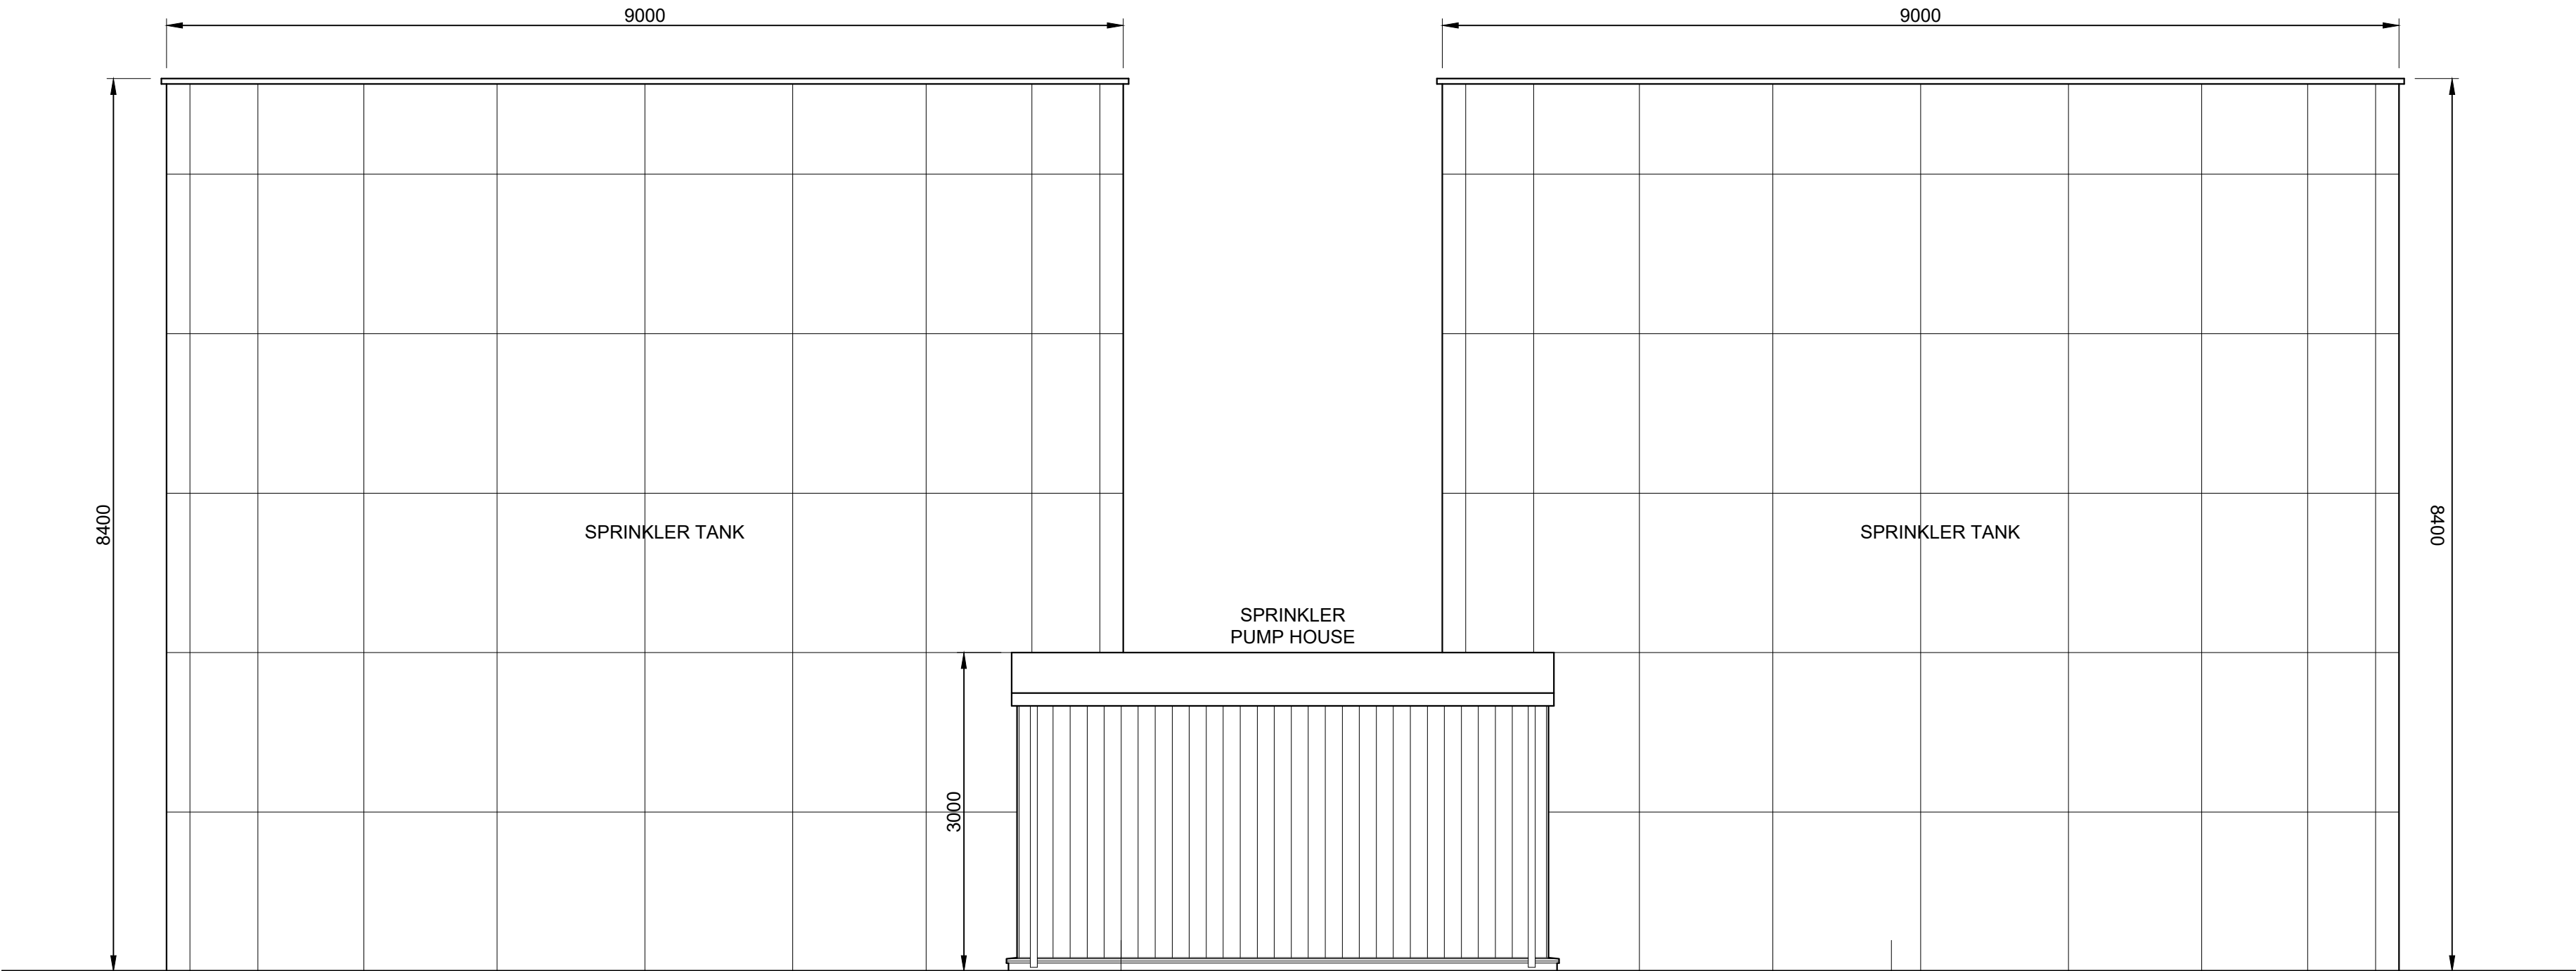


Sprinkler Tanks and Pump House Elevation Scale 1:50

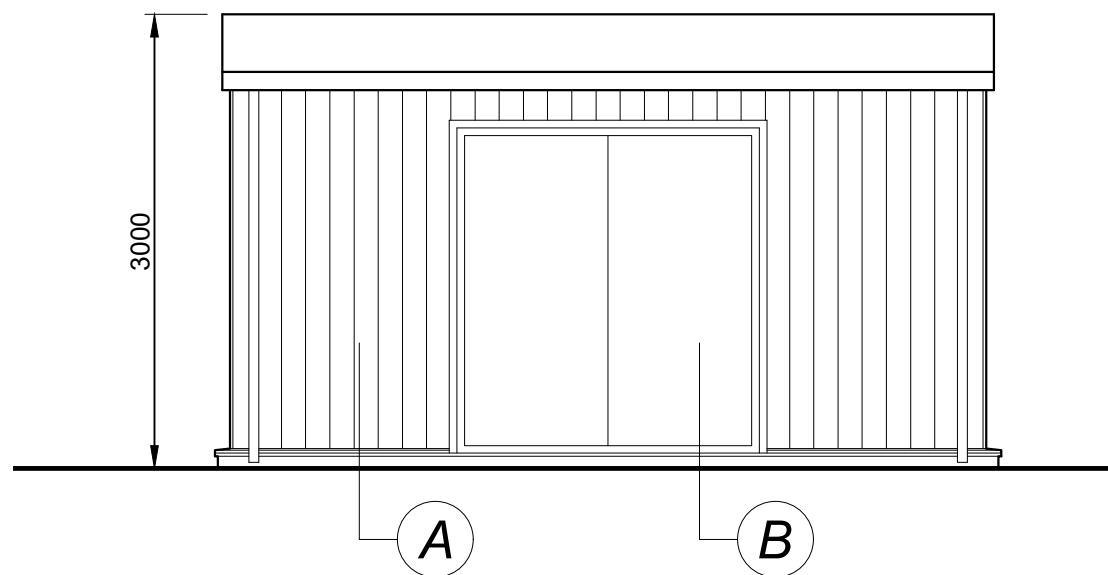


Pump House Elevation Scale 1:50

External Finishes

- A** Vertically laid
Profiled wall cladding system.
Finish: Tata Colorcoat HPS 200 Ultra.
Colour: Alaska Grey (RAL 7000)
- B** Steel insulated personnel door & frame
Finish: Factory applied polyester powder
coat paint finish.
Colour: Anthracite (RAL 7016)
- C** Galvanised steel water storage tanks
Finish: Factory applied polyester powder
coat paint finish
Colour: Metallic Silver (RAL 9006)

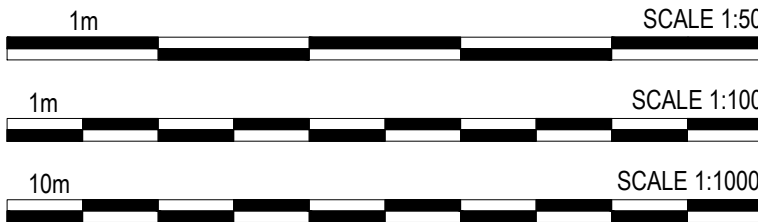

PLANNING

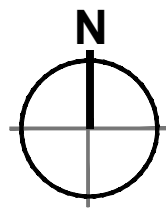

- Masterplan Boundary
- Application Boundary
- Sprinkler Tanks & Pump House

- Dimensions are in millimeters, unless stated otherwise.
- Scaling of this drawing is not recommended.
- It is the recipients responsibility to print this document to the correct scale.
- All relevant drawings and specifications should be read in conjunction with this drawing.

rev	amendments	by	ckd	date
-----	------------	----	-----	------

Unit 02, Symmetry Park,
Merseyside
Sprinkler Tank and Pump House Details

TRITAX SYMMETRY
A TRITAX BIG BOX COMPANY

umc architects
3rd Floor, Manchester Club, 81 King Street, Manchester, M2 4AH
o. +44 (0)161 413 0590 e. info@umcarchitects.com

RIBA PoW Stage:	2	Revision:	P04
Suitability / Status:	S2		
Drawn / Checked:	MY / DEB		
Date:	17/02/23		
Scale:	As Noted A1		
UMC Project Ref:	22604		
Drawing no:	22604 - UMC - XXXX - SI - DR - A - 0705		