






Proposed Substation Enclosure

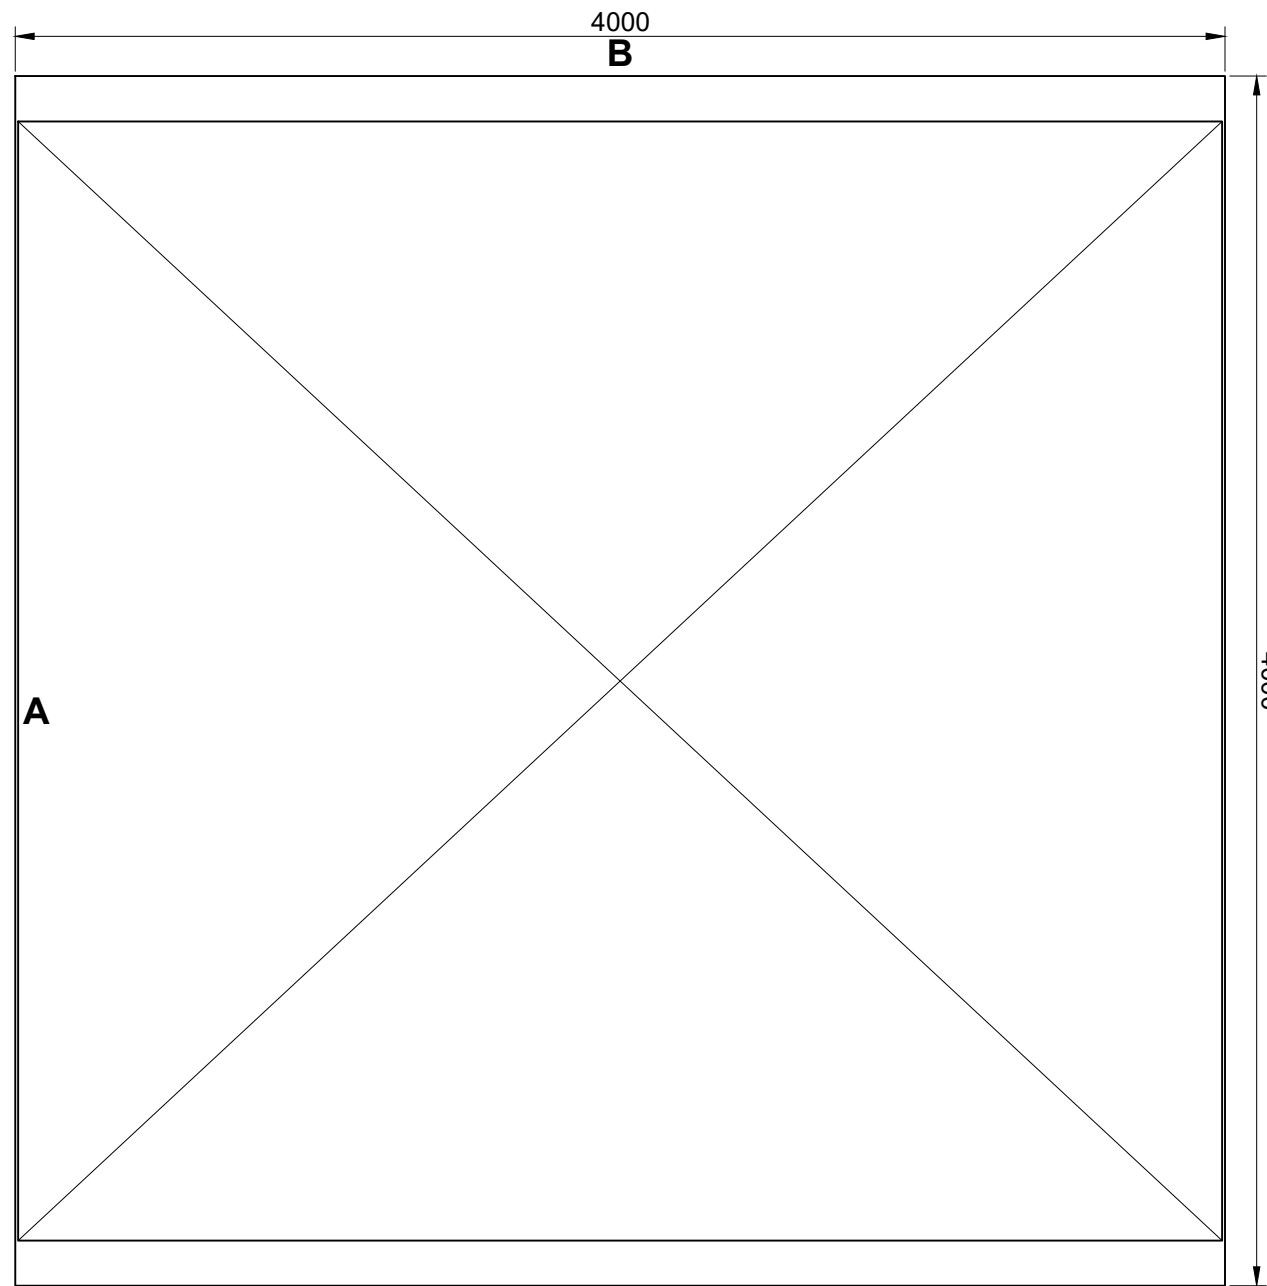


Ring-main Unit/ HV Enclosure Plan Scale 1:25

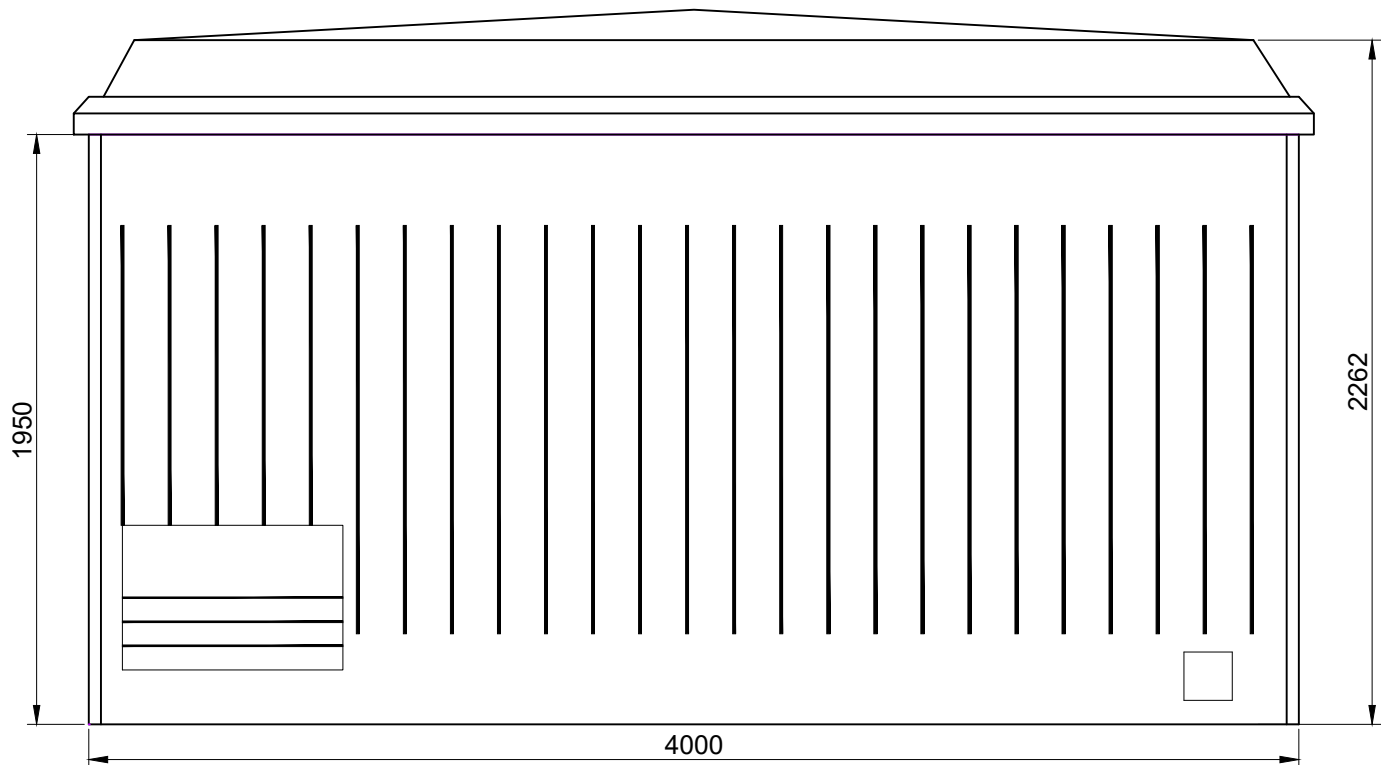


Ring-main Unit/ HV Enclosure Side Elevation A Scale 1:25

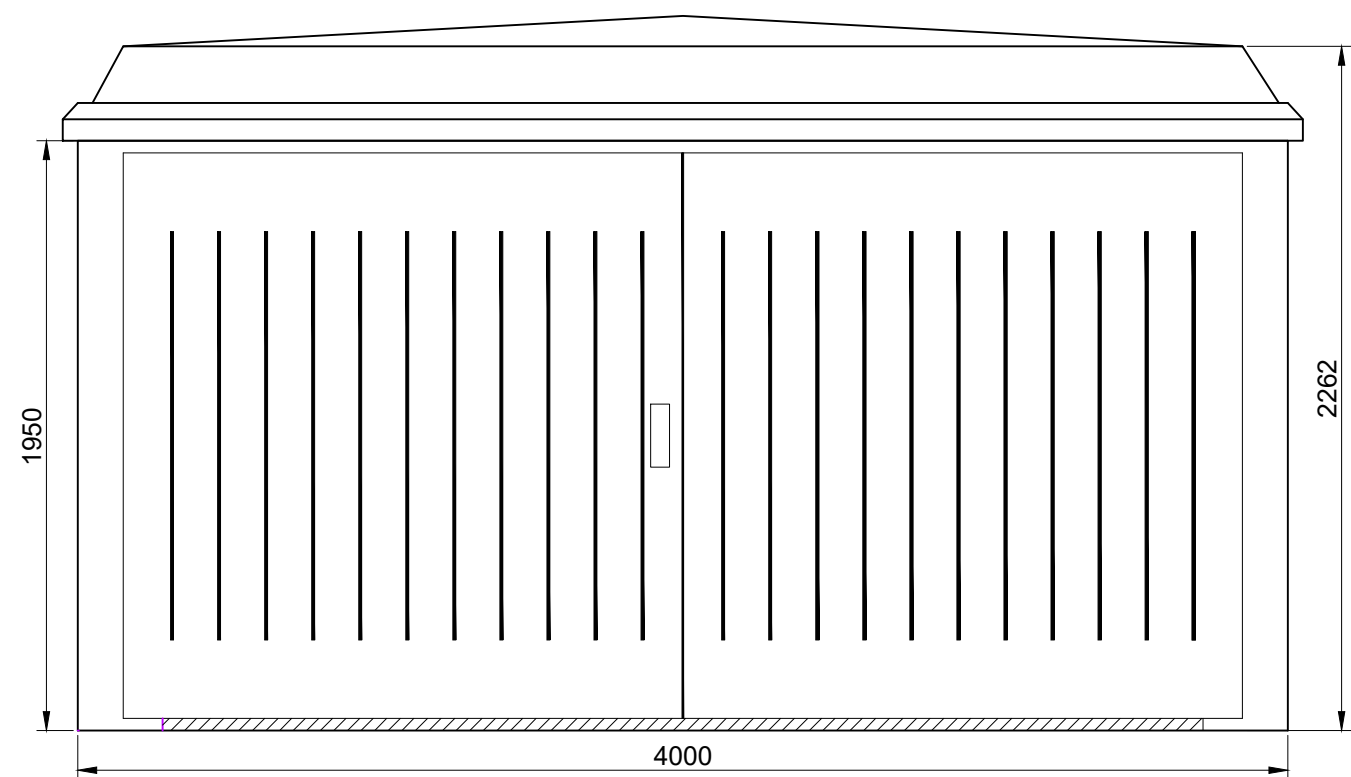

Ring-main Unit/ HV Enclosure Front Elevation B Scale 1:25

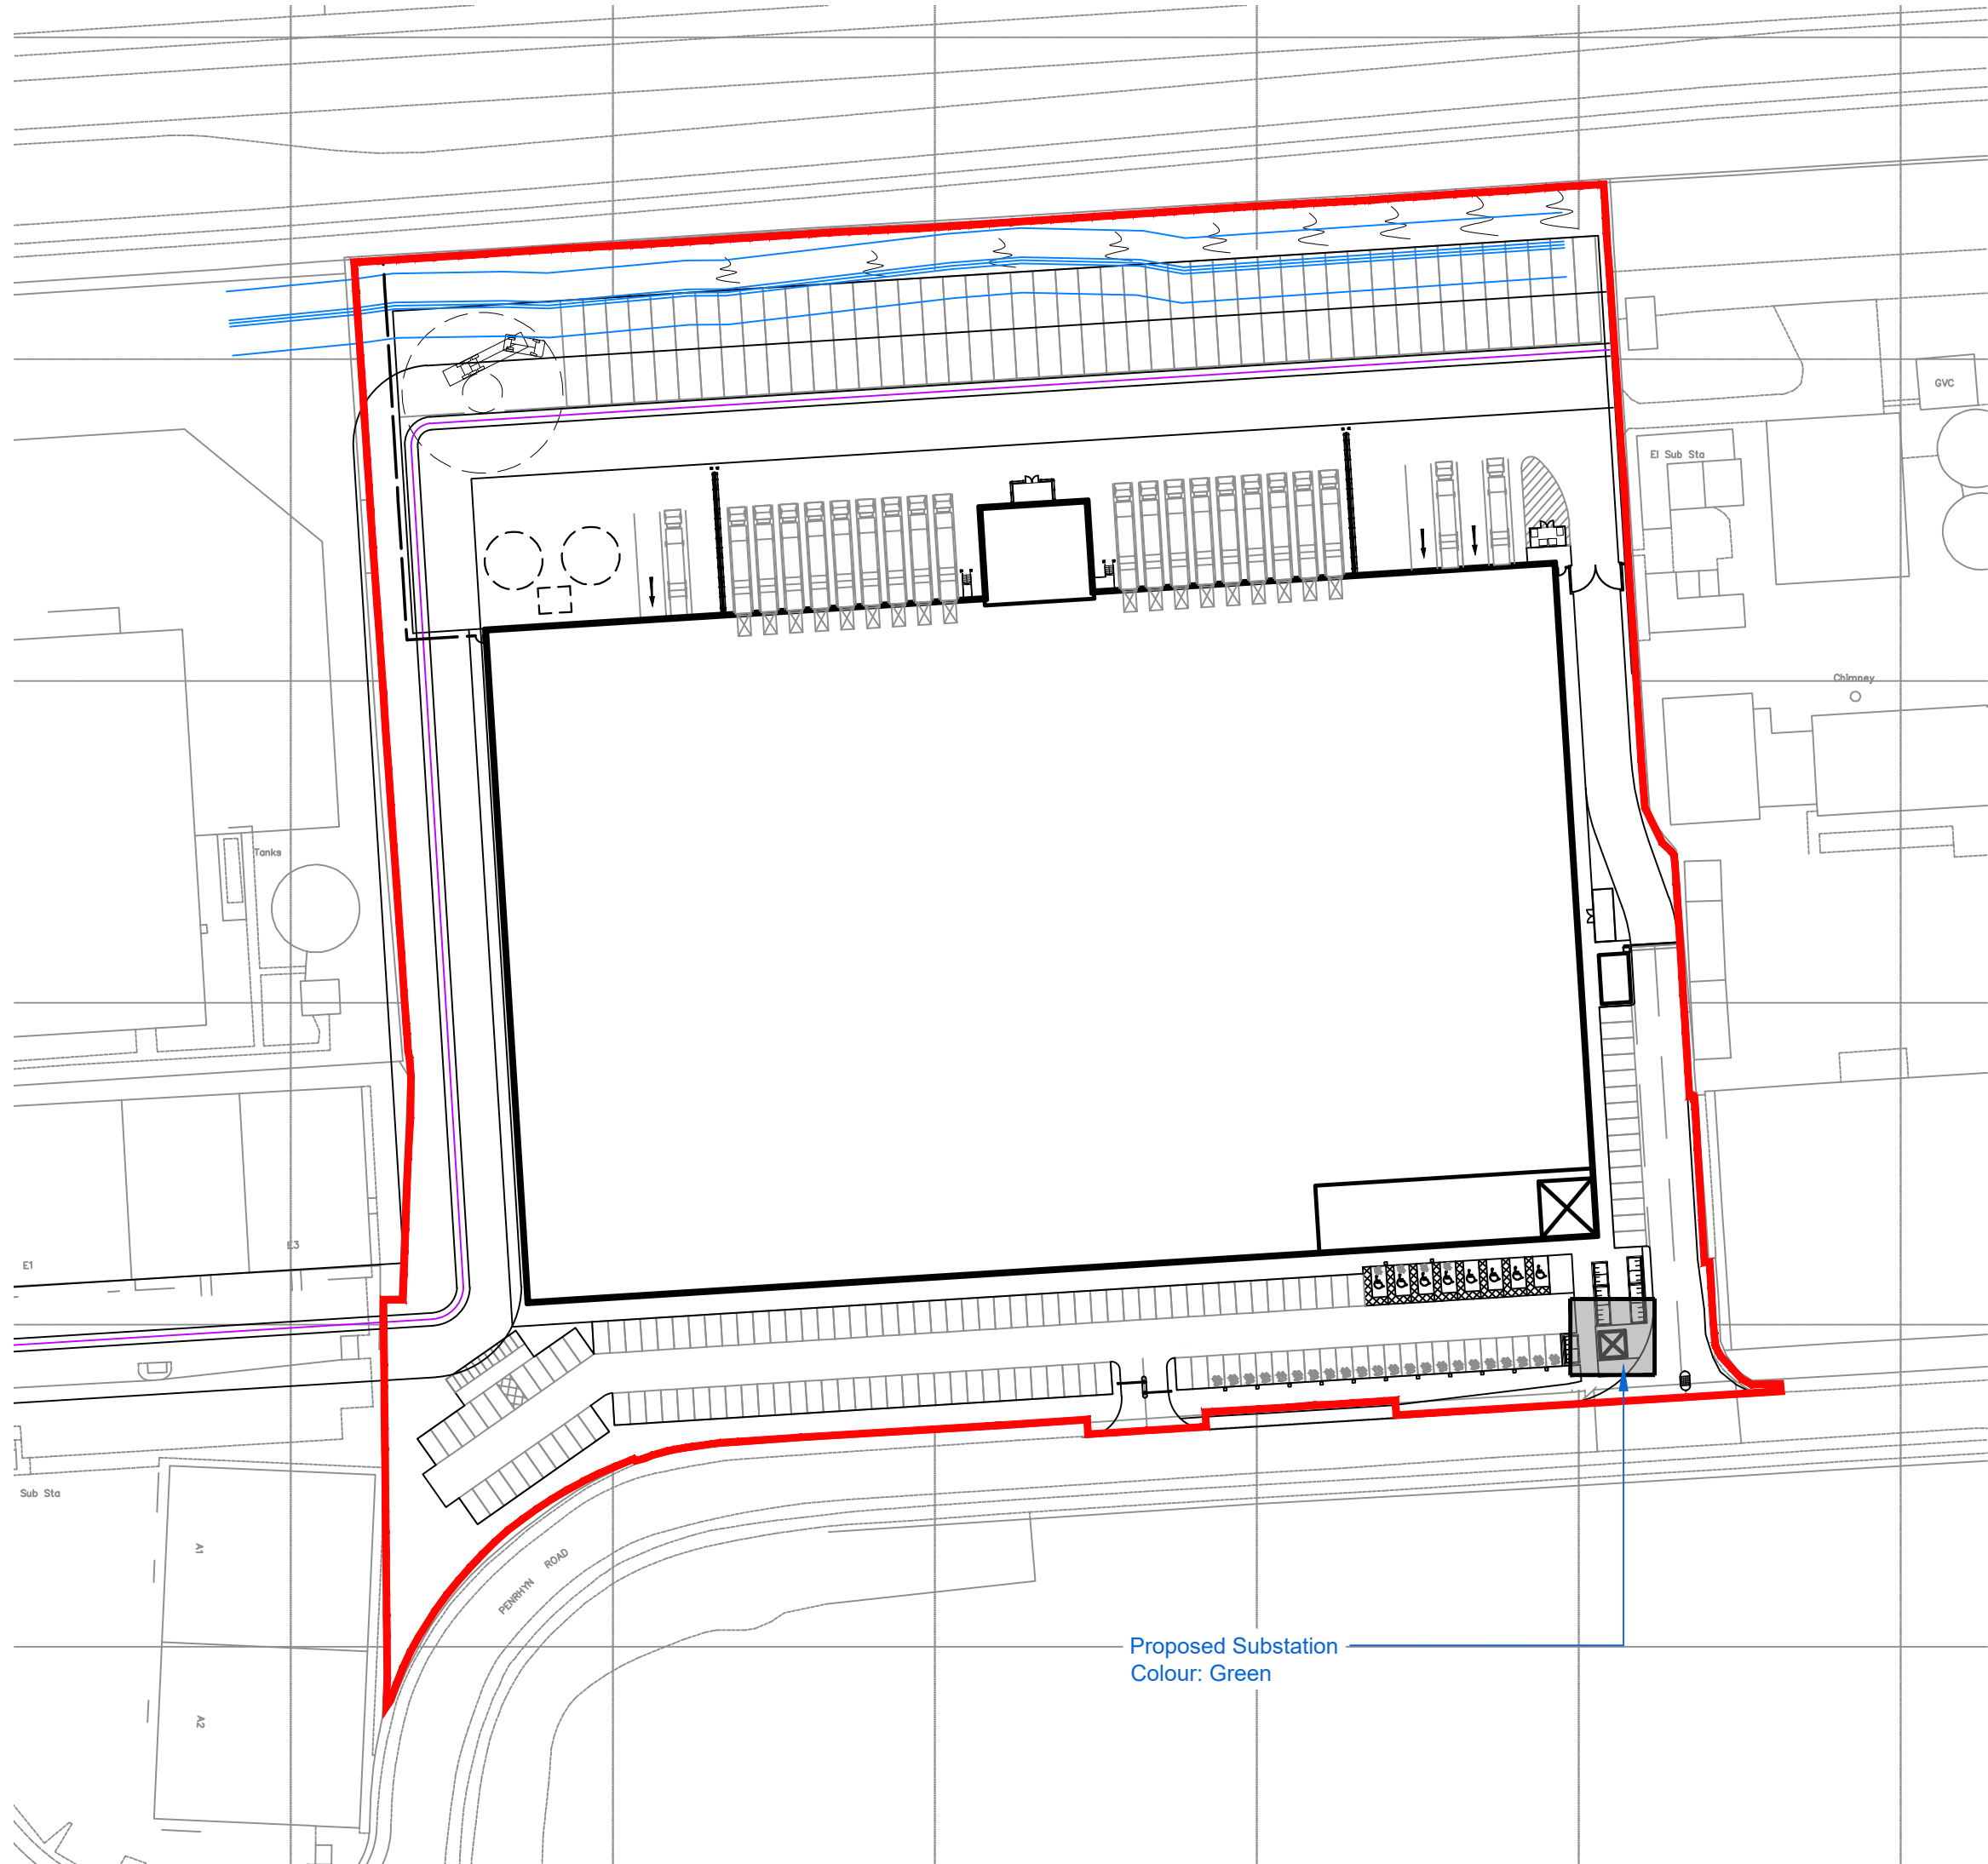

Location Plan Scale 1:1000

 

PLANNING

rev	amendments	by	ckd	date
Penrhyn Road, Knowsley Business Park, Merseyside Proposed Substation Details				
GRAFTONGATE				
Newark Beacon Innovation Centre, Cafferata Way, Newark, Nottinghamshire NG24 2TN o: +44 (0)1636 653027 f: +44 (0)1636 653010 e: info@umcarchitects.com				
Drawing Status:		Planning		
Drawn / Checked:		DEB / DEB		
Date:		06.12.2024		
Scale:		1:1000 @ A1		
Drawing no:		Revision:		
21002 P1007		A		