



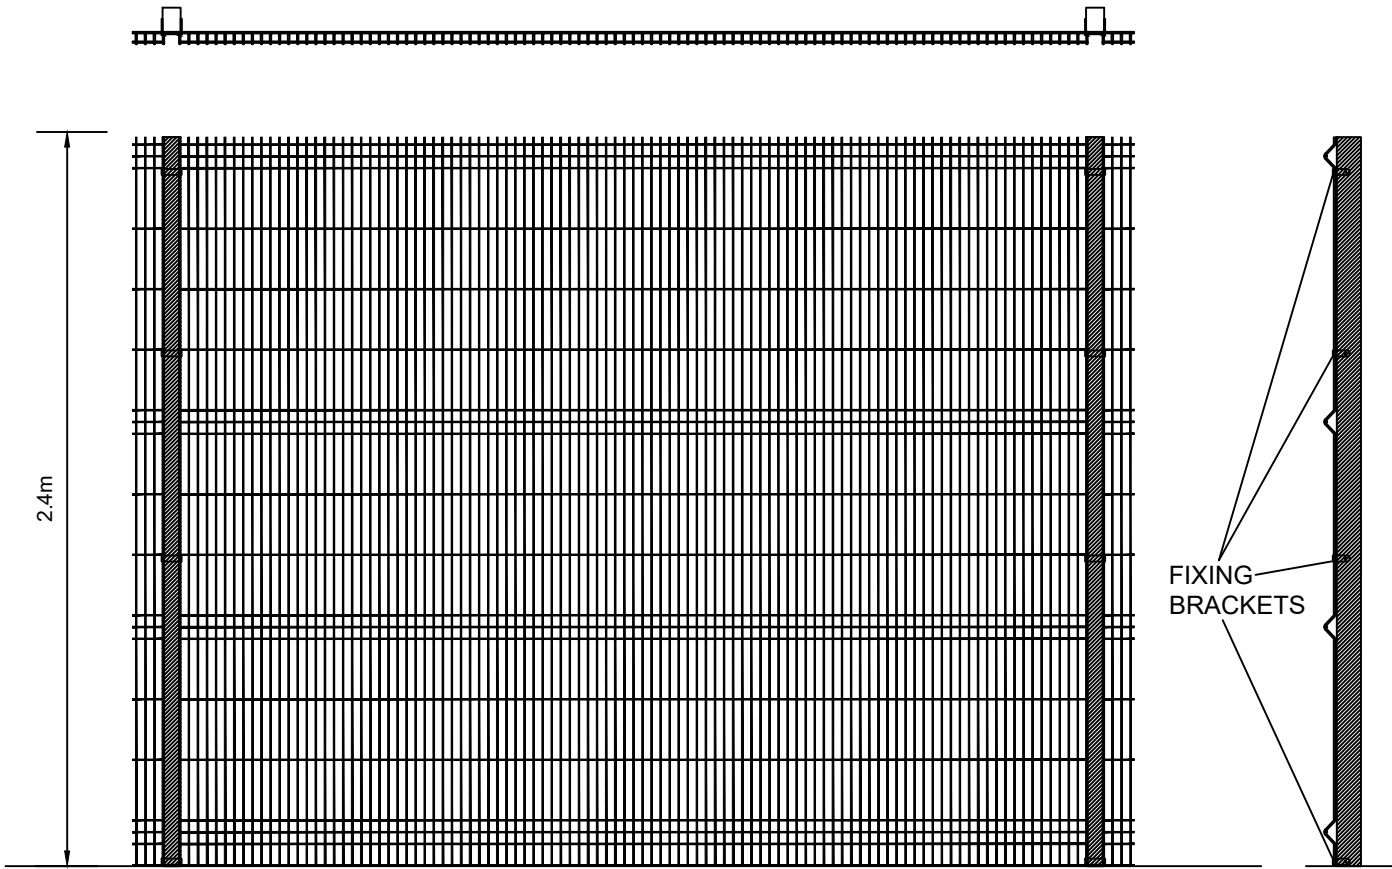


2.4 m Weld Mesh Security Fencing
Scale 1:25@A3

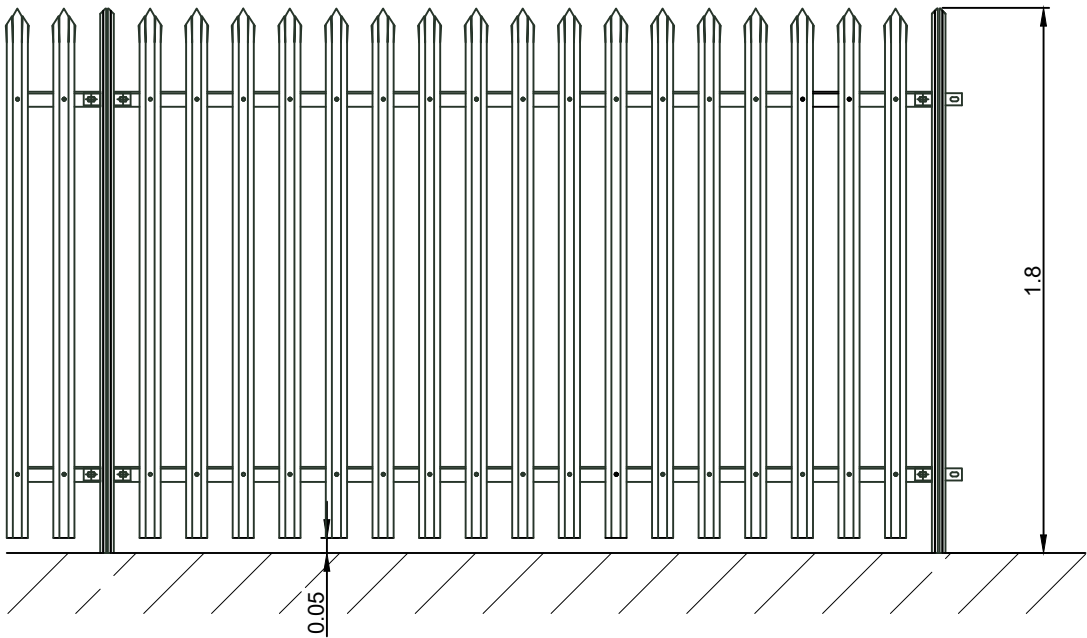


1.8m Palisade Auxiliary Transformer Compound Fence
Scale 1:25@A3

Indicative Lighting positions and dimensions

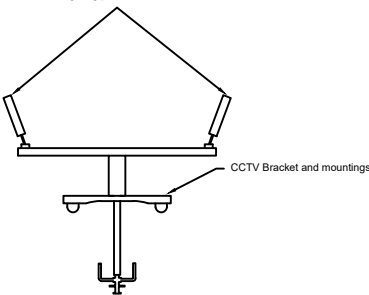


Front Elevation

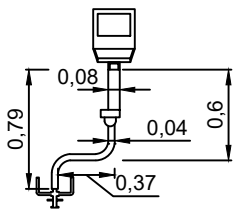

Side Elevation



Example images of bracket in place

 

4m Individual Lighting Columns with CCTV
Scale 1:50@A3

Lighting and CCTV Bracket
Scale 1:50@A3

NOTE: Lighting and CCTV bracket to be fitted to BESS Containers



0344 8700 007
axis.co.uk



Client

Pelagic Energy

Project

Kirkby BESS

Drawing Title

Fencing and Security

Scale

1:25 @A3

Date

June 2026

Dwg no

2569-02-009

Status

--

Drawn

SK

Checked

JMg

Rev

E