




50-PERSON COVERED STAND

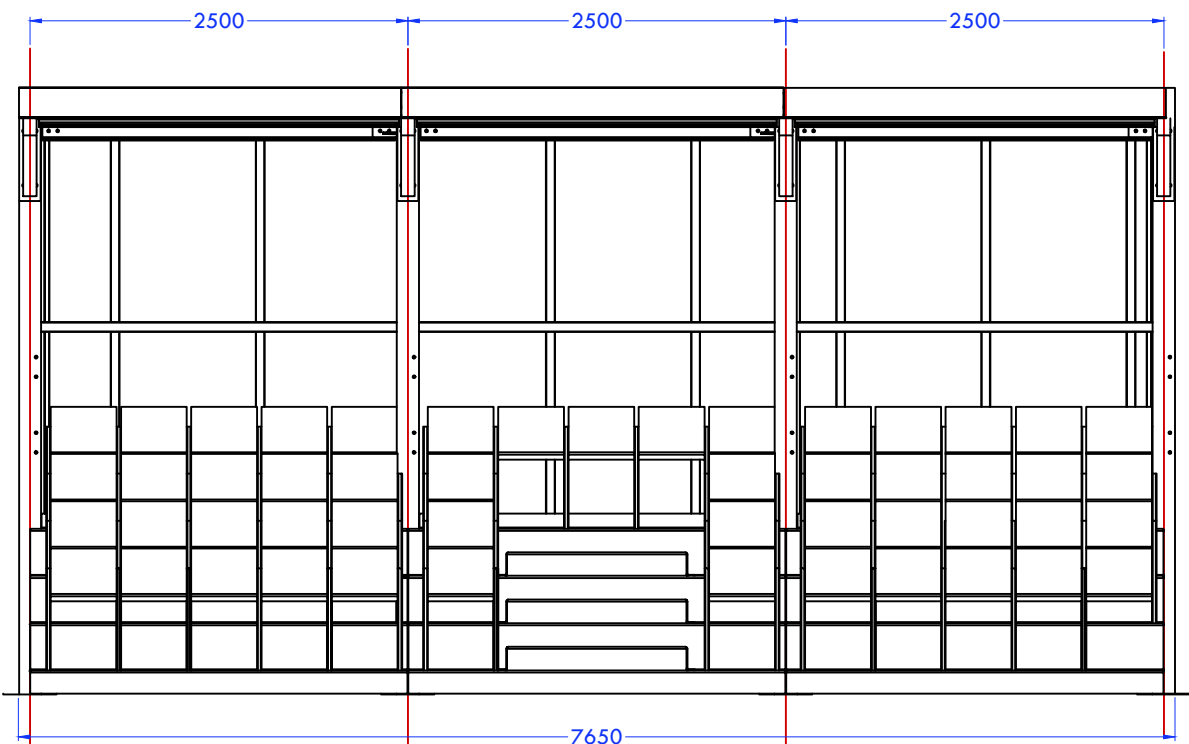

STAND ELEVATION

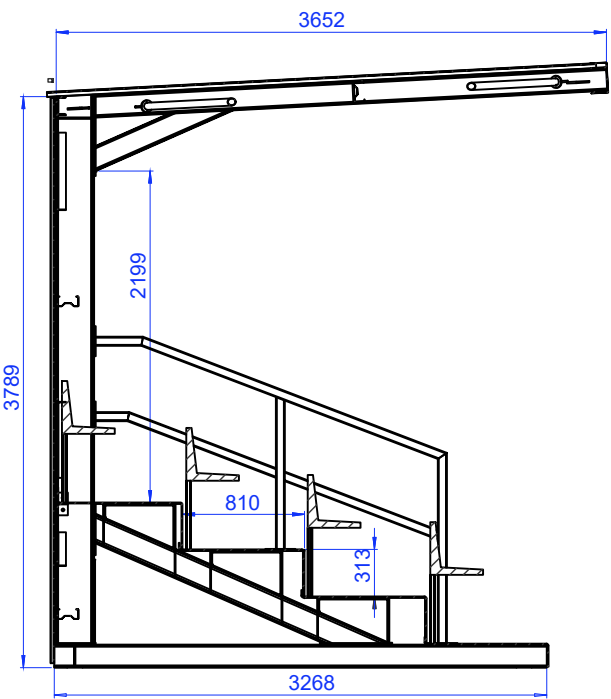

STAND SECTION

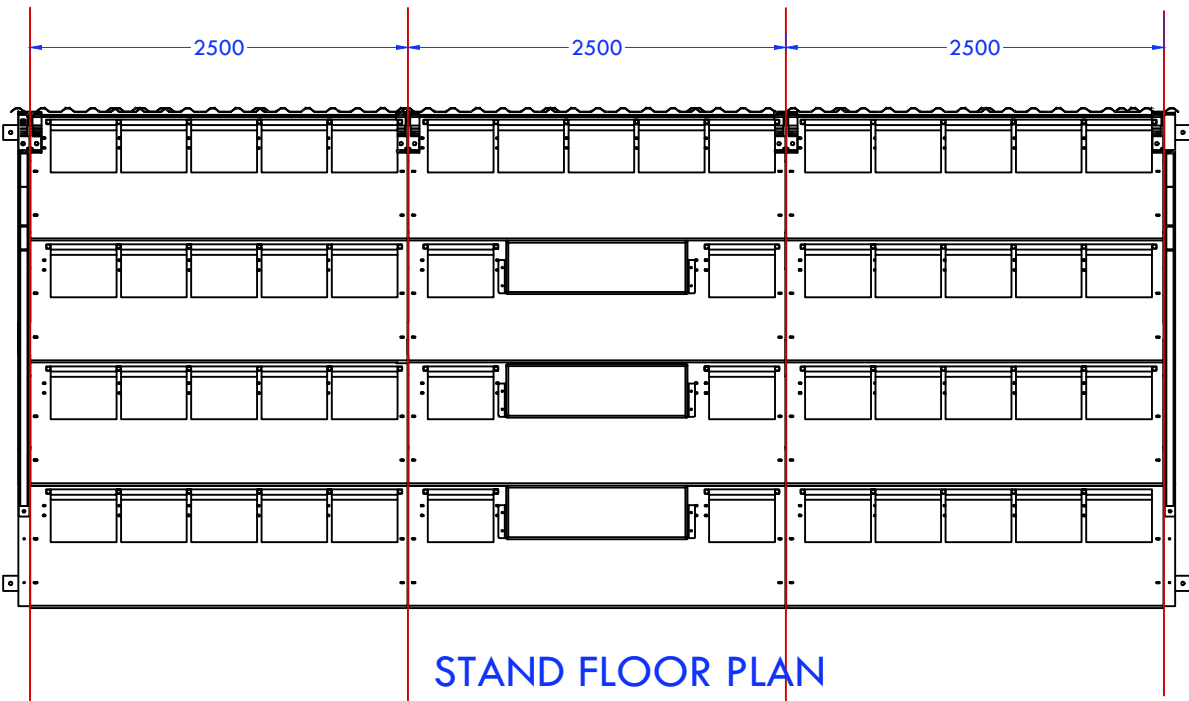

STAND FLOOR PLAN

	Rev	Amendments	Date	
 mkw Architecture structural • civil • mechanical • electrical	Project Title: Proposed Public Stands and Floodlight			
	Client: AFC Knowsley CIC			
	Site Address: AFC Knowsley, Lord Derby Pavilion, Knowsley	Postcode: L34 7HD		
	Drawing Sheet: Proposed Stand Drawings			
	Drawing Status: Planning			
	Proj No: 26-311	Dwg No: P-203	Scale: 1:50 @ A3	Rev: 00
	Designed By: TMK	Drawn By: RK	Checked By: MKWA	Date of 1st Issue: 05.03.2026
	Only figured dimensions are to be used. All dimensions to be checked on site prior to construction, order or manufacture of any element. In the event of any discrepancy, notify MKW Architecture Ltd immediately. This drawing remains the copyright of MKW Architecture Ltd and shall not be copied in whole or part without prior written consent of the Company Director.			
	MKW Architecture Ltd Suite 51, Earl Business Centre, Dowry St, Oldham, OL8 2PF T: +44(0)1932925999 E: info@mkwarchitecture.com W: www.mkwarchitecture.com			



mkw:architecture
architectural design | interior design | landscape design | planning practice

