



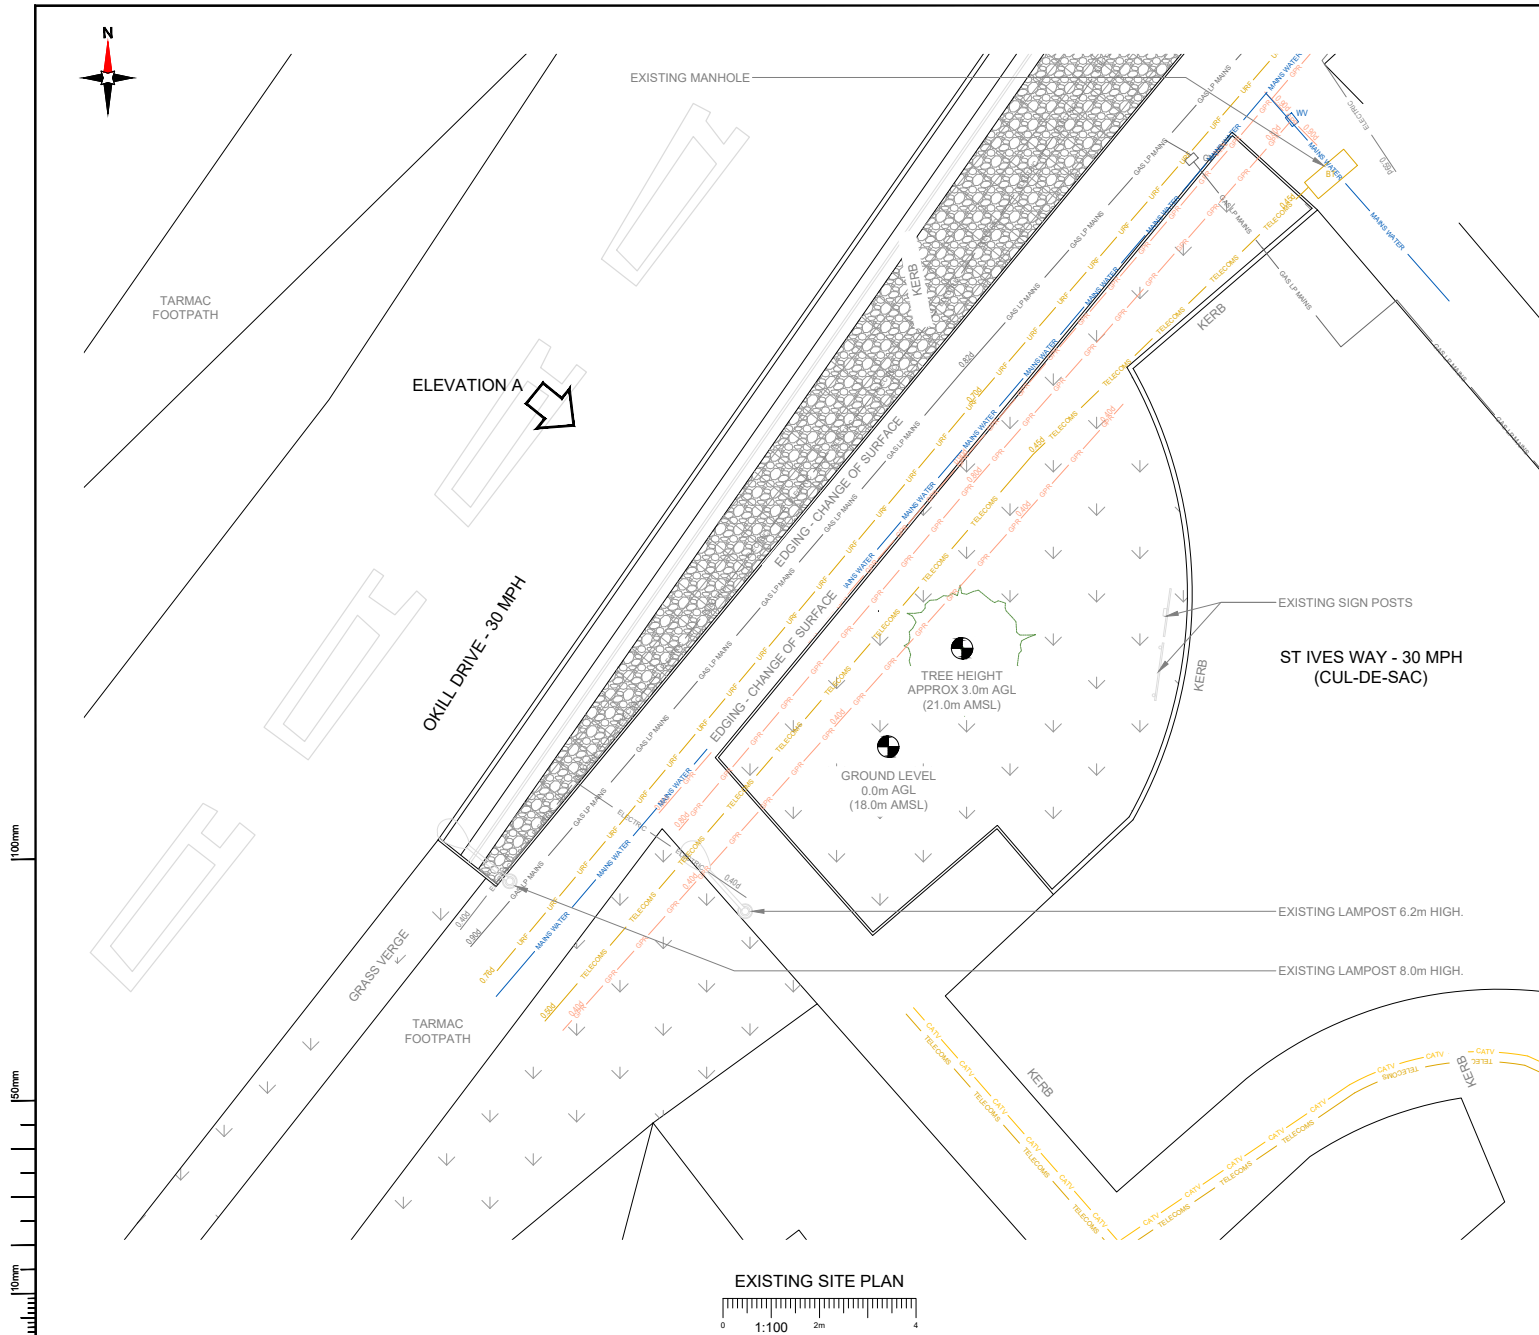

NOTES:

1. ALL DIMENSIONS IN MM UNLESS OTHERWISE NOTED.

SERVICES:

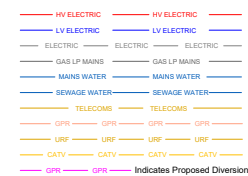

Master	MBNL Cell ID	Project	Proposed Cell ID	Issue
M001	H3G	DENSIFICATION SW	Planning	A
Date	30.03.2023	Revision / Signature Description:		
Drawn	D.Green	First Issue		
Checked	R.Brown			
Approved	R.Brown			



Hutchison 3G UK Limited
Green Park, 450 Longwater Avenue
Reading, RG30 3UR
Tel: 01628 785 000
Fax: 01628 785 001

H3G Base Station Information line:
0845 6043000
Available 8am-8pm Monday to Friday

Design Consultant & Principal Contractor:

CLARKE
telecom
Unit E, Madison Place, Northampton Road,
Manchester, M40 5AG
Tel: 0161 785 4500 Fax: 0161 785 4501
Web: www.clarke-telecom.com

Site Name:

OKELL DRIVE

Site ID:

KSY25764

Address:

OKELL DRIVE
HALEWOOD
LIVERPOOL
MERSEYSIDE
L26 7YW

Title:

100 EXISTING SITE PLAN

Project:

H3G DENSIFICATION STREETWORKS

Purpose of Issue:

PLANNING

Master Drawing No:

MBNL Cell ID:
N/A

3UK Cell ID:
N/A

KSY25764_M001_H3G_DNSW_GA_A


Issue:

A

100mm

50mm

10mm

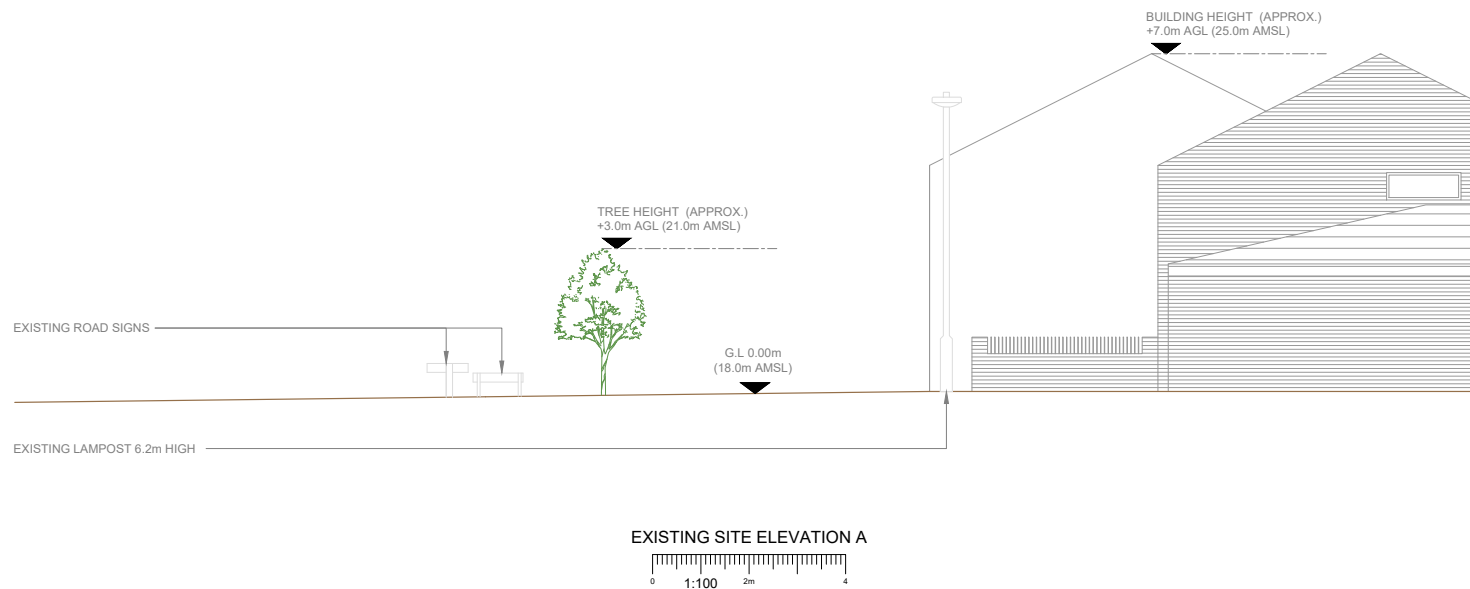

NOTES:

- ALL DIMENSIONS IN MM UNLESS OTHERWISE NOTED.

Sheet	MBNL Cell ID	Project	Purpose of Issue	Issue
M001	H3G	DENSIFICATION SW	Planning	A
Date	30.03.2023	Revision / Describe Description:		
Drawn	D.Green	First Issue		
Checked	R.Brown			
Approved	R.Brown			



Hutchison 3G UK Limited
Green Park, 450 Longwater Avenue
Reading, RG30 3UR
Tel: 01628 785 000
Fax: 01628 785 001

H3G Base Station Information line:
0845 6043000
Available 8am-8pm Monday to Friday

Design Consultant & Principal Contractor:

CLARKE
telecom
Unit E, Madison Place, Northampton Road,
Manchester, M40 5AG
Tel: 0161 785 4500 Fax: 0161 785 4501
Web: www.clarke-telecom.com

Site Name:

OKELL DRIVE

Site ID:

KSY25764

Address:

OKELL DRIVE
HALEWOOD
LIVERPOOL
MERSEYSIDE
L26 7YW

Title:

150 EXISTING SITE ELEVATION A

Project:

H3G DENSIFICATION STREETWORKS

Purpose of Issue:

PLANNING


MBNL Cell ID:	3UK Cell ID:
N/A	N/A

Master Drawing No:

KSY25764_M001_H3G_DNSW_GA_A

Issue:

A

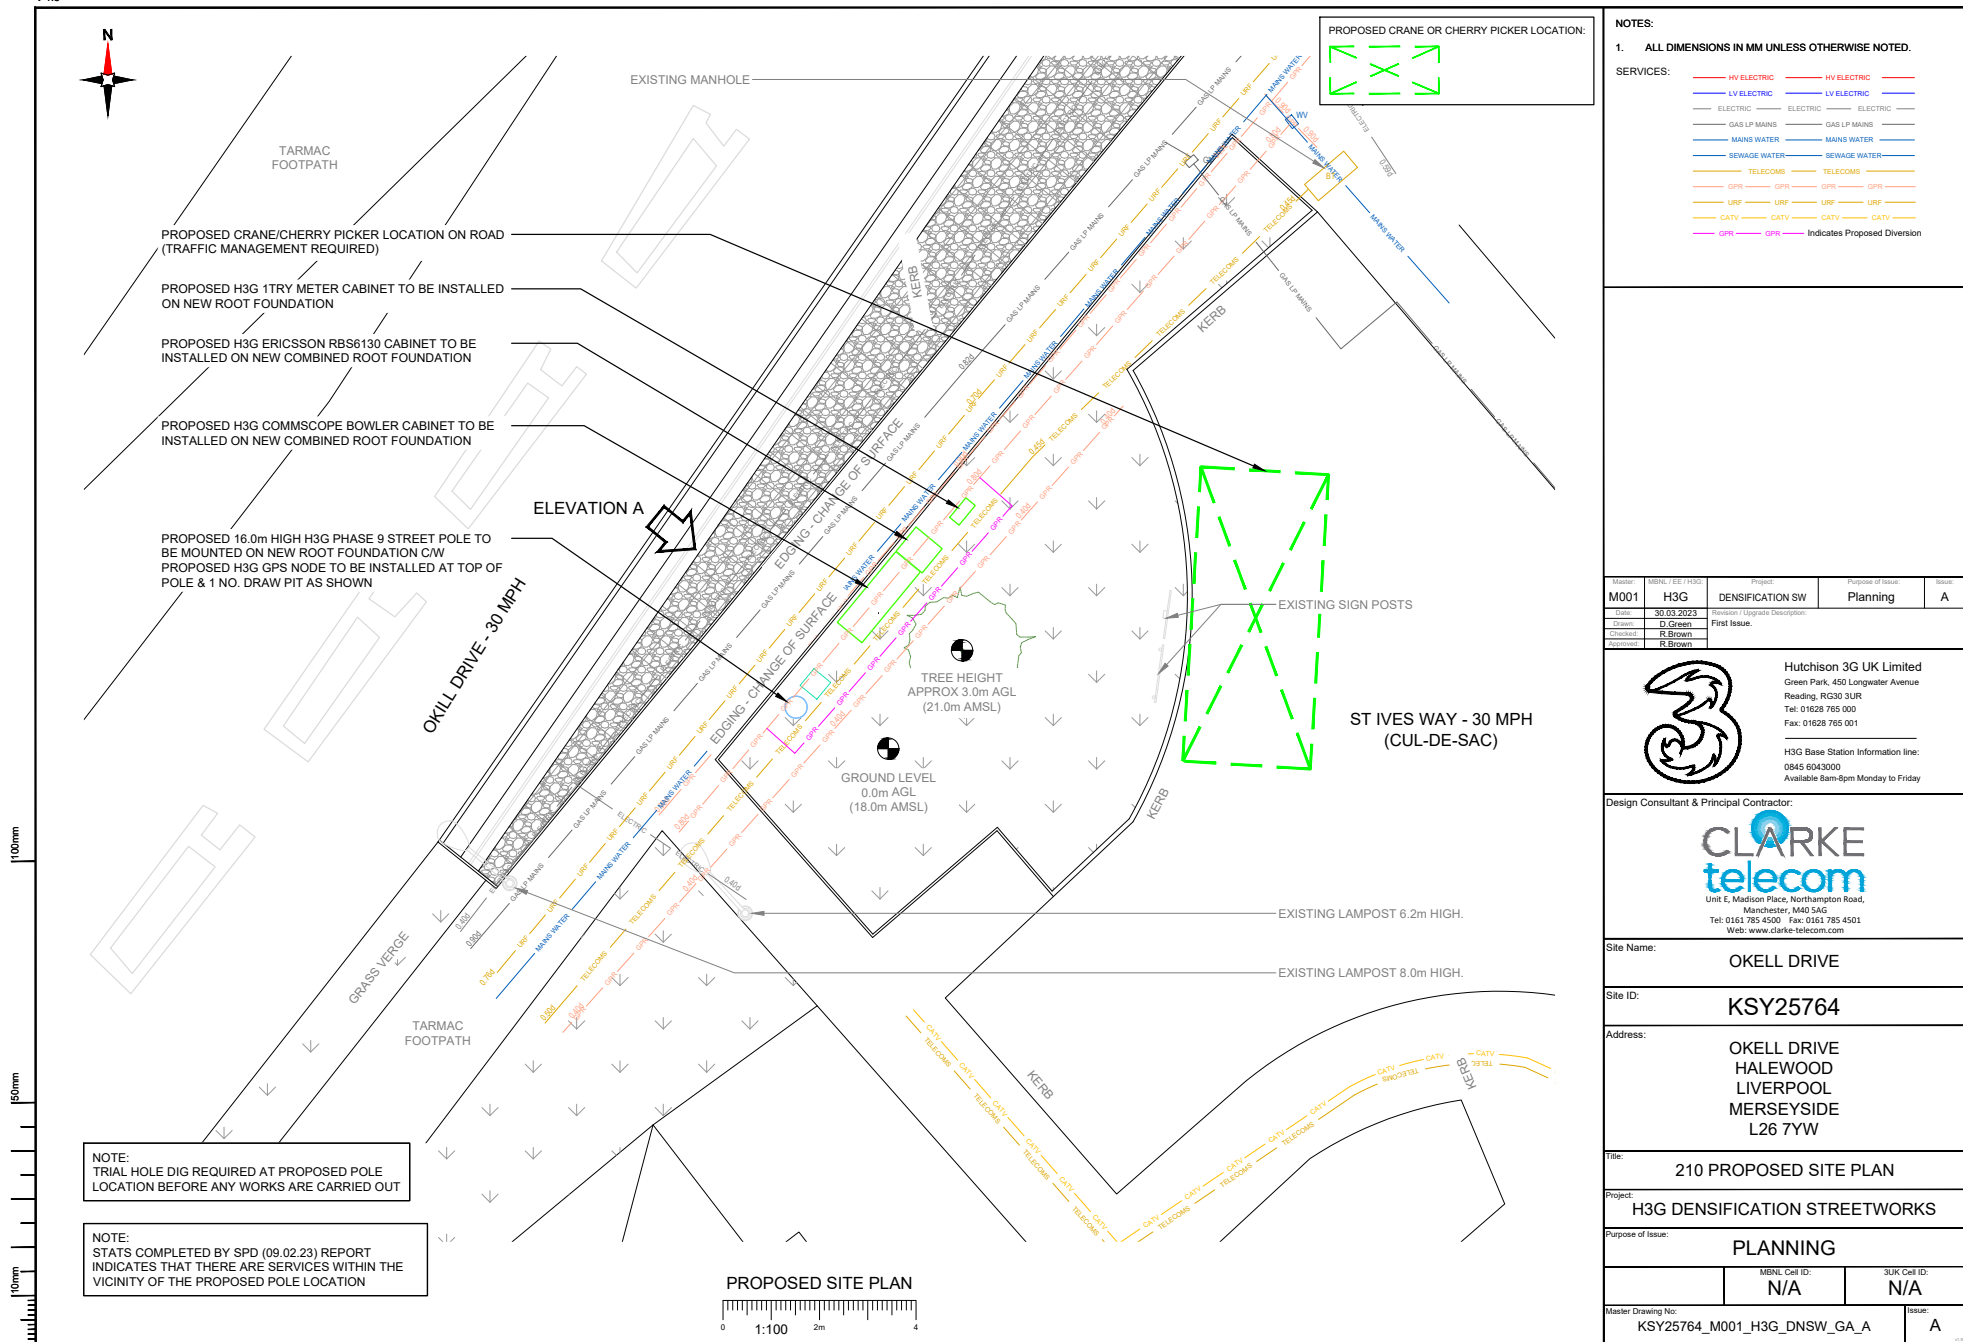

NOTES:

1. ALL DIMENSIONS IN MM UNLESS OTHERWISE NOTED.

SERVICES:

— HV ELECTRIC — HV ELECTRIC —

— LV ELECTRIC — LV ELECTRIC —

— ELECTRIC — ELECTRIC —

— GAS LP MAINS — GAS LP MAINS —

— MAINS WATER — MAINS WATER —

— SEWAGE WATER — SEWAGE WATER —

— TELECOMS — TELECOMS —

— GPR — GPR —

— URF — URF —

— CATV — CATV —

— GPR — GPR — Indicates Proposed Diversion

Master	Project	Project	Project	Issue
M001	H3G	DENSIFICATION SW	Planning	A
Drawn	30.03.2023	First Issue		
Checked	R.Brown			
Approved	R.Brown			



Hutchison 3G UK Limited
Green Park, 450 Longwater Avenue
Reading, RG30 3UR
Tel: 01628 785 000
Fax: 01628 785 001

H3G Base Station Information line:
0845 6043000
Available 8am-8pm Monday to Friday

Design Consultant & Principal Contractor:

CLARKE
telecom
Unit E, Madison Place, Northampton Road,
Manchester, M40 5AG
Tel: 0161 785 4500 Fax: 0161 785 4501
Web: www.clarke-telecom.com

Site Name:

OKELL DRIVE

Site ID:

KSY25764

Address:

OKELL DRIVE
HALEWOOD
LIVERPOOL
MERSEYSIDE
L26 7YW

Title:

210 PROPOSED SITE PLAN

Project:

H3G DENSIFICATION STREETWORKS

Purpose of Issue:


PLANNING

Master Drawing No:

KSY25764_M001_H3G_DNSW_GA_A

Issue:

A

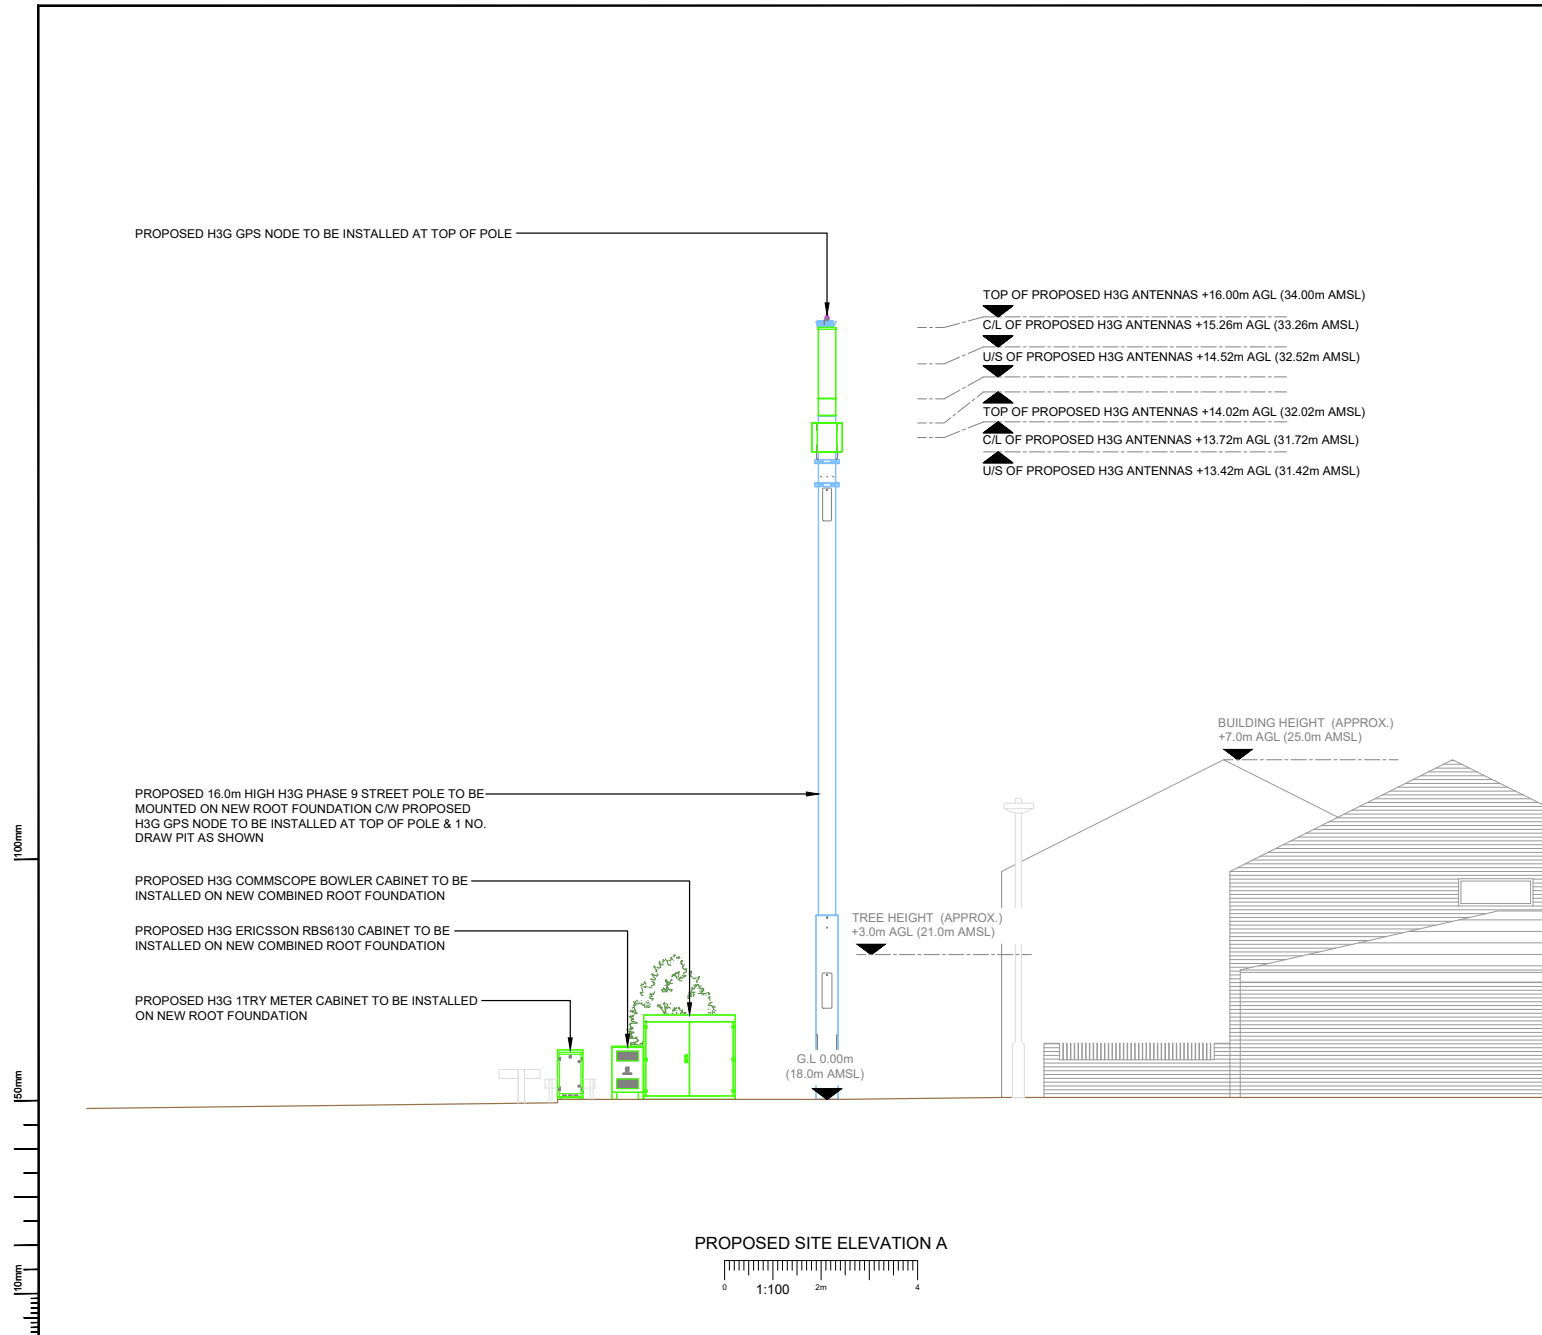

NOTES:

- ALL DIMENSIONS IN MM UNLESS OTHERWISE NOTED.

Sheet	MBNL Cell ID	Project	Purpose of Issue	Issue
M001	H3G	DENSIFICATION SW	Planning	A
Date	30.03.2023	Revision / Update Description:		
Drawn	D.Green	First Issue		
Checked	R.Brown			
Approved	R.Brown			



Hutchison 3G UK Limited
 Green Park, 450 Longwater Avenue
 Reading, RG30 3UR
 Tel: 01628 785 000
 Fax: 01628 785 001

H3G Base Station Information line:
 0845 6043000
 Available 8am-8pm Monday to Friday

Design Consultant & Principal Contractor:



Unit E, Madison Place, Northampton Road,
 Manchester, M40 5AG
 Tel: 0161 785 4500 Fax: 0161 785 4501
 Web: www.clarke-telecom.com

Site Name:

OKELL DRIVE

Site ID:

KSY25764

Address:

OKELL DRIVE
 HALEWOOD
 LIVERPOOL
 MERSEYSIDE
 L26 7YW

Title:

260 PROPOSED SITE ELEVATION A

Project:

H3G DENSIFICATION STREETWORKS

Purpose of Issue:

PLANNING

MBNL Cell ID	3UK Cell ID
N/A	N/A

Master Drawing No:

KSY25764_M001_H3G_DNSW_GA_A

Issue:

A