


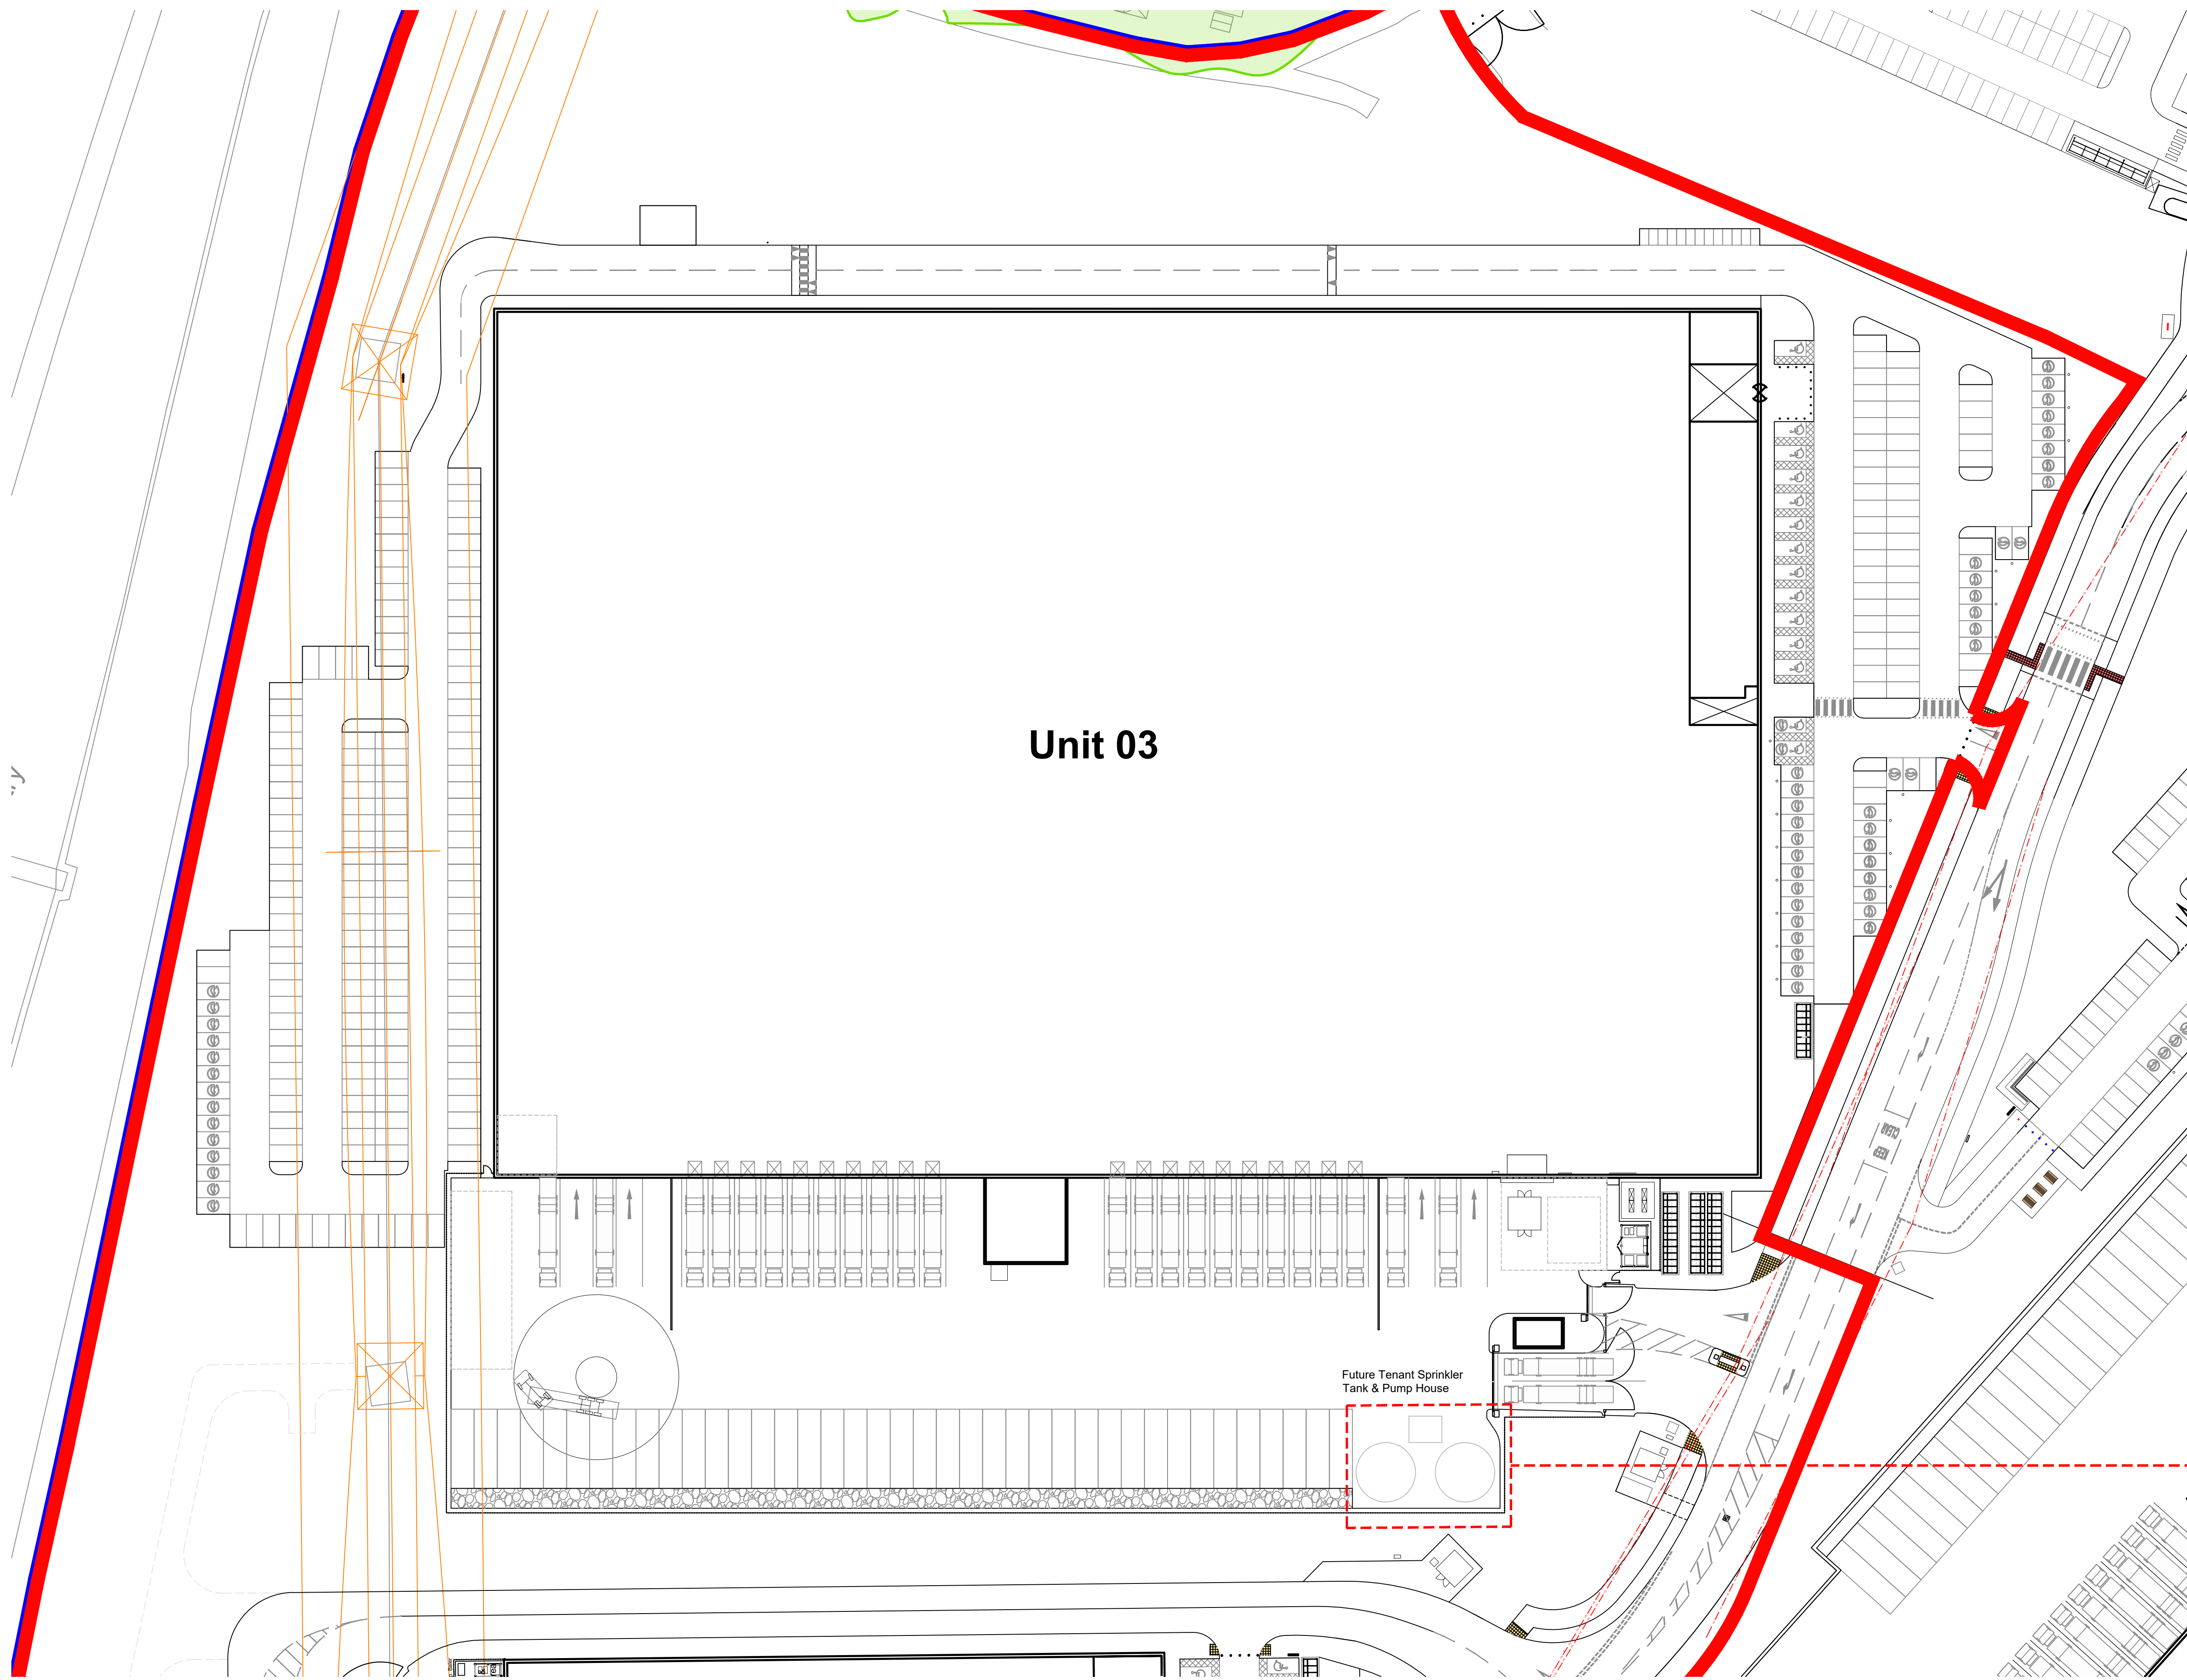
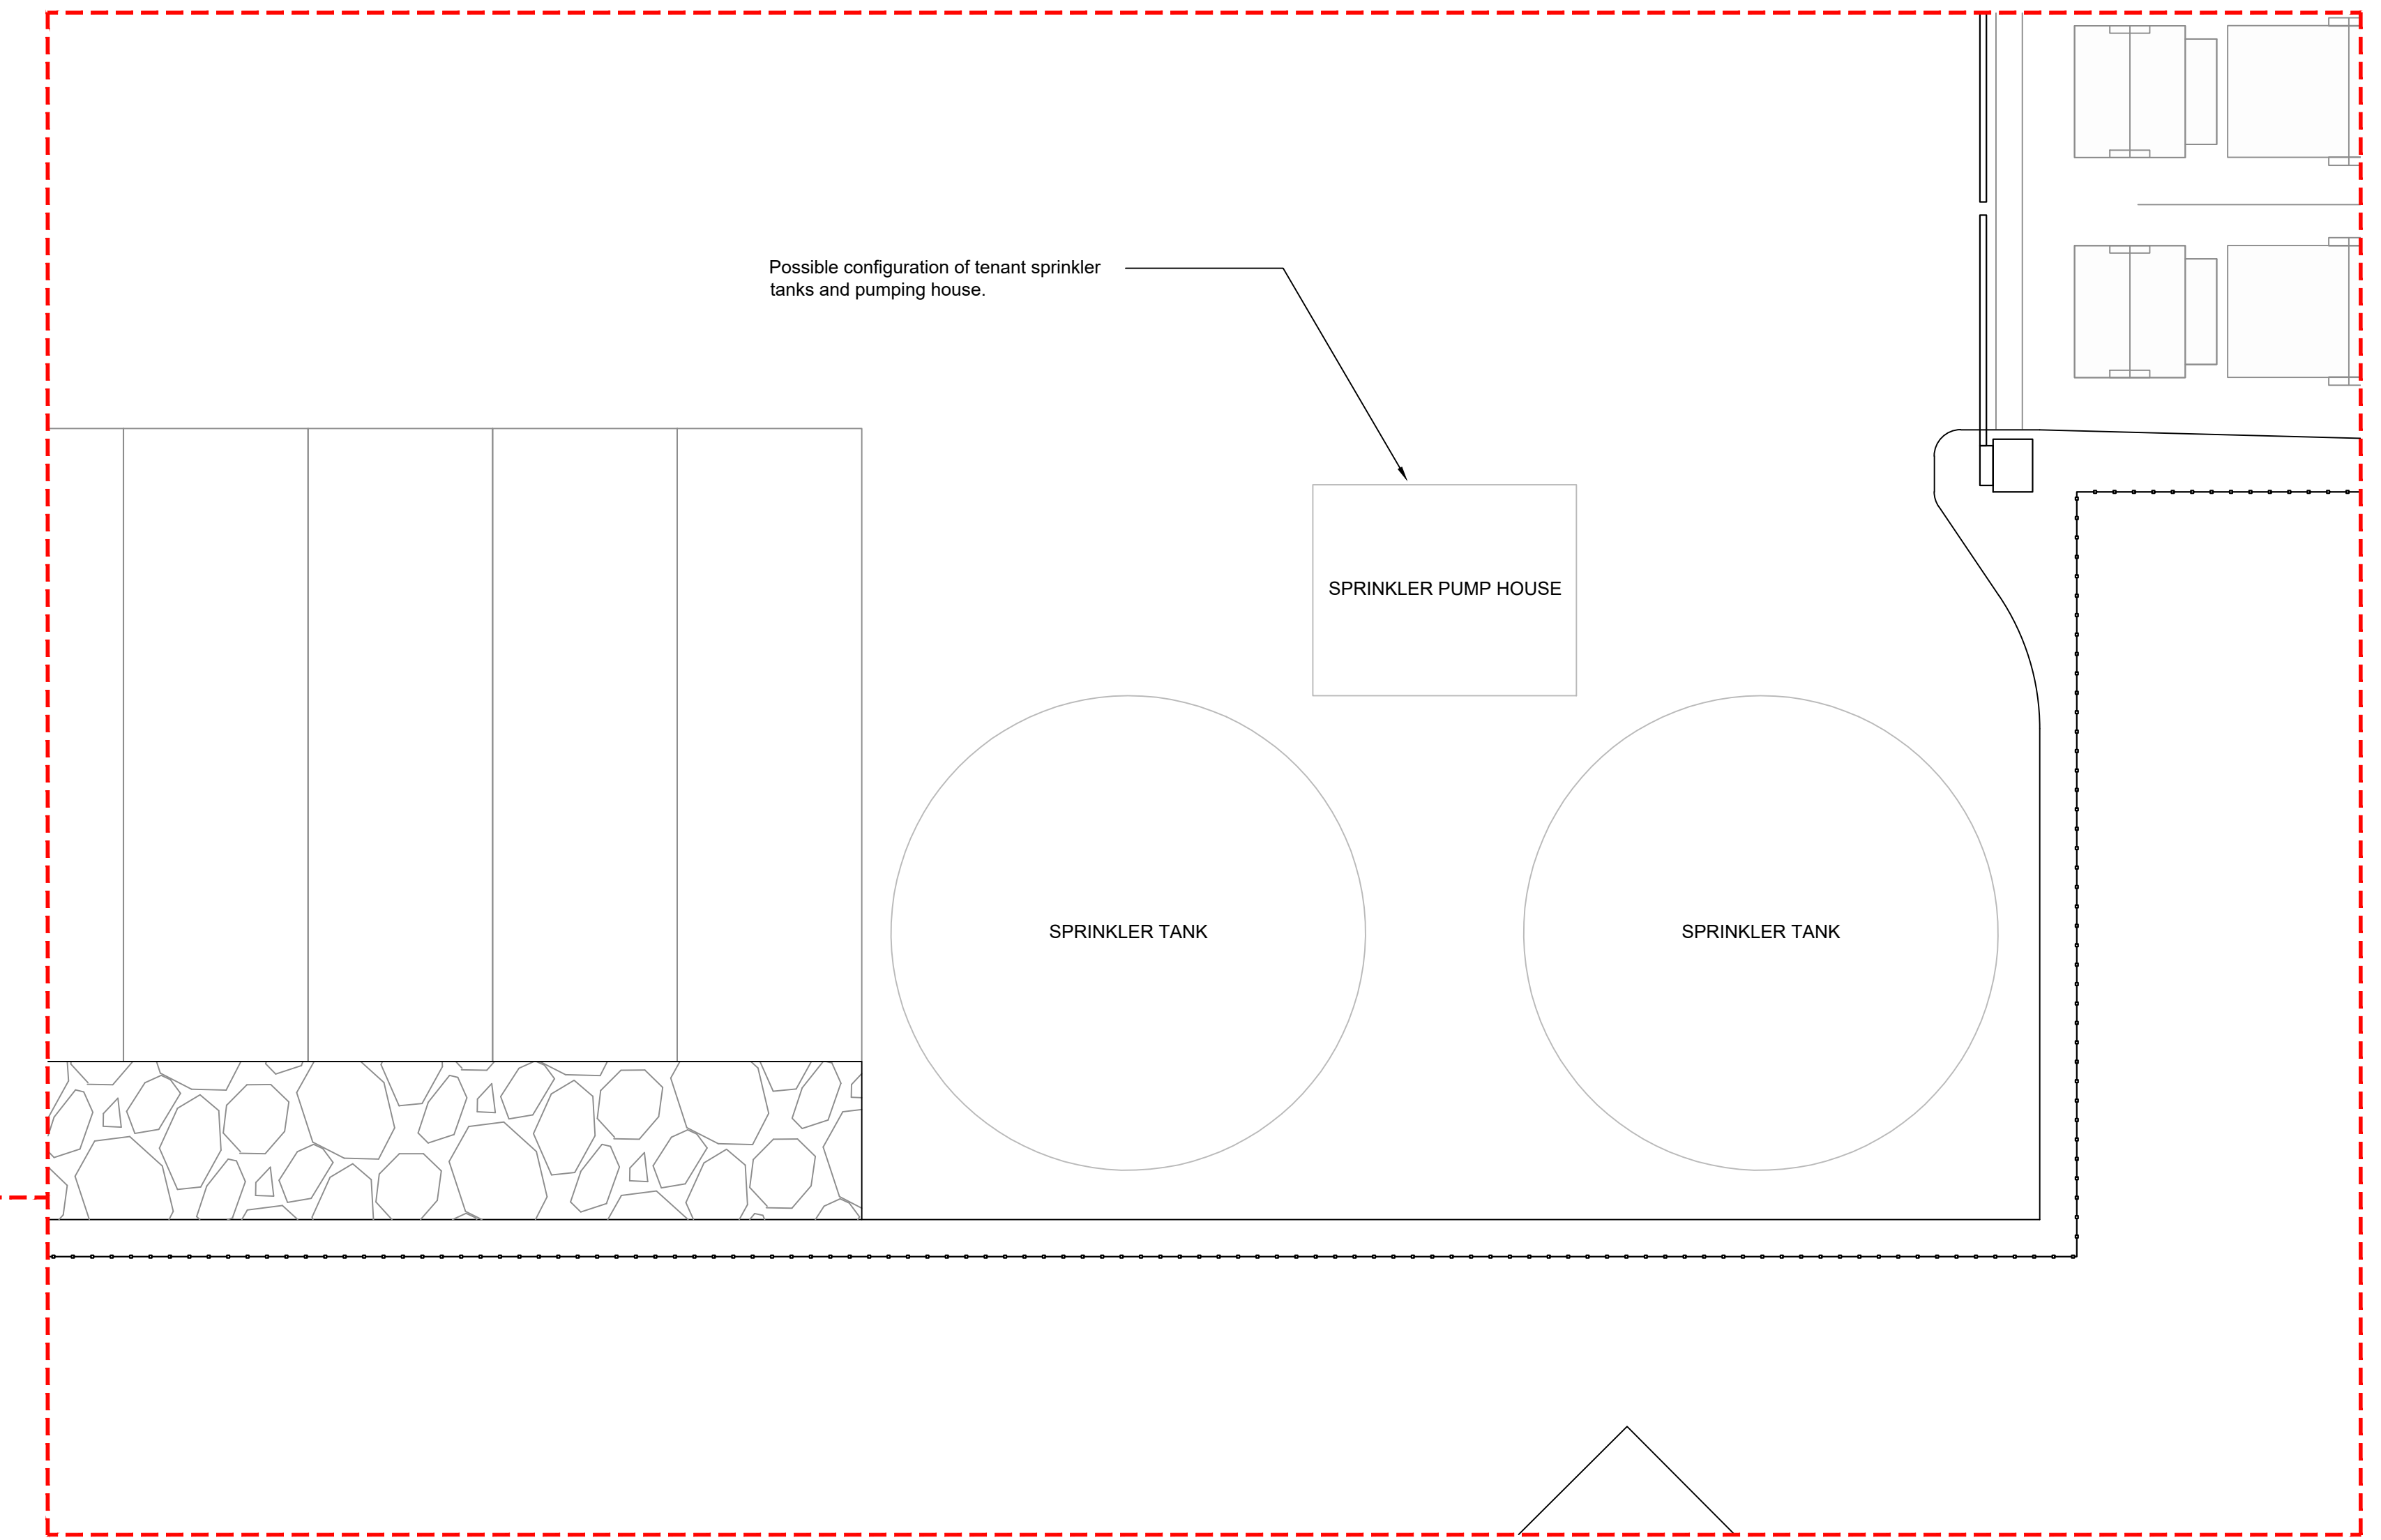


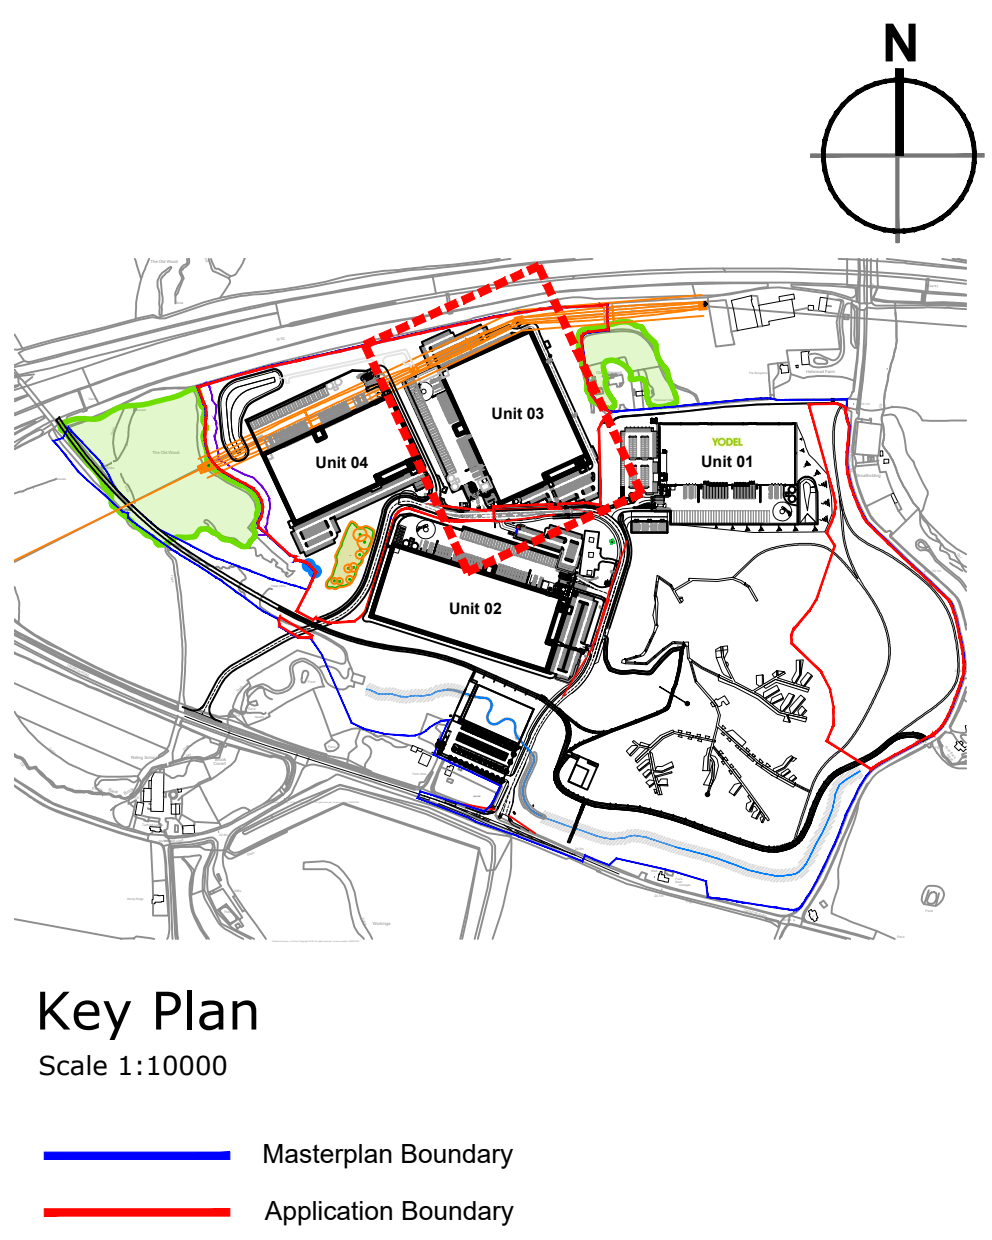


Unit 03 Site Plan
Scale 1:500

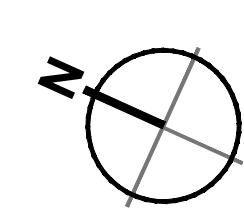

Potential Sprinkler Tank and Pump House Layout
Scale 1:100

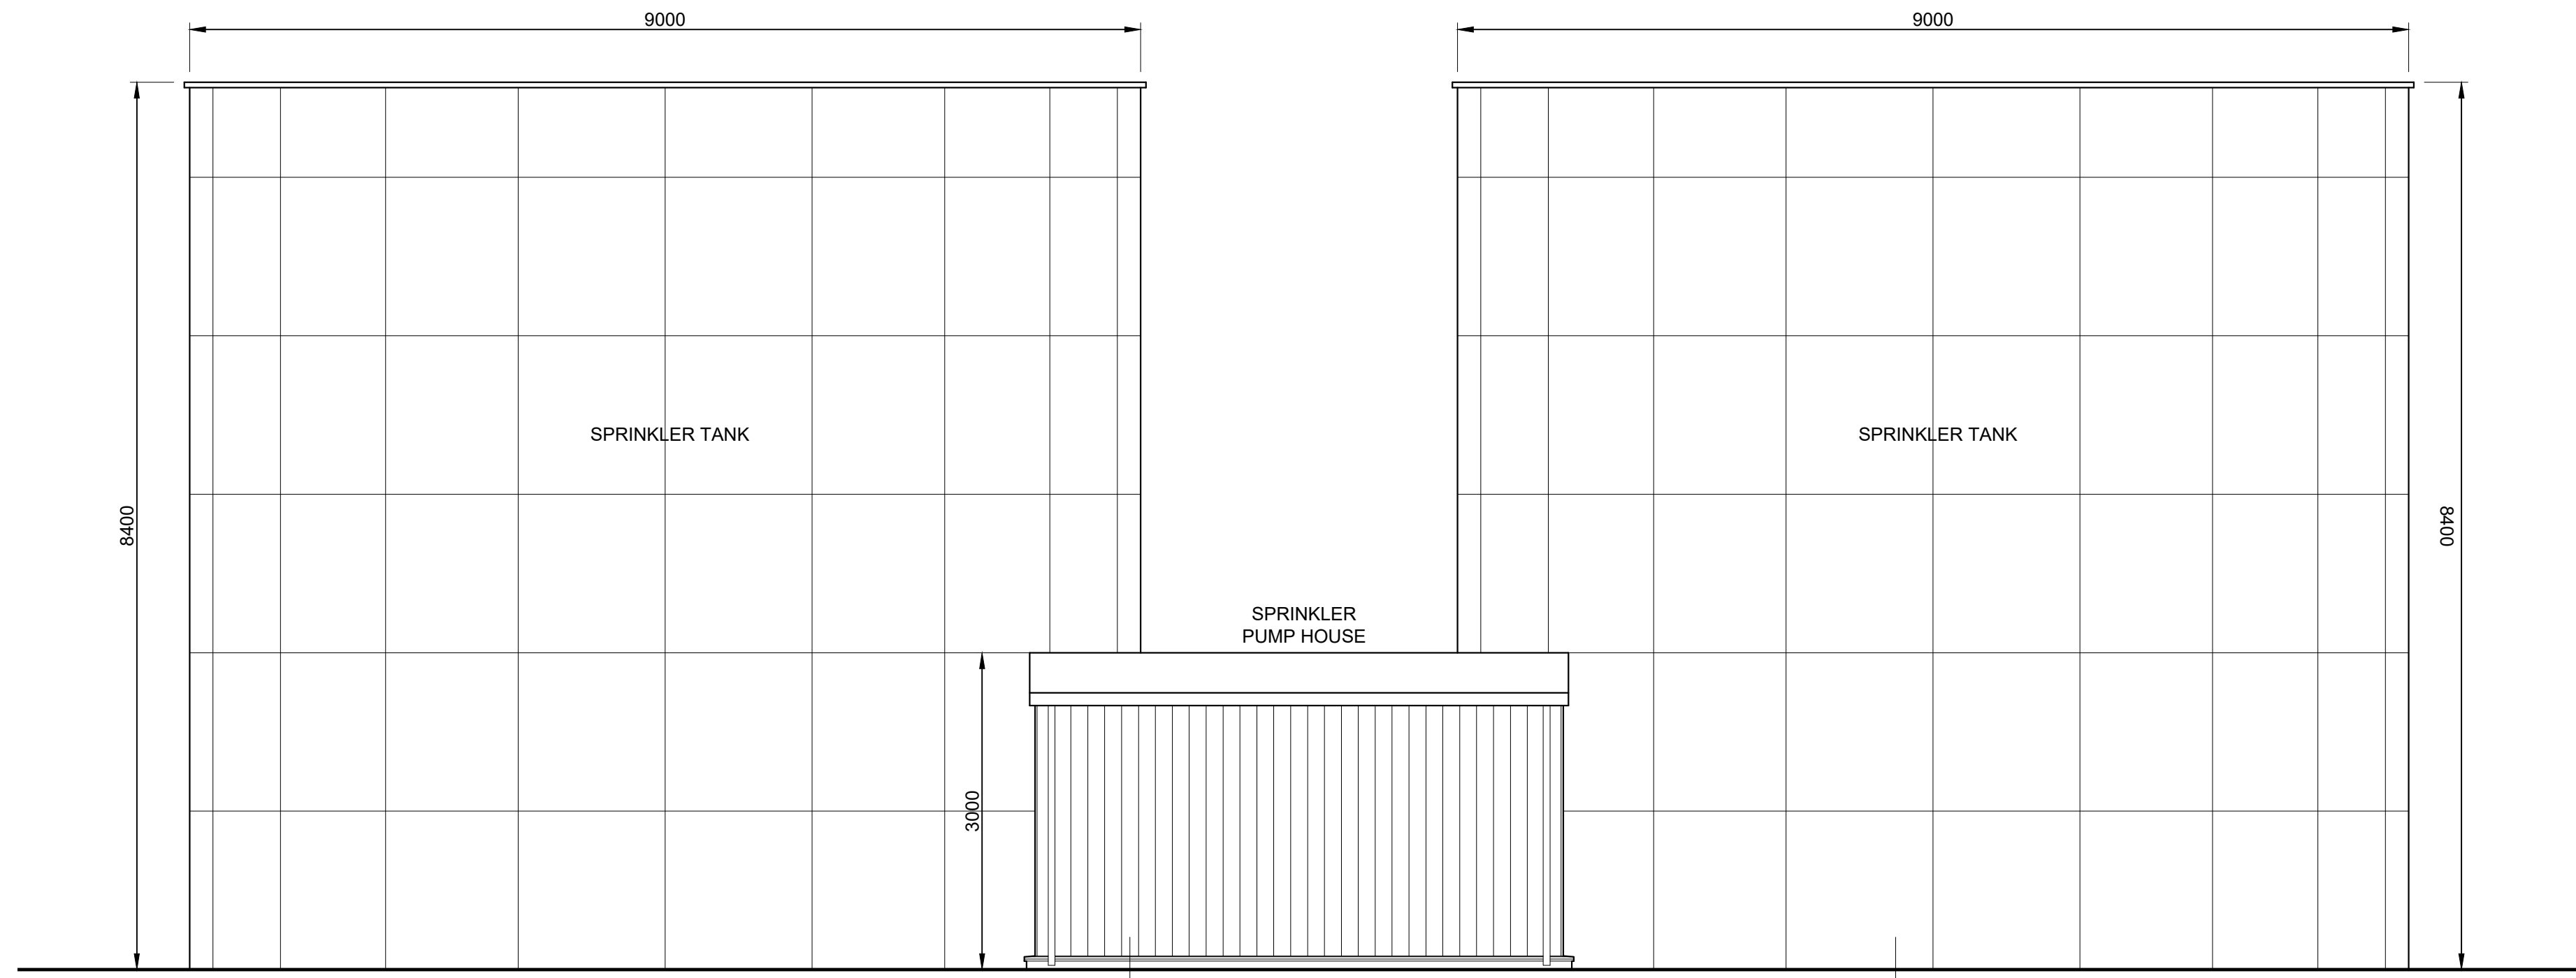


Sprinkler Tanks and Pump House Elevation
Scale 1:50

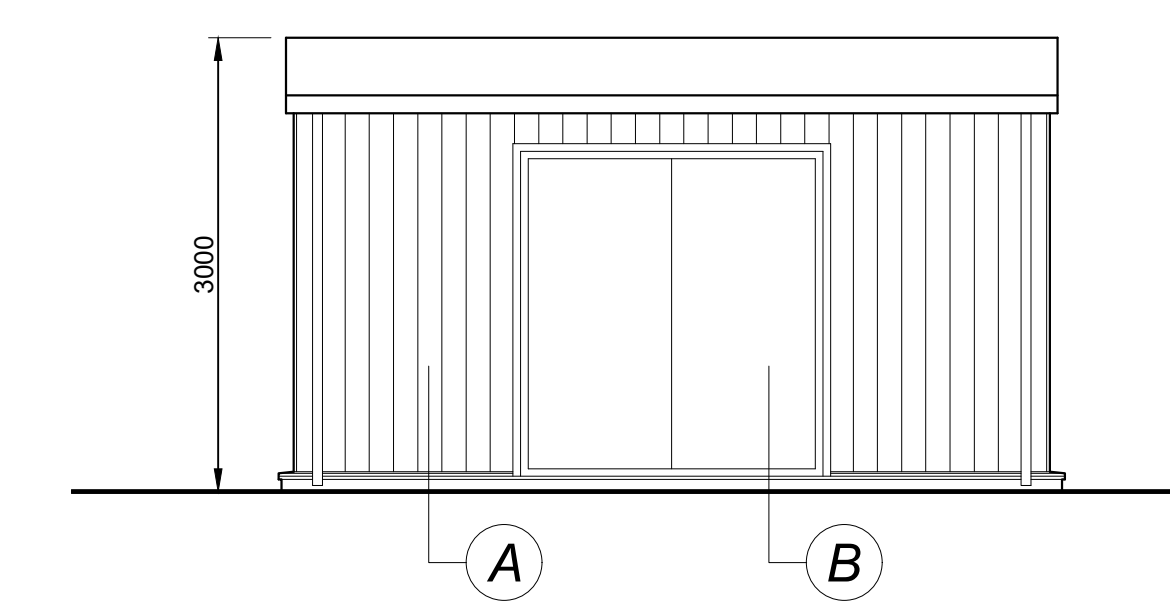

Pump House Elevation
Scale 1:50

- External Finishes
- A** Vertically laid
Profiled wall cladding system.
Finish: Tata Colorcoat HPS 200 Ultra.
Colour: Alaska Grey (RAL 7000)
 - B** Steel insulated personnel door & frame
Finish: Factory applied polyester powder
coat paint finish
Colour: Anthracite (RAL 7016)
 - C** Galvanised steel water storage tanks
Finish: Factory applied polyester powder
coat paint finish
Colour: Metallic Silver (RAL 9006)

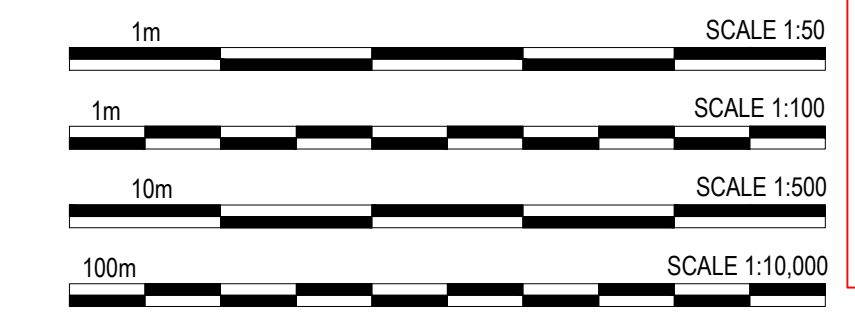

PLANNING

rev	amendments	by	chkd	date
Unit 03, Symmetry Park, Merseyside				
Unit 03 Sprinkler Tank & Pump House Details				
LOD 2		LOI 2		
 A TRITAX BIG BOX COMPANY				
				
RIBA PoW Stage:		2 - Concept Design		
Document Suitability:		S2		
Drawn / Checked:		CT / MY		
Date:		16/11/2023		
Scale:		As Noted @ A0		
UMC Project Number:		22606		
Document Reference:		Drawing no:		Revision:
22605 - UMC - XXXX - SI - DR - A		0705		P09