


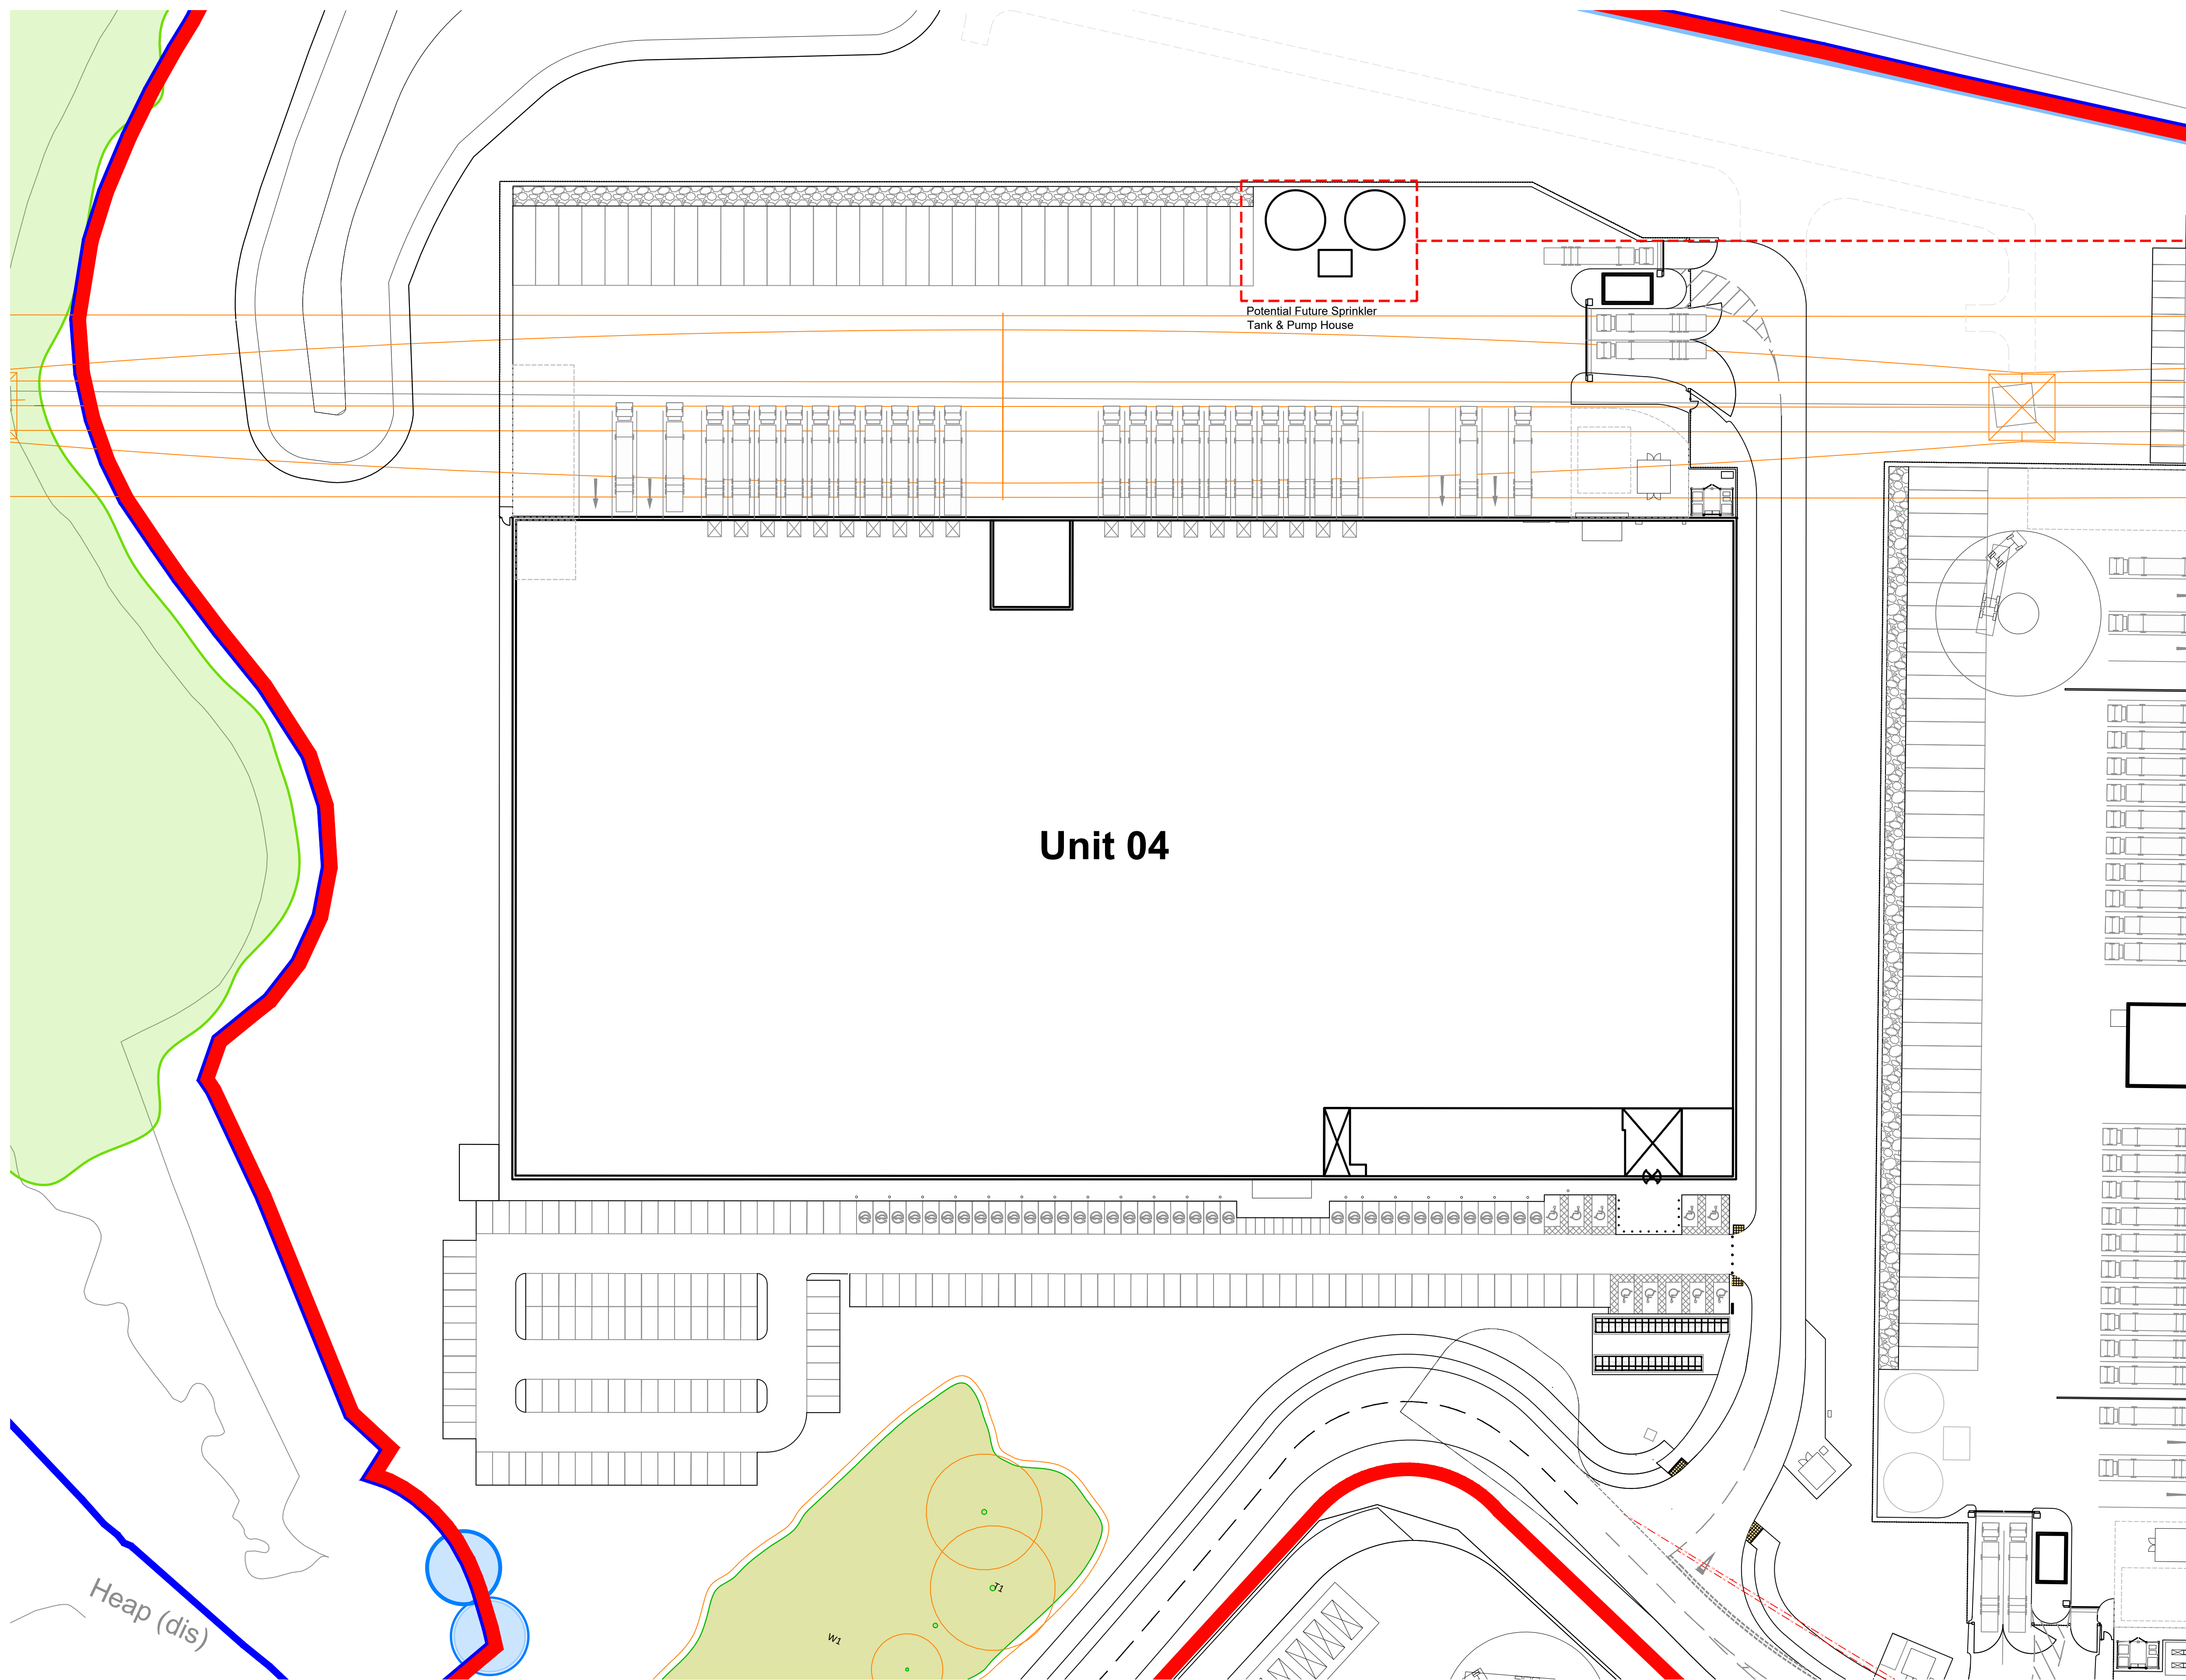


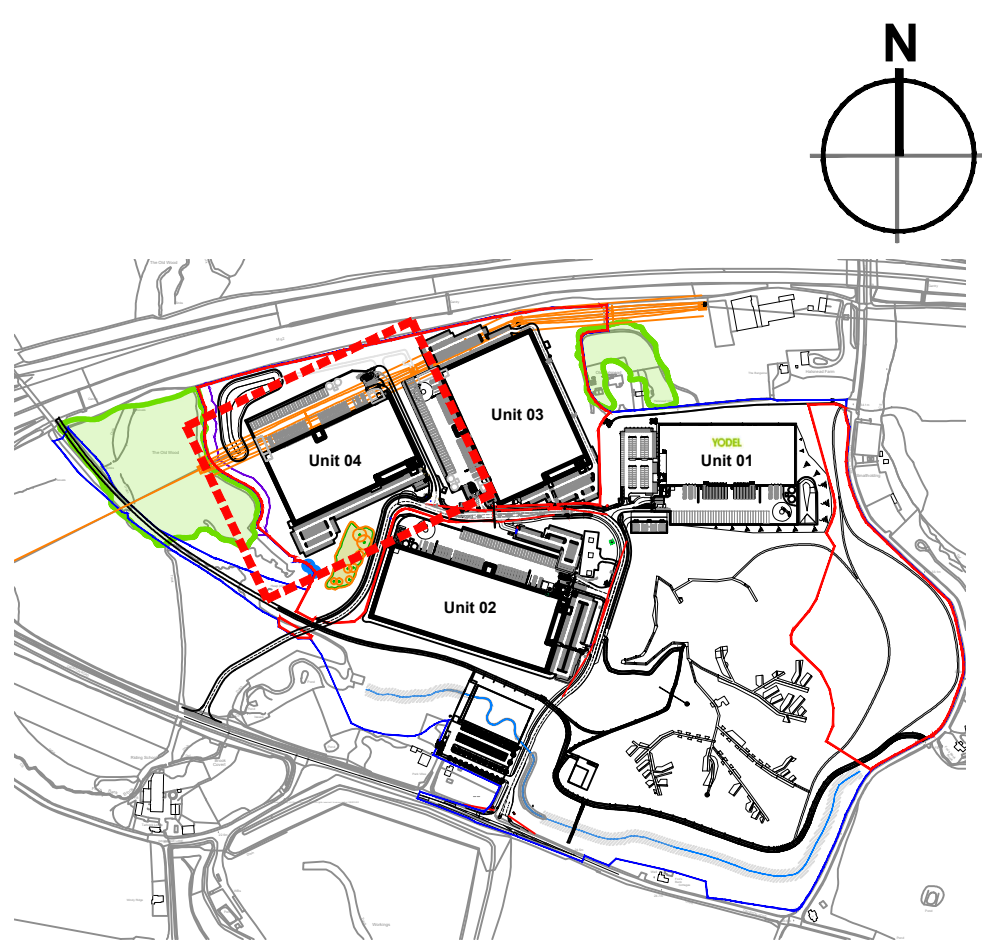


Unit 04 Site Plan
Scale 1:500

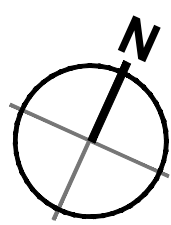


Key Plan
Scale 1:10000
Masterplan Boundary
Application Boundary

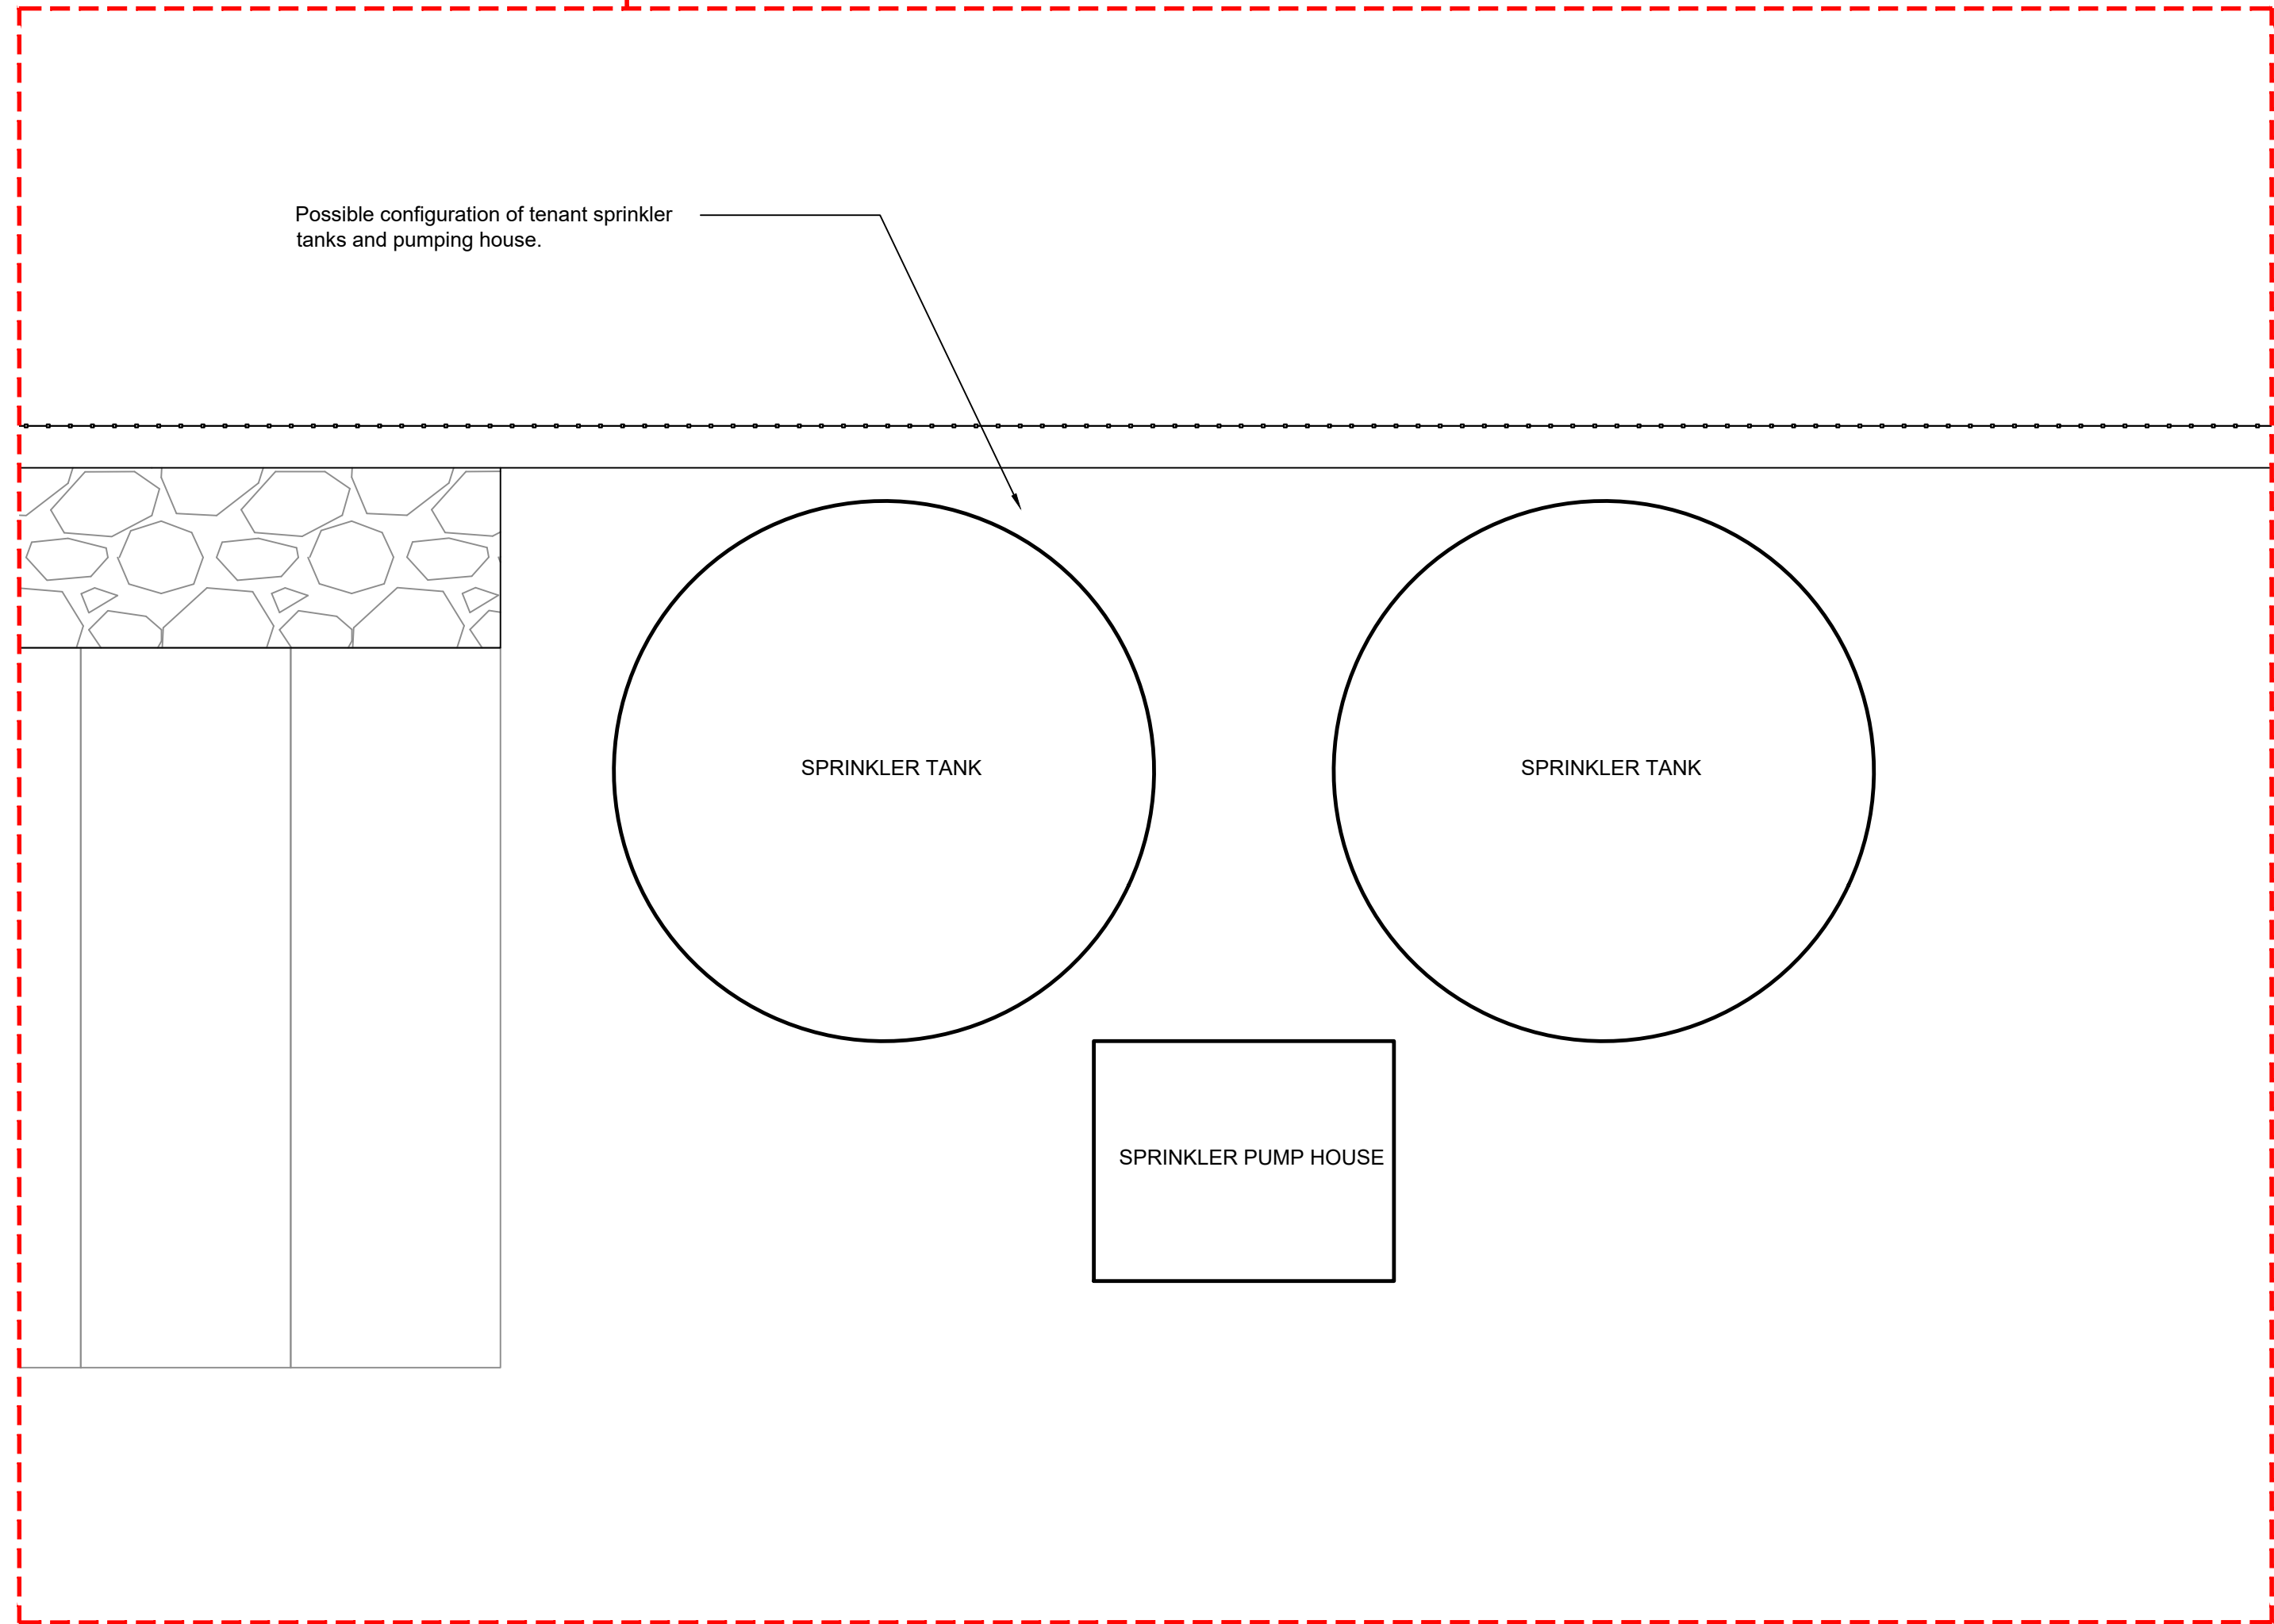

Potential Sprinkler Tank and Pump House Layout
Scale 1:100

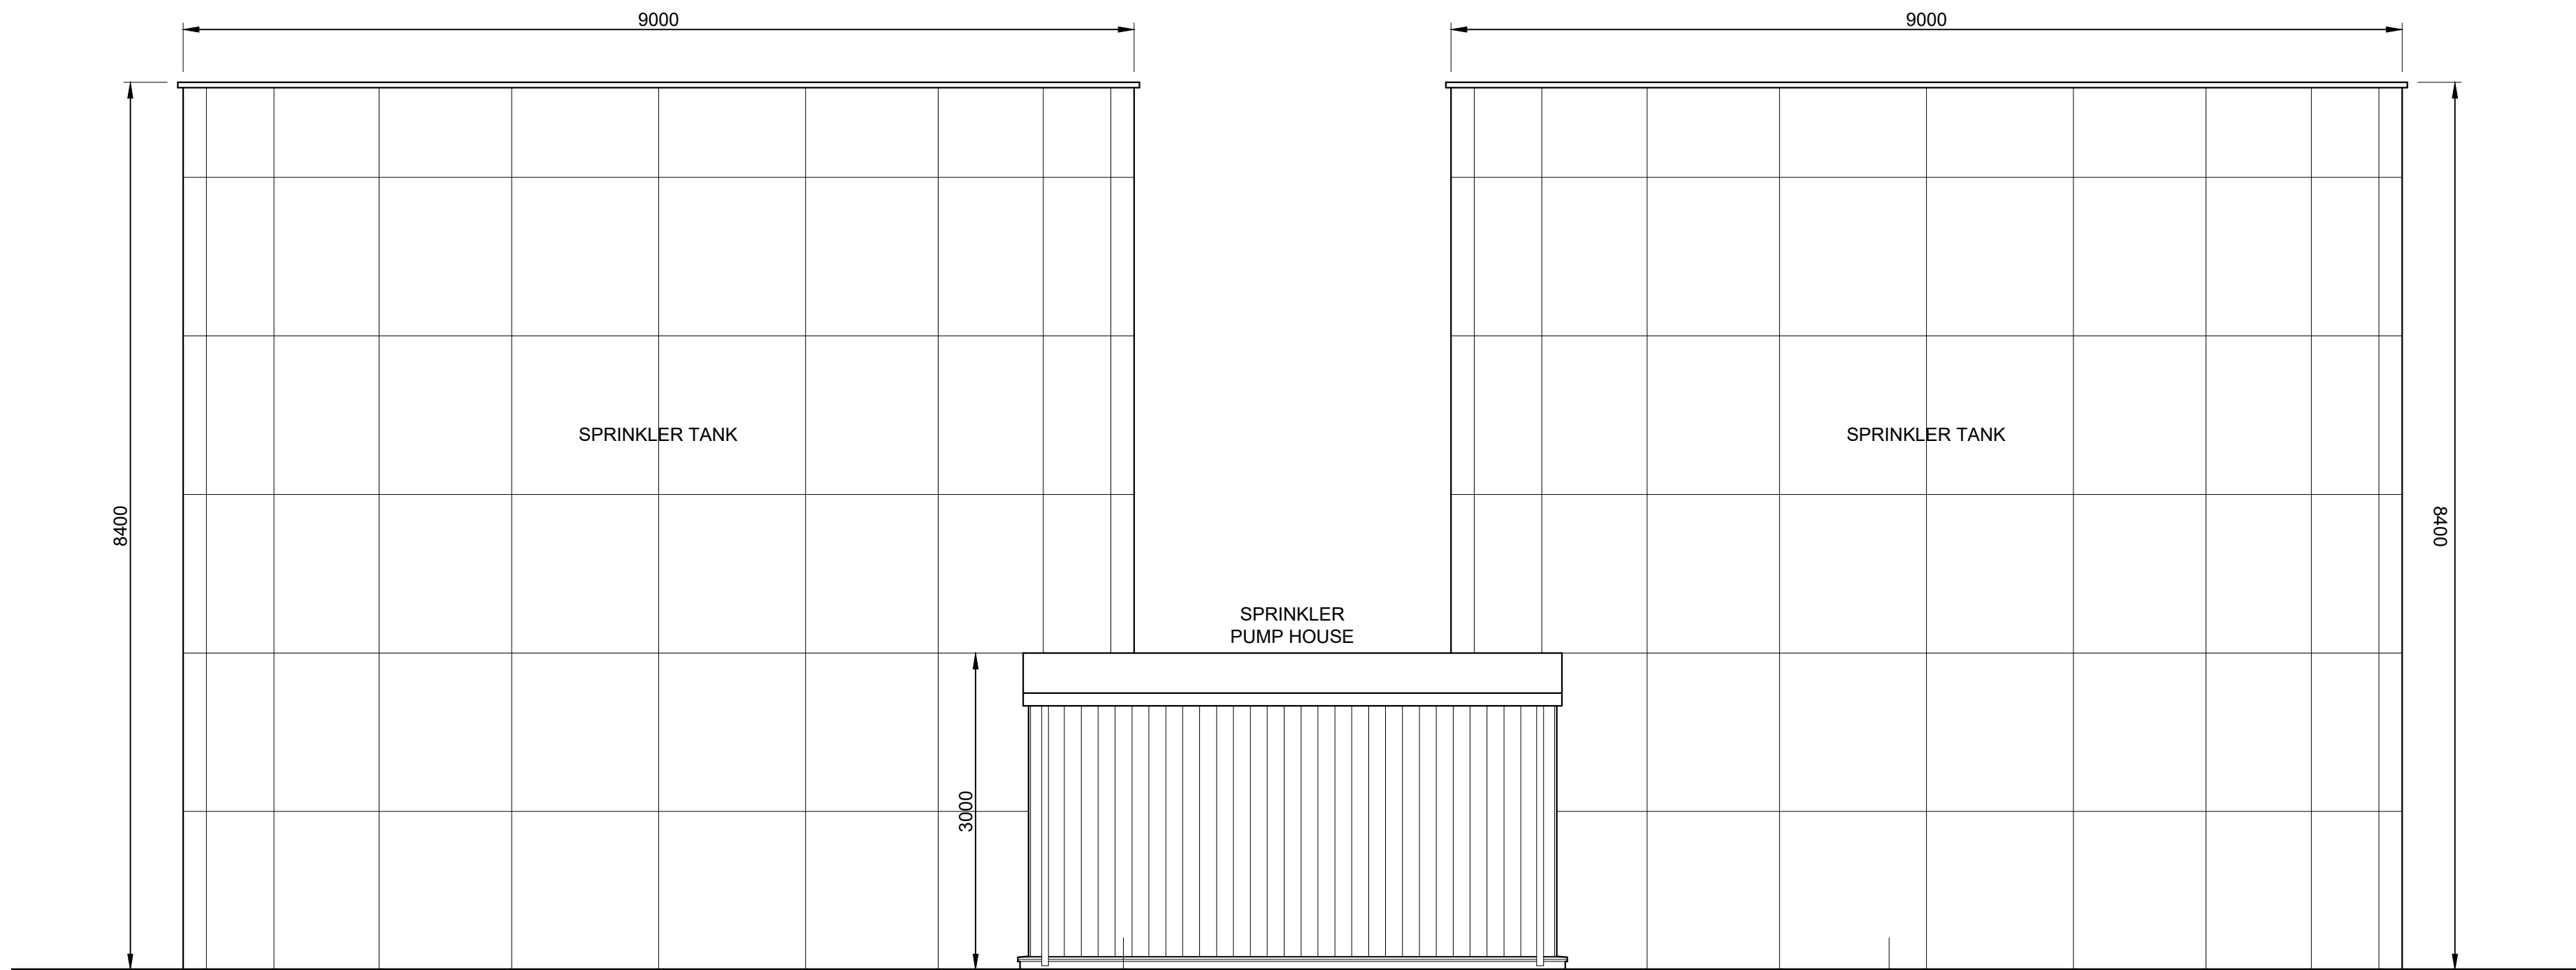


Sprinkler Tanks and Pump House Elevation
Scale 1:50

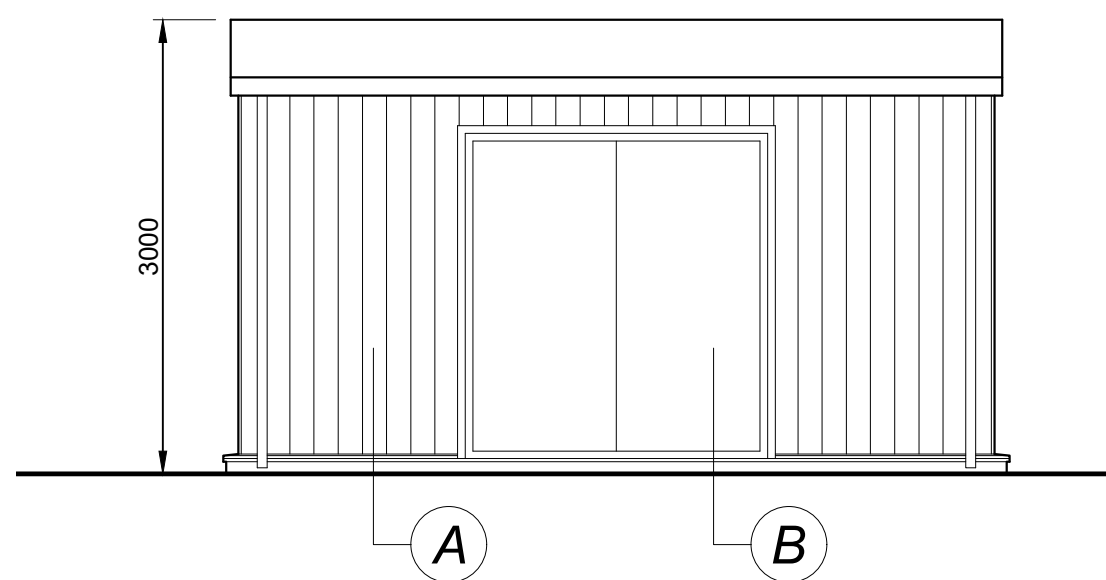

Pump House Elevation
Scale 1:50

External Finishes

- A** Vertically laid
Profiled wall cladding system.
Finish: Tata Colorcoat HPS 200 Ultra.
Colour: Alaska Grey (RAL 7000)
- B** Steel insulated personnel door & frame
Finish: Factory applied polyester powder
coat paint finish
Colour: Anthracite (RAL 7016)
- C** Galvanised steel water storage tanks
Finish: Factory applied polyester powder
coat paint finish
Colour: Metallic Silver (RAL 9006)

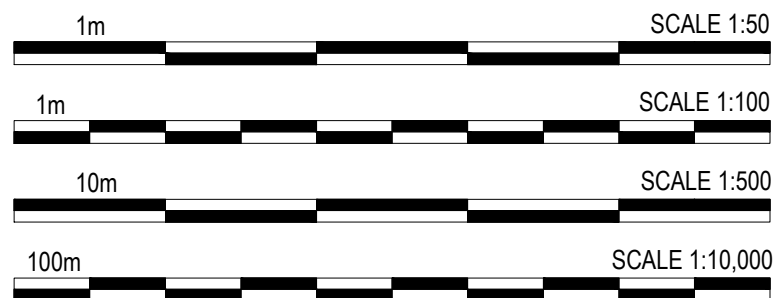

PLANNING

rev | amendments | by | dtd | date
Unit 04, Symmetry Park, Merseyside

Unit 04 Sprinkler Tank & Pump House
LOD 2 | LOI 2

TRITAX SYMMETRY
A TRITAX BIG BOX COMPANY



REBA ProjW Stage: 2 - Concept Design
Document Suitability: S2
Drawn / Checked: CT / MY
Date: 21/11/2023
Scale: As Noted @ A0
UMC Project Number: 22606
Document Reference: Drawing no: Revision:
22606 - UMC - XXXX - SI - DR - A 0705 P09