


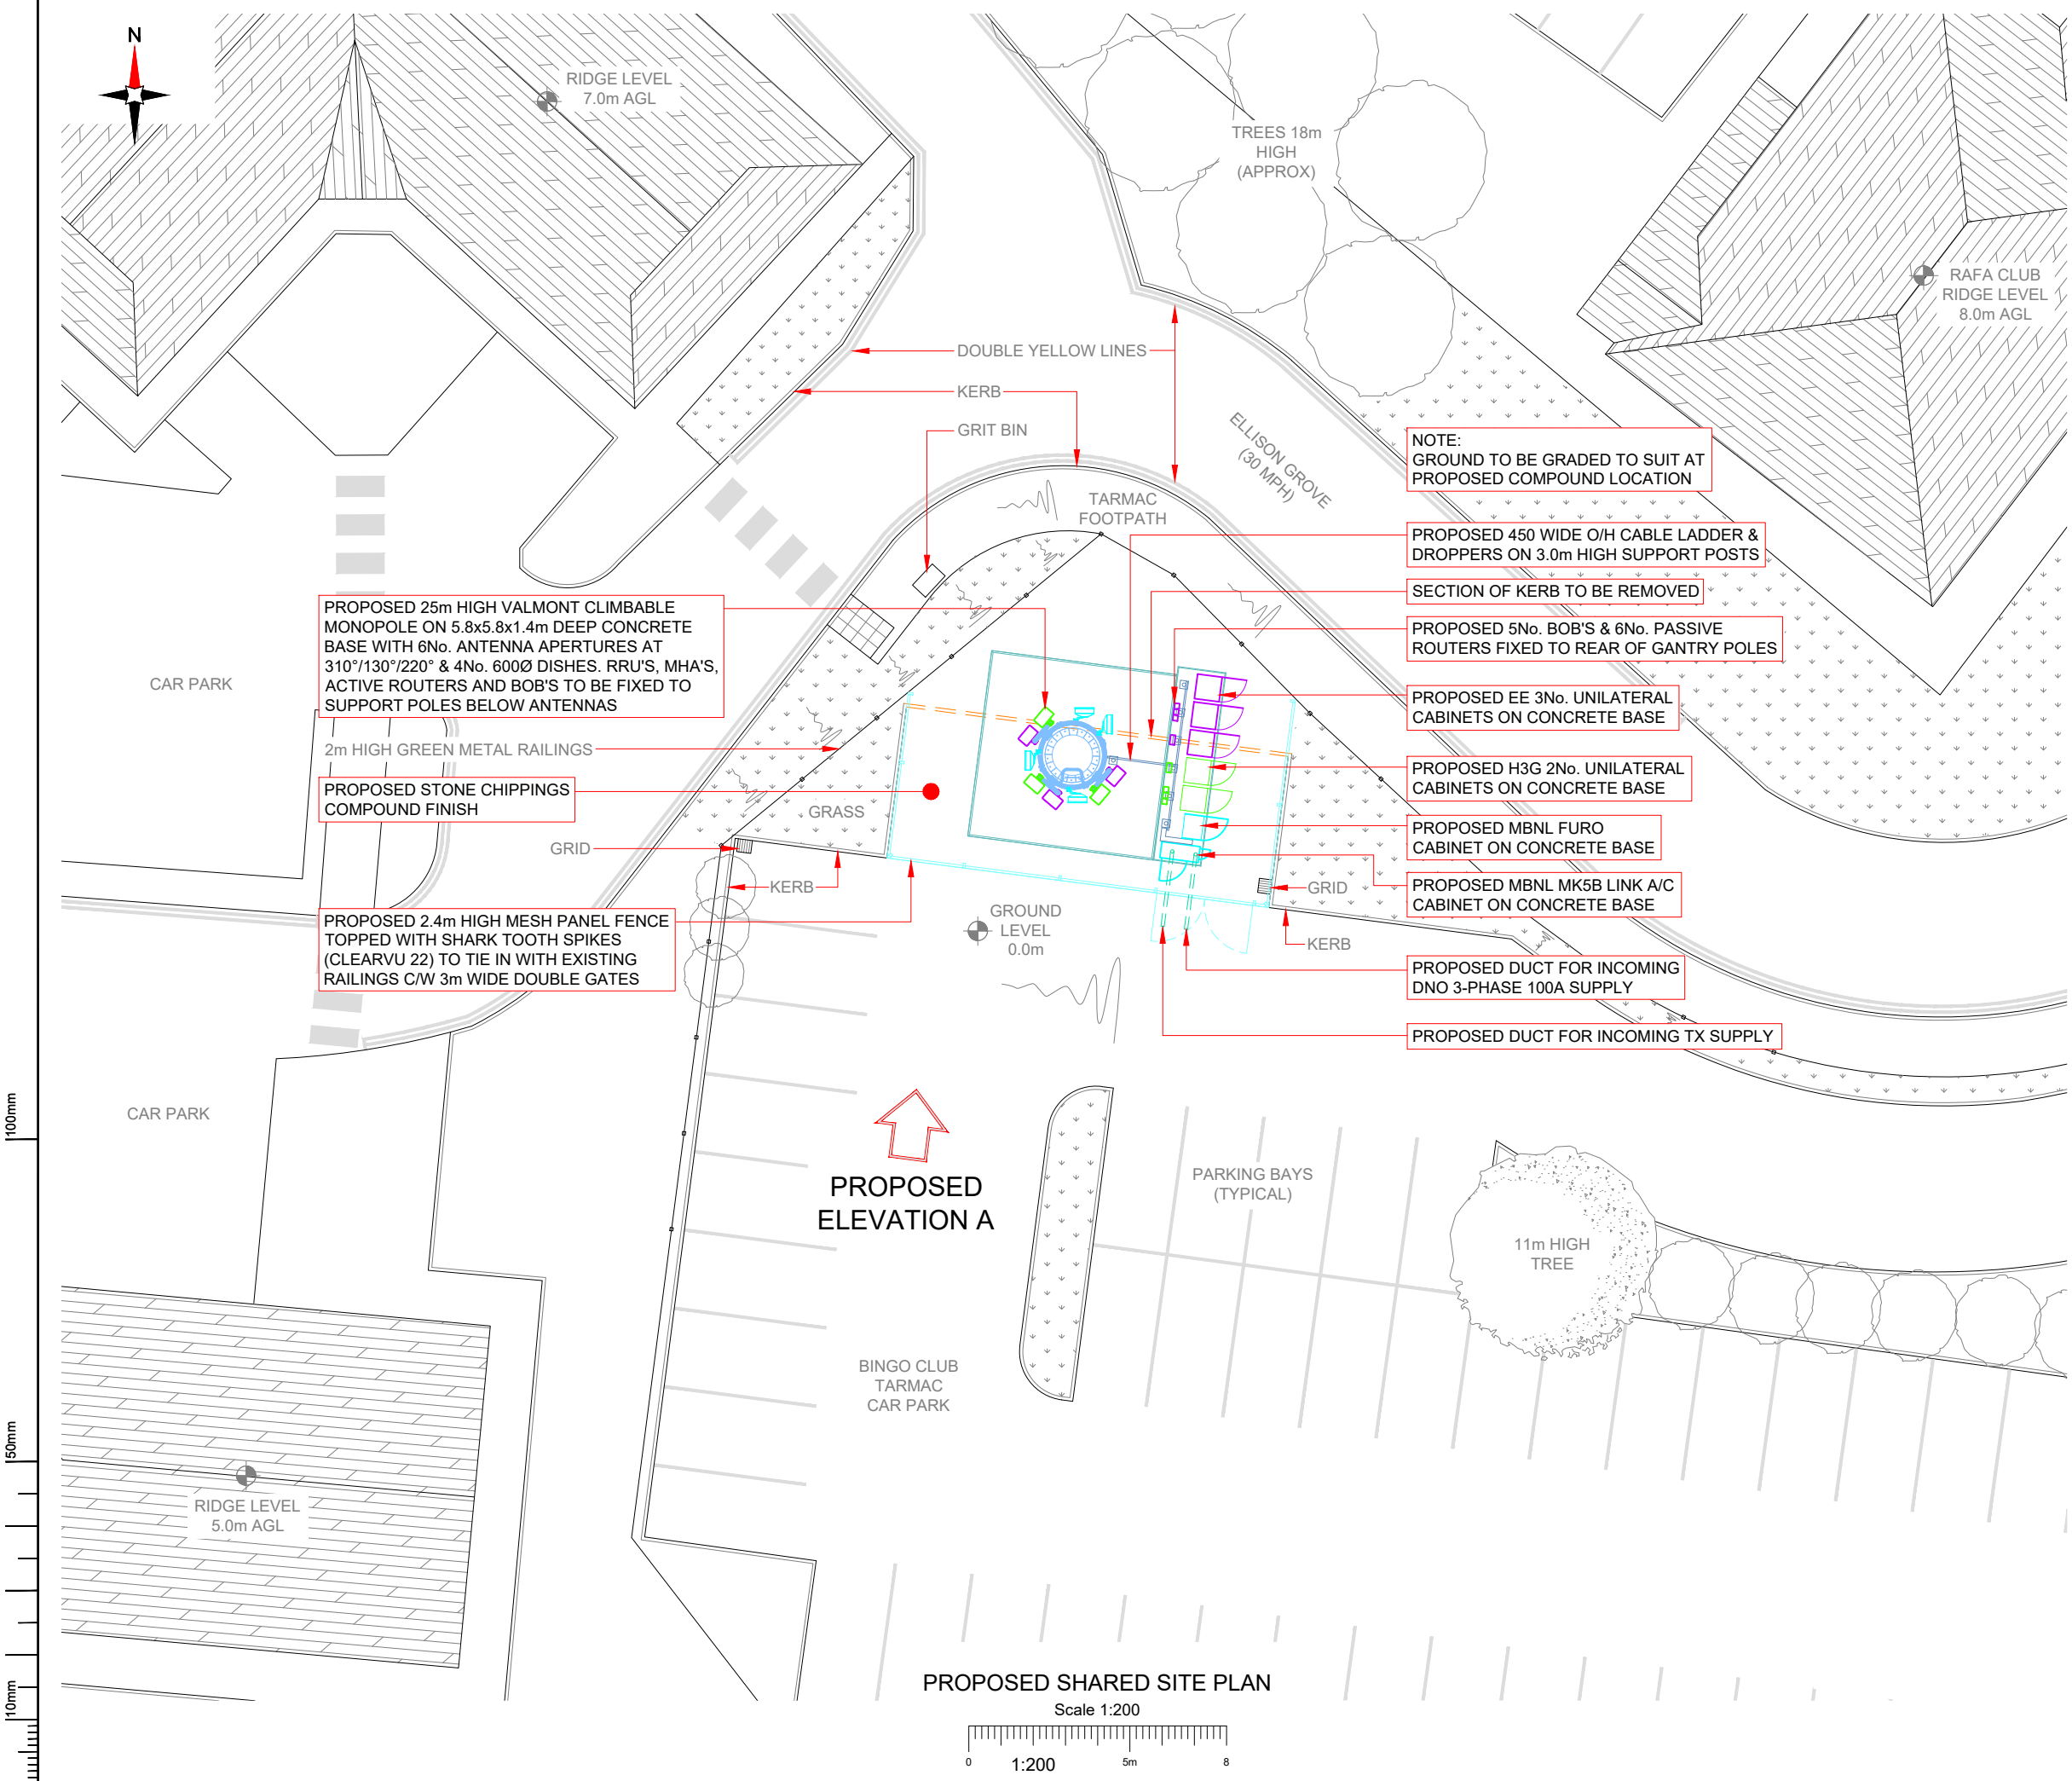

- NOTES:
- ALL DIMENSIONS IN MM UNLESS OTHERWISE NOTED.

SHARED CONFIGURATION SITE

RF CONFIG

H3a

Master:	MBNL / EE / H3G:	Project:	Purpose of Issue:	Issue:
M001	MBNL	NTQ	Planning	A
Date:	14/04/22	Revision / Upgrade Description:		
Drawn:	J. BOOTE	First Issue		
Checked:	J. STOCKDALE			
Approved:	J. STOCKDALE			



Hutchison 3G UK Limited
Star House, 20 Grenfell Road
Maidenhead, SL6 1EH
Tel: 01628 765 000
Fax: 01628 765 001

H3G Base Station Information line:
0845 6043000
Available 8am-8pm Monday to Friday



Hatfield Business Park
Hatfield
Hertfordshire
AL10 9BW

Tel: 01707 315000
Fax: 01707 319001



Mobile Broadband Network Limited
Sixth Floor, Thames Tower, Station Road, Reading, RG1 1LX

Design Consultant & Principal Contractor:



WHP Telecoms
Unit 1 Maple Park,
Low Fields Avenue, Leeds
LS12 6HH

Tel: 01133023550
e-mail: info@whptelecoms.com

Site Name:
CLUB 3000 BINGO HUYTON

Site ID:
1668316

Address:
**CLUB 3000 BINGO HUYTON,
POPLAR BANK,
HUYTON, LIVERPOOL,
MERSEYSIDE,
L36 9US**

Title:
200 PROPOSED SHARED SITE PLAN

Project:
NTQ

Purpose of Issue:
GENERAL ARRANGEMENT

EE Cell ID:	MBNL Cell ID:	3UK Cell ID:
96147	KSY093	-

Master Drawing No:	Issue:
1668316_KSY093_96147_M001	A