



VD_E_A3_v1.2 Plotted By: Chun Li on 26.11.2025 at 2:55 PM

THIS DRAWING REMAINS THE PROPERTY OF VITAL ENERGI AND MUST NOT BE REPRODUCED, COPIED, OR HANDED OVER TO A THIRD PARTY WITHOUT PRIOR WRITTEN CONSENT. UNCONTROLLED COPY IF PRINTED

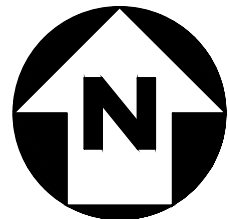

PRESCOT GYM &
SOCCER CENTRE (BY
VOLAIR), 119
WARRINGTON RD,
PRESCOT L35 5AD

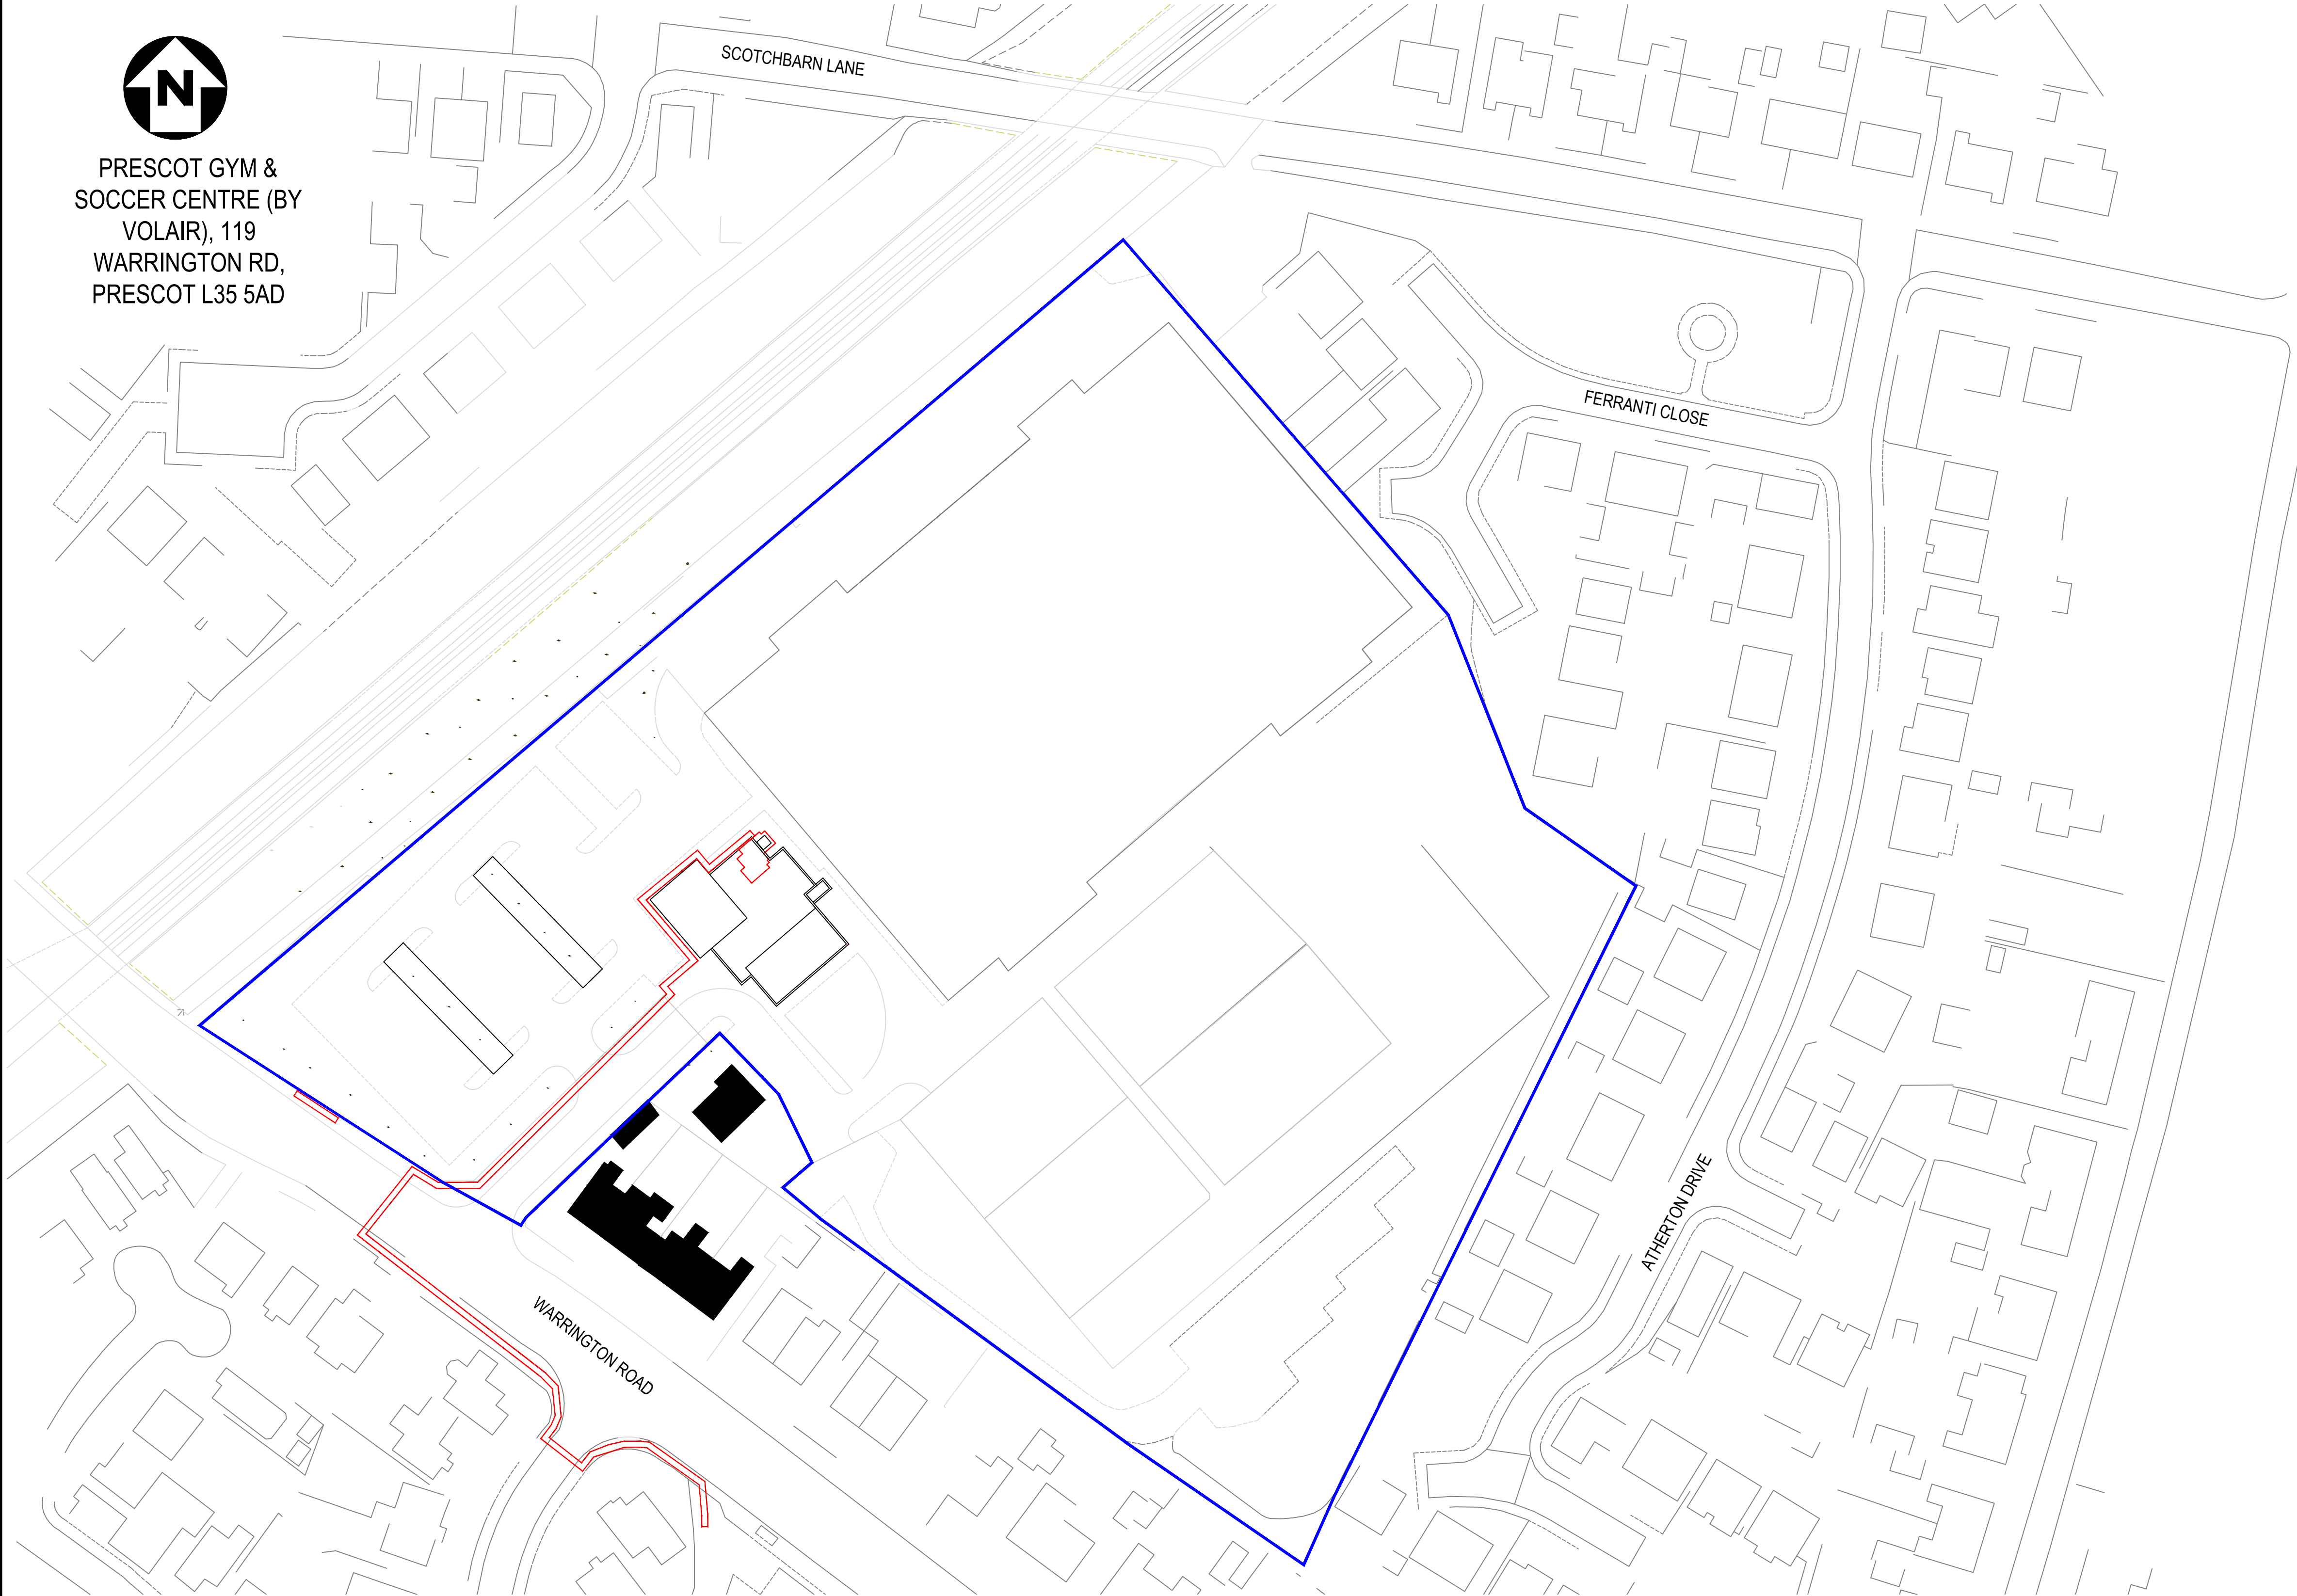

GENERAL NOTES:

ALL BUILDERS WORK IS TO BE CONSTRUCTED IN ACCORDANCE WITH THE CURRENT AND RELEVANT BUILDING REGULATIONS AND BRITISH STANDARDS. MANUFACTURERS INSTALLATION/ GUIDANCE NOTES ARE TO BE READ IN CONJUNCTION TO TASK BEING CARRIED OUT.

ALL DIMENSIONS ON DRAWING ARE IN MILLIMETERS UNLESS OTHERWISE STATED. ALL LEVELS ON DRAWING ARE IN METERS UNLESS OTHERWISE STATED.

THE CONTRACTOR SHALL BE RESPONSIBLE FOR THE ACCURACY OF ALL DIMENSIONS AND FOR THE CORRECT SETTING OUT OF WORK CARRIED OUT ON SITE.

THIS DRAWING IS TO BE READ IN CONJUNCTION WITH ALL RELEVANT ARCHITECTURAL, STRUCTURAL AND MECHANICAL DRAWINGS/ SPECIFICATIONS ISSUED.

ALL MATERIALS AND WORKMANSHIP SHALL BE IN ACCORDANCE WITH THE RELEVANT SPECIFICATIONS AND BRITISH STANDARDS

THE CONTRACTOR SHALL ENSURE THE STABILITY OF THE BUILDING AND ANY ADJOINING STRUCTURES IS MAINTAINED AT ALL STAGES OF CONSTRUCTION. THE CONTRACTOR SHALL DESIGN, INSTALL AND MAINTAIN ANY NECESSARY TEMPORARY WORKS.

CONTRACTOR TO PROVIDE METHOD STATEMENTS AND RISK ASSESSMENTS TO THE ENGINEER AND PLANNING SUPERVISOR A MINIMUM OF 14 DAYS BEFORE THE WORKS COMMENCE


THIS DRAWING IS TO BE READ IN CONJUNCTION WITH:

50890-VE-PSC-XX-DR-A-XX01 GENERAL ARRANGMENT
50890-VE-PSC-XX-DR-A-XX02 PROPOSED SITE PLAN
50890-VE-PSC-XX-DR-A-XX03 PROPOSED LOCATION PLAN
50890-VE-PSC-XX-DR-A-XX06 EXISTING SITE PLAN
50890-VE-PSC-XX-DR-A-XX04 SLAB LAYOUT & DETAILS
50890-VE-PSC-XX-DR-A-XX05 STEEL SUPPORT LAYOUT & DETAILS
50890-VE-PSC-XX-E-A-XX01 EXISTING ELEVATIONS
50890-VE-PSC-XX-E-A-XX02 PROPOSED ELEVATIONS
50890-VE-PSC-XX-E-A-XX03 PROPOSED ELEVATIONS (SITE)

KEY LEGEND

OWNERSHIP BOUNDARY

RED LINE PLANNING BOUNDARY
TOTAL AREA 245 sq.m

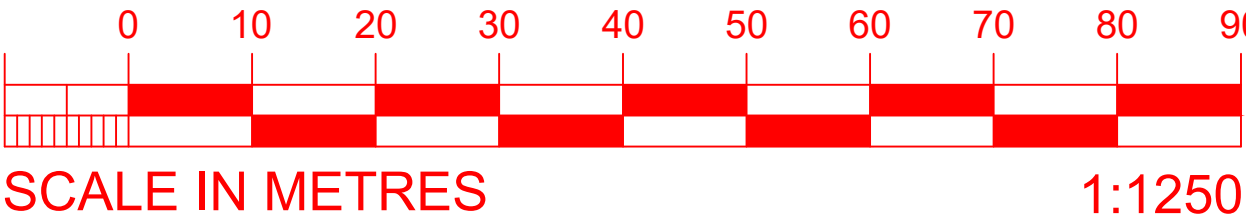

LOCATION PLAN
(SCALE 1:1250)

ISSUED FOR STAGE
APPROVAL

					*	VITAL ENERGi. Century House, Roman Road, Blackburn United Kingdom, BB1 2LD. Tel: +44 (0)1254 296 000 Fax: +44 (0)1254 296 040 	Project: LCR PUBLIC SECTOR DECARB							STAGE APPROVAL	Status: S4	Stage: 3
P1	15.10.25	ISSUED FOR STAGE APPRIVAL	RC	CV	RJR		*	Title: PRESCOT SOCCER CENTRE LOCATION PLAN								
PA1	15.10.25	ISSUED FOR PLANNING APPRIVAL	RC	CV	RJR		*							Drg-No:	Rev:	
REV	DATE	DESCRIPTION	DRN	CHK	APP		CAD QA	DATE	10.10.2025	SCALE	1:1250	SHEET	A3	50890-VE-PSC-XX-DR-A-XX03	P1	