



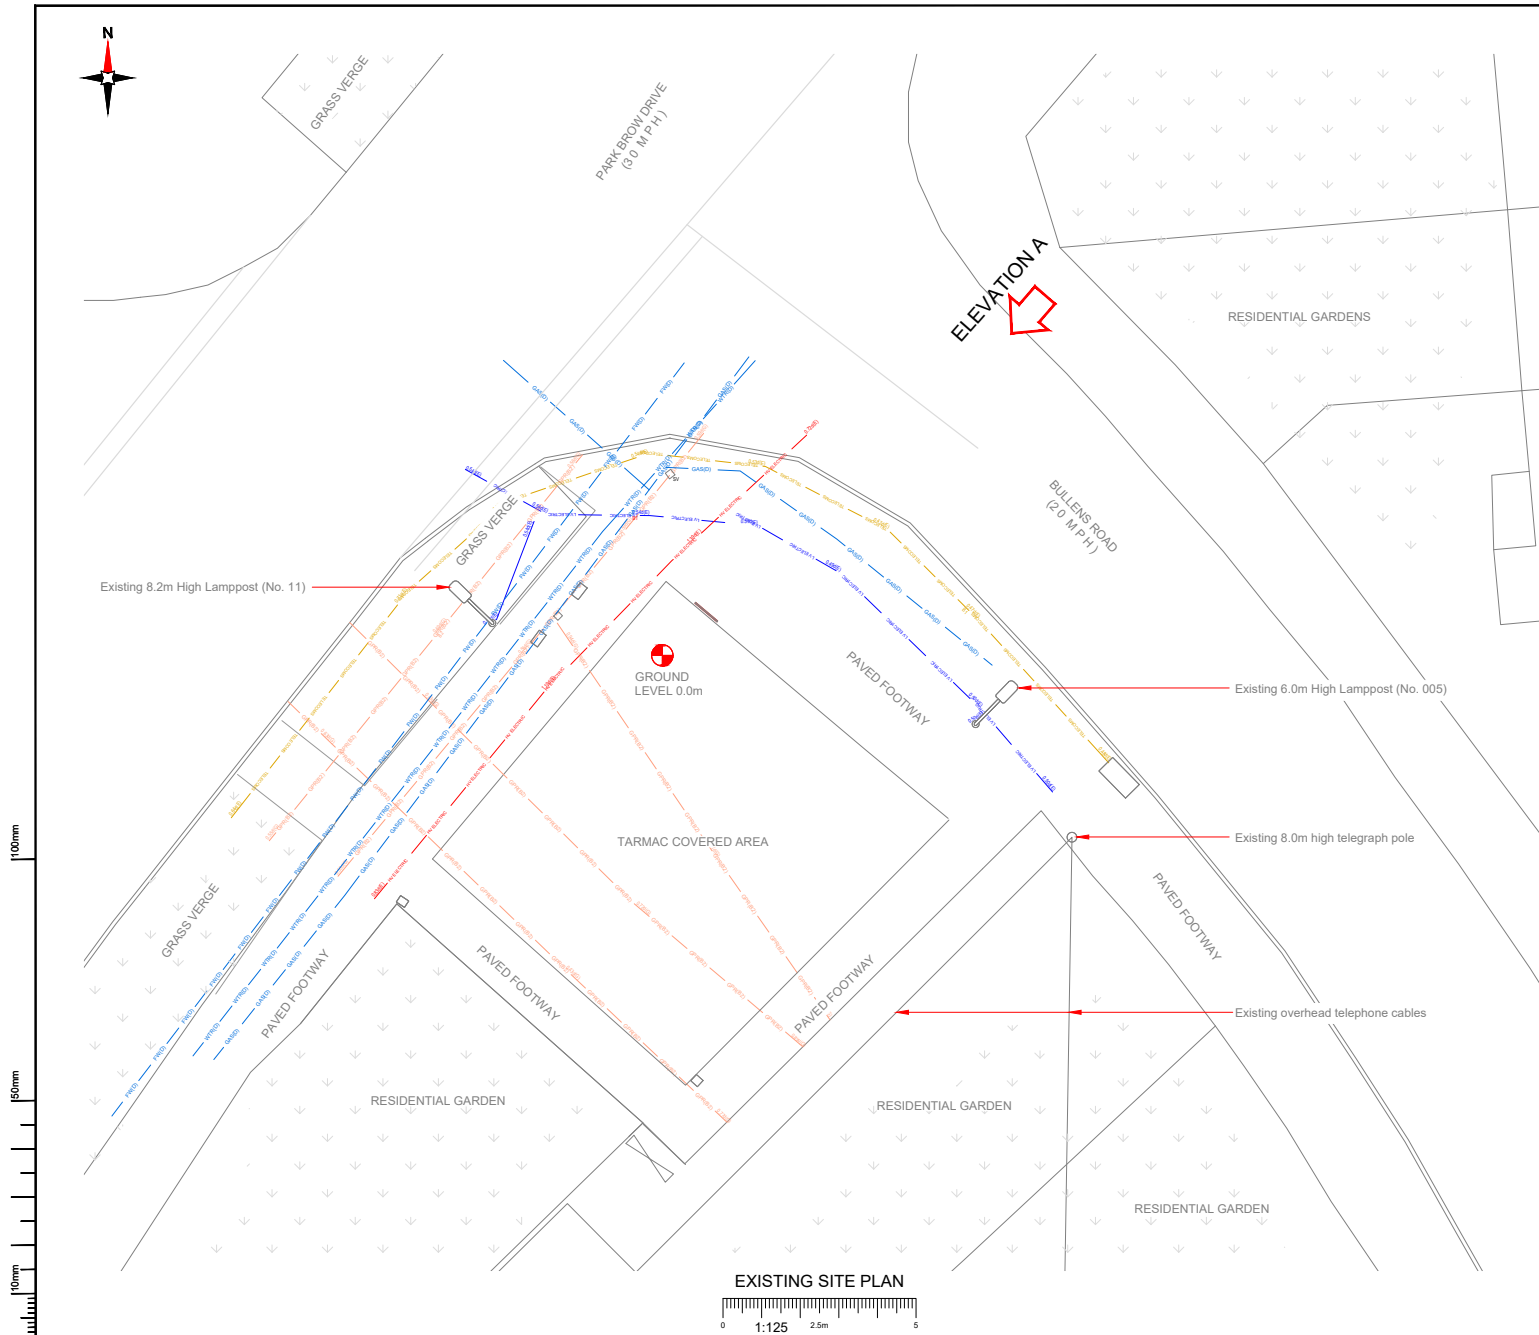

NOTES:

- ALL DIMENSIONS IN MM UNLESS OTHERWISE NOTED.

SERVICES LEGEND

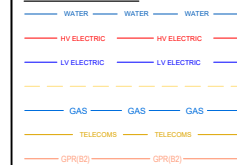

Drawn:	MBNL Cell ID:	Project:	Purpose of Issue:	Issue:
M001	H3G	DENSIFICATION SW	Planning	A
Date:	28/04/2023	Revised/Original/Superseded:	First Issue - Site nomination dated: 13-03-2023	
Drawn:	R. Sweeney			
Checked:	G. Thomas			
Approved:	G. Thomas			

Signal Infrastructure UK Limited (formerly known as CK Hutchison Networks (UK) Limited) (a company registered in England and Wales with company number 12855914) (a Hutchison 3G UK Limited (a company registered in England and Wales with company number 03855486))

Green Park, 450 Longwater Avenue
Reading, RG2 6GF
Tel: 01628 785 000
Fax: 01628 785 001

H3G Base Station Information line:
0845 6043000
Available 8am-8pm Monday to Friday

Design Consultant & Principal Contractor:

CLARKE
telecom

Unit E, Madison Place, Northampton Road,
Manchester, M40 5AG
Tel: 0161 785 4500 Fax: 0161 785 4501
Web: www.clarke-telecom.com

Site Name:
PARK BROW DRIVE

Site ID:
KS25678

Address:
**BULLENS ROAD
KIRBY
KNOWSLEY
LIVERPOOL
L32 8TT**

Title:
100 EXISTING H3G SITE PLAN

Project:
H3G DENSIFICATION STREETWORKS

Purpose of Issue:
PLANNING


MBNL Cell ID:
KS25678

3UK Cell ID:
L1024

Master Drawing No:
KS25678_KS25678_L1024_M001

Issue:
A

100mm
50mm
10mm

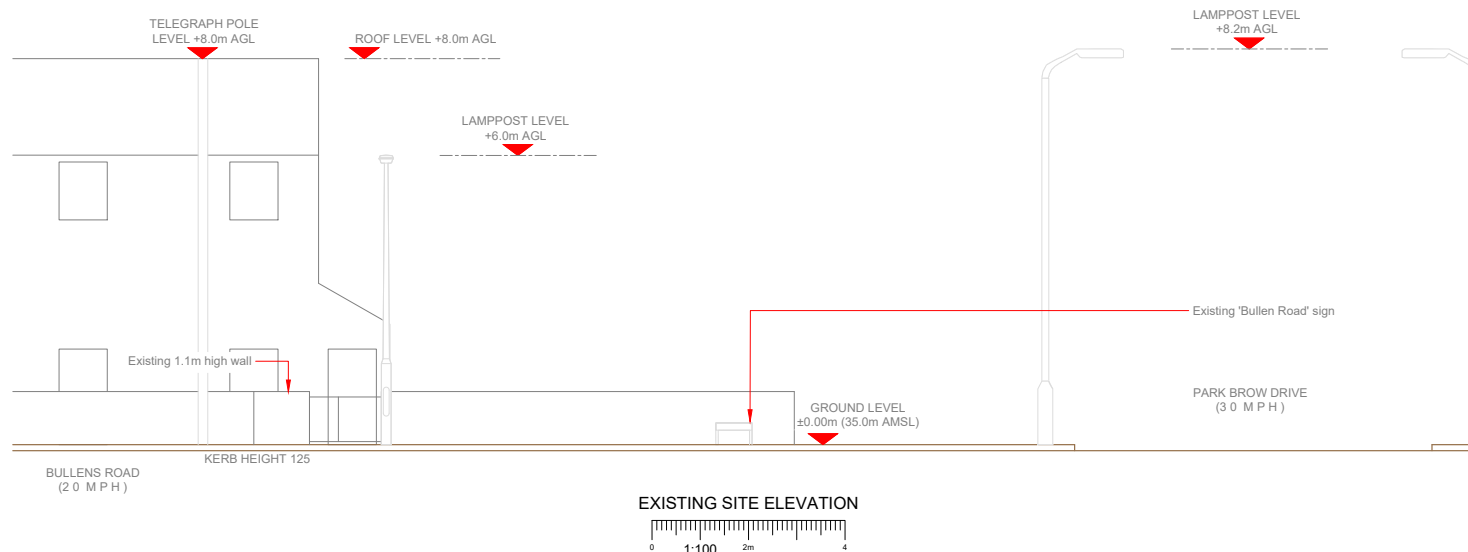

NOTES:

- ALL DIMENSIONS IN MM UNLESS OTHERWISE NOTED.

Drawn:	MBNL Cell ID:	Project:	Purpose of Issue:	Issue:
M001	H3G	DENSIFICATION SW	Planning	A
Date:	28/04/2023	Revision 1: Original Drawing		
Drawn:	R. Sweeney	First Issue - Site nomination dated: 13-03-2023		
Checked:	G. Thomas			
Approved:	G. Thomas			

3

Signal Infrastructure UK Limited (formerly known as CK Hutchison Networks (UK) Limited) (a company registered in England and Wales with company number 12865914) (a company registered in England & Wales with company number 03855486)

Green Park, 450 Longwater Avenue
Reading, RG2 6GF
Tel: 01628 785 000
Fax: 01628 785 001

H3G Base Station Information line:
0845 6043000
Available 8am-8pm Monday to Friday

Design Consultant & Principal Contractor:

CLARKE
telecom

Unit E, Madison Place, Northampton Road,
Manchester, M40 5AG
Tel: 0161 785 4500 Fax: 0161 785 4501
Web: www.clarke-telecom.com

Site Name: **PARK BROW DRIVE**

Site ID: **KS25678**

Address: **BULLENS ROAD
KIRBY
KNOWSLEY
LIVERPOOL
L32 8TT**


Title: **150 EXISTING H3G ELEVATION**

Project: **H3G DENSIFICATION STREETWORKS**

Purpose of Issue: **PLANNING**

MBNL Cell ID: **KS25678** 3UK Cell ID: **L1024**

Master Drawing No: **KS25678_KS25678_L1024_M001** Issue: **A**

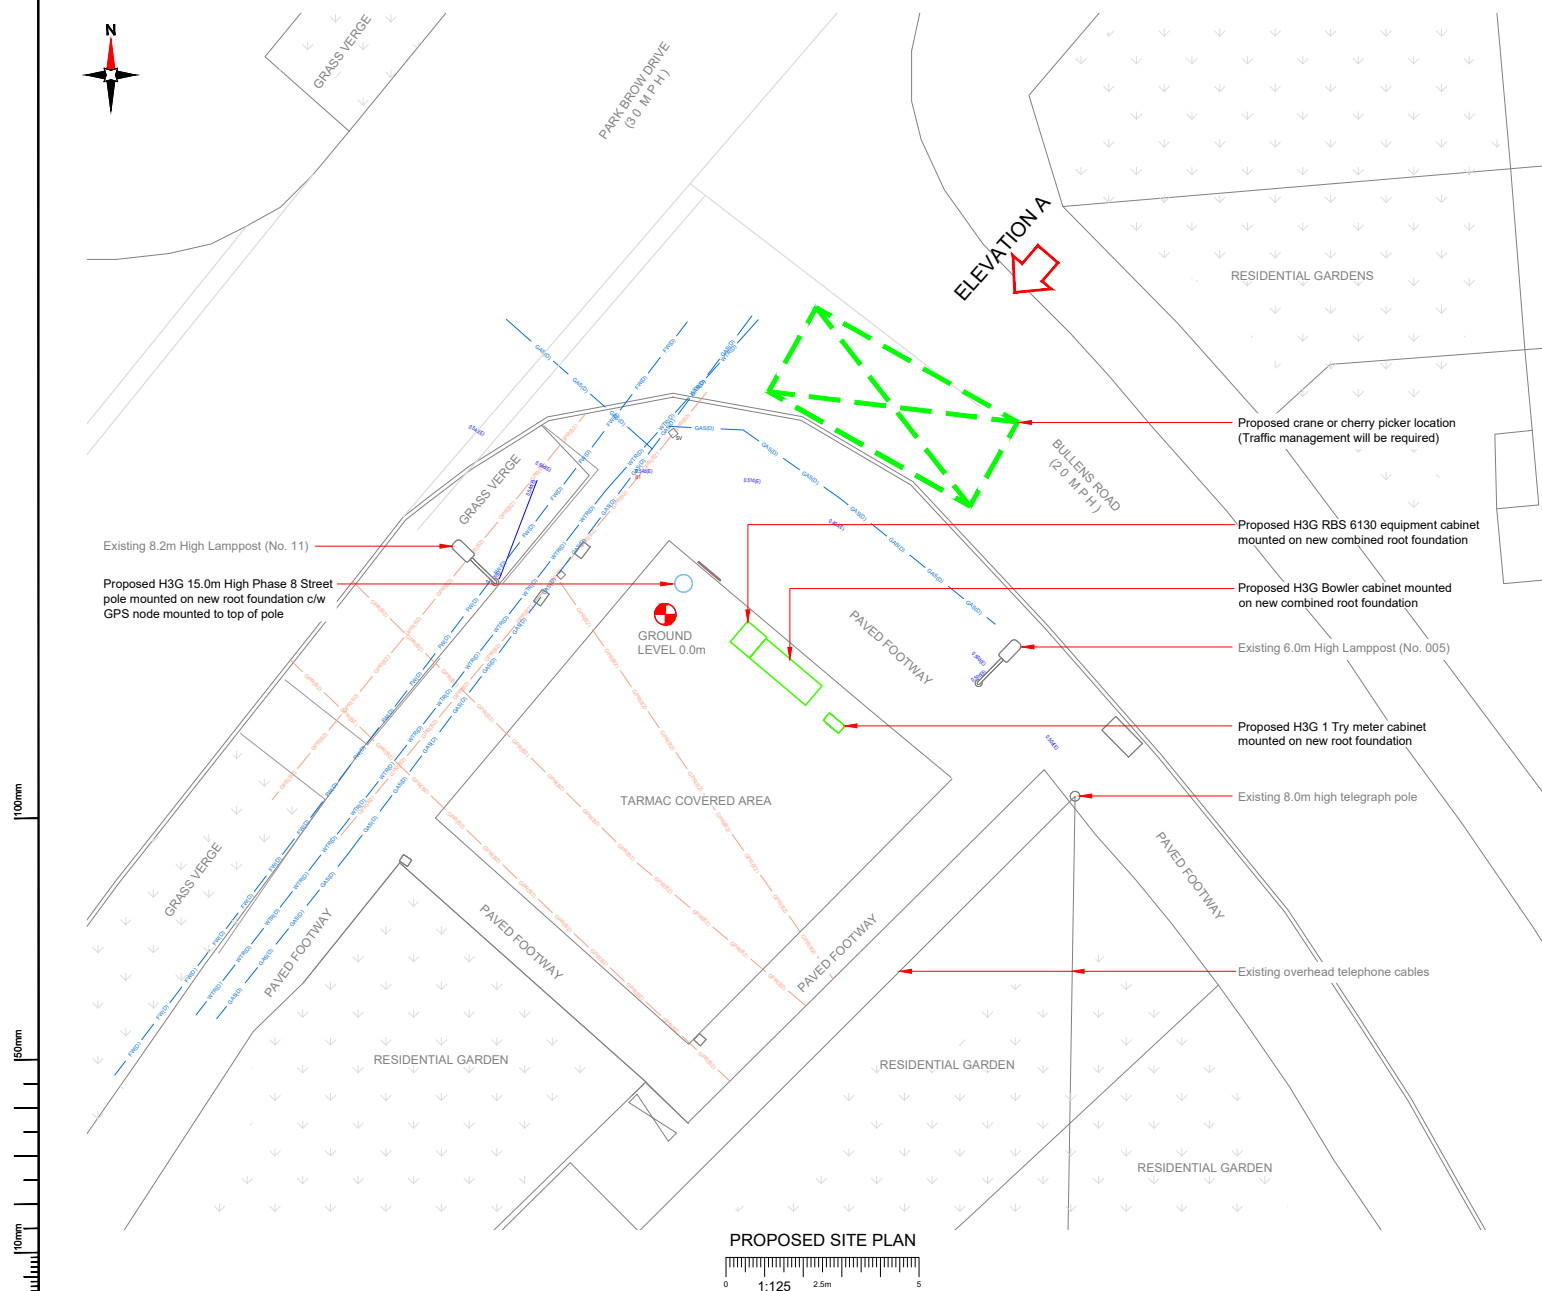

The diagram illustrates a multi-layered cable structure with the following layers from top to bottom:

- WATER** (Blue line)
- WATER** (Blue line)
- WATER** (Blue line)
- HV ELECTRIC** (Red line)
- HV ELECTRIC** (Red line)
- LV ELECTRIC** (Blue line)
- LV ELECTRIC** (Blue line)
- GAS** (Blue line)
- GAS** (Blue line)
- GAS** (Blue line)
- TELECOMS** (Yellow line)
- TELECOMS** (Yellow line)
- GPR(R2)** (Red line)
- GPR(R2)** (Red line)

Master:	MBNL / EE / H3G.	Project:	Purpose of Issue:	Issue
M001	H3G	DENSIFICATION SW	Planning	A
Date:	26/04/2023	Revision / Upgrade Description:		
Drawn:	R. Sweeney	First Issue - Site nomination dated: 13-03-2023		
Checked:	G Thomas			
Approved:	G Thomas			



Cignal Infrastructure UK Limited (formerly known as CK Hutchison Networks (UK) Limited) (a company registered in England and Wales with company number 12985914) c/o Hutchison 3G UK Limited (a company registered in England & Wales with company number 03885486)

Green Park, 450 Longwater Avenue
Reading, RG2 6GF
Tel: 01628 765 000
Fax: 01628 765 001

H3G Base Station Information line:
0845 6043000
Available 8am-8pm Monday to Friday

Design Consultant & Principal Contractor:



Site Name: **PARK BROW DRIVE**

Site ID: KSY25678


Address: BULLENS ROAD
KIRBY
KNOWSLEY
LIVERPOOL
L32 8TT

Title: 210 PROPOSED H3G SITE PLAN

Project: **H3G DENSIFICATION STREETWORKS**

Purpose of Issue:	PLANNING
-------------------	----------

MBNL Cell ID: KS Y108	3UK Cell ID: L1024
Master Drawing No: KS Y25678 KS Y108 L1024 M001	
Issue: A	

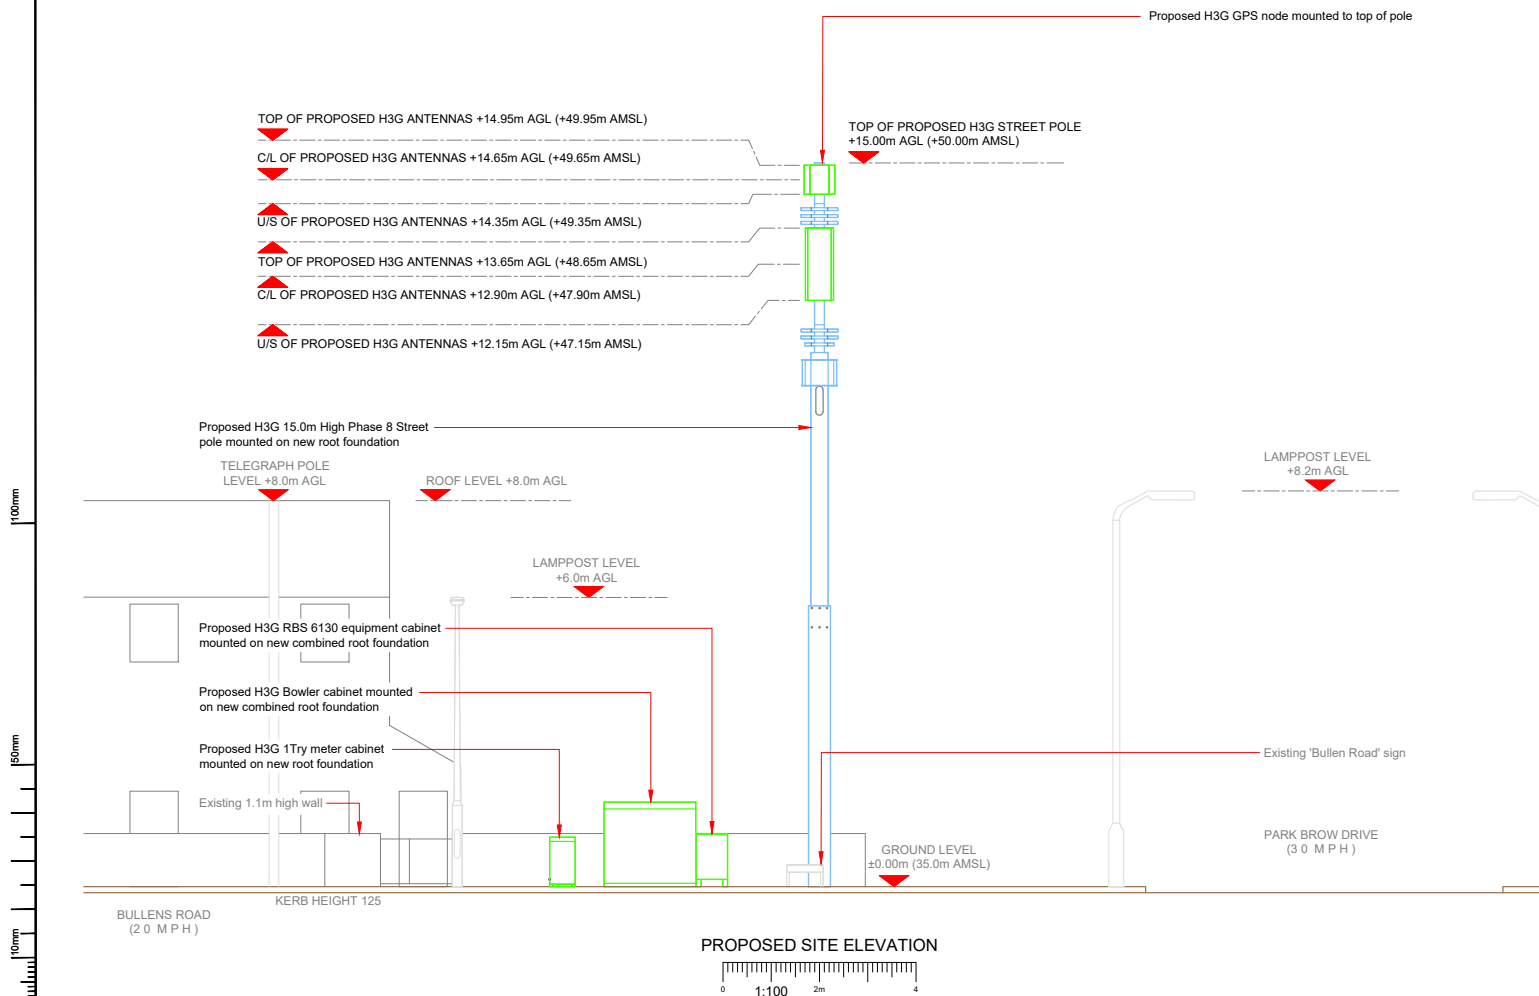

NOTES:

- ALL DIMENSIONS IN MM UNLESS OTHERWISE NOTED.

Model	Model Ref (H3G)	Project	Proposed Elevation	Issue
M001	H3G	DENSIFICATION SW	Planning	A
Date	28/04/2023	Revision (signature/consent)		
Drawn	R. Sweeney	First Issue - Site nomination dated: 13-03-2023		
Checked	G. Thomas			
Approved	G. Thomas			

3

Signal Infrastructure UK Limited (formerly known as CK Hutchison Networks (UK) Limited) (a company registered in England and Wales with company number 12855914) (a Hutchison 3G UK Limited (a company registered in England & Wales with company number 03855486))

Green Park, 450 Longwater Avenue
Reading, RG2 6GF
Tel: 01628 785 000
Fax: 01628 785 001

H3G Base Station Information line:
0845 6043000
Available 8am-8pm Monday to Friday

Design Consultant & Principal Contractor:

CLARKE
telecom

Unit 6, Madison Place, Northampton Road,
Manchester, M40 5AG
Tel: 0161 785 4500 Fax: 0161 785 4501
Web: www.clarke-telecom.com

Site Name: **PARK BROW DRIVE**Site ID: **KS Y25678**Address: **BULLENS ROAD
KIRBY
KNOWSLEY
LIVERPOOL
L32 8TT**Title: **260 PROPOSED H3G ELEVATION**Project: **H3G DENSIFICATION STREETWORKS**Purpose of Issue: **PLANNING**

MBNL Cell ID:	3UK Cell ID:
KS Y108	L1024
Master Drawing No: KS Y25678_KS Y108_L1024_M001	
Issue: A	