



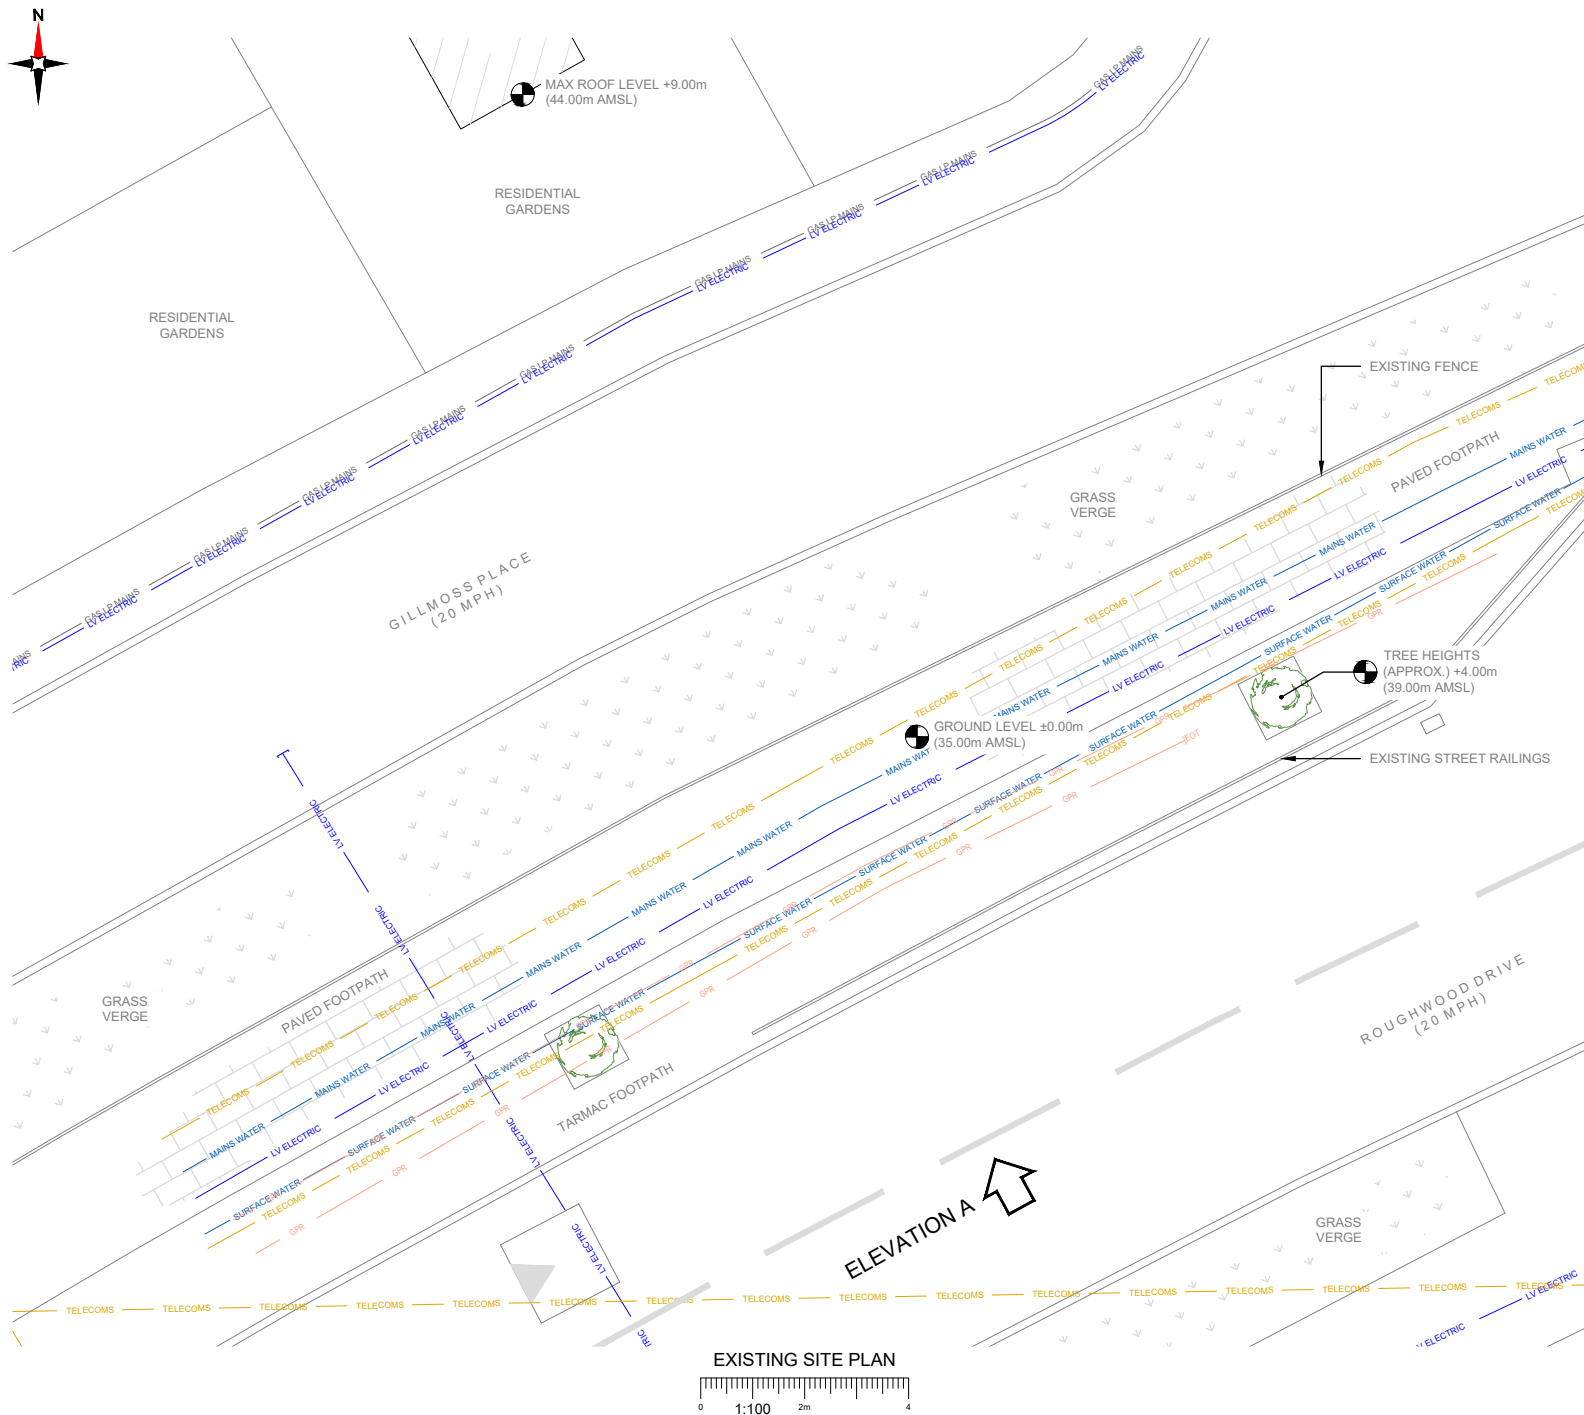

NOTES:

1. ALL DIMENSIONS IN MM UNLESS OTHERWISE NOTED.

SERVICES:

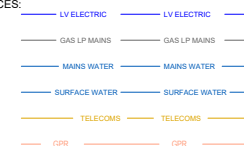

Master:	MBNL / EE / H3G:	Project:	Purpose of Issue:	Issue:
M001	H3G	DENSIFICATION SW	Planning	A
Date:	07/03/2023	Revision / Upgrade Description:		
Drawn:	W.Weston	First Issue		
Checked:	G.Thomas			
Approved:	G.Thomas			



Hutchison 3G UK Limited
Green Park, 450 Longwater Avenue
Reading, RG30 3UR
Tel: 01628 765 000
Fax: 01628 765 001

H3G Base Station Information line:
0845 6043000
Available 8am-8pm Monday to Friday

Design Consultant & Principal Contractor:

CLARKE
telecom
Unit E, Madison Place, Northampton Road,
Manchester, M40 5AG
Tel: 0161 785 4500 Fax: 0161 785 4501
Web: www.clarke-telecom.com

Site Name: **ROUGHWOOD DRIVE**

Site ID: **KSU25680**

Address:
**ROUGHWOOD DRIVE,
KIRKBY,
LIVERPOOL, MERSEYSIDE,
L33 9UN**


Title: **100 EXISTING SITE PLAN**

Project: **H3G DENSIFICATION STREETWORKS**

Purpose of Issue: **PLANNING**

EE Cell ID: 83374	MBNL Cell ID: KSU098	3UK Cell ID: L1026
-----------------------------	--------------------------------	------------------------------

Master Drawing No: KSU25680_KSU098_L1026_83374_M001_H3G_DNSW_GA_A	Issue: A
---	--------------------

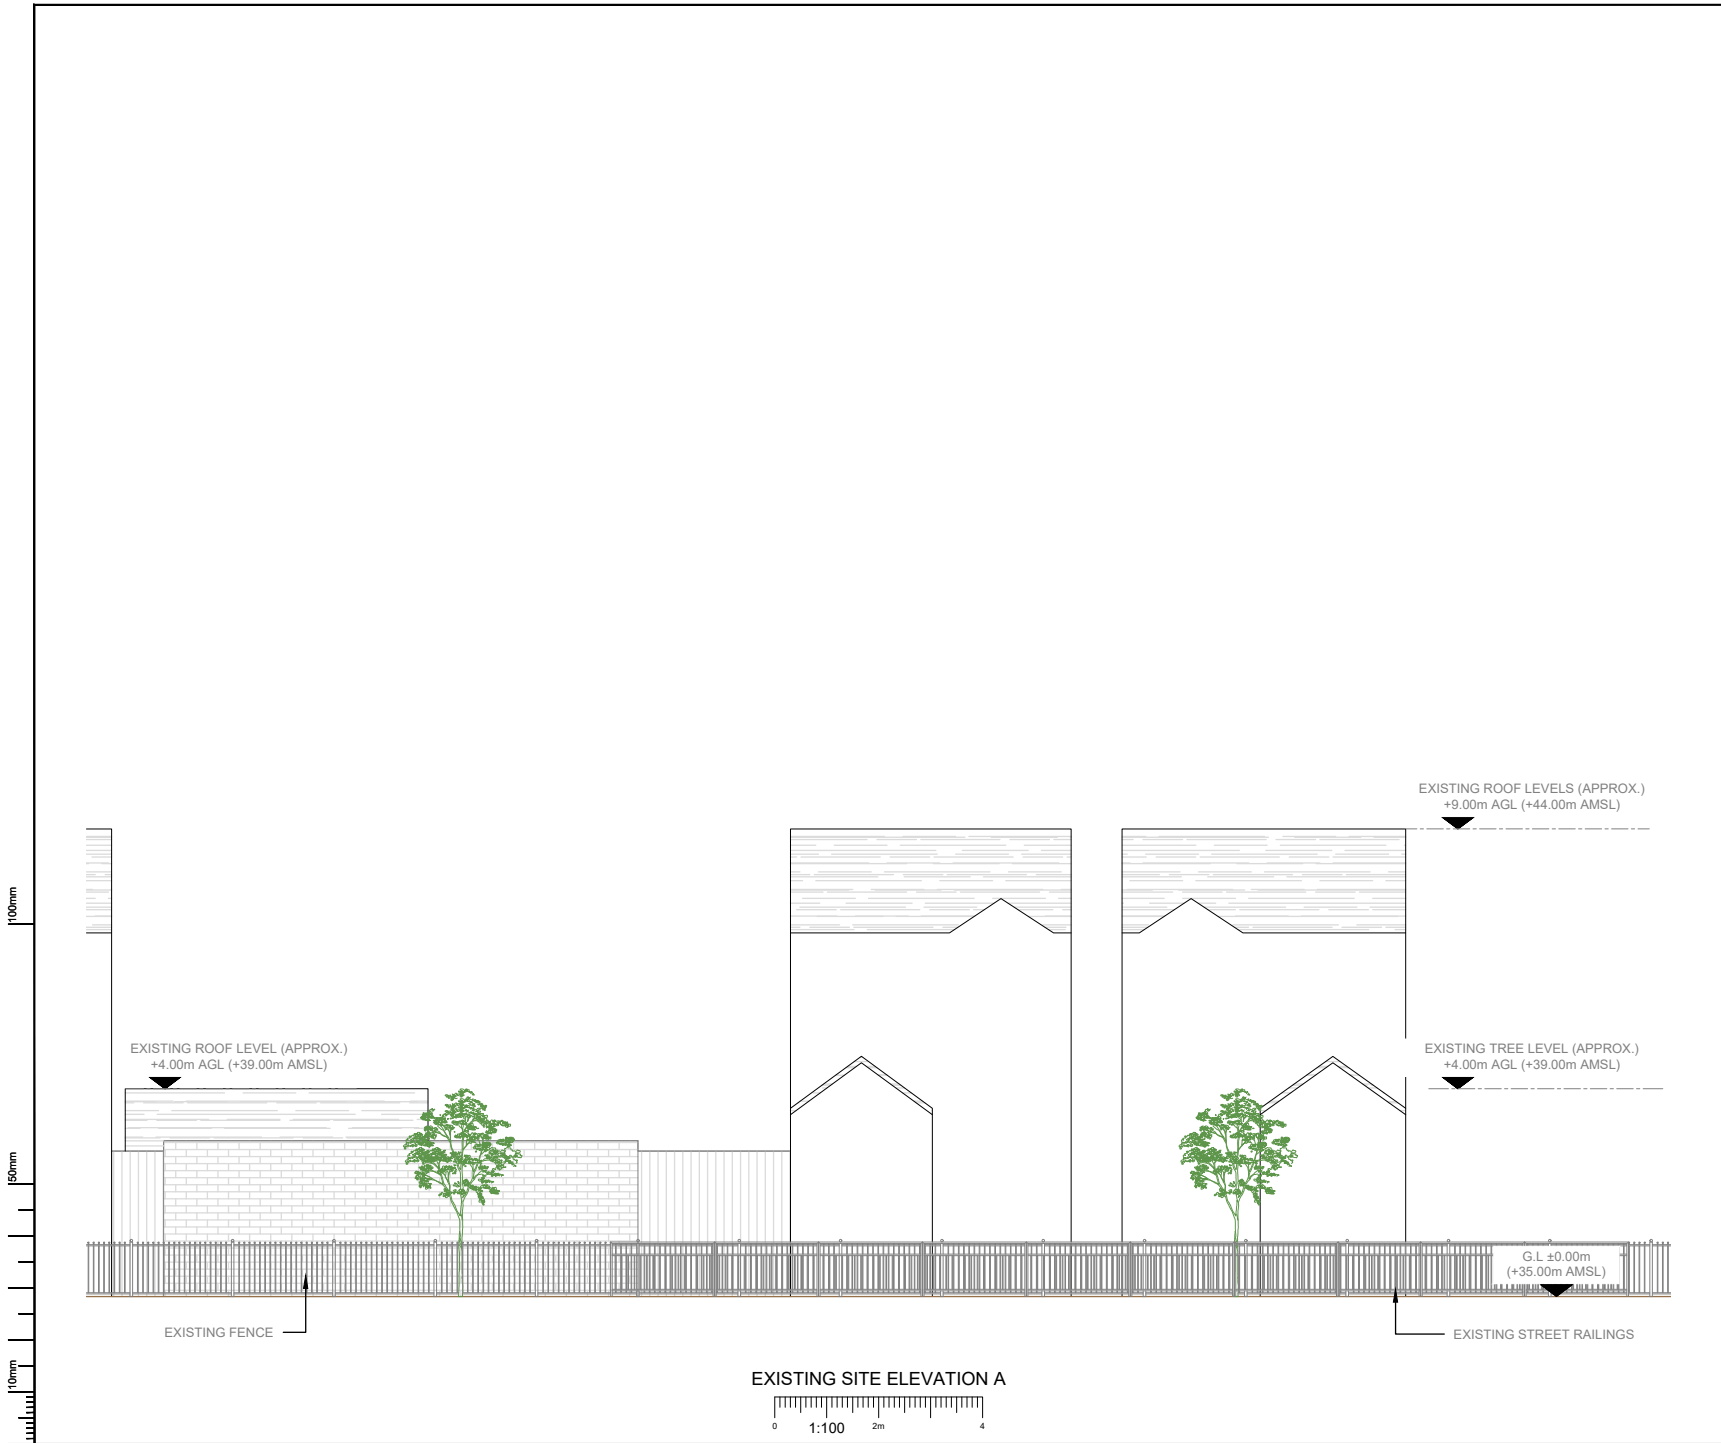

NOTES:

1. ALL DIMENSIONS IN MM UNLESS OTHERWISE NOTED.

Master:	MBNL / EE / H3G	Project:	DENSIFICATION SW		Purpose of Issue:	Planning	Issue:	A
M001	H3G	Date:	07/03/2023	Revision / Upgrade Description:				
		Drawn:	W. Weston	First Issue				
		Checked:	G. Thomas					
		Approved:	G. Thomas					



Hutchison 3G UK Limited
Green Park, 450 Longwater Avenue
Reading, RG30 3UR
Tel: 01628 765 000
Fax: 01628 765 001

H3G Base Station Information line:
0845 6043000
Available 8am-8pm Monday to Friday

Design Consultant & Principal Contractor:



CLARKE
telecom
Unit E, Madison Place, Northampton Road,
Manchester, M40 5AG
Tel: 0161 785 4500 Fax: 0161 785 4501
Web: www.clarke-telecom.com

Site Name:

ROUGHWOOD DRIVE

Site ID:

KS Y25680

Address:

ROUGHWOOD DRIVE,
KIRKBY,
LIVERPOOL, MERSEYSIDE,
L33 9UN

Title:

150 EXISTING SITE ELEVATION A

Project:

H3G DENSIFICATION STREETWORKS

Purpose of Issue:

PLANNING


EE Cell ID:	MBNL Cell ID:	3UK Cell ID:
83374	KS Y098	L1026

Master Drawing No:

KS Y25680_KS Y098_L1026_83374_M001_H3G_DNSW_GA_A

Issue:

A

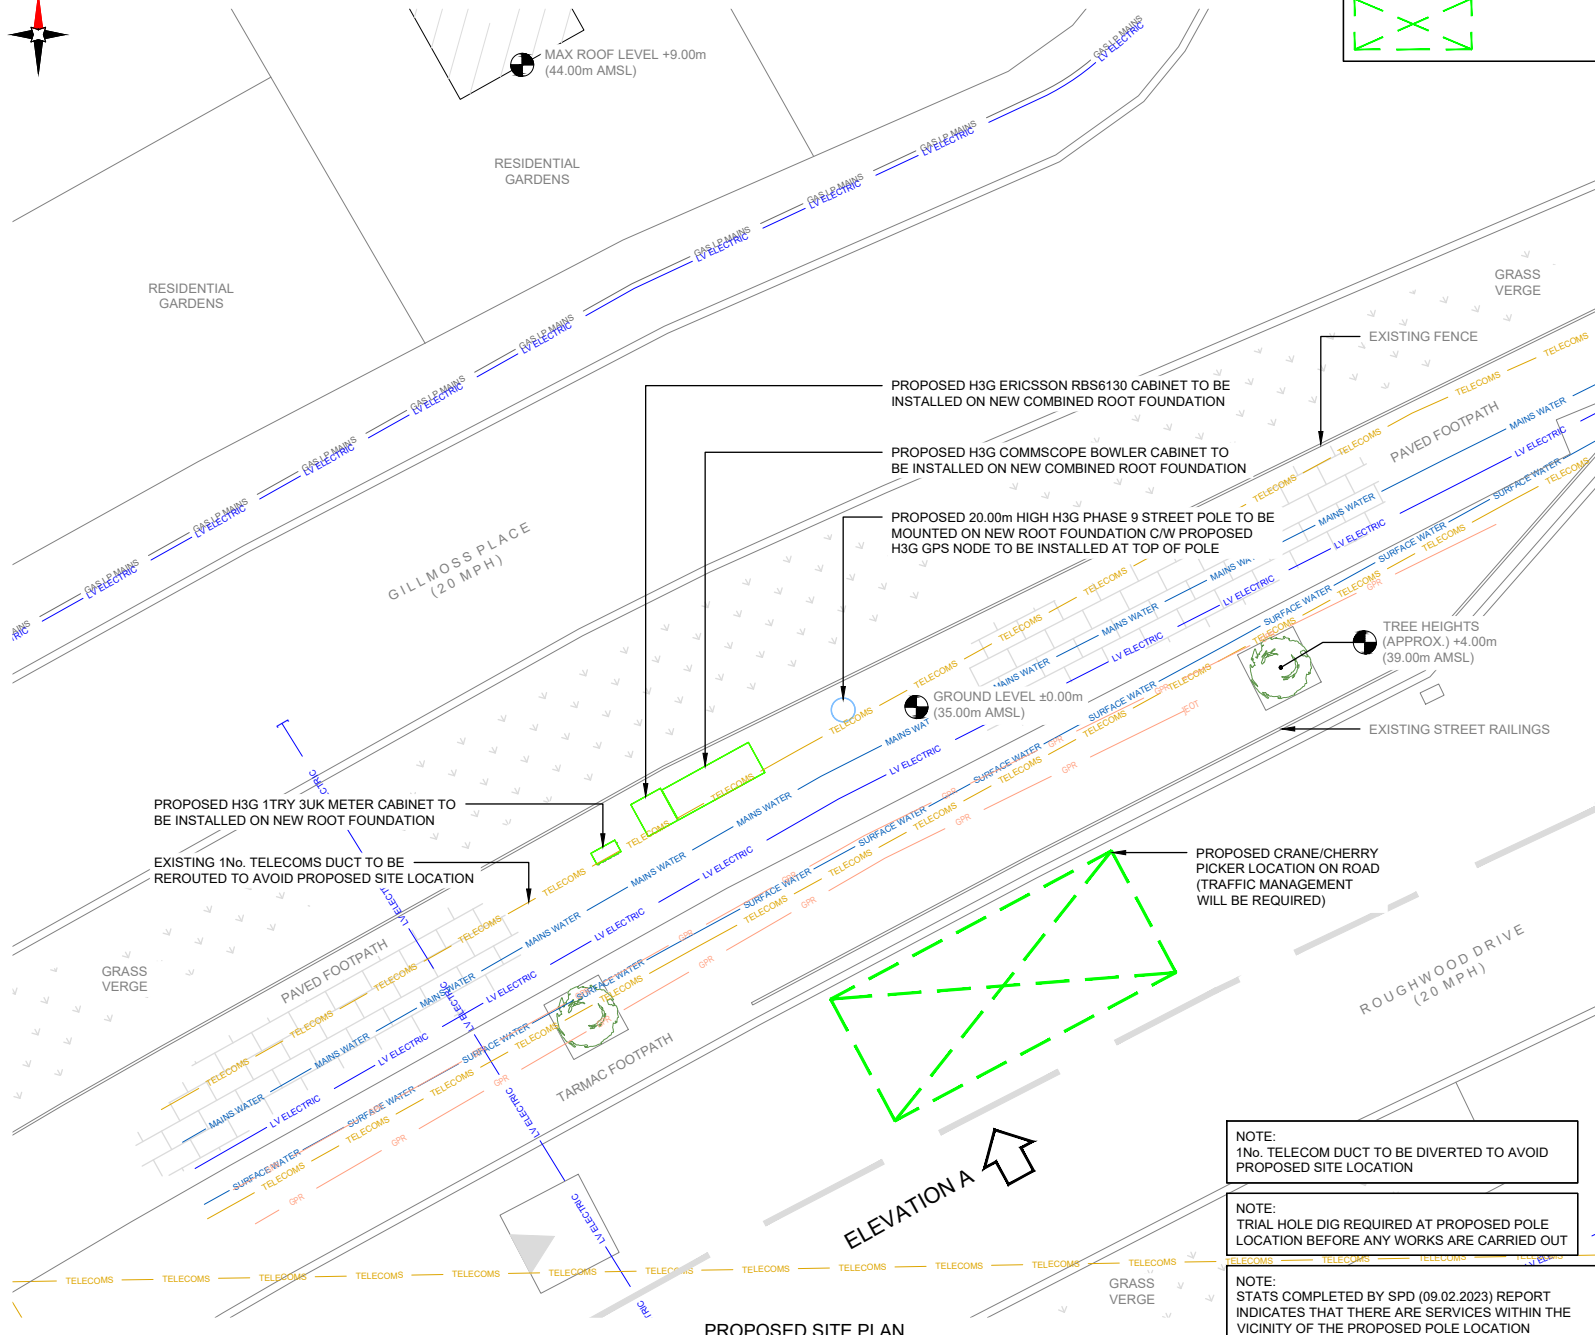

PROPOSED CRANE OR CHERRY PICKER LOCATION:

The diagram shows a 2x3 grid of green line segments. The top row consists of three horizontal line segments. The bottom row consists of three vertical line segments. In the center of the grid, there is a green 'X' formed by two diagonal line segments crossing each other. This diagram likely represents a proposed layout for crane or cherry picker locations and their movement paths.

NOTES:

1. ALL DIMENSIONS IN MM UNLESS OTHERWISE NOTED.

SERVICES:

_____ LV ELECTRIC _____	_____ LV ELECTRIC _____
_____ GAS LP MAINS _____	_____ GAS LP MAINS _____
_____ MAINS WATER _____	_____ MAINS WATER _____
_____ SURFACE WATER _____	_____ SURFACE WATER _____
_____ TELECOMS _____	_____ TELECOMS _____
_____ GPR _____	_____ GPR _____

Master:	MBNL / EE / HDG	Project:	Purpose of Issue:	Issue:
M001	H3G	DENSIFICATION SW	Planning	A
Date:	07/03/2023	Revision / Upgrade Description: First Issue		
Drawn:	W.Veston			
Checked:	G.Thomas			
Approved:	G.Thomas			



Hutchison 3G UK Limited
 Green Park, 450 Longwater Avenue
 Reading, RG30 3UR
 Tel: 01628 765 000
 Fax: 01628 765 001


H3G Base Station Information line:
 0845 8043000
 Available 8am-8pm Monday to Friday

Design Consultant & Principal Contractor:


Unit E, Madison Place, Northampton Road,
Manchester, M40 5AG
Tel: 0161 785 4500 Fax: 0161 785 4501
Web: www.clarke-telecom.com

Site Name:			
ROUGHWOOD DRIVE			
Site ID:			
KSY25680			
Address:			
ROUGHWOOD DRIVE, KIRKBY, LIVERPOOL, MERSEYSIDE, L33 9UN			
Title:			
210 PROPOSED SITE PLAN			
Project:			
H3G DENSIFICATION STREETWORKS			
Purpose of Issue:			
PLANNING			
EE Cell ID:	MBNL Cell ID:	3UK Cell ID:	
83374	KSY098	L1026	
Master Drawing No:			Issue:
KSY25680_KSY098_L1026_83374_M001_H3G_DNSW_GA_A			A

NOTES:
1. ALL DIMENSIONS IN MM UNLESS OTHERWISE NOTED.

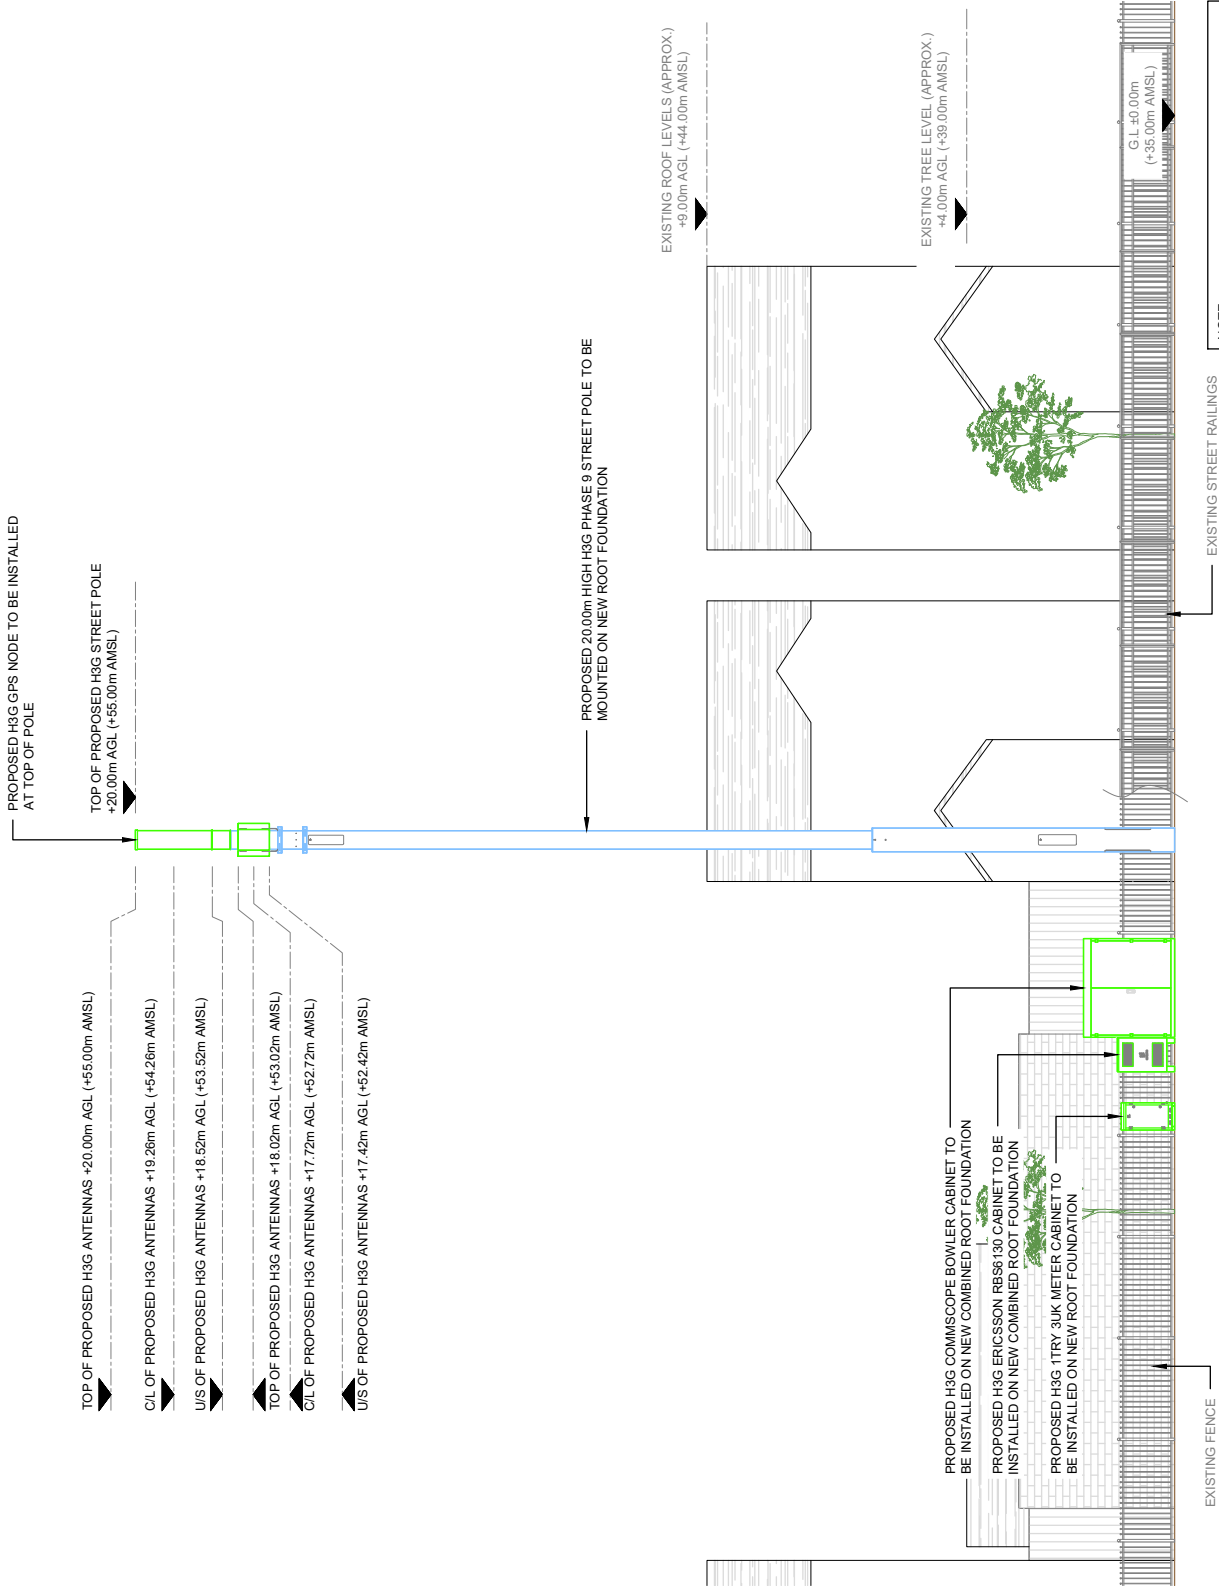

Revision	By	Date	Description
01	W. Wilson	07/03/2023	Initial Design
02	G. Thompson	07/03/2023	Final Issue

Hutchison 3G UK Limited
Green Park, 450 Longwater Avenue
Reading, RG20 3UR
Tel: 01628 765 000
Fax: 01628 765 001

H3G Base Station Information line:
0845 604 5000
Available 8am-6pm Monday to Friday

CLARKE telecom
Unit E, Madison Place, Northampton Road,
Tel: 0161 785 4500 Fax: 0161 785 4501
Web: www.clarke-telecom.com

Design Consultant & Principal Contractor:

Site Name: **ROUGHWOOD DRIVE**

Site ID: **KSY25680**

Address: **ROUGHWOOD DRIVE,
KIRKBY,
LIVERPOOL, MERSEYSIDE,
L33 9UN**

Title: **260 PROPOSED SITE ELEVATION A**

Project: **H3G DENSIFICATION STREETWORKS**

Purpose of Issue: **PLANNING**

EE Call ID: **83374** MRE Call ID: **KSY098** 3UK Call ID: **L1026**

Master Drawing No: **KSY25680_KSY098_L_1026_83374_M001_H3G_DNSW_GA_A**

Issue: **A**