


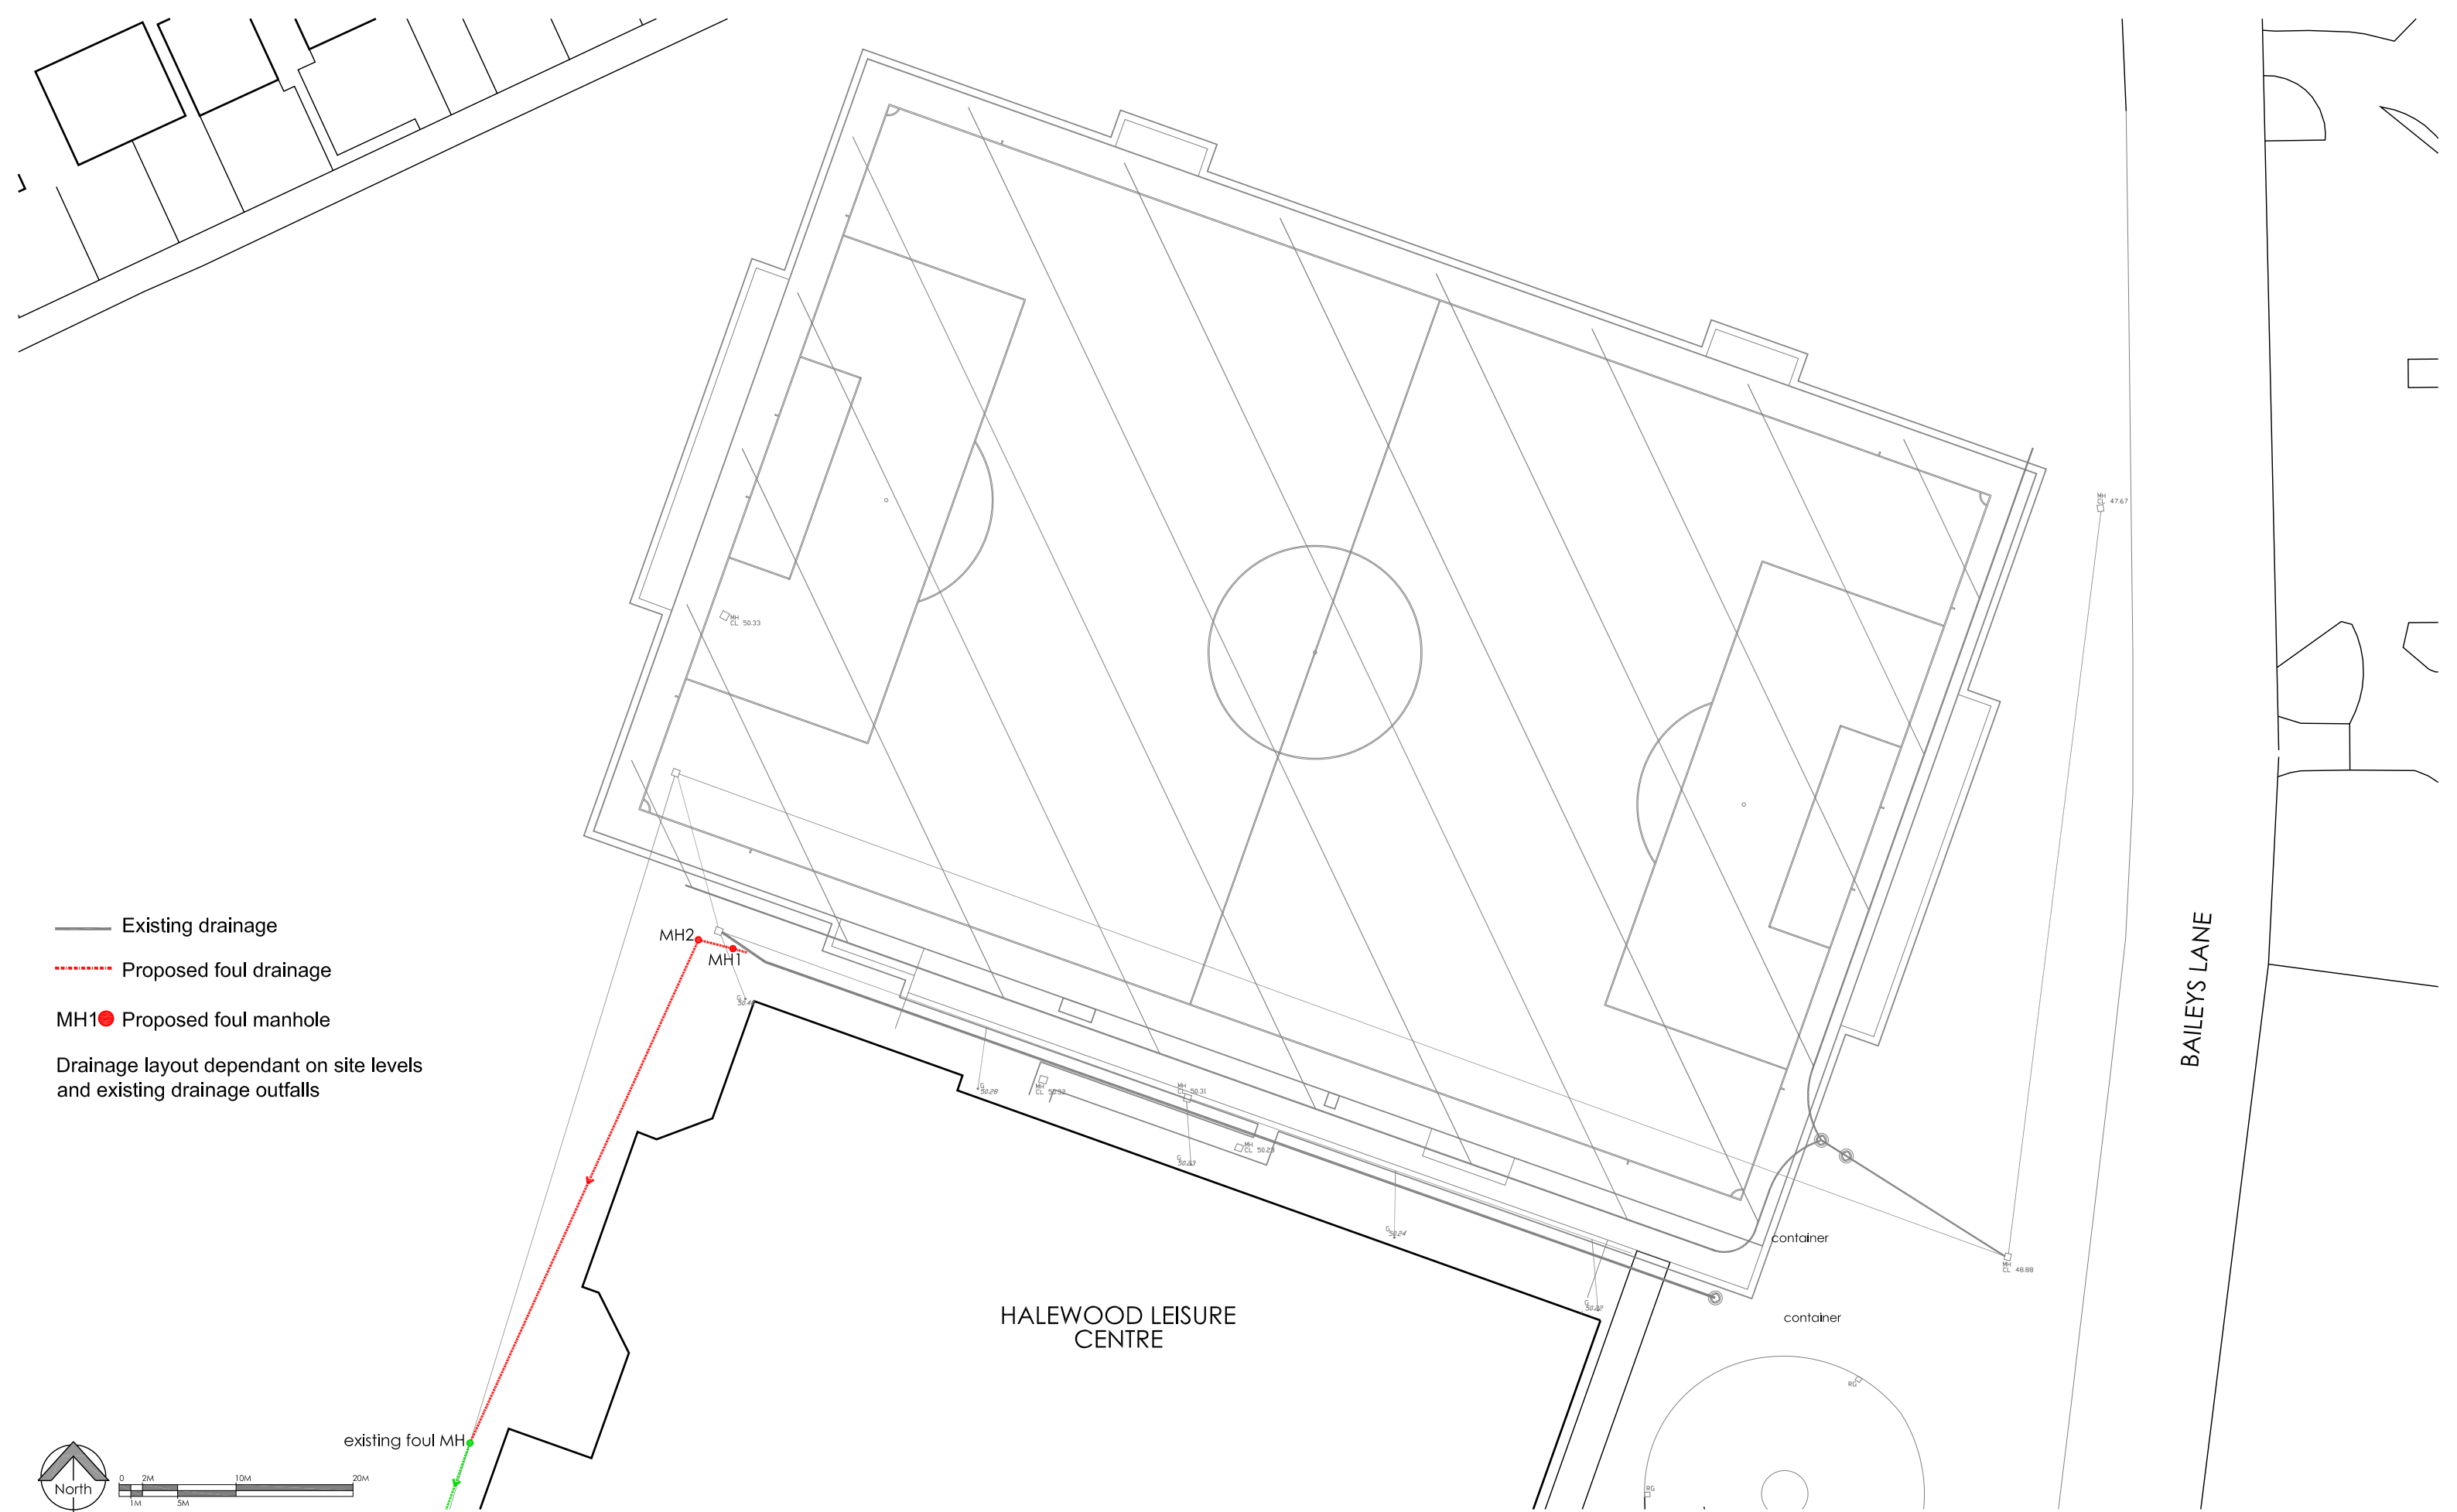


Existing drainage

Proposed foul drainage

MH1● Proposed foul manhole

Drainage layout dependant on site levels
and existing drainage outfalls

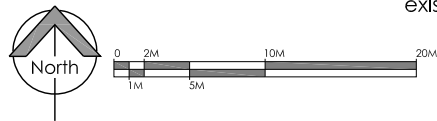

Copyright Notice:
This drawing is the copyright of Steve Wells Associates
and shall not be reproduced without permission. © 2024

Dwg. Purpose **Planning**

No.	Revision / Issue	Date
-----	------------------	------

Project	Client
Proposed AGP Alterations at Halewood Apollo FC Baileys Lane, Halewood Liverpool, L26 0TY	Knowsley Council
Dwg. Title	Proposed Site Drainage Plan



Churchill House, Mill Hill, Pontefract, West Yorkshire,
WF8 4HY t : 01977 797258 e: mail@stevewells-associates.com

Dwg. No. 205-104-1009		Rev.
Scale 1:500 @ A3	Date October 2024	
Drawn by GSB	Checked DKW	