



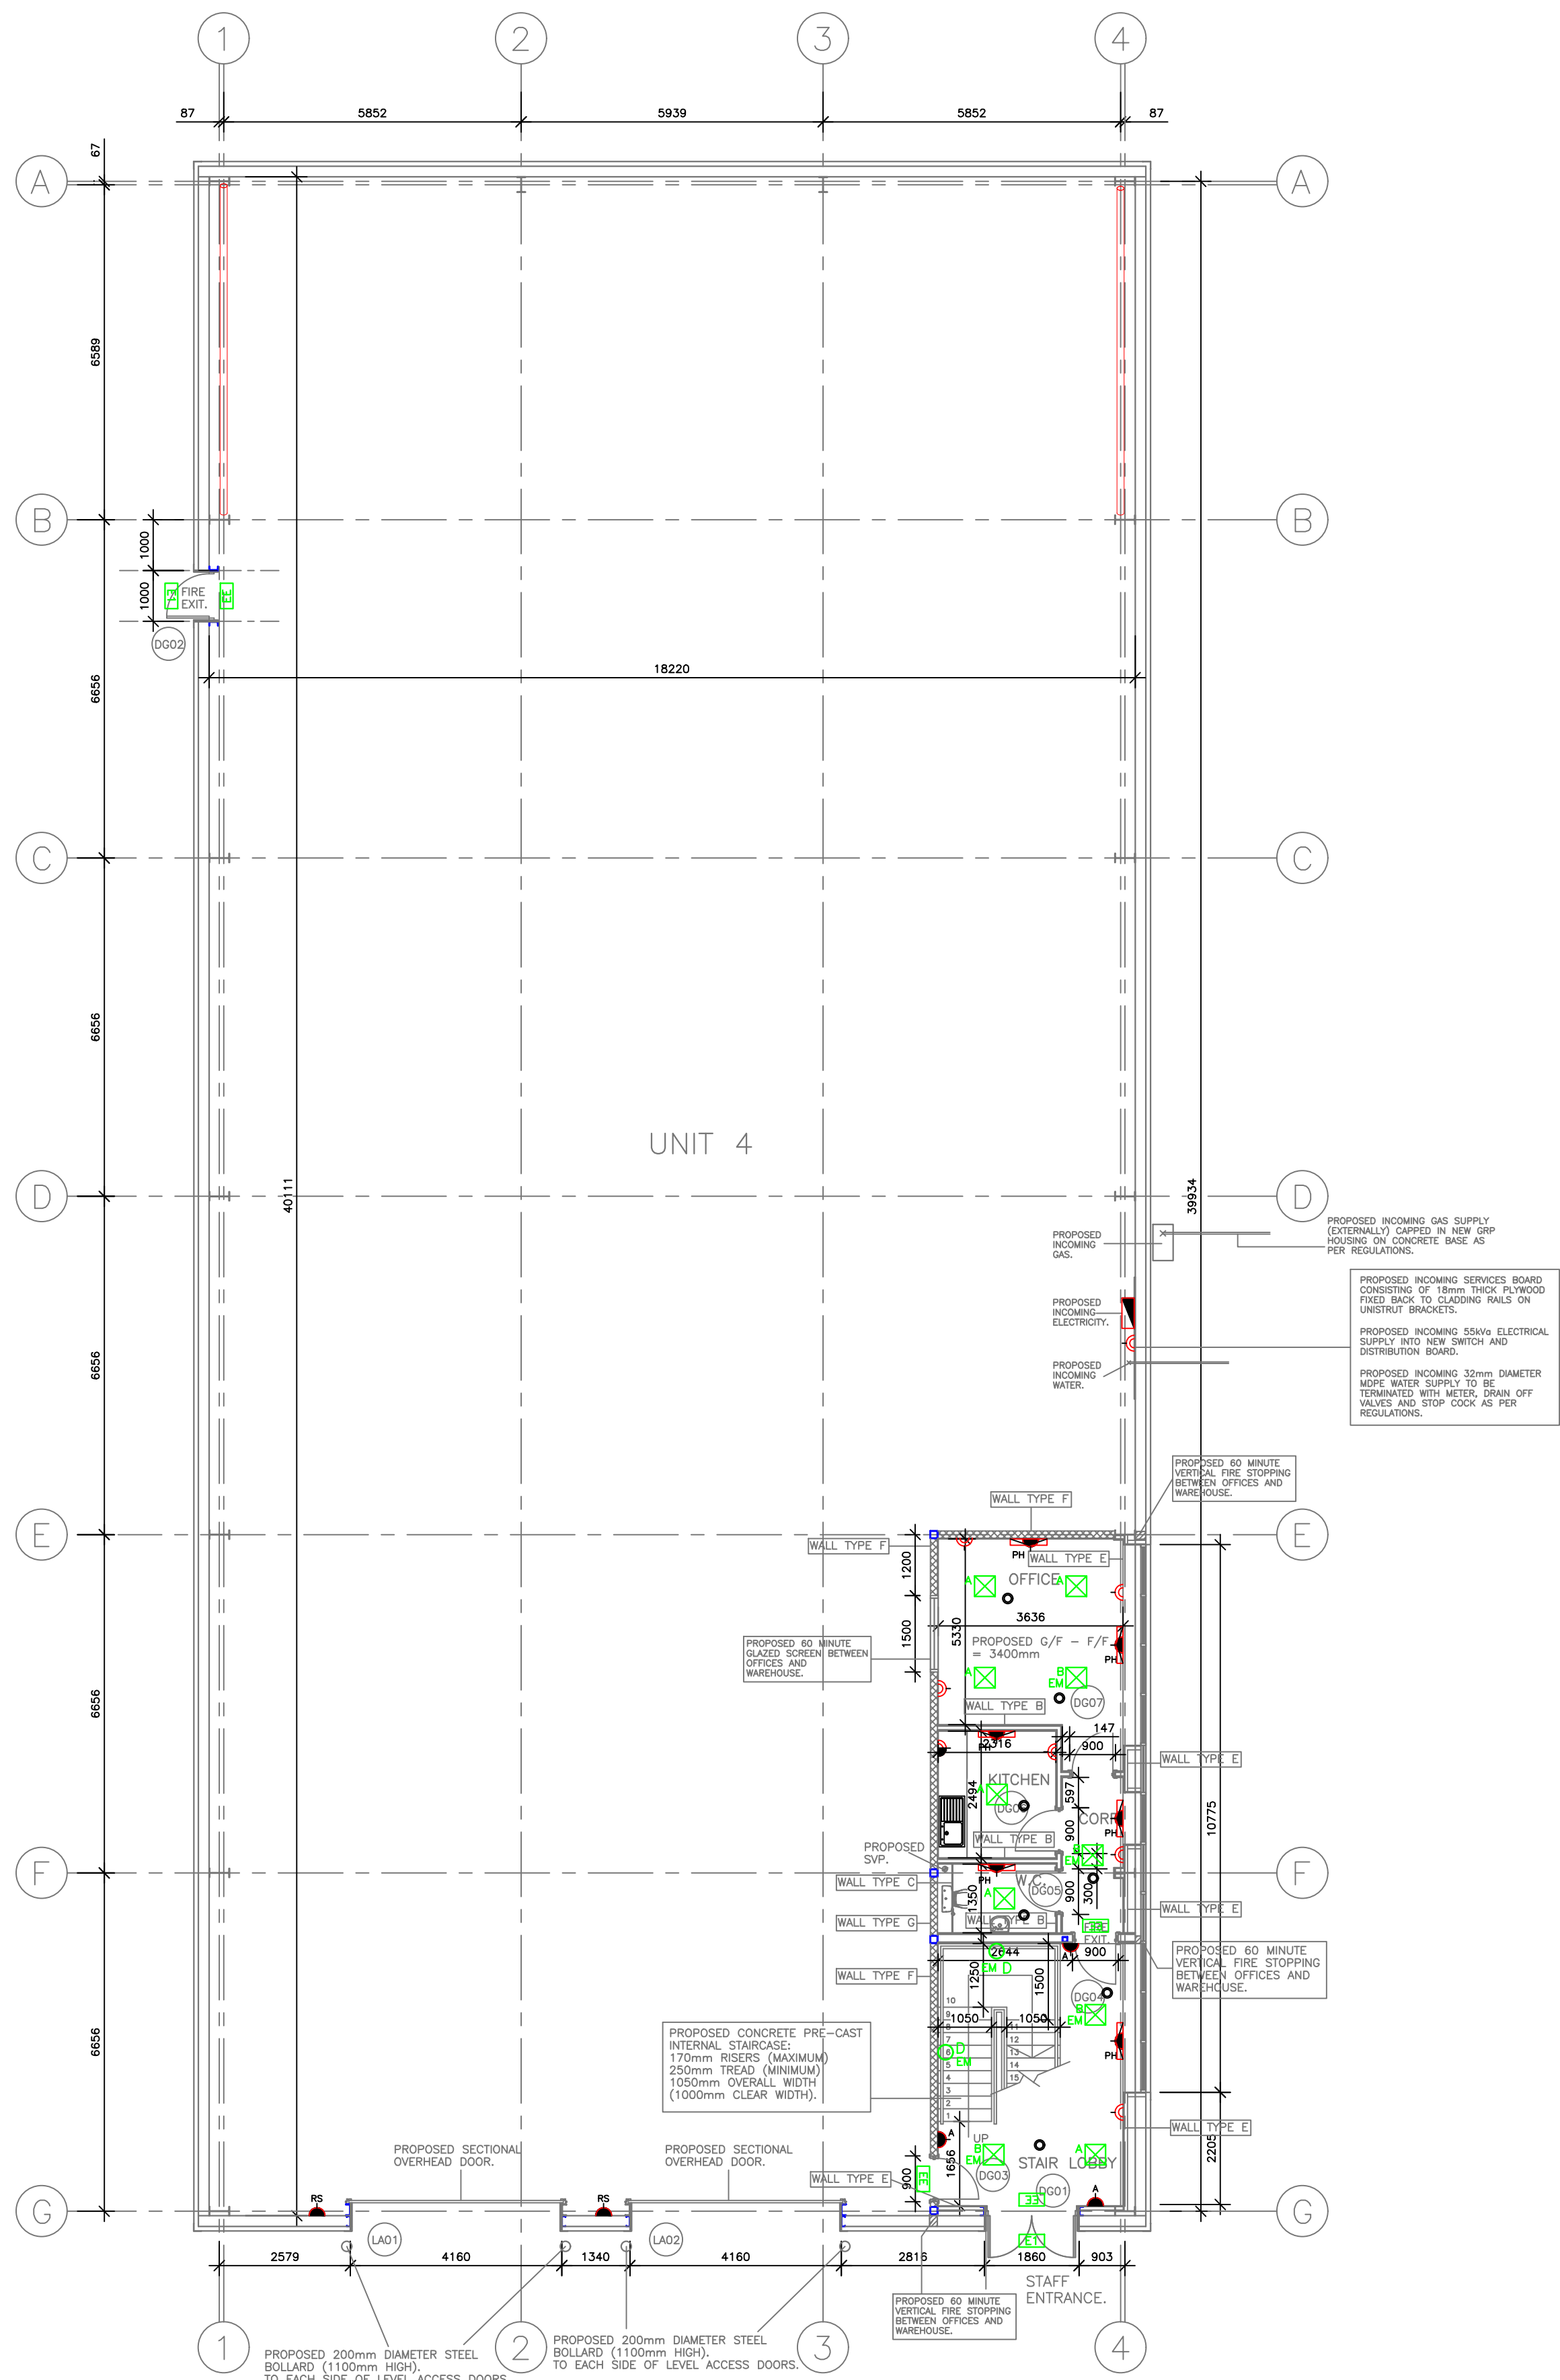

PROPOSED GROUND FLOOR PLAN. (UNIT 4).
SCALE 1:100

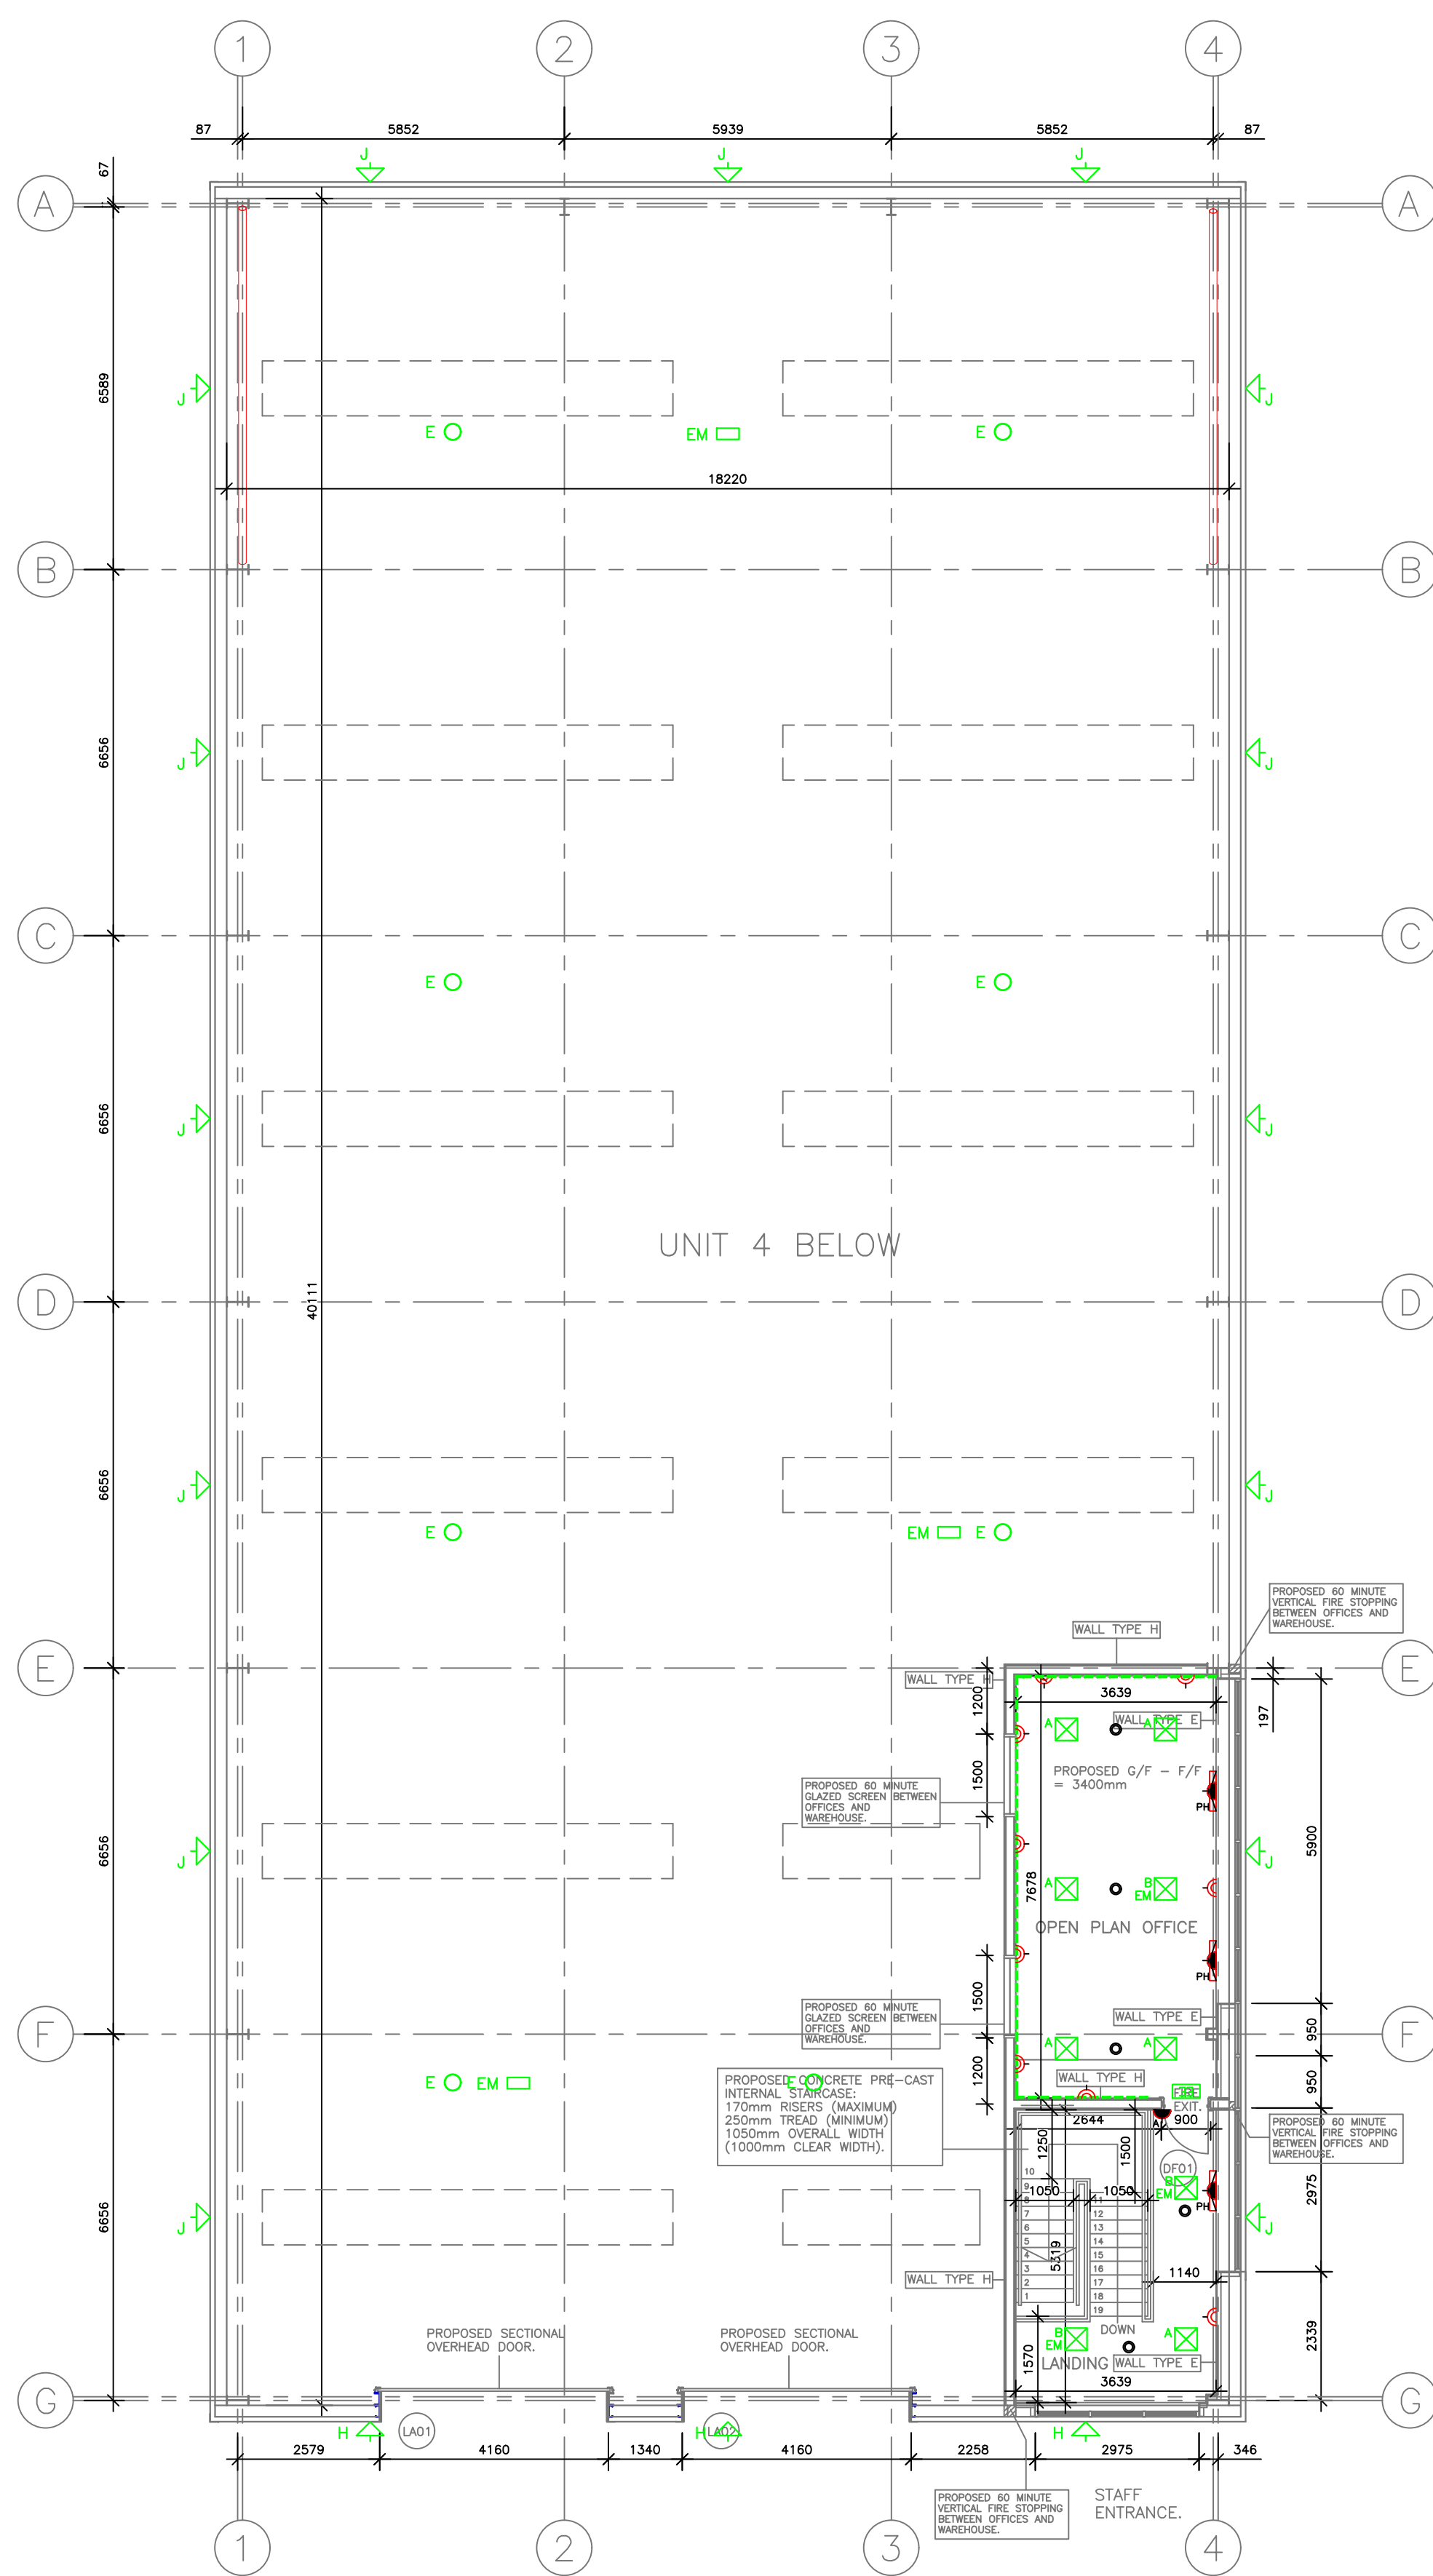

PROPOSED FIRST FLOOR PLAN. (UNIT 4).
SCALE 1:100

POWER AND LIGHTING LEGEND	
	PROPOSED NEW DISTRIBUTION BOARD
	13A TWIN SWITCHED SOCKET OUTLET AT LOW LEVEL
	13A TWIN SWITCHED SOCKET OUTLET ABOVE DESK/WORK TOP
	13A SINGLE UNSWITCHED SOCKET OUTLET AT LOW LEVEL FOR KITCHEN APPLIANCE
	13A SINGLE SWITCHED SOCKET OUTLET AT LOW LEVEL FOR FRIDGE/FREEZER
	13A SINGLE SWITCHED SOCKET OUTLET AT LOW LEVEL FOR OVEN
	13A UN-SWITCHED FUSED SPUR FOR FIRE ALARM PANEL
	13A UN-SWITCHED FUSED SPUR FOR ACCESS CONTROL
	13A SWITCHED FUSED SPUR FOR ELECTRIC WATER HEATER
	13A SWITCHED FUSED SPUR FOR HEAT RECOVERY UNIT
	13A SWITCHED FUSED SPUR FOR AIR CONDITIONING UNIT
	13A SWITCHED FUSED SPUR FOR ROLLER SHUTTER
	13A UN-SWITCHED FUSED SPUR FOR INTRUDER ALARM PANEL
	13A SWITCHED FUSED SPUR FOR ELECTRIC PANEL HEATER
	13A SWITCHED FUSED SPUR FOR ELECTRIC LST TOWEL RAIL
	LOT 20 COMPLIANT ELECTRIC PANEL HEATER
	TP&N ROTARY ISOLATOR FOR LIFT
	ROTARY ISOLATOR FOR KITCHEN EQUIPMENT
	ROTARY ISOLATOR FOR FLEXIBLE OFFICE UNIT DB
	RJ45 CAT6 DATA OUTLET
	WIRELESS ACCESS POINT
	DISABLED WC ALARM EMERGENCY PULL CORD
	DISABLED WC ALARM INDICATOR UNIT C/W SOUNDER
	DISABLED WC ALARM RESET BUTTON
	45A COOKER ISOLATION SWITCH WITH LOW LEVEL OUTLET FOR ELECTRIC OVEN/HOB
	DADO TRUNKING
	PROPOSED 600mm x 600mm LED LIGHTING PANEL TO SUSPENDED CEILING
	PROPOSED 600mm x 600mm LED LIGHTING PANEL TO SUSPENDED CEILING (EMERGENCY VERSION)
	PROPOSED LIGHTING MOTION SENSOR TO SUSPENDED CEILING OR OPEN SPACE
	PROPOSED RECESSED DOWNLIGHT TO SUSPENDED CEILING
	PROPOSED WALL MOUNTED LED LIGHT TO STAIRWELL
	PROPOSED 200W LED LIGHTING UNIT TO WAREHOUSE MOUNTED ON BRACKETS FROM STRUCTURE
	PROPOSED 67W LED LIGHTING UNIT 1800mm LONG MOUNTED FOR STEEL STRUCTURE
	PROPOSED 67W LED LIGHTING UNIT 1800mm LONG MOUNTED FOR STEEL STRUCTURE (EMERGENCY VERSION)
	PROPOSED 67W LED LIGHTING UNIT 1500mm LONG MOUNTED FOR STEEL STRUCTURE
	PROPOSED 67W LED LIGHTING UNIT 1500mm LONG MOUNTED FOR STEEL STRUCTURE (EMERGENCY VERSION)
	PROPOSED 6W LED BULKHEAD EMERGENCY LIGHT FITTING (EMERGENCY VERSION)
	LED NON MAINTAINED ILLUMINATED EMERGENCY EXIT SIGN COMPLETE WITH RELEVANT RUNNING MAN LEGEND AND 3HR BATTERY BACKUP
	LED NON MAINTAINED EMERGENCY BULKHEAD FITTING COMPLETE WITH 3HR BATTERY BACKUP
	EXTERNAL 160W AZTEC FLOODLIGHT ASYMETRIC 4000K TO WAREHOUSE YARDS (LED)
	EXTERNAL 28W FLOODLIGHT TO WAREHOUSE PATHS 4000K (LED)

PROPOSED UNIT 4 – GROUND FLOOR PLAN.

PROPOSED UNIT 4 – FIRST FLOOR PLAN.

DO NOT SCALE OFF DRAWING : PLEASE CHECK ALL DIMENSIONS ON SITE

This drawing is to be read in conjunction with all relevant specifications, documents and other issued job drawings. Discrepancies or omissions must be reported to the client. The contractor is to check and verify all building and site dimensions and to check levels before work commences.

ALL INFORMATION CONTAINED ON THIS DRAWING REMAINS COPYRIGHT OF PRIME PROPERTY LIMITED ©

Generic Notes:

Client Details:

Project Title:

Project Stage:

Project No:

Drawing No:

Revision:

Issue Date:

Revision Comments:

By:

Specific Notes:

Client Details:

Project Title:

Project Stage:

Project No:

Drawing No:

Revision:

Issue Date:

Revision Comments:

By:

Specific Notes:

Client Details:

Project Title:

Project Stage:

Project No:

Drawing No:

Revision:

Issue Date:

Revision Comments:

By:

Specific Notes:

Client Details:

Project Title:

Project Stage:

Project No:

Drawing No:

Revision:

Issue Date:

Revision Comments:

By:

Specific Notes:

Client Details:

Project Title:

Project Stage:

Project No:

Drawing No:

Revision:

Issue Date:

Revision Comments:

By:

Specific Notes:

Client Details:

Project Title:

Project Stage:

Project No:

Drawing No:

Revision:

Issue Date:

Revision Comments:

By:

Specific Notes:

Client Details:

Project Title:

Project Stage:

Project No:

Drawing No:

Revision:

Issue Date:

Revision Comments:

By:

Specific Notes:

Client Details:

Project Title:

Project Stage:

Project No:

Drawing No:

Revision: