



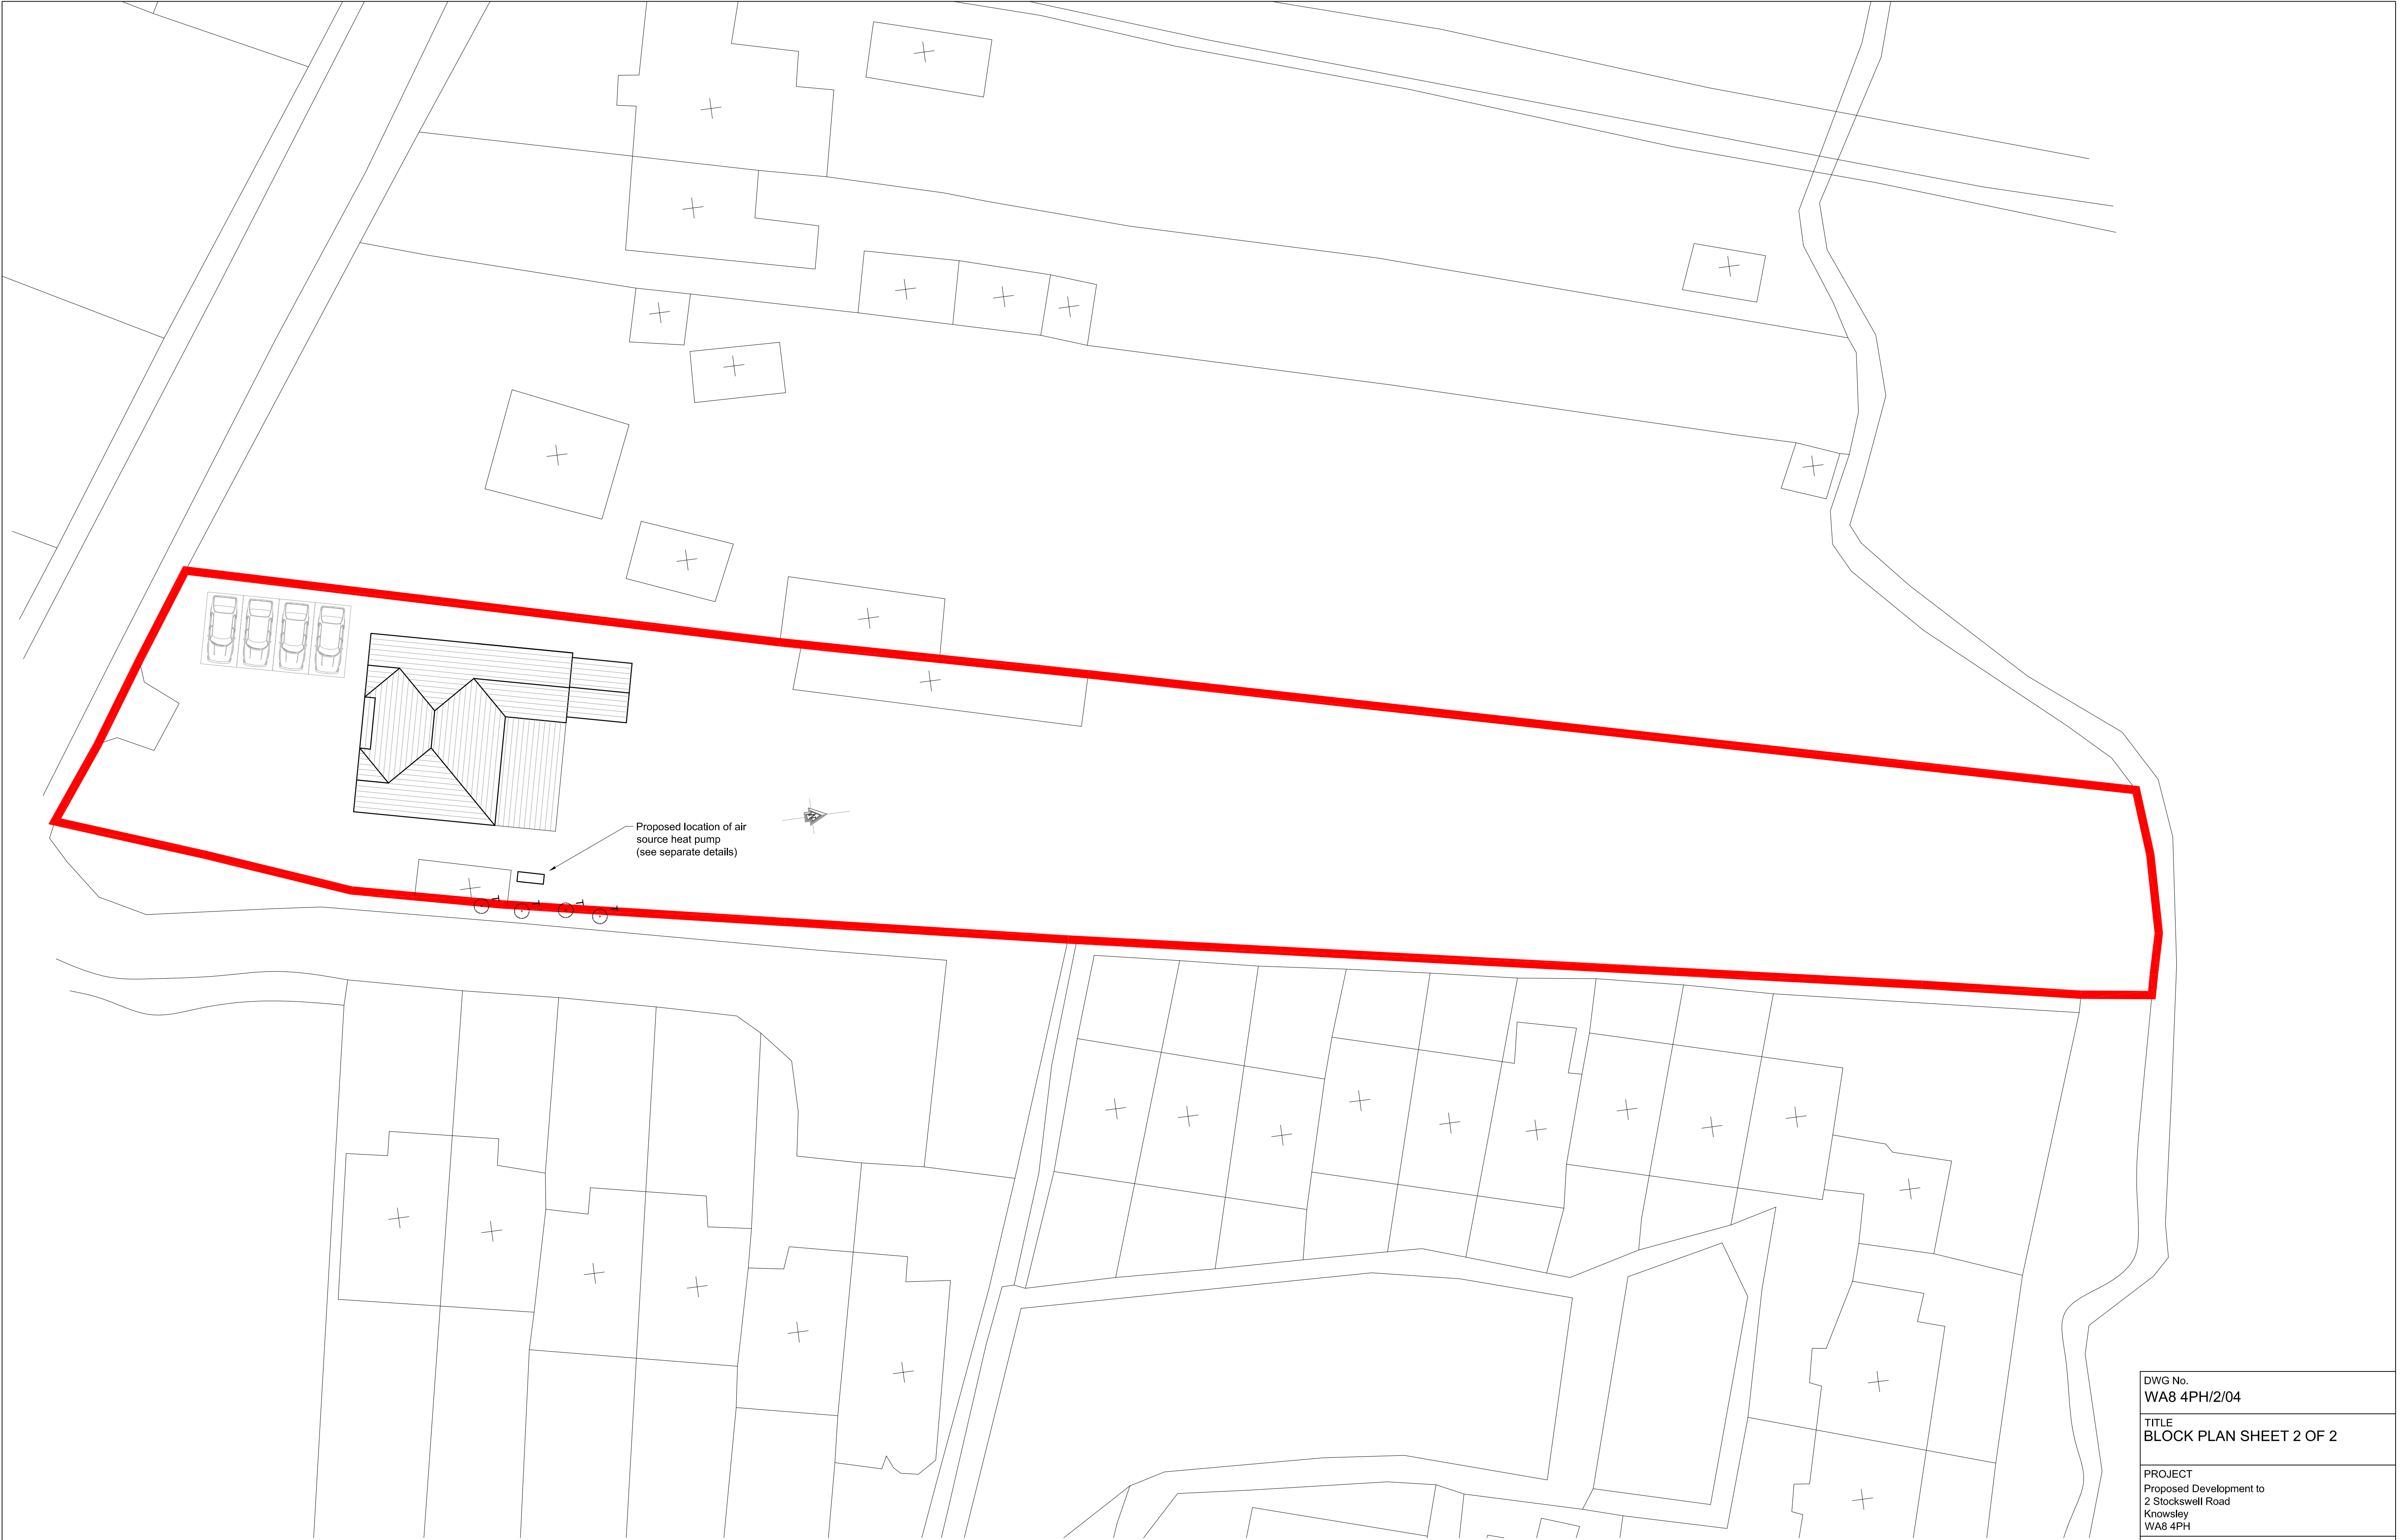

Proposed location of air
source heat pump
(see separate details)

PROPOSED BLOCK, ROOF & SITE PLAN

scale 1:200

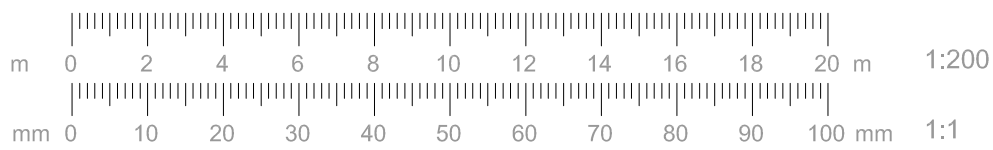

DWG No. WA8 4PH/2/04	
TITLE BLOCK PLAN SHEET 2 OF 2	
PROJECT Proposed Development to 2 Stockswell Road Knowsley WA8 4PH	
CLIENT Mr. S. Liptrott	
DATE	23/01/2025
SCALE AT A1 AS SHOWN	
PRO-TECH ARCHITECTURE	
WWW.PRO-TECHARCHITECTURE.CO.UK CONTACT : LEE ROWLEY B.ENG.(HONS) 0151-420-7895 07967836028 20 ELSTREE COURT WIDNES, WAB 3EP INFO@PRO-TECHARCHITECTURE.CO.UK FOLLOW US ON FACEBOOK @PROTECHARCHITECTURELTD	