
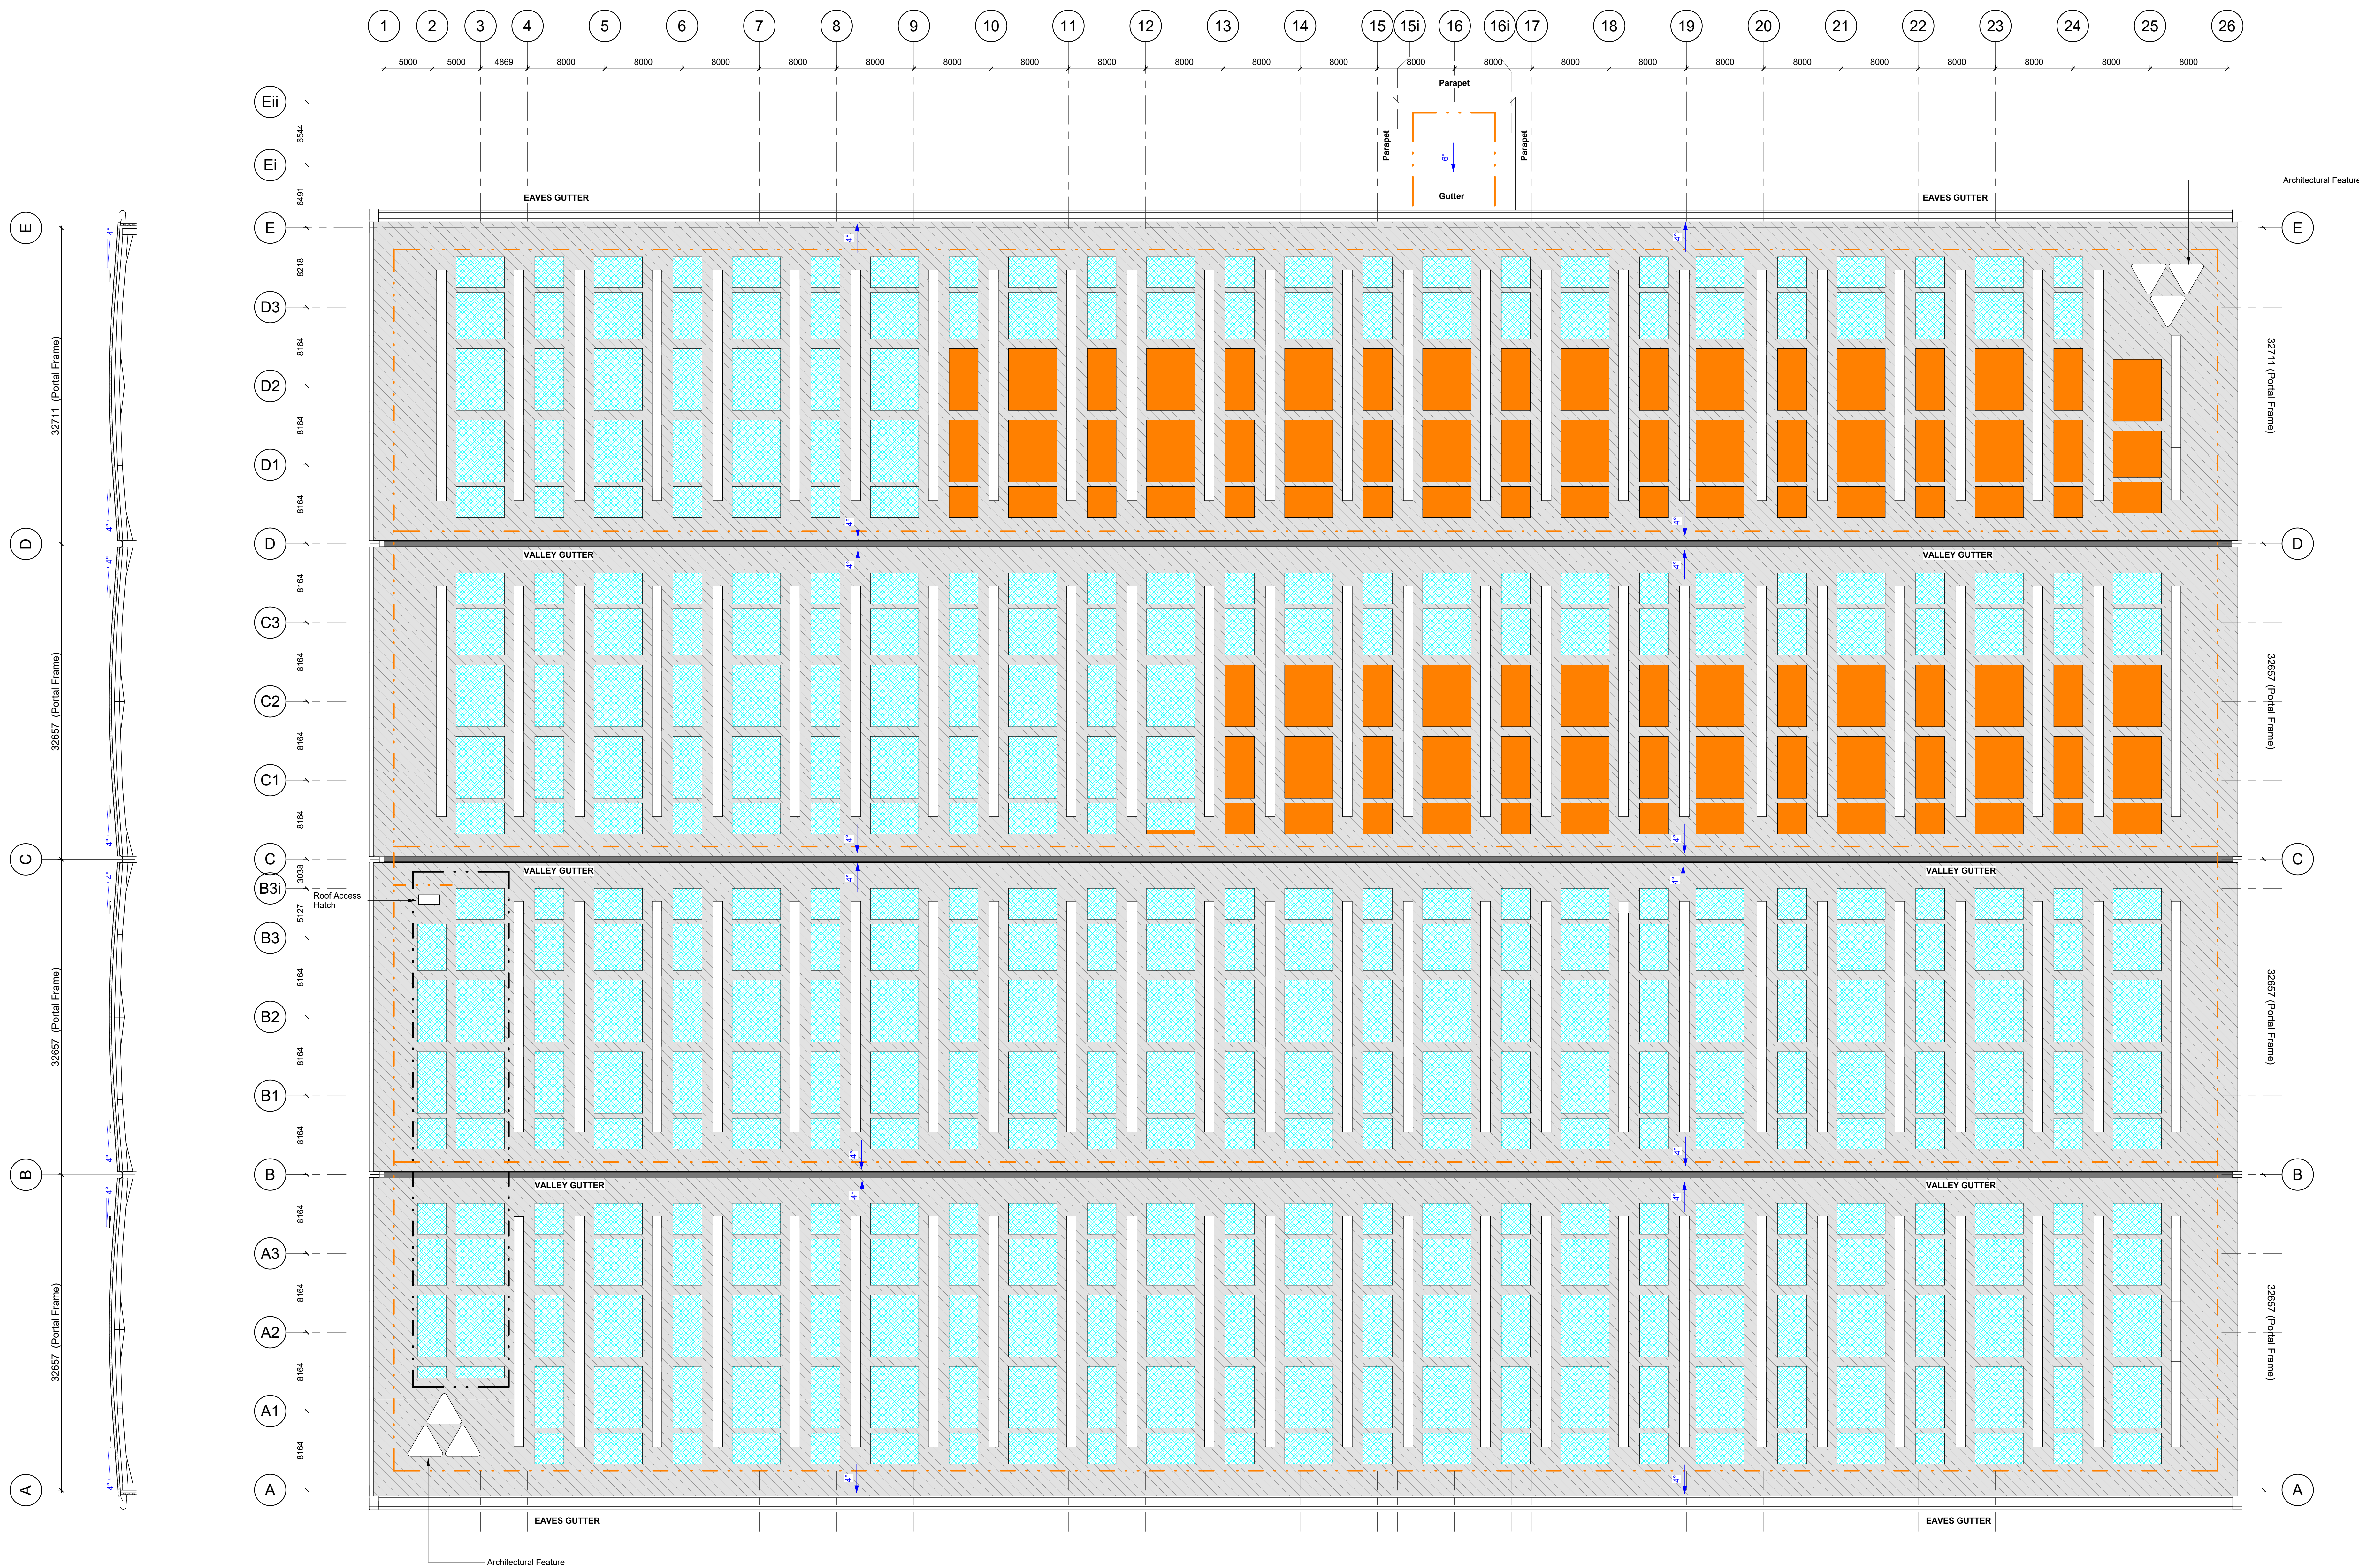


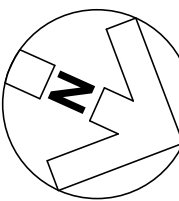

**Roof Plan**  
1 : 250

- Key:**
- Roof lights to equate to 10% of internal floor area, layout shown indicatively.
  - Mansafe system to be Fall restraint to the Main office and Transport office. Layout shown is indicative only and subject to detailed design by main contractor specialist Sub-Contractor, but to provide safe roof access and maintenance to all roof area, including two sets of harnesses and lanyards to satisfy EN 795 and BS 7883.
  - Phase 1: Initial PV Output 334 kW AC
  - Phase 2: Future PV Output 1540 kW AC
- Note:**
- Solar PV Specialist layout out to be consider at a later date to provide an optimal arrangement to maximise the number of panels.
  - No rooflights are to be installed in the roof area directly above the main office accommodation or production area
- Disclaimer:** Full roof deployment will require an additional G99 application and is subject to DNO/NESO approval.

5m SCALE 1:250

rev | amendments | by | dtd | date  
**Unit 03, Symmetry Park,**  
**Merseyside**  
Unit 03 Roof Plan

Information Container LOIN  
LOD 2 LOI 2  
**TRITAX SYMMETRY**  
A TRITAX BIG BOX COMPANY

**umc**  
architects

3rd Floor, Manchester Club, 81 King Street, Manchester, M2 4AH  
144 (0)161 413 0599  
info@umcarchitects.com

RIBA Plan Stage: Stage 2 - Concept Design  
Document Suitability: S2  
Drawn / Checked: MG/ MY  
Date: 25/01/24  
Scale: As indicated @ A0  
UMC Project Number: 22605

Document Reference: Drawing no: Revision:  
22605 - UMC - XXXX - RF - DR - A - 1003 P06

PLANNING  
THE INFORMATION CONTAINED HEREIN IS FOR INFORMATION ONLY AND DOES NOT CONSTITUTE A COMMITMENT OR ENDORSEMENT BY ANY AUTHORITY