


Spillage Isolines

1 lux	
2 lux	
3 lux	
5 lux	

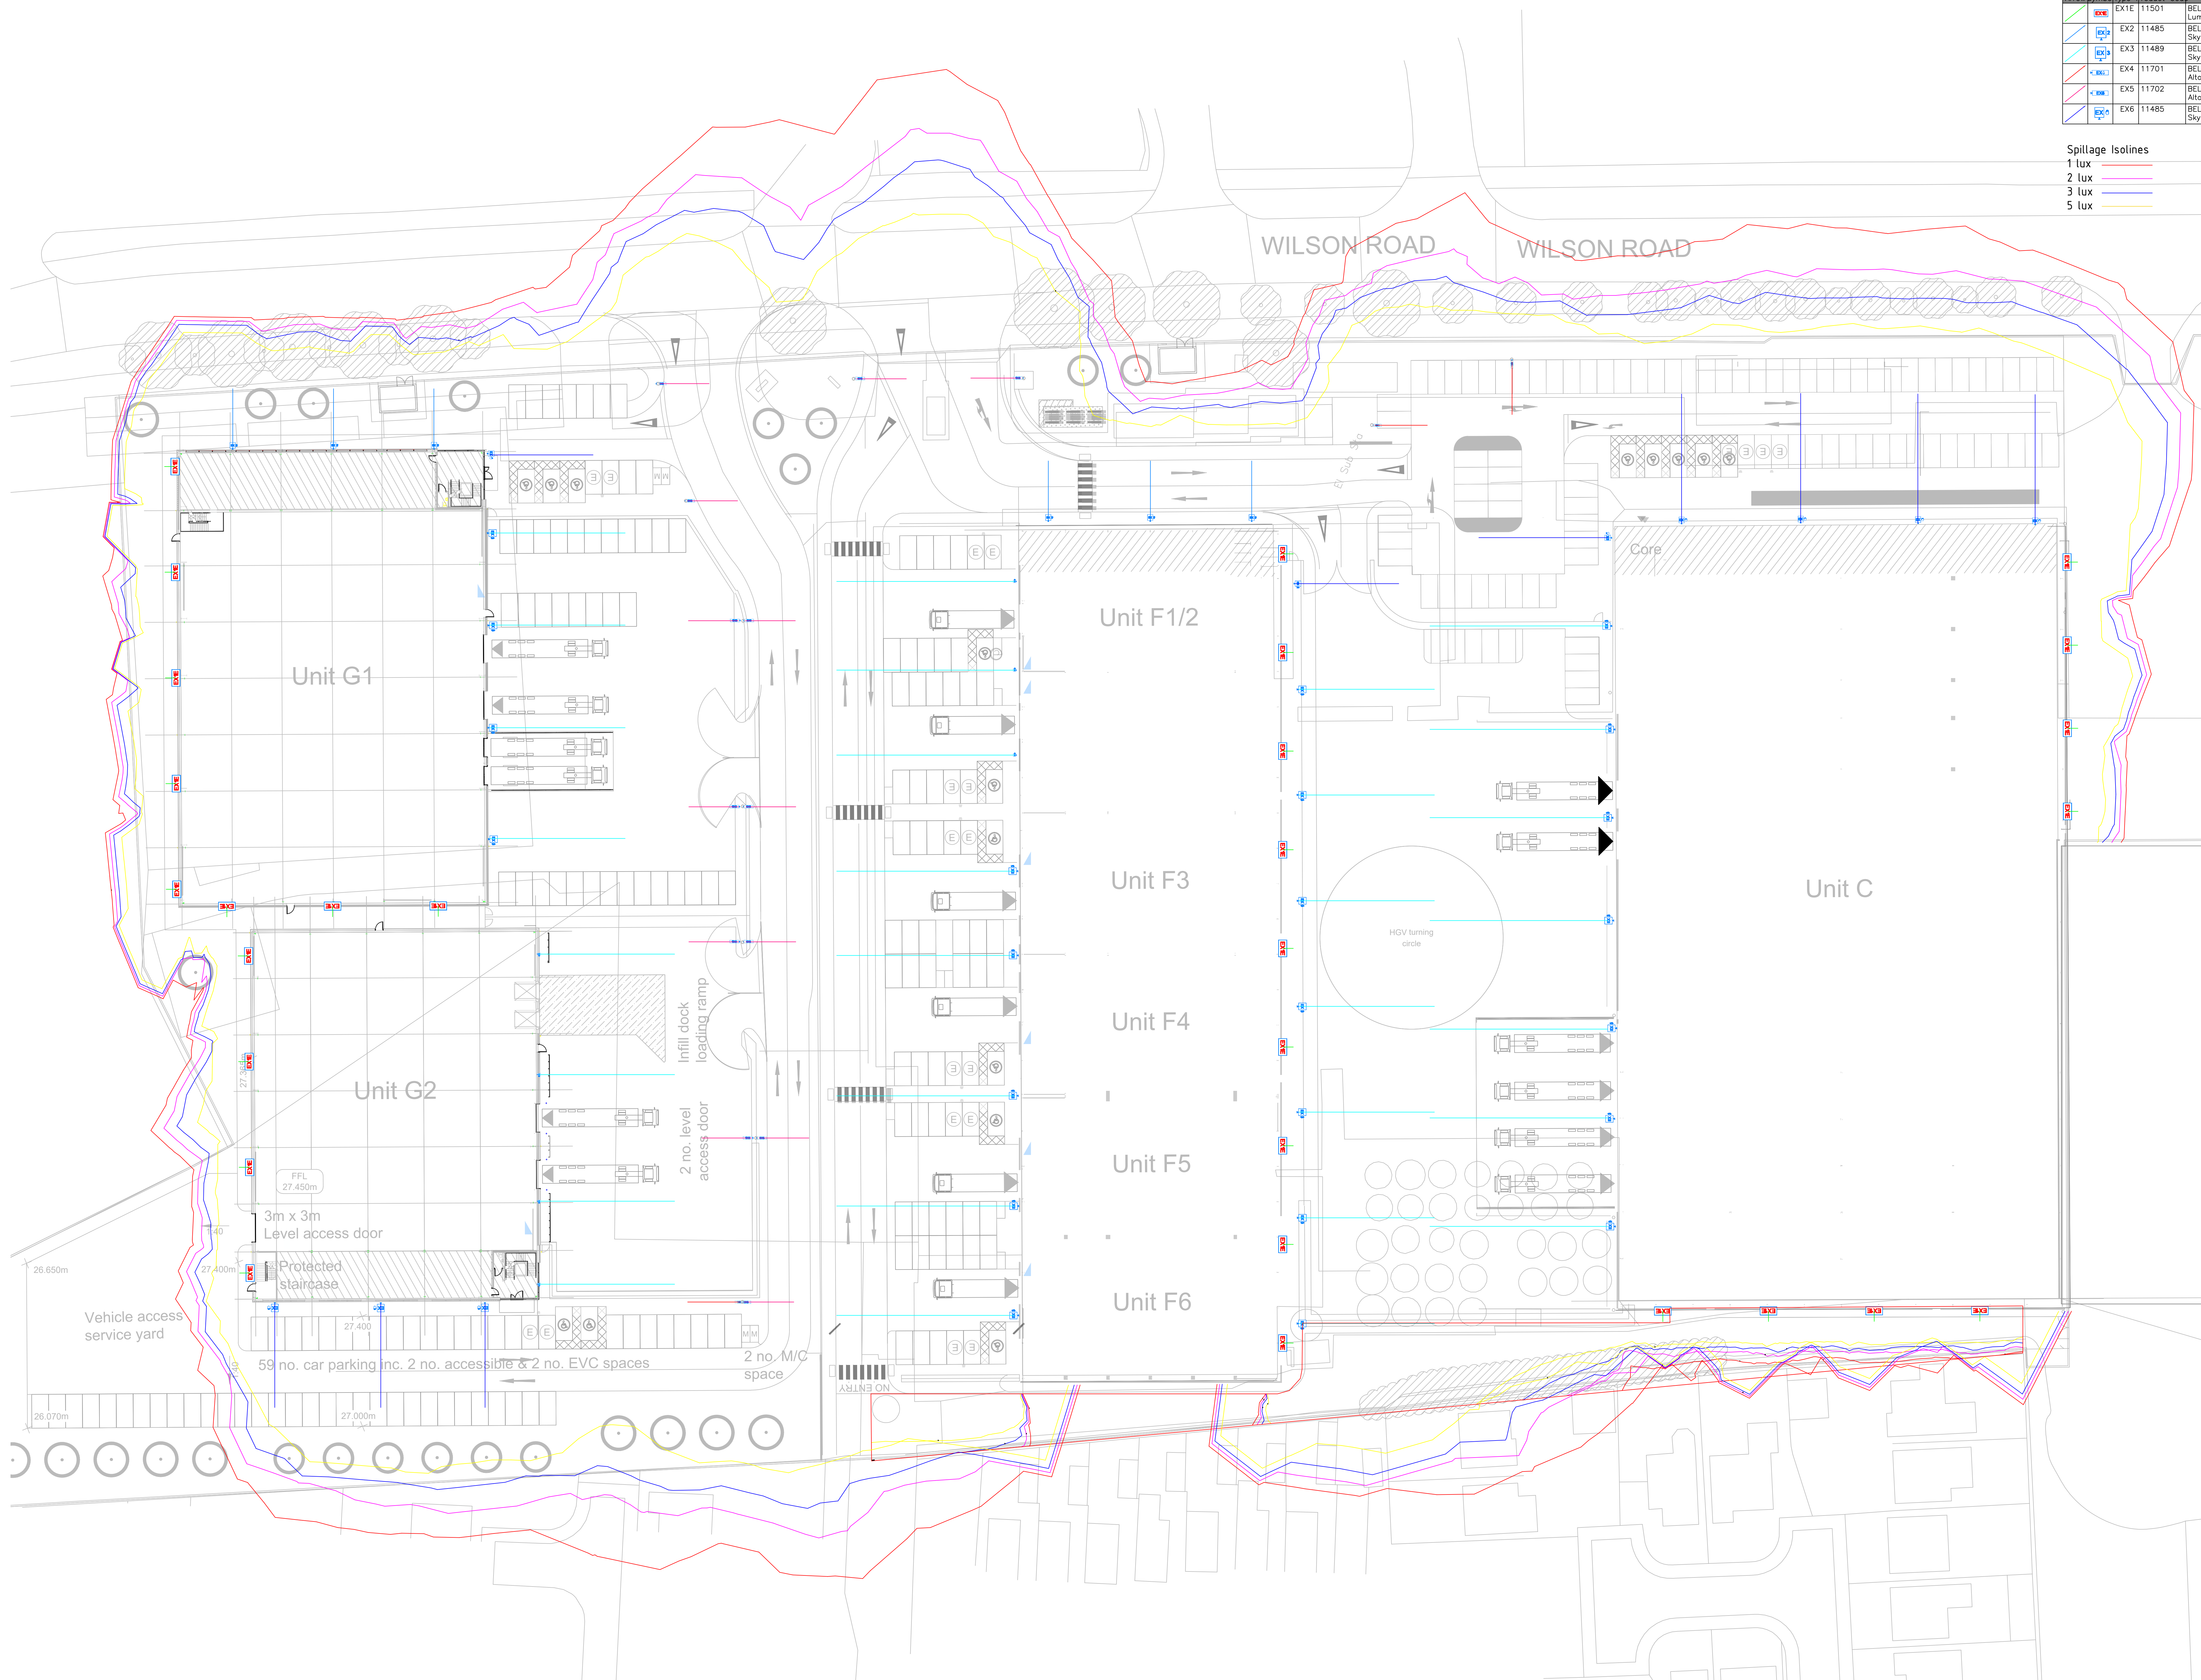

B	09:50:00	SITE PLAN UPDATED
A	09:50:00	CONTRACT INCORPORATED
	09:50:00	WPLB, S&P
REV.	DATE	AMENDMENT
		
WPL Consulting LLP 1 Alton Way Lancaster Way Leeds LS19 7ZA Tel: 0113 202 9444 Fax: 0113 202 9333 E-mail: mail@wplconsulting.co.uk		
PROJECT TITLE DAVOS PROPERTY DEVELOPMENTS LTD SOVEREIGN HUYTON LIVERPOOL		
DRAWING TITLE EXTERNAL LIGHTING LAYOUT ISOLINE PLOT		
PROJECT NO:	DRAWING NO:	REVISION:
10182	ME0001	B
SCALE:	DATE:	DRAWN BY:
1:300@A0	AUG 25	CP
CHECKED BY:		DATE: