


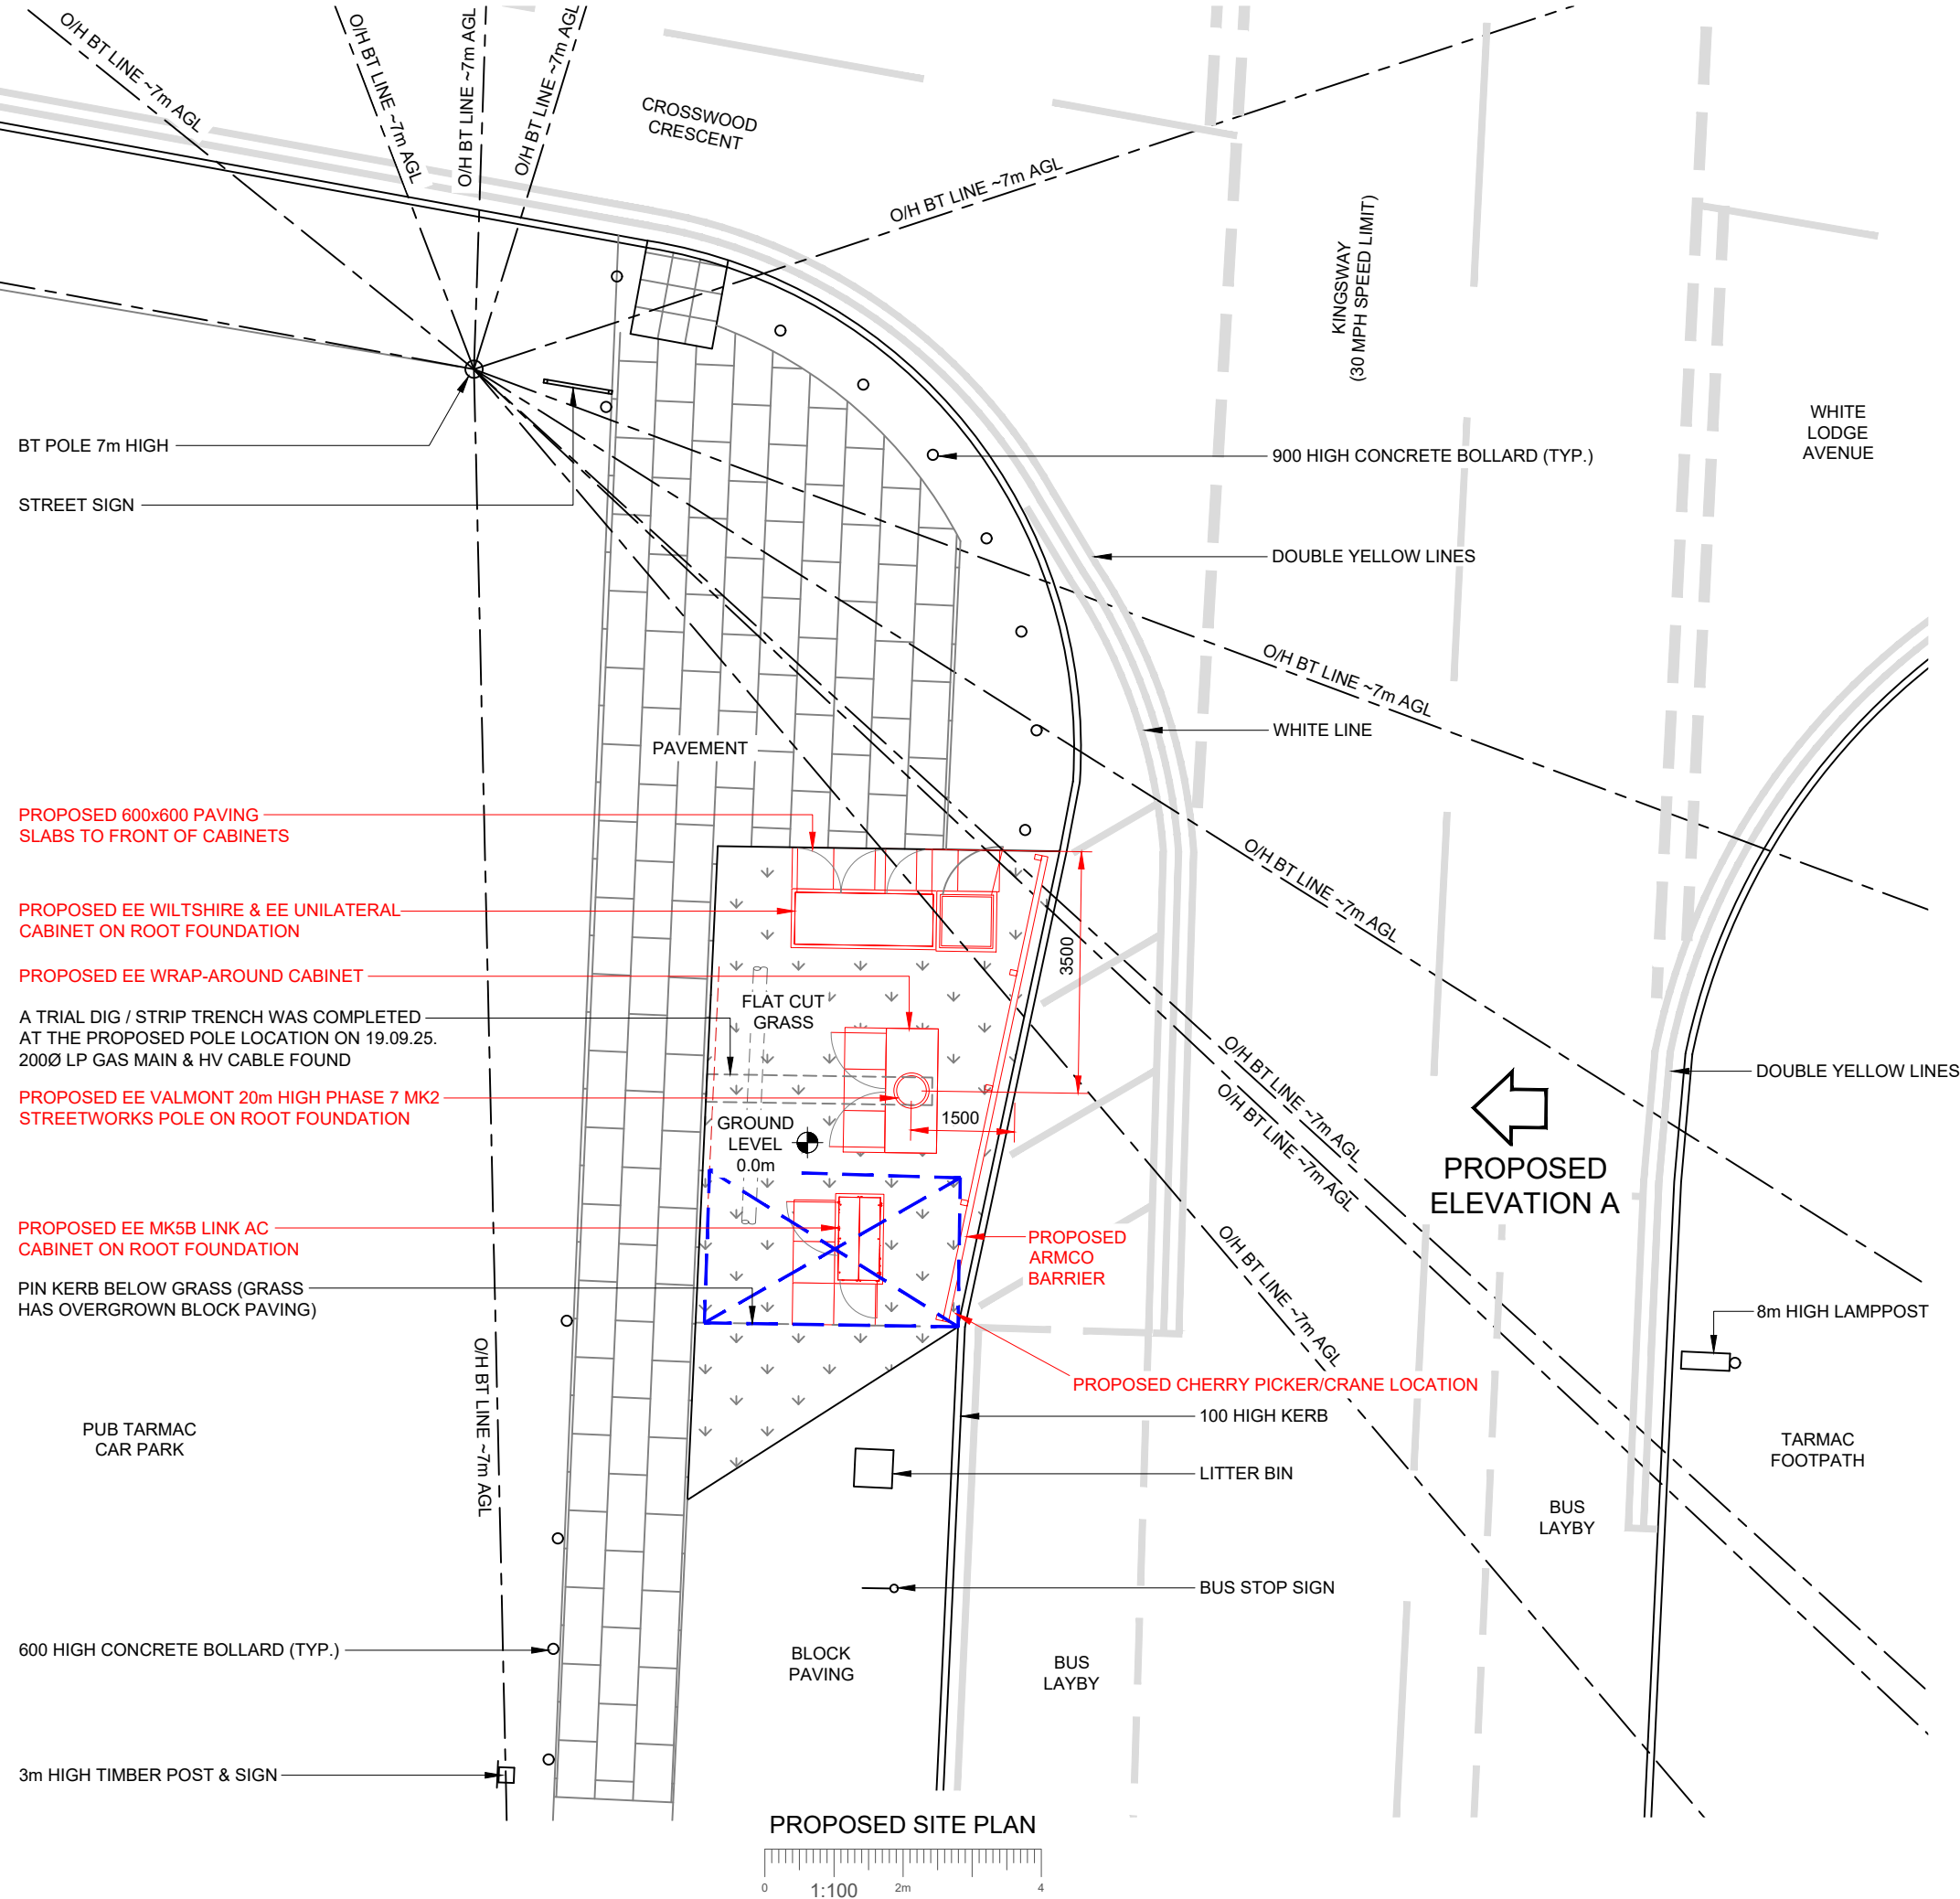

NOTES:			
1. ALL DIMENSIONS IN MM UNLESS OTHERWISE NOTED.			
Master: M001		Project: NTQ	Purpose of Issue: Planning
Date: 08/10/2025		Revision / Upgrade Description:	
Drawn: J. Boote		First Issue	
Checked: J. Stockdale			
Approved: G. Jennings			
 Hutchison 3G UK Limited Green Park, 450 Longwater Avenue Reading, RG30 3UR Tel: 01628 765 000 Fax: 01628 765 001 H3G Base Station Information line: 0845 6043000 Available 8am-8pm Monday to Friday		 Everything Everywhere One Statham Street London E1 8EE Tel: 020 7356 5000	
		Mobile Broadband Network Limited Sixth Floor, Thames Tower, Station Road, Reading, RG1 1LX	
Design Consultant & Principal Contractor:			
		WHP Telecoms Unit 1 Maple Park, Low Fields Avenue, Leeds LS12 6HH Tel: 01133023550 e-mail: info@whptelecoms.com	
Site Name:			
KINGSWAY			
Site ID:			
30002812			
Address:			
KINGSWAY, HUYTON, KNOWSLEY, MERSEYSIDE, L36 2PW			
Title:			
150 PROPOSED SITE PLAN			
Project:			
NTQ			
Purpose of Issue:			
GENERAL ARRANGEMENT			
EE Cell ID:	MBNL Cell ID:	H3G Cell ID:	
39793	KSY125	L2147	
File name:			
KSY125_39793_L2147_M001			