


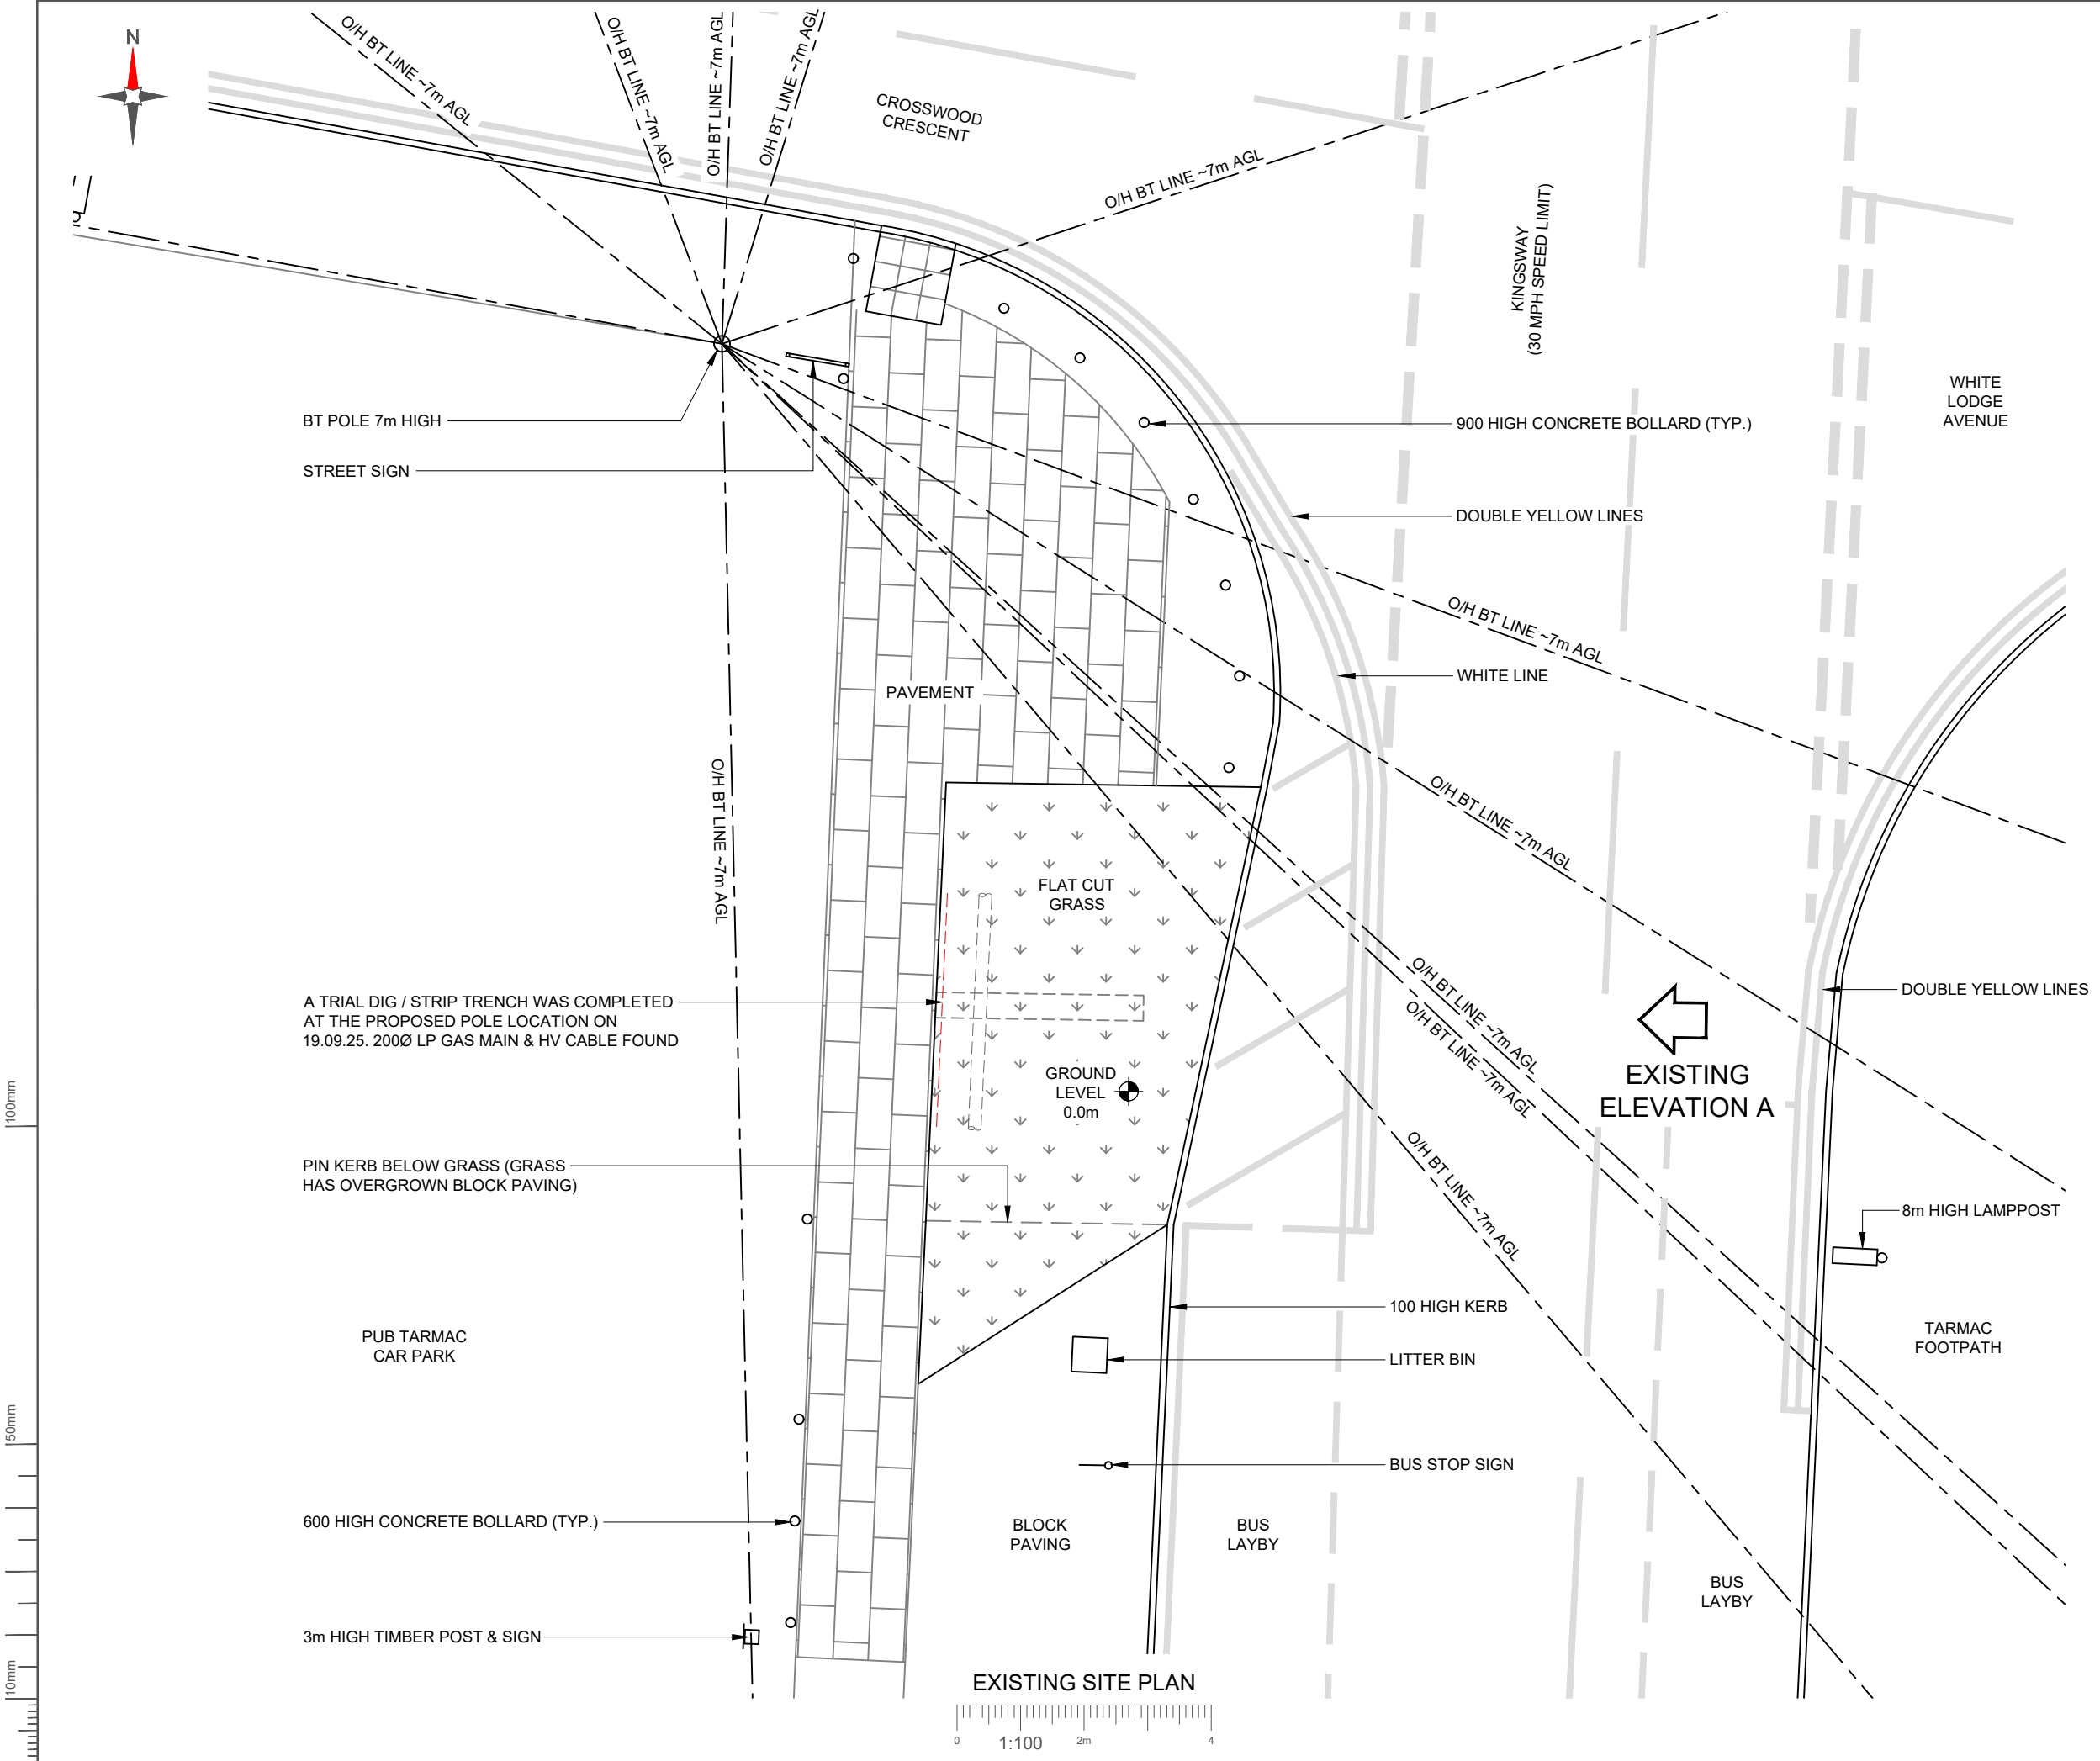

- NOTES:
- ALL DIMENSIONS IN MM UNLESS OTHERWISE NOTED.

Master:	M001	Project:	NTQ	Purpose of Issue:	Planning	Issue:	A
Date:	08/10/2025	Revision / Upgrade Description:					
Drawn:	J. Boote	First Issue					
Checked:	J. Stockdale						
Approved:	G. Jennings						



Hutchison 3G UK Limited
Green Park, 450 Longwater Avenue
Reading, RG30 3UR
Tel: 01628 765 000
Fax: 01628 765 001

H3G Base Station Information line:
0845 6043000
Available 8am-8pm Monday to Friday



Everything Everywhere
One Braham Street
London
E1 6EE

Tel: 020 7356 5000



Mobile Broadband Network Limited
Sixth Floor, Thames Tower, Station Road, Reading, RG1 1LX

Design Consultant & Principal Contractor:



WHP Telecoms
Unit 1 Maple Park,
Low Fields Avenue, Leeds
LS12 6HH

Tel: 01133023550
e-mail: info@whptelecoms.com

Site Name: **KINGSWAY**

Site ID: **30002812**

Address: **KINGSWAY,
HUYTON,
KNOWSLEY,
MERSEYSIDE,
L36 2PW**

Title: **100 EXISTING SITE PLAN**

Project: **NTQ**

Purpose of Issue: **GENERAL ARRANGEMENT**

EE Cell ID:	MBNL Cell ID:	H3G Cell ID:
39793	KSY125	L2147

File name: **KSY125_39793_L2147_M001**