


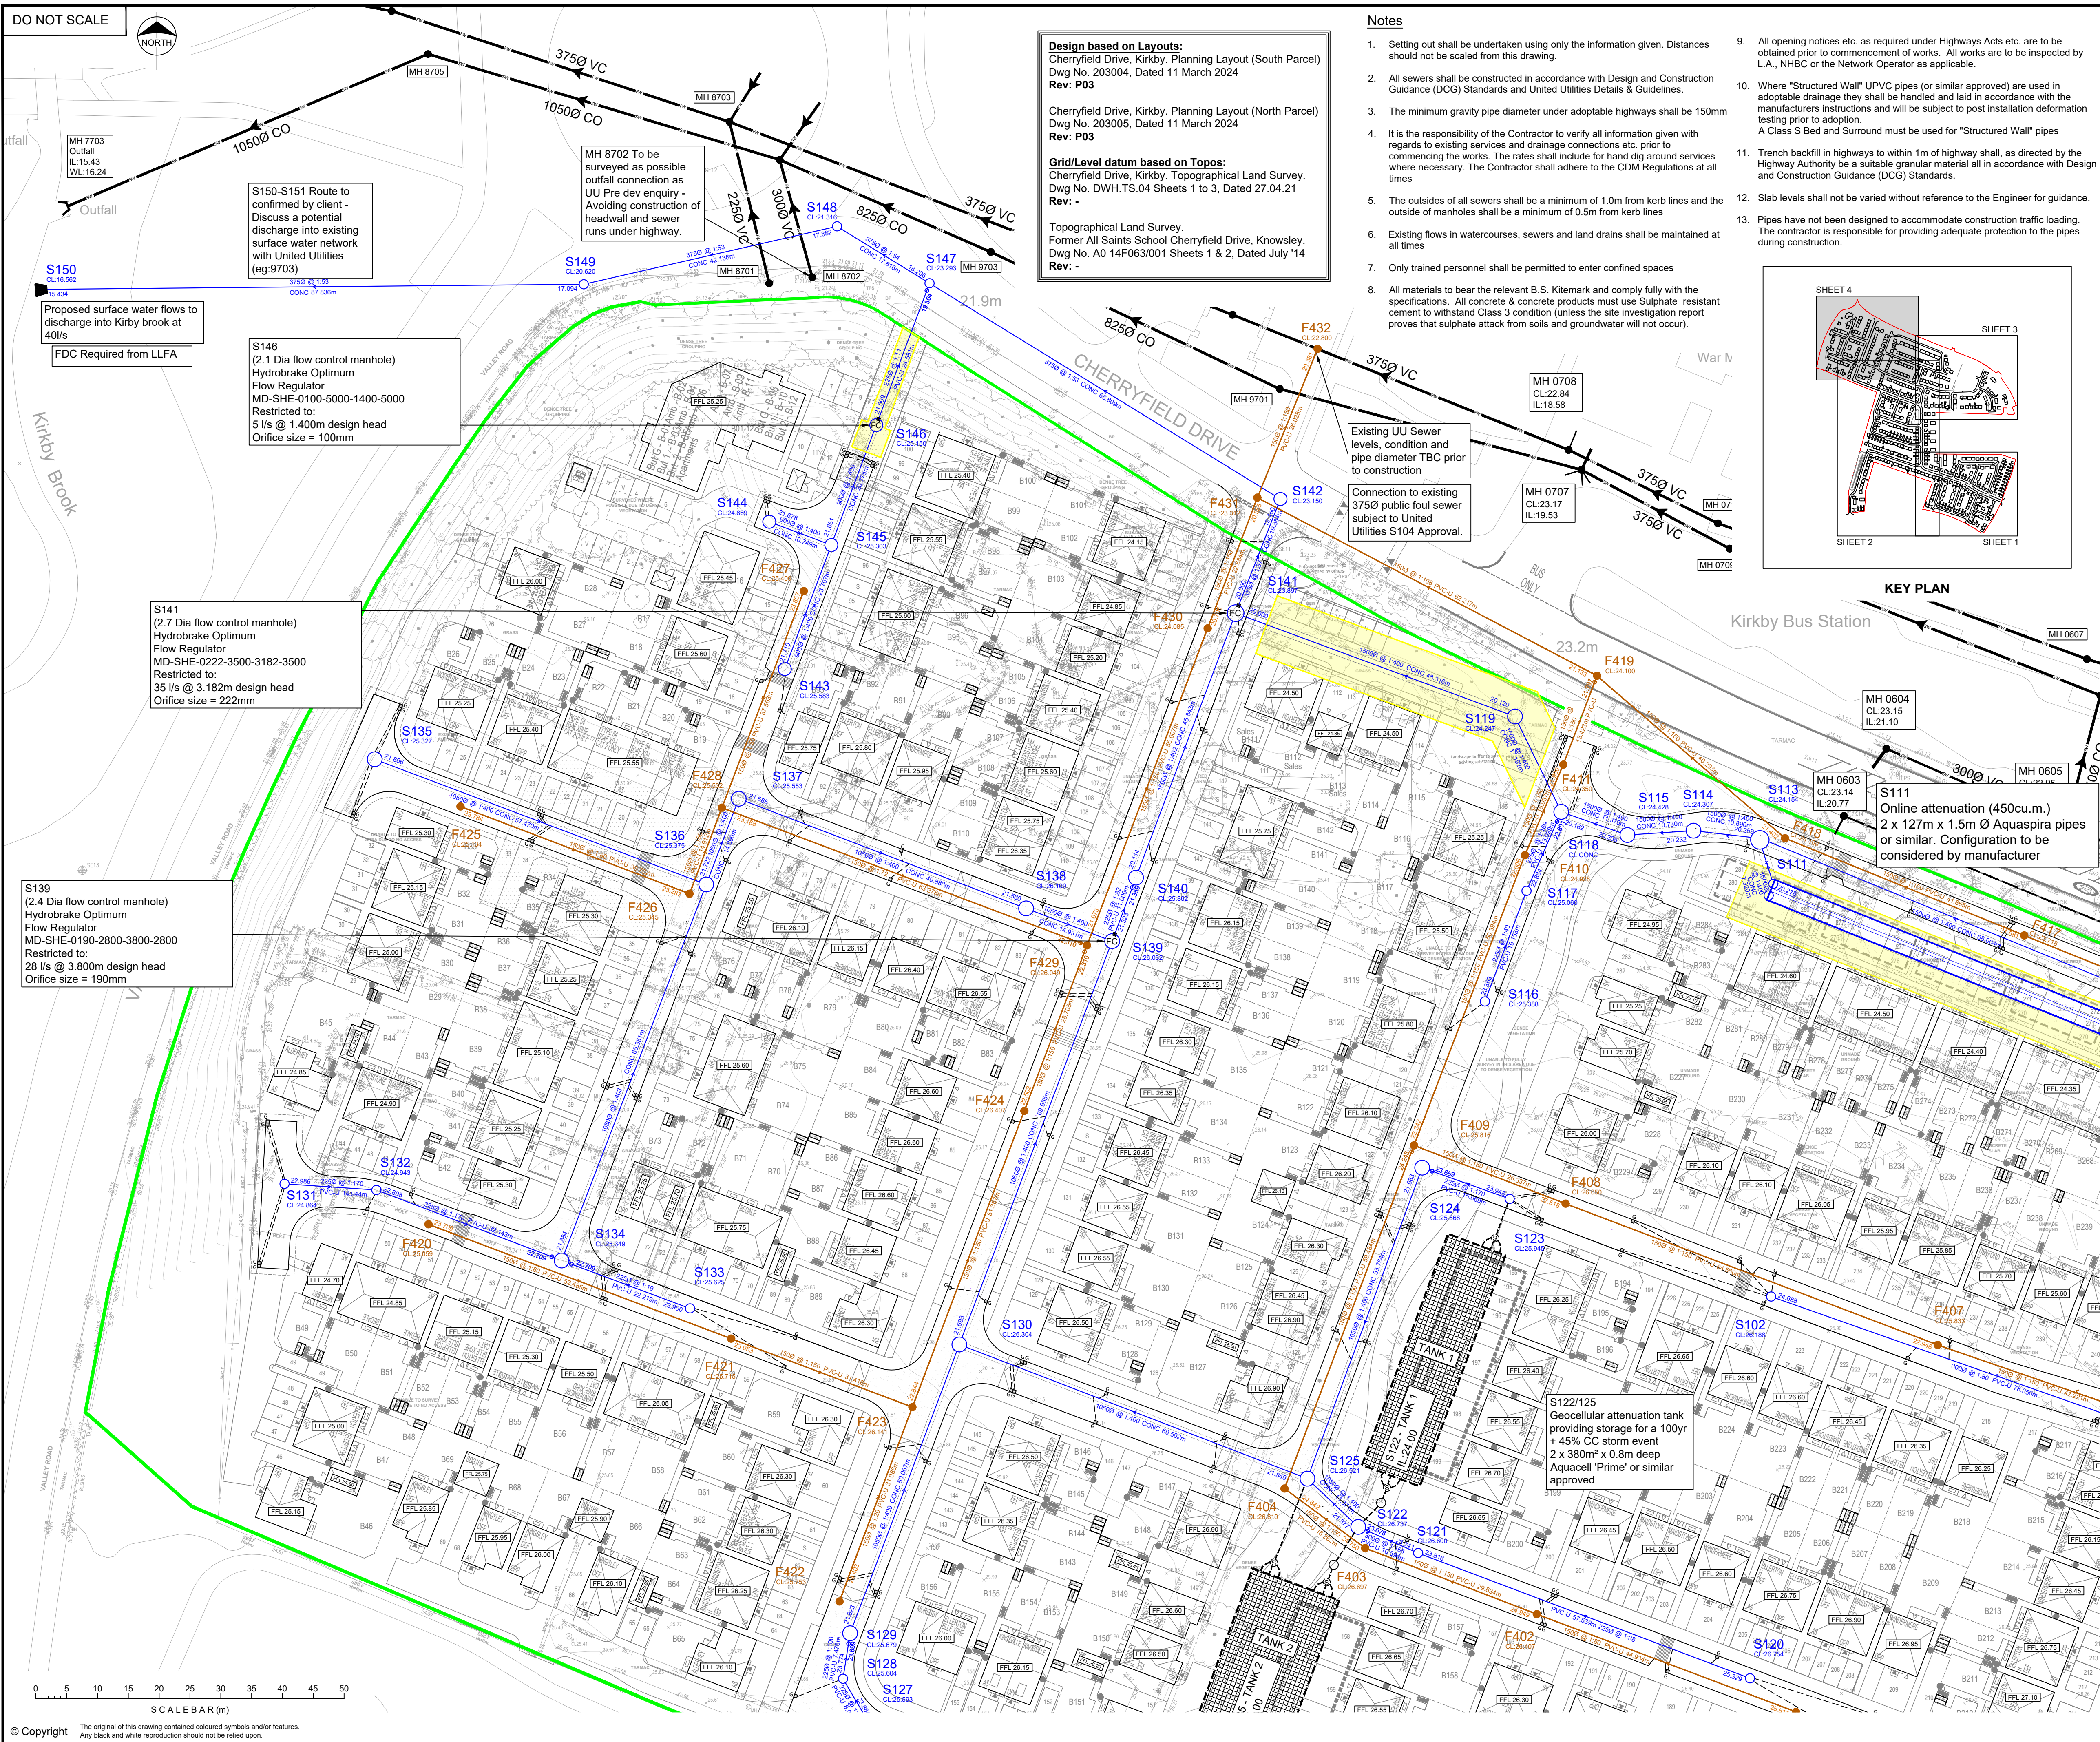

LEGEND

Existing

Existing Surface Water Sewer

Existing Foul Sewer

Proposed

Proposed Surface Water Sewer

Proposed Foul Water Sewer

Flow Control Manhole

Highway Gully

Easement

Proposed Slab Level

Adoptable SUDs Feature

Site Boundary

Offline attenuation
(Cellular crates)

TENDER

A	21.10.25	Updated to show latest Planning Layout	PJN	JAR
Rev.	Date	Revision	By	Appd.

coopers
chartered consulting engineers

Tel: 01244 684910
Email: admin@coopers.co.uk
Web: http://coopers.co.uk

Client

**BARRATT
HOMES**

BarraTT/David Wilson Homes
North West
303 Bridgewater Place
2nd Floor
Warrington
Cheshire
WA3 6XF
TEL: 01925 846600

Project

**CHERRYFIELD DRIVE,
KIRKBY.**

Title

**Proposed S104 Drainage Layout
Sheet 4 of 4**

DRAWING NUMBER	SCALE at A1	1:100
7778 / 01-4	DATE	28.04.25
	DRAWN	JAR
	CHECKED	AJ
	REVISION	A