
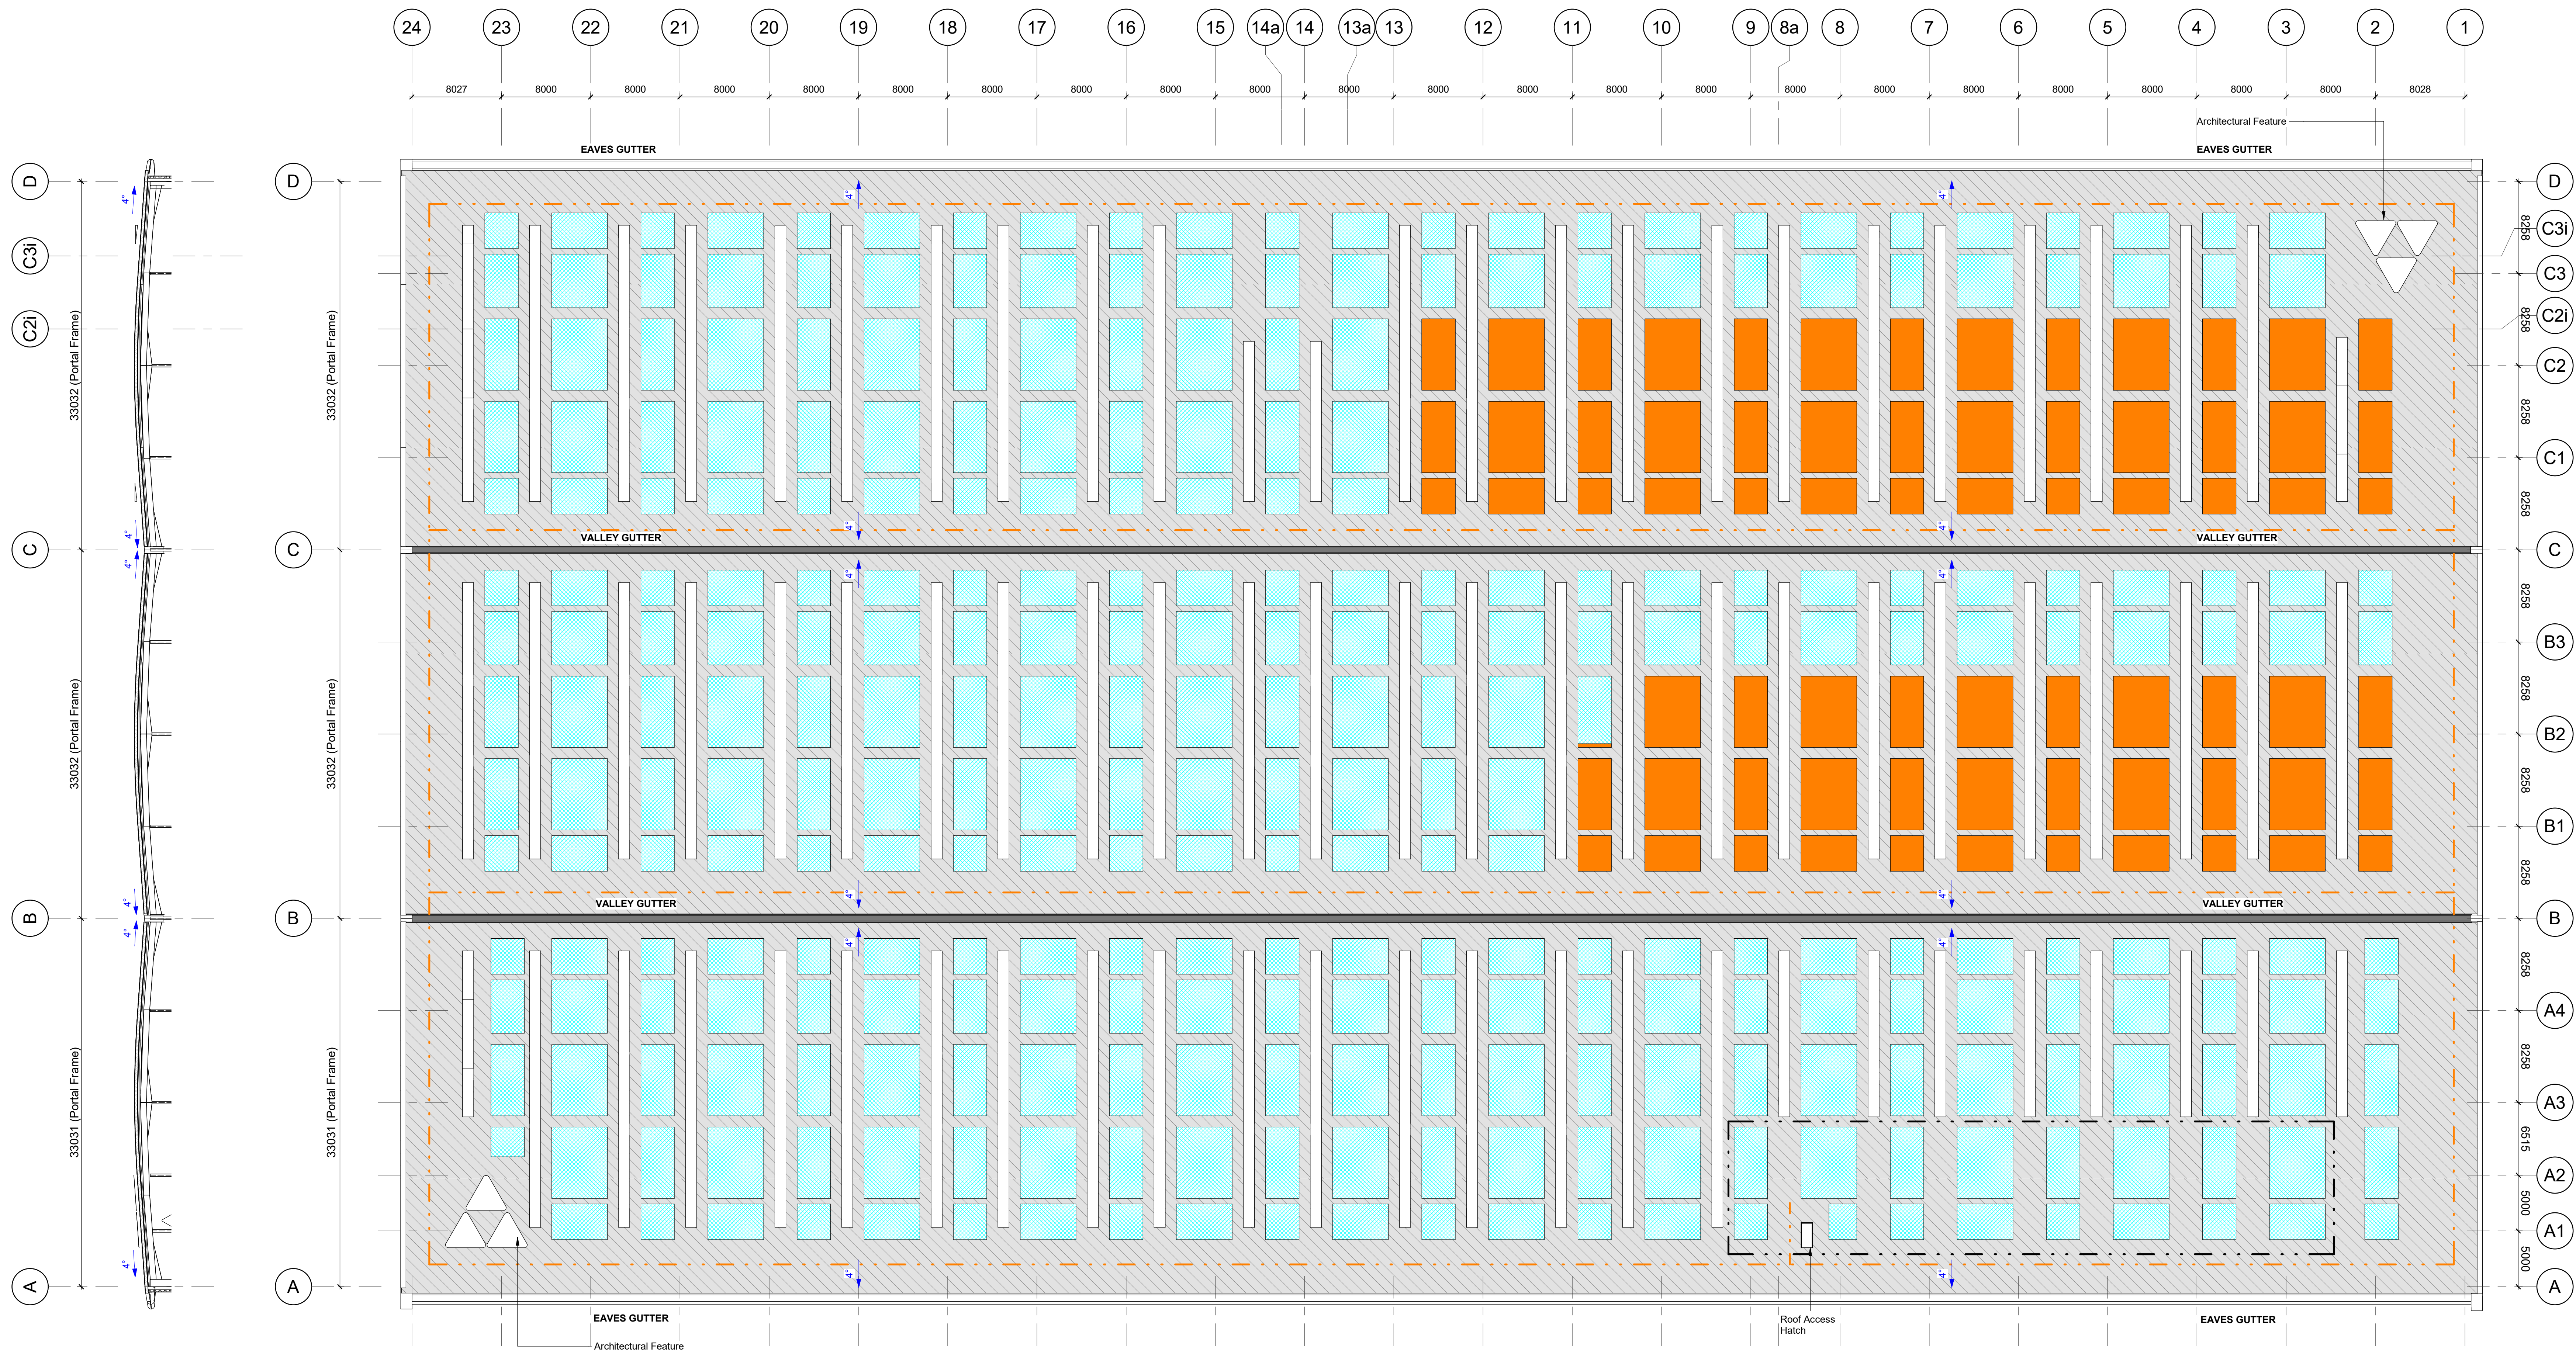


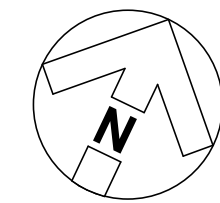

Roof Plan
1 : 250

- Key:**
- Roof lights to equate to 10% of internal floor area, layout shown indicatively.
 - Mansafe system to be Fall restraint to the Main office and Transport office. Layout shown is indicative only and subject to detailed design by main contractor specialist Sub-Contractor, but to provide safe roof access and maintenance to all roof area, including two sets of harnesses and lanyards to satisfy EN 795 and BS 7883.
 - Phase 1: Initial PV Output 263 kW AC
 - Phase 2: Future PV Output 1100 kW AC
- Note:**
- Solar PV Specialist layout out to be consider at a later date to provide an optimal arrangement to maximise the number of panels.
 - No rooflights are to be installed in the roof area directly above the main office accommodation or production area
- Disclaimer:** Full roof deployment will require an additional G99 application and is subject to DNO/NESO approval.

5m SCALE 1:250

rev | amendments | by | ckd | date

Unit 04, Symmetry Park,
Merseyside

Unit 04 Roof Plan

Information Container LOIN

LOD 2 LOI 2

TRITAX SYMMETRY
A TRITAX BIG BOX COMPANY

umc
architects

3rd Floor, Manchester Club, 81 King Street, Manchester, M2 4AH
144 (0)161 413 0599
info@umcarchitects.com

RIBA Plan Stage: 2 - Concept Design
Document Suitability: S2
Drawn / Checked: BMC / MY
Date: 06/11/23
Scale: As indicated @ A0
UMC Project Number: 22606

Document Reference: 22606-UMC-XXXX-RF-DR-A-1003
Drawing no: 1003
Revision: P06

PLANNING
THIS DRAWING IS A PRELIMINARY DESIGN AND SHOULD BE USED FOR ANY OTHER PURPOSE