


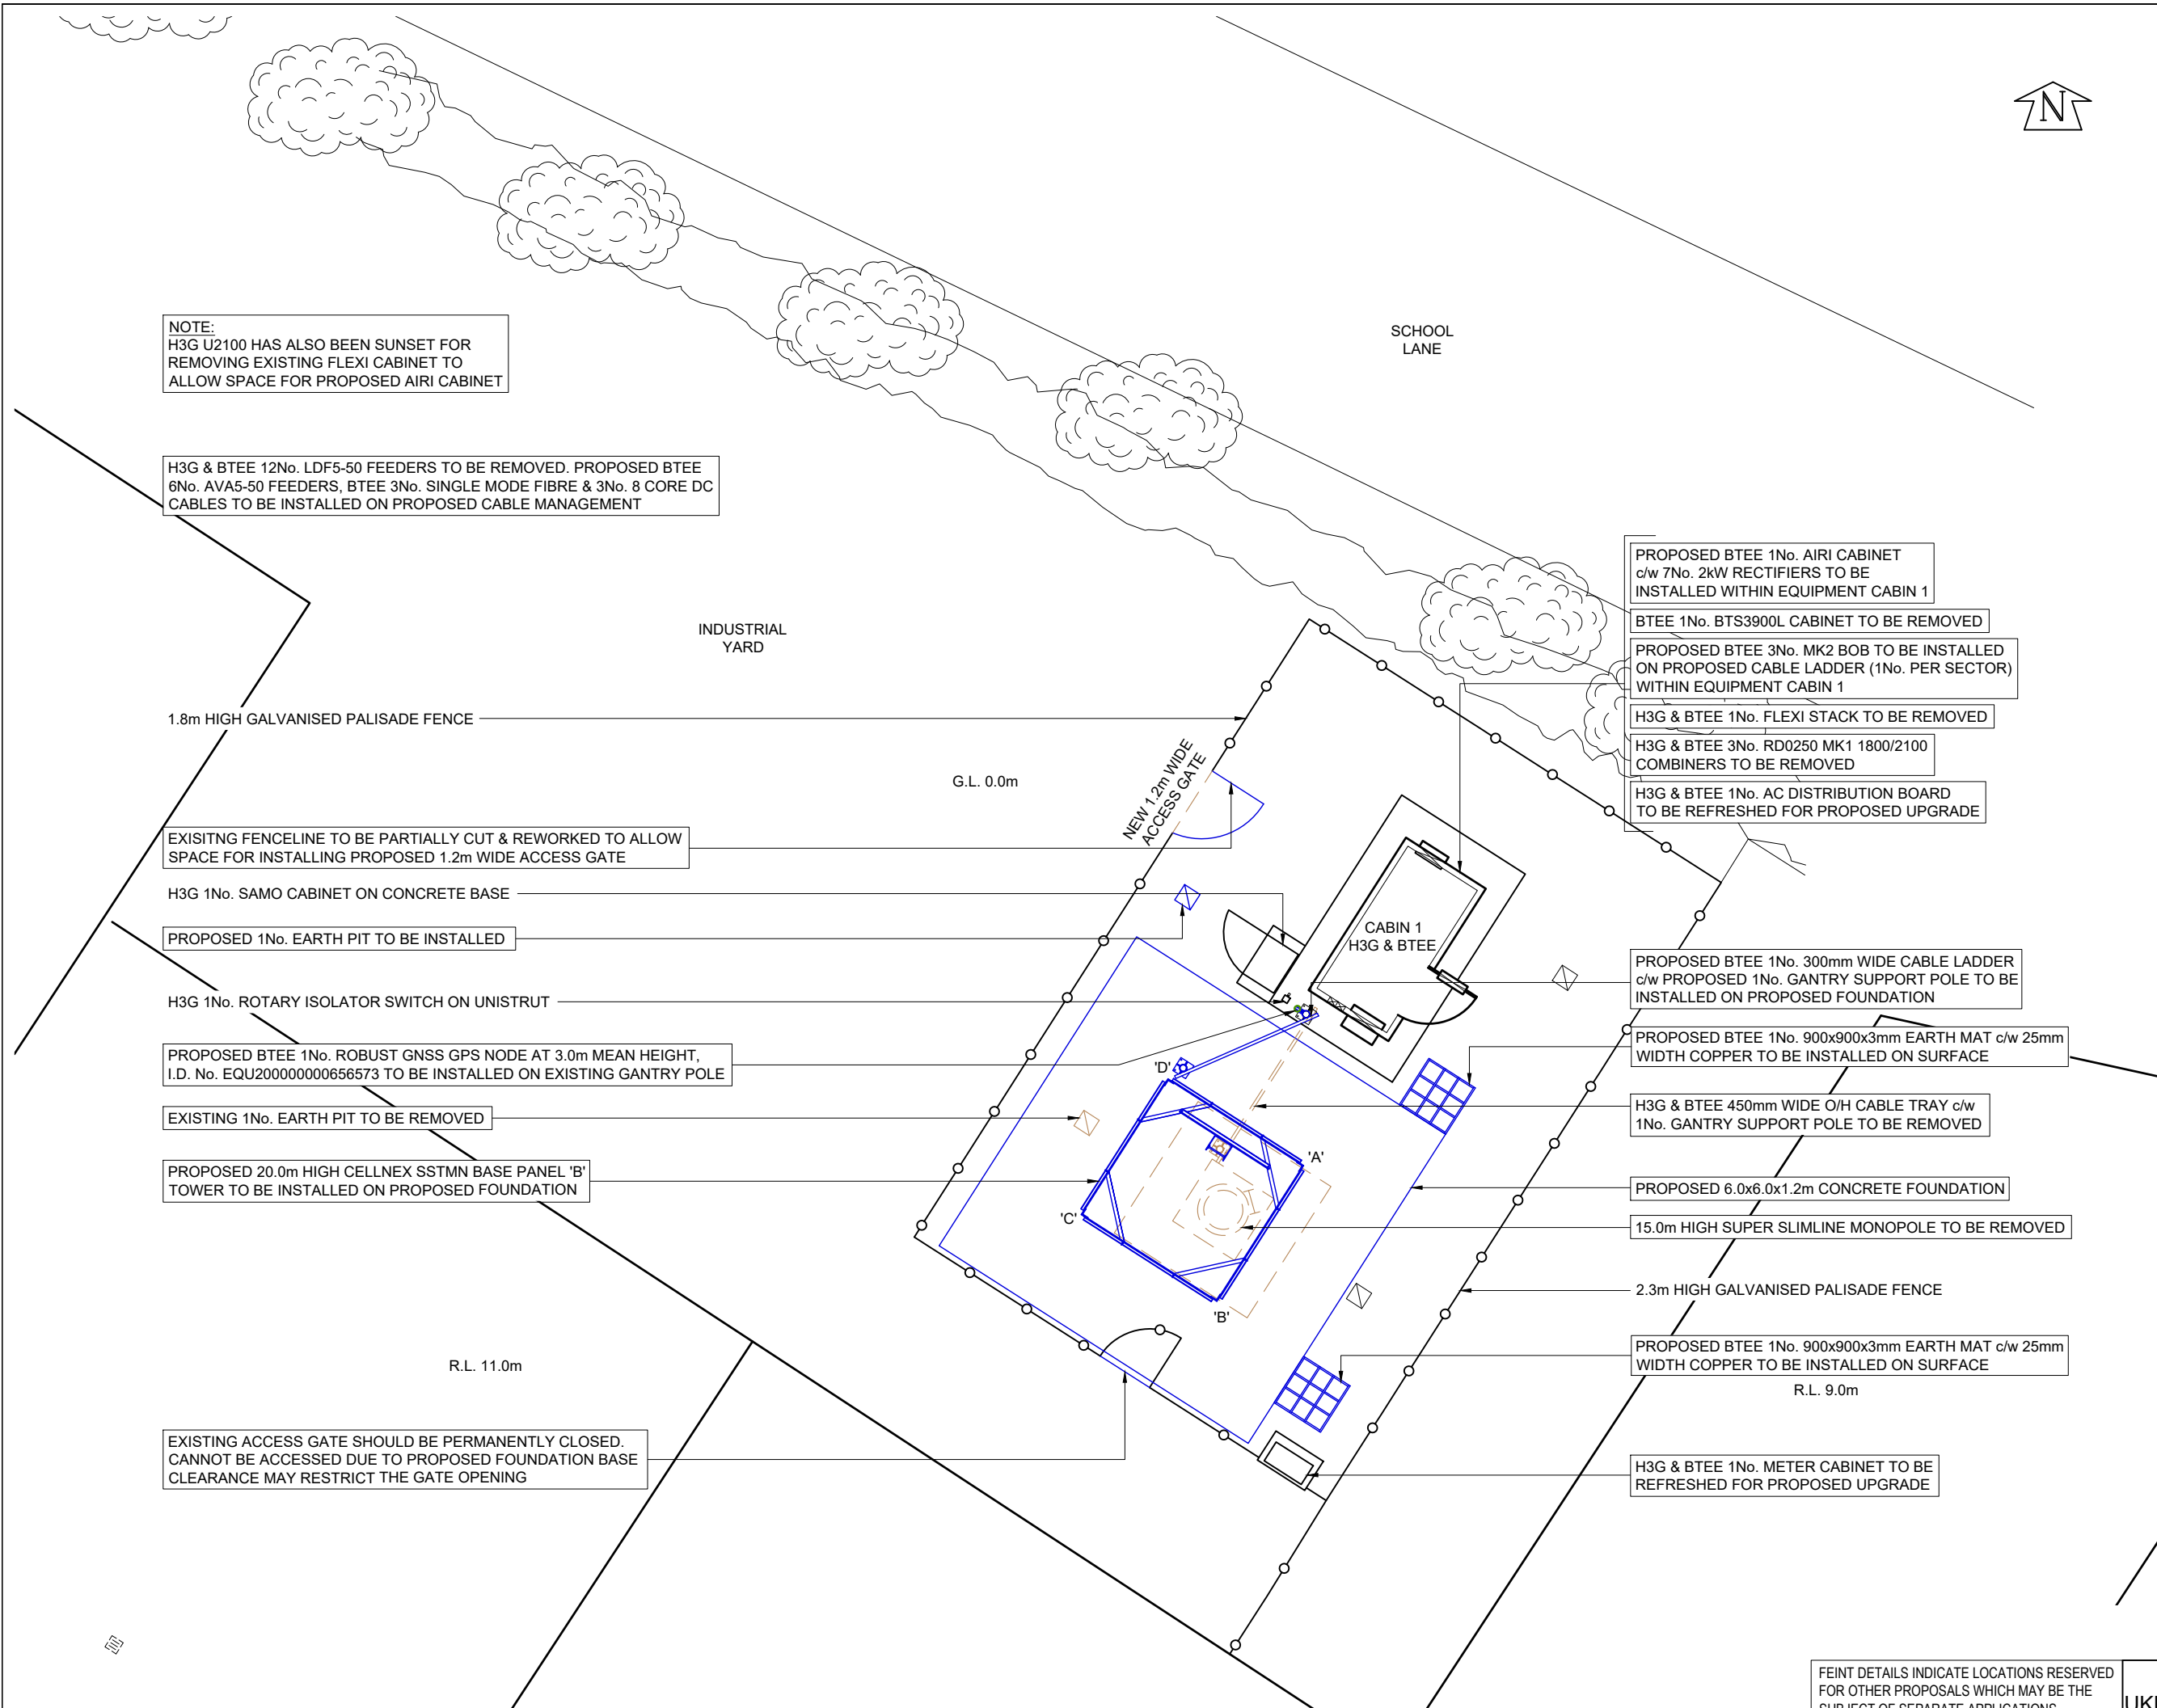

©2020 Cellnex
All rights reserved. No part of this publication may be reproduced, stored in a retrieval system or transmitted in any form or by any means (Electronic, Mechanical, Photocopying, Recording or otherwise), without the prior written consent of the Company.

NOTES

UNDERGROUND SERVICES
UNDERGROUND SERVICES ARE INDICATIVE ONLY. POSITIONS SHOULD BE CONFIRMED ON SITE PRIOR TO ANY DEVELOPMENT

DRAINAGE
DUCTS
FEEDERS
FENCE PLAN
GAS
LIGHTNING PROTECTION - EARTHING

POWER
SERVICES UNKNOWN
TELECOMS
WATER

ACCESS ARRANGEMENTS

KEYS:-

ARQVA GATE KEY

B KEY

C KEY

LEGGE KEY

SURVEY REQUIRED TO CONFIRM ACCESS KEYS FOR REMAINING ROOMS AND SITE ENTRANCE

PROJECT No.		COL.MOD.UK.0003509	
CELL No.		95555	
3	COL.MOD.UK.0003509 MINOR AMEND	03/10/25	HFC HFC
2	COL.MOD.UK.0003509 PLANNING ISSUE	23/09/25	HFC HFC
1	181684 CONVERSION	12/05/16	PS PS
0	0 O DRIVE MIGRATION	28/05/11	IM IM
ISS	REVISION	DATE	DRN APP

cellnex
driving telecom connectivity

CELLNEX UK
R+, 4TH FLOOR, 2 BLAGRAVE STREET, READING, RG1 1AZ
Tel. 020 4526 8553

SITE No

UK-MY-005554

J & L SUPPLIES

J & L SUPPLIES

11A CADDICK ROAD

SOUTH KNOWSLEY

MERSEYSIDE

L34 9HP

NGR

SJ 43066 96089

OS GRID

343066, 396089

TITLE

SITE PLAN

PROPOSED

BTEE LTD

SCALE

1:100

DRAWN

IM

28/05/11

APPROVED

HFC

03/10/25

DRG No.

Sheet 1 of 1

Rev

3

FEINT DETAILS INDICATE LOCATIONS RESERVED FOR OTHER PROPOSALS WHICH MAY BE THE SUBJECT OF SEPARATE APPLICATIONS

A3